THE CITY OF WILLOUGHBY LAKESHORE EAST EQUALIZATION BASIN PHASE II CITY OF WILLOUGHBY OFFICIALS: LAKE COUNTY, OHIO

MAYOR ROBERT FIALA SERVICE DIRECTOR **RICH PALMISANO** CHER HOFFMAN FINANCE DIRECTOR MIKE LUCAS LAW DIRECTOR

CITY OF EASTLAKE OFFICIALS:


MAYOR JIM OVERSTREET SERVICE DIRECTOR **ROBERT GORENTZ** FINANCE DIRECTOR CAROL-ANN SCHINDEL, CPA

CITY OF WILLOUGHBY COUNCIL:

WARD 1 WARD 2 KEN J. KARY JOHN TOMASELLI WARD 3 / VICE PRESIDENT WARD 4 / PRESIDENT OF COUNCIL ROBERT E. CARR WARD 5 MIKE L. MERHAR WARD 6 DANIEL J. GARRY COUNCIL AT LARGE DANIEL J. ANDERSON

CITY OF EASTLAKE COUNCIL:

WARD 1 / PRESIDENT OF COUNCIL JAMES OVERSTREET WARD 2 / VICE PRESIDENT JOHN MEYERS WARD 3 JASON KASUNICK WARD 4 DANYIELL KOSTELNIK COUNCIL AT LARGE ANGELA R. SCHMIDT COUNCIL AT LARGE CHRIS KRAJNYAK MICHAEL D. SEMICK COUNCIL AT LARGE

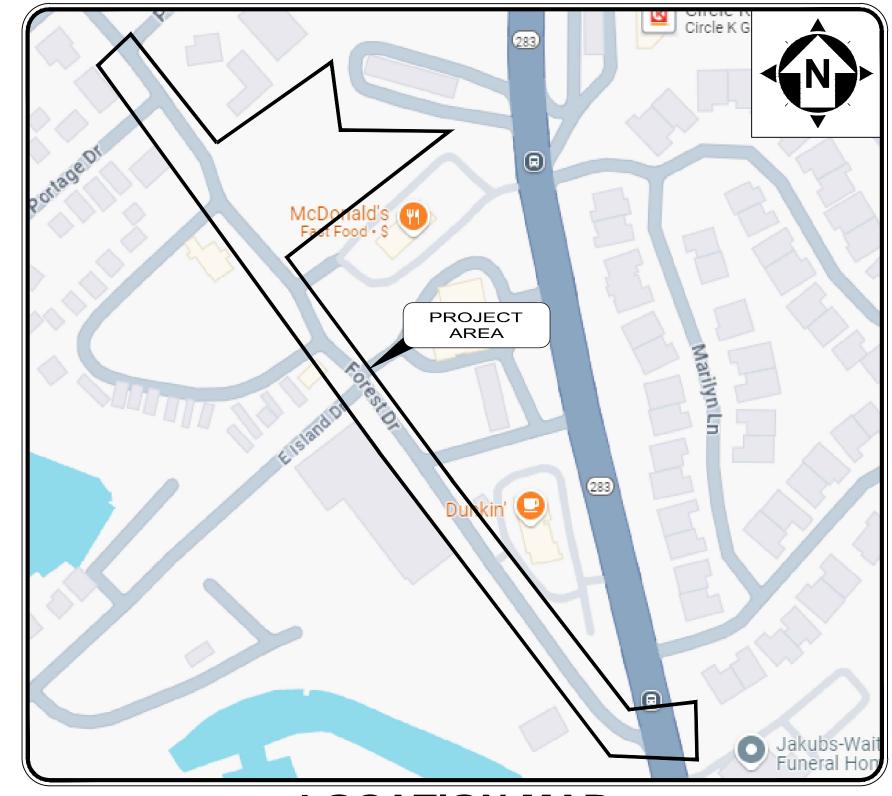

LOCATION MAP NOT TO SCALE

OCTOBER 2025



COUNTY

ENGINEER:

VERDANTAS, LLC 8150 STERLING COURT MENTOR, OHIO 44060

RYAN SCHUSTER, P.E.

verdantas

 UNDERGROUND BUILDING SERVICE UTILITY LINES ARE NOT SHOWN ON THE PLANS. THE CONTRACTOR SHALL BE RESPONSIBLE FOR LOCATING, MAINTAINING AND REPLACING AS NECESSARY TO ENSURE CONTINUAL SERVICE TO

2. THE CONTRACTOR IS RESPONSIBLE TO CALL OHIO UTILITIES PROTECTION SERVICE @ 1-800-362-2764, THREE WORKING DAYS PRIOR TO CONSTRUCTION.

ENGINEER'S PROJECT No.230264




P.E. No. 72755

10/3/2025 DATE

PROJECT NO.

230264 DISCIPLINE **GENERAL** SHEET NAME 00-G-01

64\DWG\SHEETS\PHASE II\G 230264 - COVERSHEET PHASE II.DWG - 1 COVER SHEET - 9/30/2025 1:01:56 PM - CORY SCOTT

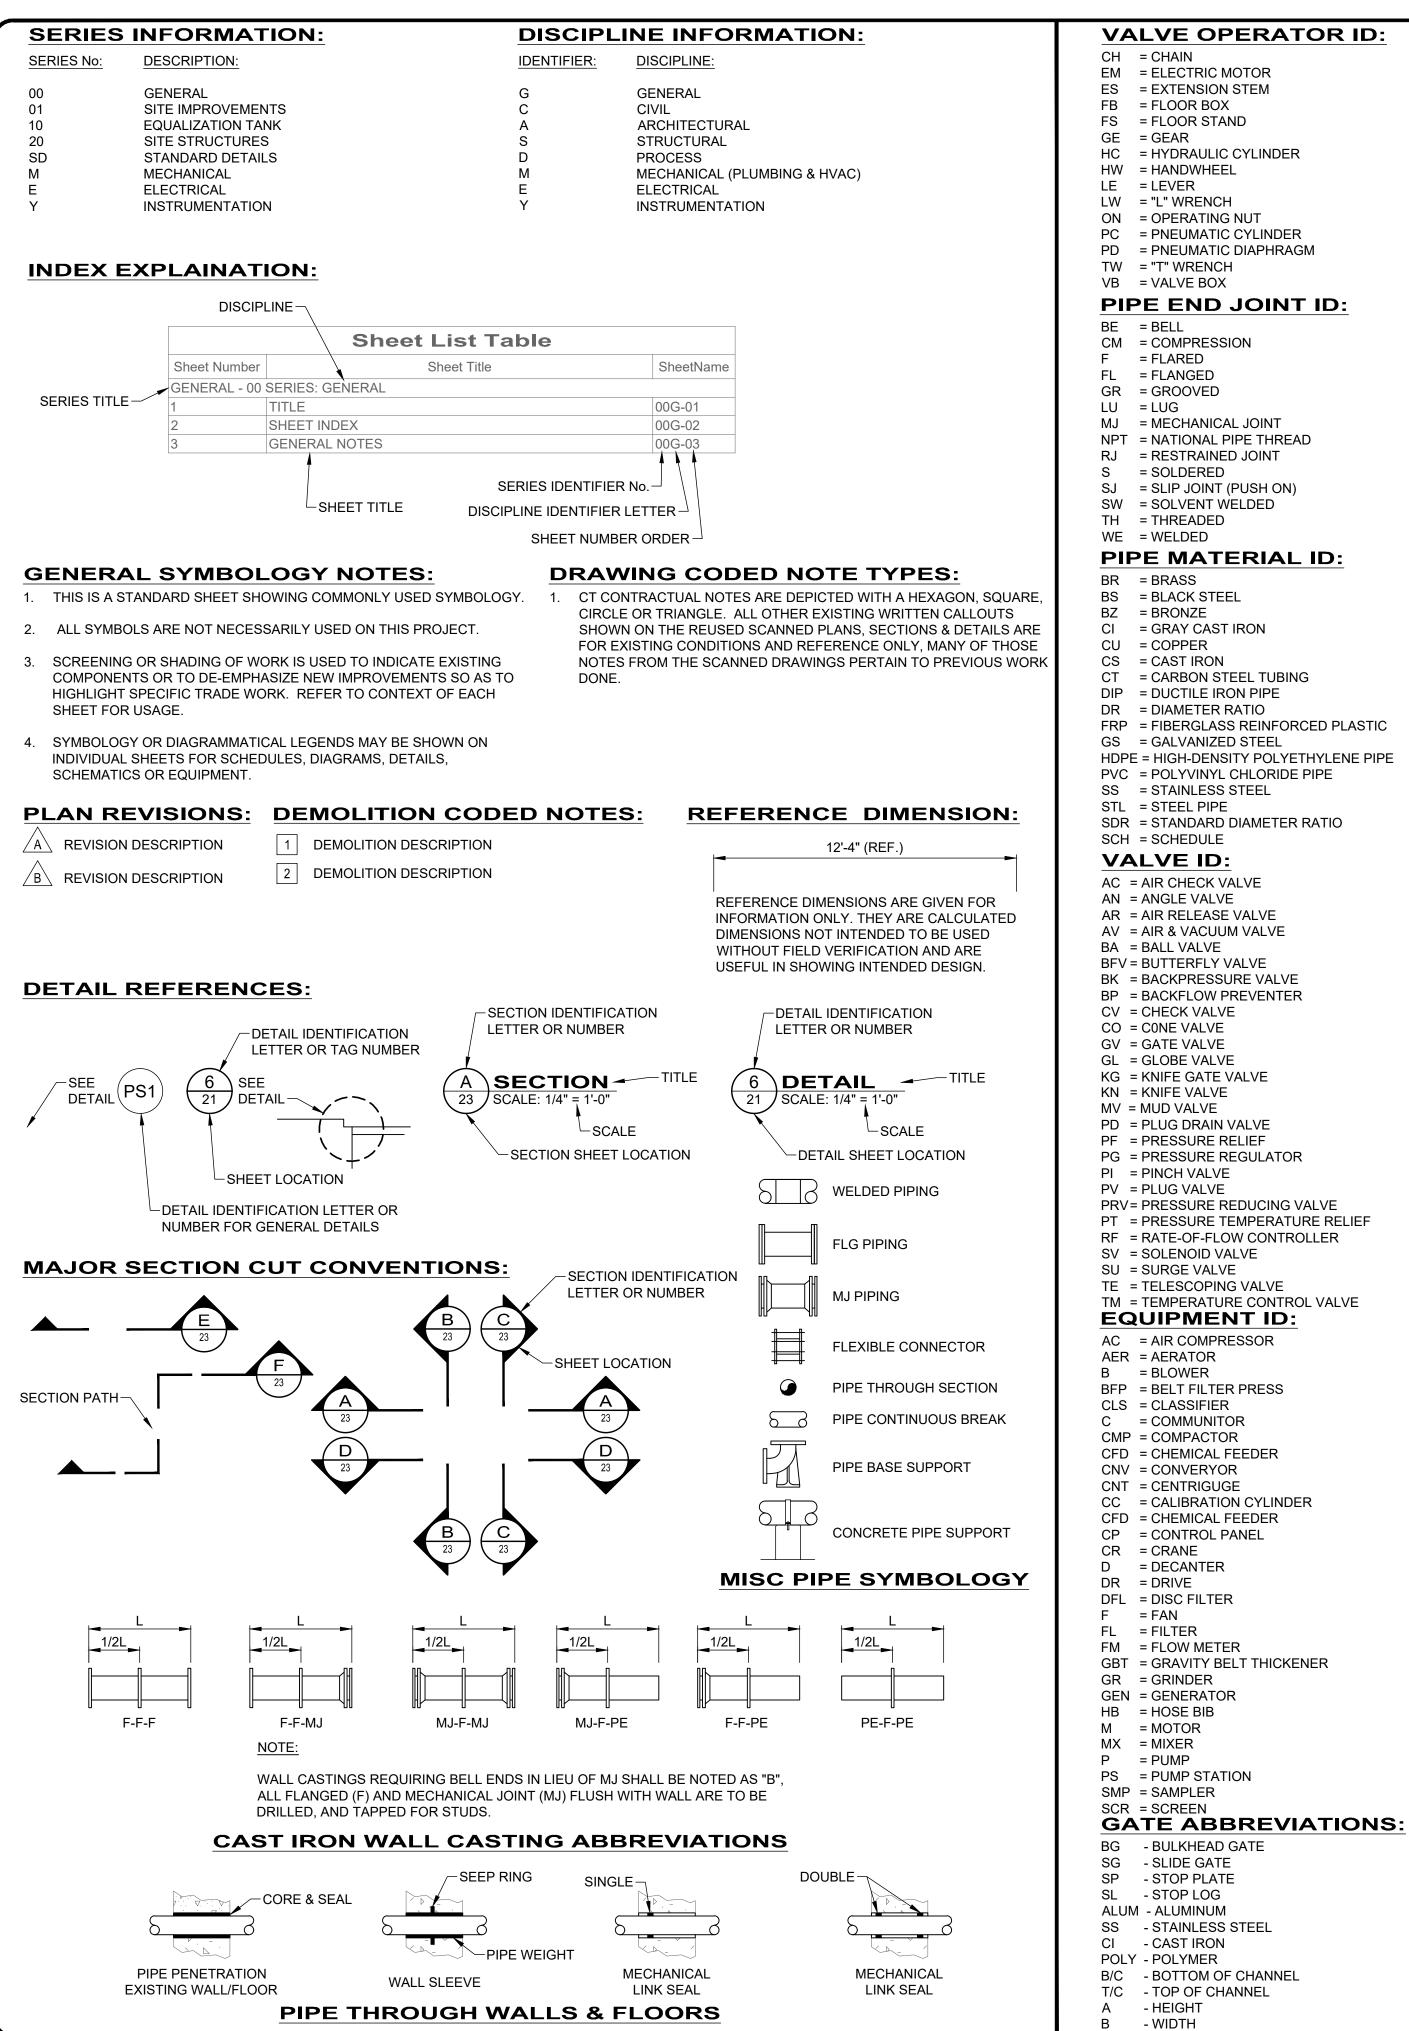

	SHEET LIST TABLE	
SHEET NUMBER	SHEET TITLE	SHEET DESCRIPTION
	GENERAL - 00 SERIES: GENERAL	
1	COVER SHEET	00-G-01
2	SHEET INDEX AND LEGENDS	00-G-02
3	SITE LEGEND	00-G-03
4	GENERAL NOTES	00-G-04
5	GENERAL NOTES	00-G-05
	SITE IMPROVEMENT - 01 SERIES: CIVIL	
6	EXISTING SITE PLAN	01-C-01
7	PROPOSED UTILITY PLAN	01-C-02
8	PROPOSED SITE PLAN	01-C-03
9	PROPOSED GRADING PLAN	01-C-04
10	FOREST DRIVE PAVING PLAN	01-C-05
11	16" FORCE MAIN PLAN & PROFILE STA 10+00 - 12+00	01-C-06
12	24" SANITARY SEWER TO EQ TANK PLAN & PROFILE	01-C-07
13	16" FORCE MAIN TO EQ TANK PLAN & PROFILE	01-C-08
14	4" WATER SERVICE LINE PLAN & PROFILE	01-C-09
15	LANDSCAPE PLAN	01-C-10
16	LANDSCAPE DETAIL	01-C-11
	EQUALIZATION BASIN - 10 SERIES: PROCESS	
17	EQ TANK PLAN & SECTION	10-D-01
18	EQ TANK DETAILS	10-D-02
19	EQ TANK DETAILS	10-D-03
20	EQ TANK DETAILS	10-D-04
20	SITE STRUCTURES - 20 SERIES: STRUCTURAL	10-D-04
21		20-S-01
	GENERAL NOTES	
22	GENERAL NOTES	20-S-02
23	GENERAL NOTES	20-S-03
24	STANDARD DETAILS	20-S-04
25	STANDARD DETAILS	20-S-05
26	VALVE VAULT	20-S-06
27	WET WELL	20-S-07
	SITE STRUCTURES - 20 SERIES: PROCESS	
28	WET WELL & VALVE VAULT DETAILS	20-D-01
29	CONTROL BUILDING PLAN & DETAILS	20-D-02
	SITE STRUCTURES - 20 SERIES: ARCHITECTURAL	
30	CONTROL BUILDING PLAN, ELEVATIONS & CODE DATA	20-A-01
	EROSION CONTROL - 30 SERIES: EROSION	
31	SWPPP COVER	30C-01
32	SWPPP NOTES AND CALCS	30C-02
33	SWPPP PLAN	30C-03
34	SWPPP FORMS	30C-04
35	SWPPP DETAILS	30C-05
36	SWPPP DETAILS	30C-06
	STANDARD DETAILS - SD SERIES: CIVIL	
37	STANDARD DETAILS	SD-C-01
38	STANDARD DETAILS	SD-C-02
39	STANDARD DETAILS	SD-C-03
	MECHANICAL - M SERIES: MECHANICAL	
40	CONTROL BLG MECH PLANS & SCHEDULES	M-01
41	MECHANICAL DETAILS	M-02
	ELECTRICAL - E SERIES: ELECTRICAL	
42	ELECTRICAL LEGEND & GENERAL NOTES	E-01
43	SINGLELINE DIAGRAM & SCHEDULES	E-02
44	ELECTRICAL SITE PLAN	E-03
45	CONTROL BUILDING ELECTRICAL PLAN	E-04
46	SITE STRUCTURES ELECTRICAL PLANS & DETAILS	E-05
47	EQ TANK ELECTRICAL PLANS & DETAILS	E-06
48	STANDARD ELECTRICAL DETAILS	E-07



URT 60

8150 STERLING COURT MENTOR, OHIO 44060

	ISSUE DATE: 10/3/2025	SCALE: N/A	DESIGNED BY: CAS	DRAWN BY: CAS	CHECKED BY: RSS
	LAKESHORE EAST EO BASIN		LAKE COUNTY	GENERAL - 00 SERIES	SHEET INDEX AND LEGENDS
		PROJE 230 DISCII	26		
	GE	SHEET	ER	AL	
,	O	0-0		2	
	2		•	48	

EXISTING SYMB	OI S
SANITARY MANHOLE SANITARY CLEANOUT	(<u>S</u>)
SANITARY CLEANOUT SANITARY LINE CAP	1
SANITARY LINE PAINT MARKING	SAN
SANITARY STRUCTURE NUMBER	(00)
SANITARY VENT PIPE	8
STORM MANHOLE (SOLID LID)	(D)
STORM MANHOLE (OPEN GRATE)	
CURB INLET	
CURB INLET (DOUBLE)	ДЕ
CATCH BASIN	
CATCH BASIN (ROUND LID)	6
CATCH BASIN (DOME)	E3
CATCH BASIN (SIDE INLET)	F7
DRAIN	a
DOWNSPOUT	
STORM CLEANOUT	0
STORM LINE CAP	
STORM ENDWALL	
STORM HEADWALL	
STORM LINE PAINT MARKING	STM
	(20)
STORM STRUCTURE NUMBER	(00)
ROCK CHANNEL PROTECTION	
SURFACE DRAINAGE FLOW	r.J.
STORM FLOOD ROUTING ARROW	L _{1/}
FIRE HYDRANT	<u> </u>
WATER SIAMESE CONNECTION	Q
WATER VALVE	8
WATER VALVE BOX	<u></u>
WATER METER	
WATER METER PIT	
WATER LINE REDUCER	[>>
WATER LINE CAP	I
WATER LINE PLUG	
WATER WELL	III.T
WATER LINE PAINT MARKING	WAT
WATER LINE MARKER	
POST INDICATOR VALVE	(PV)
WATER MANHOLE	(Ŵ)
WATER CORPORATION STOP	
WATER FLUSHING ASSEMBLY	∞
WATER FIXTURE	WE
WATER FITTING (TEE)	ŀ
WATER FITTING (CROSS)	H
WATER FITTING (45° WYE)	4
WATER FITTING (11.25°)	Н
WATER FITTING (22.50°)	4
WATER FITTING (45°)	4
WATER FITTING (90°)	7
IRRIGATION SPRINKLER HEAD	(g)
IRRIGATION CONTROL BOX	
IRRIGATION BOX	[RR]
STEAM MANHOLE	(SM)
STEAM VENT COMBINED SEWER MANHOLE	(€M)
	- <u>-</u> -
GAS LIGHT POST (YARD) CAS MANHOLE	
CAS VALVE	(G)
GAS VALVE	(g)
GAS VALVE BOX	₩ * *
GAS	
GAS METER	<u> </u>
GAS REGULATOR	[GR]
GAS VENT PIPE	(V)
GAS LINE MARKER	GAS
GAS LINE PAINT MARKING	GAS ×
GAS LINE FIXTURE	GE
GAS	GTB.
ELECTRIC LIGHT POST (YARD)	-1
ELECTRIC MANHOLE	(Ē)
ELECTRIC PULL BOX	PB
ELECTRIC CONTROL BOX	[C7]
ELECTRIC JUNCTION BOX	<i>[CT</i>]
ELECTRIC VAULT BOX	VLT
ELECTRIC METER	EM
ELECTRIC PEDESTAL	E
ELECTRIC RISER BOX	EB
ELECTRIC TRANSFORMER	TR
ELECTRIC HVAC UNIT	[AG]
	·
ELECTRIC GROUND LIGHT	ELE XX
ELECTRIC GROUND LIGHT ELECTRIC LINE PAINT MARKING	
ELECTRIC LINE PAINT MARKING CABLE TV MANHOLE	(Ĉ)
ELECTRIC LINE PAINT MARKING CABLE TV MANHOLE CABLE TV PEDESTAL	(C)
ELECTRIC LINE PAINT MARKING CABLE TV MANHOLE	(Ĉ)

EXISTING SYMBO	OLS
TELEPHONE MANHOLE	(T)
TELEPHONE PULL BOX	PB
TELEPHONE PEDESTAL	<u> </u>
TELEPHONE RISER BOX TELEPHONE LINE PAINT MARKING	
TELEPHONE PAY PHONE	
FIBER OPTIC CABLE MANHOLE	É
FIBER OPTIC CABLE PAINT MARKING	F0C
FIBER OPTIC CABLE MARKER	(R)
TRAFFIC CONTROL MANHOLE TRAFFIC CONTROL BOX	
TRAFFIC CONTROL PAINT MARKING	
TRAFFIC PULL BOX	PB
TRAFFIC SIGNAL PEDESTAL	TRP
UNKNOWN, PULL BOX	PB .
UNKNOWN, CLEANOUT UNKNOWN, MANHOLE	(Û)
UNKNOWN, VALVE	<u>(ල</u>) හි
UNKNOWN, PEDESTAL	
UNKNOWN, UTILITY END NOT LOCATED	
MONITORING WELL	
TEST WELL WATER WELL	
SOIL BORING	<u> </u>
SWAMP	<u>*</u>
POLE, ELECTRIC	P
POLE, TELEPHONE	, t &
POLE, LIGHT	, ,
POLE, LIGHT, DECORATIVE	
POLE, LIGHT-OVERHEAD	
POLE, CABLE TV	C
POLE, UTILITY	<i>y</i>
	φ ,
POLE, GENERAL	P R
POLE, TRAFFIC CONTROL	Ç,
POLE, GUY	
POLE, BRACE	<u> </u>
POLE, ELECTRIC/TELEPHONE	¢ P
POLE, ELECTRIC W/LIGHT	2
POLE, ELECTRIC/CABLE TV	96.
POLE, ELECTRIC/TELEPHONE/LIGHT	0
POLE, ELECTRIC/TELEPHONE/CABLE TV	90
POLE, ELEC./TELE./LIGHT/CABLE TV	\$ \frac{1}{2}
POLE, TELEPHONE/LIGHT	7
POLE, TELEPHONE/CABLE TV	-19th
POLE, TELEPHONE/LIGHT/CABLE TV	(A)
POLE, CABLE TV W/LIGHT	() () () () () () () () () () () () () (
POLE, GUY WIRE	·
SIGN	-
SIGN, DOUBLE SIDED SIGN, DUAL POST	0 0
SIGN, RAILROAD	00
POST	0
BOLLARD	0
DELINEATOR POST	©
PARKING BUMPER BLOCK HANDICAP PARKING SYMBOL	<u></u>
HANDICAP PARKING SYMBOL HANDICAP PARKING SYMBOL	Ġ.
HANDICAP DETECTABLE WARNING	5000
MAILBOX	[MB]
PAPERBOX	PBI
PARKING METER	(P)
GRAVE HEADSTONE EX. BARBEQUE GRILL	(RIP)
VACUUM	- NAG
FUEL PUMP	FUEL
FLAG POLE	F
RAISED PAVEMENT MARKER	. □
GUARDRAIL, CENTER POST	0
GUARDRAIL, TERMINAL POST GUARDRAIL, BOTTOM POST	· ·
GUARDRAIL, TOP POST	0
FENCE POST	٠
PICNIC TABLE	
BENCH TREE	
DECIDUOUS TREE EVERGREEN TREE	
STUMP	
RUSH	v- @

EXISTING SYME	3OLS
PVMT. MARKING, LANE ARROW	\triangleleft
PVMT. MARKING, LANE ARROW	5
PVMT. MARKING, LANE ARROW	
PVMT. MARKING, LANE ARROW	
PVMT. MARKING, LANE ARROW	
PVMT. MARKING, LANE ARROW	477
PVMT. MARKING, LANE ARROW	
PVMT. MARKING, LANE ARROW	27 4
PVMT. MARKING, BICYCLE LANE	600
PVMT. MARKING, SYMBOL	•
PVMT. MARKING WORD, BICYCLE	616
PVMT. MARKING WORD, LANE	I ANE LANG
PVMT. MARKING WORD, ONLY	ĝn a y
PVMT. MARKING WORD, RAILROAD	
PVMT. MARKING WORD, SCHOOL	SCHOOL
IRON PIN FOUND	0
SOLID IRON PIN FOUND	0
IRON PIPE FOUND	©
DRILL HOLE FOUND	×
CHISELED "X" FOUND	X
MONUMENT BOX FOUND	M
MONUMENT CONCRETE FOUND	©
MONUMENT RIGHT-OF-WAY FOUND	RW
PK NAIL FOUND	Ø
MAG NAIL FOUND	Ø
SPIKE FOUND	Δ
HUB FOUND	
AXLE FOUND	0
WOOD POST FOUND	•
CORNER STONE FOUND	CS
AERIAL TARGET FOUND	AER
GPS CONTROL FOUND	GPS
BENCHMARK FOUND	•

PROPOSED SYME	OLS
SANITARY MANHOLE	
SANITARY MANHOLE, ADJUST	<u>S</u>
SANITARY CLEANOUT	0
SANITARY LINE CAP	1
SANITARY STRUCTURE NUMBER	(00)
SANITARY VENT PIPE	Ø
STORM MANHOLE (SOLID GRATE)	
STORM MANHOLE (OPEN GRATE)	
STORM MANHOLE, ADJUST	
CURB INLET	<u> </u>
CURB INLET (DOUBLE)	
CURB INLET, ADJUST	ِيْسِلى <u>ا</u>
CURB INLET (DOUBLE), ADJUST	<u> </u>
CATCH BASIN	
CATCH BASIN (SOLID)	 X
CATCH BASIN, ADJUST	
<u> </u>	
CATCH BASIN (SIDE INLET)	
DRAIN	=
DOWNSPOUT	•
STORM CLEANOUT	0
STORM LINE CAP	1
STORM HEADWALL	
STORM STRUCTURE NUMBER	(00)
ROCK CHANNEL PROTECTION	5080808
SURFACE DRAINAGE FLOW	<u></u>
SURFACE DRAINAGE FLOW	
STORM FLOOD ROUTING ARROW	
FIRE HYDRANT	€ €
FIRE HYDRANT, ADJUST	Ø.
WATER SIAMESE CONNECTION	< □
WATER VALVE	⊗ €
WATER VALVE BOX	⊠
WATER METER	WM
WATER LINE REDUCER	
WATER LINE CAP	
WATER WELL	•
WATER LINE MARKER	
WATER LINE MARKER	
POST INDICATOR VALVE	(PIV)
WATER MANHOLE	<u> </u>
WATER CORPORATION STOP	•
WATER FLUSHING ASSEMBLY	•
WATER FITTING (TEE)	B
WATER FITTING (CROSS)	•
WATER FITTING (45° WYE)	4
WATER FITTING (11.25°)	H
WATER FITTING (22.50°)	4
WATER FITTING (45°)	4
WATER FITTING (90°)	- 'P
IRRIGATION SPRINKLER HEAD	
IRRIGATION CONTROL BOX	IRR
WATER METER	WM -
GAS LIGHT POST (YARD)	<u> </u>
GAS MANHOLE	G
GAS MANHOLE	
GAS VALVE	⊗ ❸
GAS METER	GM
GAS REGULATOR	GR
GAS VENT PIPE	 ⊘
ELECTRIC LIGHT (GROUND)	*
ELECTRIC LIGHT POST (YARD)	
	<u> </u>
ELECTRIC MANHOLE	E
ELECTRIC MANHOLE, ADJUST	
ELECTRIC PULL BOX	РВ
ELECTRIC CONTROL BOX	СТЦ
ELECTRIC JUNCTION BOX	JCT
ELECTRIC VAULT BOX	VLT
ELECTRIC METER	EM
ELECTRIC PEDESTAL	EP
ELECTRIC TRANSFORMER	TR
ELECTRIC AIR CONDITION UNIT	AC AC
	P
POLE, ELECTRIC	<u> </u>
	4
POLE, TELEPHONE	<u> </u>
POLE, LIGHT	<u> </u>
<u> </u>	₱ <u> </u>
POLE, LIGHT	₱ <u>₱</u> ₱ ₽

POLE, UTILITY

POLE, GENERAL

	01.0
PROPOSED SYMB	OLS R
POLE, TRAFFIC CONTROL	•
POLE, GUY	
POLE, BRACE	<i>₿</i>
POLE, ELECTRIC/TELEPHONE	P
	P
POLE, ELECTRIC W/LIGHT	<u>E</u>
POLE, ELECTRIC/CABLE TV	•
POLE, ELEC./TELE./LIGHT	
POLE, ELEC./TELE./CABLE TV	
POLE, ELEC./TELE./LIGHT/CABLE	₽
POLE, TELEPHONE/LIGHT	<u></u>
	<u> </u>
POLE, TELEPHONE/CABLE TV	₹ •
POLE, TELE./LIGHT/CABLE TV	<u>É</u>
POLE, CABLE TV W/LIGHT	<u> </u>
POLE, FLAG	•
GUY WIRE	/ ————————————————————————————————————
POST, SIGN (SINGLE SIDED)	•
POST, SIGN (DOUBLE SIDED) POST, SIGN (DUAL POST)	
POST (GENERAL)	•
BOLLARD	•
DELINEATOR POST FENCE POST	⊚ ■
PARKING COUNT	00
PARKING BUMPER BLOCK	
HANDICAP PARKING SYMBOL HANDICAP DETECTABLE WARNING	<u>&</u> &
MAILBOX	MB
PAPERBOX	PB
PARKING METER	
STREET SIGN	
TELEPHONE MANHOLE TELEPHONE MANHOLE (ADJ)	
TELEPHONE PEDESTAL	TP
CABLE MANHOLE	© (a)
CABLE MANHOLE (ADJUSTED) CABLE PEDESTAL	[CP]
CABLE SATELLITE	\overline{A}
TRAFFIC CONTROL MANHOLE	(B)
TRAFFIC CONT. MANHOLE (ADJ)	Ŏ
TRAFFIC CONTROL BOX TRAFFIC PULL BOX	TRAF PB
TRAFFIC FOLL BOX TRAFFIC SIGNAL PEDESTAL	TP
INLET PROTECTION	
STRAW BALE CHECK DAM TREE (DECIDUOUS)	
TREE (EVERGREEN)	**
BUSH	£35
PVMT. MARKING, LANE ARROW	-
PVMT. MARKING, LANE ARROW PVMT. MARKING, LANE ARROW	7
PVMT. MARKING, LANE ARROW	**
PVMT. MARKING, LANE ARROW PVMT. MARKING, LANE ARROW	*
PVMT. MARKING, LANE ARROW	4
PVMT. MARKING, LANE ARROW	J F
PVMT. MARKING, BICYCLE PVMT. MARKING, CHEVRON	
PVMT. MARKING, CHEVRON PVMT. MARKING, ONE WAY	ONE WAY DO NOT ENTER
PVMT. MARKING WORD, LANE	
PVMT. MARKING WORD, ONLY PVMT. MARKING WORD, RAILROAD	
PVMT. MARKING WORD, RAILROAD PVMT. MARKING WORD, SCHOOL	SCHOOL

OSED SYMB	OLS	ABBREVIATIO	NS
	R	ABANDONED	ABAN
CCONTROL	• '	ADJUST	ADJ
	Ģ	AGGREGATE	AGG
	B	ASBESTOS PIPE	ASB
	•	ASPHALT	ASPH
	P	BACK TO BACK	B/B
RIC/TELEPHONE	7	BASEMENT FLOOR ELEVATION	BFE
RIC W/LIGHT	P	BETWEEN	BTW
	<u>L</u>	BOTTOM OF CURB ELEVATION	ВС
RIC/CABLE TV		BOTTOM OF FOOTING ELEVATION	FTG.
ELE./LIGHT	P	BOTTOM OF WALL ELEVATION	BWE
ELE./LIGHT	<u> </u>	BUILDING	BLDG
ELE./CABLE TV	\$	BULKHEAD	BHD
	 	CABLE TELEVISION	CAT\
ELE./LIGHT/CABLE	2	CAST IRON PIPE	CIP
IONE/LIGHT	J	CATCH BASIN	СВ
	[CENTERLINE	C/L
ONE/CABLE TV	, f	CENTER TO CENTER	C/C
IOUT/OADI E TV		CHAIN LINK FENCE	CLF
IGHT/CABLE TV	Z	CHEMICAL STABILIZATION	CHEM. ST
TV W/LIGHT		CONCENTRIC	CON
		CONCRETE	CONC
	•	CONNECTION	CONN
	<i>(</i>	CONTROL JOINT	CJ
INGLE SIDED)	•	COPPER PIPE	СОР
OUBLE SIDED)	=	CORRUGATED METAL PIPE	СМР
UAL POST)	• •	DEMOLITION	DEMO
AL)	•	DEPRESSED	DEP.
	•	DOWNSPOUT	DS
POST	<u> </u>	DROP MANHOLE	DMH
		DUCTILE IRON PIPE	DIP
NT	00	DUMPSTER	DUMF
PER BLOCK		ECCENTRIC	ECC
RKING SYMBOL	ය ය	EDGE OF PAVEMENT ELEVATION	EP
TECTABLE WARNING	[<u>5</u> 25]	ELECTRIC	ELEC
	MB	ENCLOSURE	ENCL
	PB	EXISTING FACE TO FACE	EX.
ER	&	FINISHED FLOOR ELEVATION	FFE
	_	FIRE HYDRANT	FH
1ANHOLE	T	FOUNDATION	FNDN
IANHOLE (ADJ)		FULL DEPTH RECLAMATION	FDR
EDESTAL	TP	FUTURE	FUT.
DLE	©	GAS	G
DLE (ADJUSTED)		GALVANIZED PIPE	GP
TAL	CP	GRADE BREAK ELEVATION	GB
ITE	$\overline{\mathcal{Q}}$	GRAVEL	GVL.
-ITE	<u> </u>	GROUND ELEVATION	GND
TROL MANHOLE	®	GUTTER ELEVATION	GUT
T. MANHOLE (ADJ)		HANDICAP (E.G. ACCESSIBLE)	НС
TROL BOX	TRAF	HIGH-DENSITY POLYETHYLENE PIPE	HDPE
BOX	РВ	HIGH POINT ELEVATION	HP
AL PEDESTAL	TP	HORIZONTAL	HOR
CTION		INSTALL	INSTL
CHECK DAM		IRRIGATION	IRR.
IOUS)		JOINT	JT
REEN)		JOINT FILLER	JF
IO LANE ADDOM	£43	JUNCTION	JCT.
IG, LANE ARROW IG, LANE ARROW	7	KNOCKOUT	КО
IG, LANE ARROW	\\\\\\\\\\\\\\\\\\\\\\\\\\\\\\\\\\\\\\	LATERAL	LAT.
IG, LANE ARROW		LOW POINT ELEVATION	LP
IG, LANE ARROW	***	MAINTAIN	MAIN
IG, LANE ARROW	*************************************	MATERIAL	MATL
IG, LANE ARROW	A	MOUNTED	MTD
IG, LANE ARROW	<i>J E</i>	MISCELLANEOUS	MISC
IG, BICYCLE		NOT TO SCALE	N.T.S
IG, CHEVRON		ORNAMENTAL	ORN
IG, ONE WAY	ONE WAY	OUT TO OUT	0/0
IG WORD, LANE	DO NOT ENTER	OVERHEAD OXYGEN LINE	OH
IG WORD, ONLY	DILY	PARKING	O PKG
IG WORD, RAILROAD		PARKING PAVEMENT	PKG PVM1
IG WORD, SCHOOL	SCHOOL	PEDESTAL	PVMI
		PERFORATE	PED
		PIPE INVERT ELEVATION	INV.
		POLYVINYL CHLORIDE PIPE	PVC
		PREFORMED JOINT FILLER	PJF
		PROPOSED PROPOSED	PJF PR.
		PULL BOX	PR.

PULL BOX

RAILROAD

REMOVE

REINFORCED

RETAINING WALL

REINFORCED CONCRETE PIPE

ELEC.
ENCL.
EX.
F/F

FNDN. FDR

GUT. HC HDPE

HOR. INSTL.

> JCT. KO LAT.

MAINT. MATL.

MISC. N.T.S. ORN. O/O ОН

PERF. INV. PVC PJF

PR.

PB

REINF. RCP

RMV.

RET.WALL

NS	ABBREVIAT	IONS
ABAN.	ROOF LEADER	RL
ADJ.	SALVAGE	SALV.
AGG.	SANITARY SEWER	SAN.
ASB.	SERVICE	SERV.
ASPH.	SLEEVE	SLV.
B/B	STABILIZATION	STABL.
BFE	STEAM PIPE	STEA.
BTW.	STEEL PIPE	STL.
BC	STORM SEWER	STM.
FTG.	SUMP PUMP	SP
BWE	TELEPHONE	TEL.
BLDG.	TEMPORARY	TEMP.
BHD.	THICKENED	THK.
CATV	TOP OF CURB ELEVATION	TC
CIP	TOP OF HEADWALL ELEVATION	THW
СВ	TOP OF STRUCTURE ELEVATION	RIM
C/L	TOP OF WALL ELEVATION	TW
C/C	TRENCH DRAIN	TD
CLF	TYPICAL	TYP.
CHEM. STABL.	UNDERDRAIN	UD
CON.	UNDERGROUND	UG
CONC.	VERTICAL	VERT.
CONN.	VITRIFIED CLAY PIPE	VCP
CJ	WATER MAIN	W.
COP.	WINDOW ELEVATION	WIN.
CMP	WIRE MESH	WM
DEMO.	WOOD	WD.
DEP.	YARD HYDRANT	YH
DS		
DMH		
DIP		
DUMP.		
ECC.		
EP		



		ISSUED FOR:	REVIEW	<u>Q</u>	REVISION	DATE
	14	ISSUE DATE:	10/3/2025			
PROJE 230		SCALE:	A/N			
	LAKE COUNTY	DESIGNED BY:	ELE			
	GENERAL - 00 SERIES	DRAWN BY:	ELE			
	SITE LEGEND	CHECKED BY:	RSS			

GENERAL

1. IT SHALL BE THE RESPONSIBILITY OF THE CONTRACTOR TO REVIEW THE PLANS AND TECHNICAL SPECIFICATIONS, VISIT THE PROJECT SITE AND NOTIFY IN WRITING THE PROJECT ENGINEER OF ANY DISCREPANCIES IN THE PLANS OR SPECIFICATIONS PRIOR TO CONSTRUCTION.

- 2. ANY REVISIONS TO THE ACCEPTED CONSTRUCTION PLANS SHALL BE REVIEWED AND APPROVED BY THE ENGINEER PRIOR TO IMPLEMENTATION IN THE FIELD.
- 3. THE CONTRACTOR SHALL BE RESPONSIBLE FOR MAINTAINING A CURRENT SET OF "AS BUILT" DRAWINGS
- 4. THE CONTRACTOR SHALL BE RESPONSIBLE FOR ALL CONSTRUCTION LAYOUT AND SHALL NOTIFY ENGINEER IN WRITING OF ANY DISCREPANCIES.
- 5. NO WORK MAY COMMENCE WITHOUT AN EXECUTED NOTICE TO PROCEED.
- 6. THE CONTRACTOR SHALL BE SOLELY RESPONSIBLE FOR COMPLYING WITH OSHA SAFETY REQUIREMENTS. THE CONTRACTOR SHALL BE RESPONSIBLE FOR THE SAFETY OF ALL VISITORS, EMPLOYEES AND WORKERS ON THE CONSTRUCTION SITE.
- 7. THE CONTRACTOR SHALL CONSTRUCT THIS PROJECT IN COMPLIANCE WITH FEDERAL, STATE AND LOCAL BUILDING CODES.
- 8. ALL SEDIMENT AND EROSION CONTROL PRACTICES SHALL BE INSTALLED PRIOR TO ANY MAJOR SOIL DISTURBANCE, IN THEIR PROPER SEQUENCE, AND MAINTAINED UNTIL PERMANENT PROTECTION IS ESTABLISHED.
- 9. ANY DISTURBED AREAS NOT SCHEDULED FOR CONSTRUCTION ACTIVITIES WITHIN SEVEN DAYS OF DISTURBANCE SHALL BE TEMPORARILY STABILIZED.
- 10. ALL POLLUTANTS OTHER THAN SEDIMENT THAT OCCUR ON-SITE DURING CONSTRUCTION SHALL BE HANDLED AND LEGALLY DISPOSED OF IN A MANNER THAT DOES NOT CAUSE CONTAMINATION OF STORM OR SURFACE WATERS. POLLUTANTS OF CONCERN INCLUDE, BUT ARE NOT LIMITED TO, FUELS, LUBRICANTS, SOLVENTS, CONCRETE BI-PRODUCTS AND CONSTRUCTION MATERIALS.
- 11. THE CONTRACTOR SHALL BE SOLELY RESPONSIBLE FOR THE SECURITY OF ALL STORED MATERIALS ON OWNER'S SITE.
- 12. THE CONTRACTOR SHALL BE RESPONSIBLE FOR BARRICADING AND/OR FENCING AREAS THAT ARE DEEMED UNSAFE BY OWNER, ENGINEER.
- 13. THE CONTRACTOR SHALL COORDINATE WITH OWNER THE STORAGE OF STORED MATERIALS AND REMOVED EXISTING EQUIPMENT TO BE RETAINED.
- 14. IT IS THE CONTRACTOR'S RESPONSIBILITY TO MAINTAIN PEDESTRIAN, LOCAL ROADWAY AND DRIVEWAY ACCESS AT ALL TIMES.
- 15. THE CONTRACTOR SHALL BE RESPONSIBLE FOR ALL CONSTRUCTION SIGNING AND TRAFFIC CONTROL AS DIRECTED BY THE LOCAL MUNICIPALITY. ALL SIGNS AND MATERIAL USED SHALL CONFORM TO THE SPECIFICATIONS SET FORTH IN THE OHIO MANUAL OF UNIFORM TRAFFIC CONTROL DEVICES.
- 16. THE CONTRACTOR SHALL PROVIDE A PRE-CONSTRUCTION VIDEO TAPE SURVEY OF THE ENTIRE PROJECT AREA. ALL COSTS ASSOCIATED FOR THIS WORK, INCLUDING THE VIDEO TAPE SURVEY, SHALL BE INCLUDED IN THE LUMP SUM PRICE BID FOR MOBILIZATION, AS PER PLAN
- 17. THE CONTRACTOR IS RESPONSIBLE FOR SECURING THE SITE AT ALL TIMES DURING WORK. SITE SHALL BE SECURE EVEN AT TIMES OF NO WORK.
- 18. ROOF DRAINS, FOUNDATION DRAINS, AND OTHER CLEAN WATER CONNECTIONS TO THE SANITARY SEWER SYSTEM ARE PROHIBITED.
- 19. THE PROJECT IS FEDERALLY FUNDED AND MUST FOLLOW FEDERAL PROCUREMENT AND PREVAILING WAGE REQUIREMENTS. THE CONTRACTOR IS SOLELY RESPONSIBLE TO MEET THESE REQUIREMENTS AS DETAILED IN THE BID AND CONTRACT DOCUMENTS.
- 20. BOOSTER PUMPS SHALL NOT BE PROVIDED ON WATER SERVICES.

UNDERGROUND UTILITIES

- 1. THE CONTRACTOR SHALL NOTIFY UTILITY COMPANIES AT LEAST THREE (3) WORKING DAYS, EXCLUDING SATURDAYS, SUNDAYS AND LEGAL HOLIDAYS, PRIOR TO CONSTRUCTION TO HAVE UTILITIES STAKED, MARKED OR OTHERWISE DESIGNATED IN THE CONSTRUCTION AREA IN SUCH A MANNER OR LOCATING SHALL BE COORDINATED TO STAY APPROXIMATELY THREE (3) DAYS AHEAD OF THE PLANNED CONSTRUCTION.
- 2. THE CONTRACTOR SHALL EXPOSE ALL UTILITIES OR STRUCTURES PRIOR TO CONSTRUCTION TO VERIFY THE VERTICAL AND HORIZONTAL LOCATION OF THE UTILITY OR STRUCTURE AND ITS EFFECT ON THE PROPOSED CONSTRUCTION. THE CONTRACTOR SHALL COORDINATE HIS WORK WITH THE UTILITY OWNER.
- 3. OSHA STANDARDS PROHIBITING CRANE OR BACKHOE OPERATIONS WITHIN SET DISTANCES OF ENERGIZED PRIMARY CONDUCTORS SHALL BE OBSERVED. TEMPORARY RELOCATION OF ELECTRICAL UTILITIES, INCLUDING RESTRAINT POLES, RELOCATION OF POLES AND RUBBER COVERING OF ENERGIZED CONDUCTORS MAY BE REQUIRED. THE COORDINATION AND COST OF THESE SERVICES IS THE RESPONSIBILITY OF THE CONTRACTOR. THE CONTRACTOR MAY RESTRAIN POLES IF THE METHOD OF SUPPORT HAS BEEN SUBMITTED TO AND APPROVED BY THE UTILITY OWNER.
- 4. THE CONTRACTORS SHALL EXPOSE BY PRE-EXCAVATING ALL UTILITIES OR STRUCTURES PRIOR TO CONSTRUCTION TO VERIFY THE VERTICAL AND HORIZONTAL EFFECT ON THE PROPOSED CONSTRUCTION, AND SHALL MAKE ADJUSTMENTS IN ELEVATIONS AS DIRECTED BY THE ENGINEER TO PROVIDE SUFFICIENT CLEARANCE BETWEEN THE PROPOSED AND EXISTING UTILITIES.

EXISTING UTILITIES

- 1. THE LOCATIONS OF THE UNDERGROUND UTILITIES ARE PLOTTED ACCORDING TO THE INFORMATION FURNISHED BY THE UTILITIES CONCERNED AND THE CITY DOES NOT GUARANTEE THE ACCURACY THEREOF. CONTRACTOR TO CALL OUPS (1-800-362-2764) "48 HOURS BEFORE YOU DIG" AND CALL OIL & GAS PRODUCERS PROTECTIVE (1-800-925-0988). CONTRACTOR ALSO TO COORDINATE HIS WORK WITH THE DOMINION EAST OHIO GAS COMPANY, THE ILLUMINATING COMPANY, AMERITECH COMPANY AND CABLE TV FOR GAS LINE AND/OR POLE RELOCATION.
- 2. IN THE EVENT OF DAMAGE TO EXISTING PUBLIC AND/OR PRIVATE UTILITIES, THE AGENCY CONCERNED SHALL BE NOTIFIED IMMEDIATELY AND ALL REPAIR WORK SHALL BE EXECUTED IN ACCORDANCE WITH THE SPECIFICATIONS OF THE RESPECTIVE AGENCY AT NO ADDITIONAL EXPENSE TO THE CITY INCLUDING ANY INSPECTION FEES OR MAINTENANCE CREWS. CABLE (CEI, AT&T & TV) RELOCATION AND SUPPORT.
- 3. WHERE EXISTING POWER OR TELEPHONE POLES ARE IN CLOSE PROXIMITY TO WORK, THE CONTRACTOR SHALL COORDINATE HIS WORK EFFORTS WITH THOSE OF THE UTILITY COMPANIES SUCH THAT THEIR EXISTING FACILITIES CAN BE MAINTAINED AND PROTECTED DURING THE TIME WORK IS GOING ON ADJACENT TO THE POLE. THE COST FOR ANY REQUIRED PROTECTION OR RELOCATION OF EXISTING POWER OR TELEPHONE POLES SHALL BE THE RESPONSIBILITY OF THE CONTRACTOR AND NOT BE THE RESPONSIBILITY OF THE CITY.
- 4. WHERE EXCAVATION CROSSES EXISTING UTILITIES, THE CONTRACTOR SHALL USE EXCAVATION TECHNIQUES AND EQUIPMENT TO EXPOSE SUCH CROSSINGS PRIOR TO INSTALLATION OF THE RELIEF SEWER.

THE UTILITY OWNERSHIPS ARE AS FOLLOWS:

DEPARTMENT OF PUBLIC SERVICES 35150 LAKESHORE BOULEVARD EASTLAKE, OHIO 44095 PHONE: (440) 951-2200 KEVIN KOSTELNIK

THE ILLUMINATING COMPANY 6896 MILLER RD. - SUITE 101 BRECKSVILLE, OHIO 44141 PHONE: (440) 546-8748

AT&T 13630 LORAIN AVE. CLEVELAND, OHIO 44111 PHONE: (216) 476-6142 LAKE COUNTY UTILITIES DEPARTMENT 105 MAIN STREET PAINESVILLE, OHIO 44077 PHONE: (440) 350-2652 RANDALL J. ROTHLISBERGER

DOMINION EAST OHIO GAS 320 SPRINGSIDE DRIVE SUITE 320 AKRON, OHIO 44333 PHONE: (330) 664-2409

TIME WARNER CABLE 1100 E. 222ND ST. EUCLID, OHIO 44117 PHONE: (216) 531-6188

PROTECTION OF EXISTING UTILITIES AND PIPES

- 1. THE CONTRACTOR SHALL BE REQUIRED, AT HIS EXPENSE, TO DO EVERYTHING NECESSARY TO PROTECT, SUPPORT AND SUSTAIN ALL SANITARY SEWERS, STORM DRAINS, WATER, PROCESS OR GAS PIPES, SERVICE PIPES, ELECTRIC LIGHTS, POWER AND TELEPHONE POLES, CONDUIT AND OTHER FIXTURES LAID ACROSS OR ALONG THE SITE OF THE WORK. THE ENGINEER AS WELL AS THE COMPANY OR CORPORATION OWNING SAID PIPES, POLES OR CONDUITS MUST BE NOTIFIED OF THE SAME BY THE CONTRACTOR, BEFORE ANY SUCH FIXTURES ARE REMOVED OR DISTURBED. IN CASE ANY OF THE SAID SEWER, DRAIN, GAS, PROCESS OR WATER PIPES, SERVICE PIPES, ELECTRIC LIGHT, POWER AND TELEPHONE POLES, CONDUITS OR OTHER FIXTURES, IN OR OUTSIDE THE CONSTRUCTION LIMITS, ARE DAMAGED THEY SHALL BE REPAIRED BY THE AUTHORITIES HAVING CONTROL OF THE SAME AND THE EXPENSE OF SAID REPAIRS SHALL BE DEDUCTED FROM THE MONIES WHICH ARE DUE OR TO BECOME DUE THE CONTRACTOR UNDER THIS CONTRACT.
- 2. SHOULD IT BECOME NECESSARY TO CHANGE THE POSITION OR TEMPORARILY REMOVE ANY STORM DRAIN, SANITARY SEWER, ELECTRIC CONDUITS, WATER PIPES, GAS PIPES, PROCESS OR OTHER PIPES OR WIRES IN ORDER TO PERMIT THE CONTRACTOR TO USE A PARTICULAR METHOD OF CONSTRUCTION OR IN ORDER TO CLEAR THE STRUCTURES BEING BUILT, THE CONTRACTOR SHALL NOTIFY THE ENGINEER OF THE LOCATION AND CIRCUMSTANCES IMMEDIATELY
- 3. NO SURFACE, GROUND OR TRENCH WATER SHALL BE ALLOWED TO FLOW INTO EXISTING SANITARY SEWERS.
- 4. CONTRACTOR SHALL MAINTAIN FLOW THROUGH THE EXISTING BYPASS AS IS PRACTICAL. WHERE WORK IS PARTIALLY COMPLETE NECESSITATING TRENCH ABANDONMENT IN THE EVENT OF STORM EVENT CONTRACTOR SHALL STABILIZE EXCAVATION AND PROTECT THE UNFINISHED WORK. CONTRACTOR SHALL SUBMIT SUCH A PLAN FOR ENGINEER REVIEW.

LAKE COUNTY DEPARTMENT OF UTILITIES GENERAL WATER NOTES BENCH MARKS

- 1. THE INSTALLATION OF THE WATER LINE SHALL MEET THE REQUIREMENTS OF THE COUNTY OF LAKE UTILITIES DEPARTMENT RULES AND REGULATIONS, CURRENT EDITION.
- 2. 2" AND LARGER TAPS MUST BE SCHEDULED WITH WEST END SERVICE CENTER (440-918-3416) A MINIMUM OF 48 HOURS IN ADVANCE.
- 3. ONLY WATER/SEWER CONTRACTORS LICENSED BY THE LAKE COUNTY BOARD OF COMMISSIONERS MAY INSTALL WATER MAINS.
- 4. THIS APPROVAL BY THE LCDU SHALL EXPIRE IF THE WATERLINE CONSTRUCTION HAS NOT BEEN INITIATED BY A DEVELOPER WITHIN (12) MONTHS OF THE EFFECTIVE APPROVAL DATE AS SHOWN ON THE ORIGINALLY SUBMITTED FOR APPROVAL BLUEPRINT COPY. (THIS IS NOT TO BE CONSTRUED AS THE DATE THAT IS SHOWN ON THE ORIGINAL MYLAR TITLE SHEET.)
- THE CONTRACTOR SHALL NOTIFY THE LCDU AT LEAST 48 HOURS IN ADVANCE OF ANY WORK IN THEIR SYSTEMS.
- 6. THE LCDU SHALL PERFORM INSPECTION SERVICES. THE COST OF INSPECTION SHALL BE INCLUDED AS PART OF THIS CONSTRUCTION PROJECT AT THE CURRENT BASE RATE AS ESTABLISHED BY THE LAKE COUNTY BOARD OF COMMISSIONERS. (SEE SECTION 7 FEE SCHEDULE) COST FOR LAKE COUNTY INSPECTION FEE AND OTHER FEES SHALL BE INCLUDED IN THE UNIT PRICES BID FOR OTHER WATERLINE ITEMS.
- 7. WATERLINE WORK SHALL NOT BEGIN UNTIL THE AREAS OF CONSTRUCTION ARE ROUGH GRADED.
- 8. ALL WATERLINES ON THIS PROJECT SHALL BE LAID AT THE ELEVATIONS AND GRADES SHOWN ON THE DRAWINGS. HIGH POINTS IN THE WATERLINE MUST OCCUR AT THE STATIONED HYDRANT TEE LOCATIONS.
- 9. ALL HYDRANTS SHALL BE POSITIONED SO THAT THE STEAMER NOZZLES POINT IN THE DIRECTION SHOWN ON THE PLANS.
- THE PROPOSED WATERLINE SHALL HAVE 5' MINIMUM COVER OVER THE TOP OF PIPE AT ALL PLACES, EXCEPT AT SPECIFIC HYDRANT TEE LOCATIONS AS SHOWN ON THE PLANS.
- 11. ALL BOLTS SHALL BE STAINLESS STEEL TYPE 304 OR 316. WITH ANTI-GALLING AGENT
- 12. ALL SHOP DRAWINGS SHALL BE SUBMITTED TO THE ENGINEER FOR PRELIMINARY CHECKING. THE ENGINEER SHALL FORWARD CHECKED SHOP DRAWINGS TO THE LCDU FOR FINAL CHECKING AND APPROVAL.
- 13. THE LCDU SHALL PROVIDE WATER FOR THE NEW WATER MAIN WITHOUT COST FOR THE INITIAL OPERATION. ALL WATER FOR FLUSHING OPERATIONS SHALL BE PAID FOR BY THE CONTRACTOR AT CURRENT RATES AS ESTABLISHED BY THE LAKE COUNTY BOARD OF COMMISSIONERS PER 100 CUBIC FEET OF WATER USED. (SEE SECTION 7 FEE SCHEDULE)
- 14. ALL WATER MAIN PIPE SHALL BE AN APPROVED MATERIAL AS SHOWN ON THE APPROVED PLANS.
- 15. LOCATION OF STERILIZATION AND TESTING CONNECTIONS SHALL BE AS DIRECTED BY THE LCDU AND ALL COSTS ASSOCIATED WITH PLACING AND UTILIZING SAID STERILIZATION AND TESTING CONNECTIONS SHALL BE INCLUDED IN THE PRICE BID PER LINEAL FOOT OF THE WATER MAINS. NO BACTERIA SAMPLES ARE TO BE TAKEN FROM FIRE HYDRANTS.
- 16. LCDU WILL MAKE THE NECESSARY NEW SERVICE CONNECTION TAPS ON EXISTING LCDU MAINS FOR THE CONTRACTOR AT CURRENT RATES AS ESTABLISHED BY THE LAKE COUNTY BOARD OF COMMISSIONERS PER 8" AND GREATER TAPS WITHIN RIGHT OF WAY. (SEE SECTION 7 FEE SCHEDULE) SERVICE CONNECTIONS TO EXISTING BUILDINGS SHALL BE MADE BY THE CONTRACTOR.
- 17. NO WATER SERVICE CONNECTIONS TO ANY BUILDING SHALL BE PERMITTED PRIOR TO FINAL ACCEPTANCE BY THE LCDU INCLUDING RECTIFICATION OF ALL PUNCH LIST ITEMS.
- 18. ALL CURB STOP BOXES, VALVE BOXES, ETC. TO BE SET AS SHOWN ON THE PLANS. RIMS WILL BE RAISED OR LOWERED AND BOXES PLUMBED BY THE CONTRACTOR AT TIME OF HOUSE CONSTRUCTION WHEN FINAL YARD GRADING IS COMPLETED.
- 19. ALL PROJECT HYDRANTS SHALL HAVE A FIELD COAT OF APPROVED PAINT APPLIED BY THE CONTRACTOR WITH THE EXCEPTION OF HYDRANTS THAT ARE FACTORY PAINTED WITH A ONE COAT UV RESISTANT HIGH GLOSS 2-PART POLYURETHANE ENAMEL, COLOR AS SPECIFIED. IF THE COATING ON THE HYDRANT IS DAMAGED BEFORE INSTALLATION THE HYDRANT MUST BE PAINTED.
- 20. THE CONTRACTOR SHALL NOTIFY THE FIRE DEPARTMENT PRIOR TO ANY PRESSURE TESTING.
- 21. ALL PROPOSED WATER LINES SHALL BE LAID OUT BY A REGISTERED SURVEYOR WITH GRADE STAKES AT A MINIMUM OF EVERY 50' AND AT ALL FITTINGS AND A CUT SHEET PROVIDED PRIOR TO CONSTRUCTION.
- 22. THE CONTRACTOR/DEVELOPER SHALL SUBMIT A THREE YEAR MAINTENANCE BOND TO THE COMMISSIONERS BY DEVELOPER IN THE AMOUNT OF TEN PERCENT OF THE FINAL CONSTRUCTION COSTS AS CERTIFIED BY THE DEVELOPER'S ENGINEER, FOR PUBLIC EXTENSION PROJECTS.

EXCAVATION AND COMPACTION REQUIREMENT

- 1. THE SOIL BORING REPORT IS AVAILABLE FOR REVIEW.
- 2. THE OWNER AND ENGINEER DO NOT GUARANTEE THE SUITABILITY OR SUGGEST THAT THE EXISTING EXCAVATED MATERIAL IN ITS PRESENT STATE WILL CONSIST OF THE PROPER MOISTURE CONTENT TO ACHIEVE THE REQUIRED COMPACTION ON WITHOUT DRYING OR ADDING WATER TO THE MATERIAL UPON REQUEST THE OWNER WILL PROVIDE ACCESS TO THE SITE FOR THE CONTRACTOR TO CONDUCT SUCH INVESTIGATIONS AND TESTS DEEMED NECESSARY TO MAKE HIS DETERMINATION, ALL EXCAVATION, TRENCHING, AND COMPACTION REQUIREMENTS SHALL BE IN ACCORDANCE WITH 310000.
- 3. THE ENGINEER SHALL DETERMINE THE DEPTH OF THE COMPACTED LAYERS OF BACKFILL ACCORDING TO THE COMPACTION EQUIPMENT BEING USED BY THE CONTRACTOR. THEY MAY ORDER THE REMOVAL, REFILLING, RECOMPACTION AND RETESTING OF ALL BACKFILL NOT MEETING THE REQUIREMENTS OF THE CONTRACT.

MATERIAL DISPOSAL AND TEMPORARY SURFACES

- 1. THE REMOVAL AND DISPOSAL OF ALL SURPLUS EXCAVATED MATERIAL AND CONSTRUCTION DEBRIS SHALL BE THE RESPONSIBILITY OF THE CONTRACTOR THE DISPOSAL OF ALL CONSTRUCTION DEBRIS SHALL BE AT AN APPROVED LANDFILL THE DISPOSAL OF ALL "CLEAN" WASTE MATERIAL SHALL BE AT APPROVED LANDFILL, AND/OR OTHER SITES APPROVED BY THE OWNER AND ENGINEER, THE DISPOSAL OF EXISTING PIPELINE AND TANK SEDIMENTS AND WASTEWATER SLUDGE SHALL BE AT AN APPROVED LANDFILL. THE CONTRACTOR SHALL OBTAIN ALL APPROVAL, PERMITS, LICENSES, ETC. FROM LOCAL STATE AND FEDERAL AGENCIES AND/OR PRIVATE LANDOWNERS. THE CONTRACTOR SHALL FURNISH THE ENGINEER A COPY OF ALL APPROVALS OR WRITTEN PERMISSION PRIOR TO DISPOSING OF ANY WASTE AT SAID SITE.
- 2. THE CONTRACTOR SHALL BE RESPONSIBLE FOR THE COMPLETE RESTORATION OF ALL MATERIAL WASTE AND TEMPORARY STORAGE AREAS USED IN THE COURSE OF THIS CONTRACT. THE RESTORATION WORK SHALL INCLUDE CLEANUP, SHAPING AND GRADING AND ESTABLISHMENT OF VEGETATIVE COVER BY SEEDING AND MULCHING IN ACCORDANCE WITH O D.O.T. SPEC FICTION NO. 559 THE FINAL GRADING OF WASTE AREAS SHALL BE PROPERLY SLOPED TO PROVIDE DRAINAGE RUNOFF.
- 3. TEMPORARY SURFACES WHERE EXCAVATION IS LOCATED IN STREETS, DRIVES AND PARKING AREAS SHALL BE FURNISHED AND PLACED BY THE CONTRACTOR (PER TEMPORARY SURFACE DETAIL) AND SHALL BE FULLY MAINTAINED TO MINIMIZE INCONVENIENCE TO THE PUBLIC AT NO ADDITIONAL COST TO THE OWNER.
- THE CONTRACTOR IS RESPONSIBLE FOR REMOVING ALL UNUSED EXCAVATIONS SO THAT THE ORIGINAL SITE CONTOURS ARE PRESERVED UNLESS NOTED OTHERWISE. WASTING ON SITE SHALL NOT BE ANTICIPATED.
- 5. DUMP BITES MUST BE APPROVED BY THE OWNER AND THE ENGINEER

MONUMENTS, PROPERTY CORNERS AND BENCH MARKS

1. MONUMENTS, PROPERTY CORNER MARKERS AND BENCH MARKS SHALL NOT BE DISTURBED BY THE CONTRACTOR. IN THE EVENT THAT IT IS NECESSARY TO REMOVE MONUMENTS, PROPERTY CORNER MARKERS OR BENCH MARKS FOR THE CONSTRUCTION OF THE WORK, THE CONTRACTOR SHALL HAVE A REGISTERED LAND SURVEYOR PROPERLY REFERENCE THE POINTS AND SHALL HAVE SAME RESET AFTER THE CONSTRUCTION HAS PASSED THE AREA.

CLEARING AND GRUBBING

- 1. THE CONTRACTOR SHALL INCLUDE ALL NECESSARY PRECAUTIONS TO PROTECT AND SAVE ALL TREES WHICH ARE ADJACENT TO THE LINE OF WORK AND SHALL REMOVE ONLY THOSE TREES WHICH ARE DESIGNATED FOR REMOVAL ON THE PLANS OR DIRECTED BY THE ENGINEER. TREE ROOTS AND OVERHANGING BRANCHES SHALL BE CUT, EXCEPT WITH SPECIAL PERMISSION OF THE ENGINEER. WHEN REQUIRED, THE CUTTING OF ROOTS AND BRANCHES SHALL BE DONE IN A MANNER TO LEAVE A SMOOTH END WITHOUT SPLITTING OR CRUSHING. THE CUT END SHALL BE NEATLY TRIMMED. ALL DAMAGE SHALL BE REPAIRED BY THE CONTRACTOR AT HIS OWN EXPENSE TO THE SATISFACTION OF THE ENGINEER. WHERE MISCELLANEOUS SMALL TREES AND SHRUBS ARE NOTED TO BE REMOVED AND RESET, THE COST OF SUCH WORK SHALL BE CONSIDERED INCIDENTAL TO THE COMPLETION OF THE PROJECT.
- 2. IF THE PROJECT IS LOCATED WITHIN THE RANGE OF THE FEDERALLY-ENDANGERED INDIANA BAT (MYOTIS SODALIS) AND TREES MUST BE CUT, THIS MUST OCCUR BETWEEN SEPTEMBER 30 AND APRIL 1. INDIANA BATS ARE HIGHLY-DEPENDENT UPON TREES INCLUDING DEAD AND DYING TREES OF SPECIES WITH EXFOLIATING BARK, CREVICES, OR CAVITIES IN UPLAND AREAS OR RIPARIAN CORRIDORS AND LIVING TREES OF THE SPECIES LISTED ABOVE WITH EXFOLIATING BARK, CAVITIES, OR HOLLOW AREAS FORMED FROM BROKEN BRANCHES OR TOPS. IF SUITABLE TREES MUST BE CUT DURING THE PROHIBITED TIME PERIOD, A NET SURVEY MUST BE CONDUCTED TO DETERMINE THE PRESENCE OR ABSENCE OF INDIANA BATE PRIOR TO CUTTING.



rdantas

8150 MEN (440)

 OHIO
 DESIGNED BY:
 CAS
 REVIEW
 NO
 REVISIO

 CHECKED BY:
 CAS
 REVISIO
 REVISIO

 CHECKED BY:
 CAS
 REVISIO
 REVISIO

FAST EQ BASIN
ASE II
WILLOUGHBY, OHI
L-00 SERIES

PHAS

COUNTY

GENERAL - (

PROJECT NO.

230264

DISCIPLINE

GENERAL

SHEET NAME

00-G-04

SHEET 0

TREES/VEGETATION PROTECTION

- 1. TREE REMOVAL WILL BE LIMITED TO THAT NECESSARY FOR CONSTRUCTION AND WILL BE LIMITED FURTHER TO THE PERMANENT EASEMENT WHENEVER POSSIBLE.
- 2. SOIL AND OTHER MATERIAL WILL NOT BE STORED NEXT TO OR WITHIN THE DRIP-LINE OF TREES.

USE OF ROADS

1. ALL PROJECT VEHICLES, INCLUDING THOSE HAULING EQUIPMENT AND/OR MATERIALS TO OR FROM THE SITE SHALL UTILIZE STATE ROUTES ONLY. THE USE OF LOCAL ROADS BY THE CONTRACTOR IS PROHIBITED.

EXCAVATION PUMPING AND DEWATERING

- CONVEY ANY TURBID WATER REMOVED FROM EXCAVATIONS IN A CLOSED CONDUIT TO A SETTLING POND OR FILTERING DEVICE, BEFORE RELEASE FROM THE CONSTRUCTION SITE OR ASSOCIATED DISTURBED AREAS. DO NOT USE TRENCH EXCAVATIONS AS TEMPORARY DRAINAGE CHANNELS.
- 2. PRIOR TO INSTALLING GROUNDWATER DEWATERING WELLS, CONTACT THE OHIO DEPARTMENT OF NATURAL RESOURCES, DIVISION OF WATER (614-265-6740) FOR REPORTING REQUIREMENTS AND ABANDONMENT OF DEWATERING WELLS.
- 3. GROUNDWATER WHICH DOES NOT CONTAIN SEDIMENT OR OTHER POLLUTANTS IS NOT REQUIRED TO BE TREATED PRIOR TO DISCHARGE FROM THE CONSTRUCTION SITE. SEDIMENT FREE WATER SHALL NOT BE DIRECTED TO THE CONSTRUCTION STORM WATER TREATMENT SYSTEM.
- 4. DISCHARGE SEDIMENT FREE GROUNDWATER TO STABILIZED SITES, SUCH AS UNCUT GRASSED SWALES, STREAMS OR STORM SEWERS. DO NOT DISCHARGE FLOWS ONTO DISTURBED AREAS, EXPOSED SOILS IN DRAINAGES OR STREAM BANKS, OR ANY OTHER SITE WHERE THE FLOW COULD CAUSE EROSION.
- 5. WRITTEN PERMISSION OF THE PROPERTY OWNER AND THE CONSENT OF THE ENGINEER MUST BE OBTAINED TO RUN WELL POINT OR PUMP DISCHARGE LINES THROUGH PRIVATE PROPERTY, PUBLIC PROPERTY OR RIGHTS-OF-WAY.

PROHIBITED CONSTRUCTION ACTIVITIES

- 1. THE USE OF EXPLOSIVES WITHIN CITY LIMITS, UNLESS A PERMIT IS ISSUED BY THE CITY.
- 2. PUMPING OF SEDIMENT-LADEN WATER FROM TRENCHES OR OTHER EXCAVATIONS DIRECTLY INTO ANY SURFACE WATERS, STREAM CORRIDORS, OR STORM SEWERS; ALL SUCH WATER WILL BE PROPERLY FILTERED OR SETTLED TO REMOVE SILT PRIOR TO RELEASE.
- 3. DISCHARGING POLLUTANTS SUCH AS CHEMICALS, FUELS, LUBRICANTS, BITUMINOUS MATERIALS, RAW SEWAGE, OR ANY OTHER HARMFUL WASTE INTO OR ALONGSIDE OF RIVERS, STREAMS, IMPOUNDMENTS OR INTO NATURAL OR MAN-MADE CHANNELS LEADING THERETO:
- 4. OPEN BURNING OF PROJECT DEBRIS WITHOUT A PERMIT.
- 5. STORING CONSTRUCTION EQUIPMENT AND VEHICLES AND/OR STOCKPILING CONSTRUCTION MATERIALS ON PROPERTY, PUBLIC OR PRIVATE, NOT PREVIOUSLY SPECIFIED ON THE PLANS BY THE ENGINEER FOR SUCH PURPOSES;
- 6. RUNNING WELL POINT OR PUMP DISCHARGE LINES THROUGH PRIVATE OR PUBLIC PROPERTY AND RIGHTS-OF-WAY WITHOUT PERMISSION OF THE PROPERTY OWNER AND THE CONSENT OF THE ENGINEER;
- 7. OPERATION ENTAILING THE USE OF VIBRATORY HAMMERS OR COMPACTORS OUTSIDE THE THE HOURS OF 8:00 AM AND 5:00 PM OR OUTSIDE THE HOURS ALLOWED BY LOCAL ORDINANCES OR REGULATIONS;
- 8. CLOSING OFF CLEAR ACCESS TO ANY PUBLIC ALLEY, STREET, ROAD, AVENUE OR BOULEVARD WITHOUT THE PRIOR CONSENT OF MUNICIPAL OFFICIALS AND THE ENGINEER AND CLOSING CLEAR ACCESS:
- BY FIRE PROTECTION EQUIPMENT AND EMERGENCY VEHICLES;
- BY THE PUBLIC TO ANY COMMERCIAL OR PROFESSIONAL PLACE OF BUSINESS, QUASI-PUBLIC OR PUBLIC ESTABLISHMENT, OR PLACE OF RESIDENCE
- BY VEHICLES TO DRIVEWAYS WITHOUT THE PROVISION OF ALTERNATIVE MEANS OF BUILDING INGRESS AND EGRESS.

SANITARY BYPASS PUMPING

- 1. BYPASS PUMPING SHALL BE PROVIDED WHENEVER FLOW IN ANY SEWER IS DISRUPTED BY THE CONSTRUCTION OF NEW SEWER REPLACEMENTS, LATERALS, MANHOLES, OR ASSOCIATED ACTIVITIES.
- 2. CONTRACTOR SHALL PROVIDE A DETAILED BYPASS PUMPING PLAN AND SCHEDULE TO THE OWNER FOR REVIEW PRIOR TO BEGINNING ANY WORK.
- 3. BYPASS PUMPING IS REQUIRED WHENEVER FLOW IN ANY SEWER IS DISRUPTED BY THE CONSTRUCTION OR REPLACEMENT OF NEW SEWER SEGMENTS, LATERALS, MANHOLES, OR ASSOCIATED ACTIVITIES. BYPASSING OF SEWERS MUST PROVIDE FOR POTENTIAL FLOWS THAT MAY TYPICALLY BE EXPECTED DURING THE SEASON THAT THE WORK IS IN PROGRESS, INCLUDING RAINFALL AND PEAK FLOW EVENTS.
- 4. METERING OF FLOWS HAS NOT BEEN PERFORMED. THE CONTRACTOR MAY ASSUME FULL PIPE CONDITIONS FOR SIZING BYPASS PUMPING REQUIREMENTS.
- 5. BECAUSE OF THE HIGH FLOWS POSSIBLE IN THESE SEWERS, THE CONTRACTOR SHALL HAVE A CONTINGENCY PLAN TO PREVENT DAMAGE DURING HIGH FLOWS. THE OWNER WILL NOT BE RESPONSIBLE FOR DAMAGES DUE TO HIGH FLOWS.
- 6. CONTRACTOR SHALL REVIEW AND COORDINATE WITH THE MAINTENANCE OF TRAFFIC PLANS PRIOR TO SUBMITTING THE BYPASS PUMPING PLAN.
- 7. PUMPS SHALL BE FULL AUTOMATIC, SELF PRIMING PUMPS. PUMPS AND GENERATORS, IF APPLICABLE, SHALL BE CRITICALLY SILENCED. ALL SUCTION AND DISCHARGE PIPING SHALL BE FREE OF LEAKS.
- 8. ACCESS TO ALL RESIDENCES AND BUSINESSES SHALL BE MAINTAINED AT ALL TIMES, INCLUDING ACCESS FOR MAIL, SCHOOL, POLICE, FIRE, AND EMERGENCY VEHICLES.
- 9. PRIOR TO NOTIFICATION OF SHORT DURATION INTERRUPTIONS TO SERVICE SHALL BE COORDINATED A MINIMUM OF 48 HOURS IN ADVANCE, EXCLUDING WEEKENDS AND HOLIDAYS, WITH THE OWNER AND ALL AFFECTED RESIDENTS AND BUSINESSES.

SANITARY SEWER NOTES

- 1. SANITARY SEWERS SHALL MAINTAIN A MINIMUM OF 18" VERTICAL AND 10' HORIZONTAL FROM ANY WATER MAIN.
- 2. SANITARY SEWER MUST BE A MINIMUM OF 4' HORIZONTALLY, MEASURED EDGE-TO-EDGE, FROM STORM SEWERS AND GAS LINES AND MUST MAINTAIN A MINIMUM 18" VERTICAL CLEARANCE AT ANY UTILITY LINE.
- 3. SANITARY SEWER AND MANHOLE TESTING REQUIREMENTS:
- LEAKAGE TESTING SHALL BE HYDROSTATICALLY TESTED IN ACCORDANCE WITH SPECIFICATION SECTION 013319 AND RSFW 33.93 AND 33.94.
- DEFLECTION TESTING SHALL BE IN ACCORDANCE WITH SPECIFICATION SECTION 013319 AND RSFW 33.85.
- MANHOLES SHALL BE VACUUM TESTED IN ACCORDANCE WITH SPECIFICATION SECTION 013319 AND RSFW 34.7.
- 4. TRENCHING, BEDDING, AND BACKFILL SPECIFICATIONS SHALL BE IN ACCORDANCE WITH SPECIFICATION SECTION 333100 AND CONSTRUCTION DETAILS.
- 5. SANITARY SEWER FOR OPEN CUT SHALL BE IN ACCORDANCE WITH SPECIFICATION SECTION 331100
- 6. CONTRACTOR SHALL INSTALL DROP STRUCTURES IF INVERTS ARE MODIFIED AND PIPE INLET INVERT ABOVE THE MANHOLE INVERT IS 24" OR GREATER.
- 7. WHEN EMPTY DURING CONSTRUCTION, THE STRUCTURES MAY BECOME BUOYANT. IN THE EVENT THAT THE EXCAVATIONS BECOME FLOODED, THE STRUCTURES MUST BE FILLED WITH WATER TO PREVENT FLOTATION OR THE EXCAVATION IS TO BE KEPT DEWATERED.

MAINTENANCE OF TRAFFIC


- 1. IT IS THE CONTRACTORS RESPONSIBILITY TO MAINTAIN PEDESTRIAN AND LOCAL ROADWAY ACCESS AT ALL TIMES. THE CONTRACTOR SHALL FURNISH AND INSTALL TEMPORARY STONE DRIVES WITH A MATERIAL WHICH IS APPROVED IN WRITING BY THE ENGINEER. THE CONTRACTOR SHALL INSTALL TEMPORARY TRENCH TOPPING(SEE DETAIL) IN ALL ROADS AS PART OF THE BACKFILLING OPERATION. THE TEMPORARY PAVEMENT AND STONE DRIVES SHALL BE MAINTAINED TO THE SATISFACTION OF THE ENGINEER. COST FOR ALL MATERIALS, LABOR AND EQUIPMENT FOR CONSTRUCTION MAINTENANCE AND SUBSEQUENT REMOVAL SHALL BE INCLUDED IN THE UNIT PRICES FOR ALL ITEMS OF THE PROPOSAL.
- 2. ALL TRAFFIC CONTROL SHALL BE IN ACCORDANCE WITH THE "OHIO MANUAL OF UNIFORM TRAFFIC CONTROL DEVICES". AS A MINIMUM THE CONTRACTOR SHALL SUBMIT A PROPOSED TRAFFIC CONTROL PLAN FOR REVIEW AND ACCEPTANCE BY THE ENGINEER PRIOR TO BEGINNING WORK.
- 3. ACCESS MUST BE MAINTAINED FOR RESIDENCES, EMERGENCY VEHICLES AND PEDESTRIANS, INCLUDING PERSONS WITH DISABILITIES. AT ALL TIMES.
- 4. AT ALL EXCAVATION LOCATIONS THE CONTRACTOR SHALL PROVIDE SUITABLE FLASHERS, BARRICADES, AND TRAFFIC CONTROL DEVICES AS DEEMED NECESSARY BY THE ENGINEER AND IN ACCORDANCE WITH THE "MANUAL ON UNIFORM TRAFFIC CONTROL DEVICES (MUTCD).
- 5. THE CONTRACTOR SHALL PHASE CONSTRUCTION SUCH THAT AT A MINIMUM, ONE ACCESS LANE IS AVAILABLE FOR LOCAL VEHICULAR TRAFFIC. THE PAVEMENT SURFACE SHALL HAVE A UNIFORM SURFACE TO THE SATISFACTION OF THE OWNER. THE SAME ACCESS SHALL BE MAINTAINED TO ALL DRIVEWAYS. ALL OTHER AREAS SHALL BE CLOSED TO TRAFFIC WITH SIGNS AND BARRICADES TO ODOT STANDARDS. THE SURFACES SHALL CONSIST OF THE FOLLOWING MATERIALS:
- EXISTING PAVEMENT SURFACE.
- ODOT 304 LIMESTONE TEMPORARY TRENCH TOPPING

NOISE CONTROL AND AIR POLLUTION PRACTICES AND REQUIREMENTS

- CONSTRUCTION ACTIVITIES WILL BE LIMITED TO WEEKDAY DAYTIME HOURS, UNLESS APPROVED IN ADVANCE BY THE OWNER.
- 2. CONSTRUCTION EQUIPMENT WILL BE PROVIDED WITH INTAKE SILENCERS AND MUFFLERS, AS REQUIRED BY SAFETY STANDARDS.
- 3. PERIODICALLY CHECK EQUIPMENT AND MACHINERY FOR PROPER TUNING TO MINIMIZE EXHAUST EMISSIONS AND NOISE.
- 4. ALL CONSTRUCTION VEHICLES SHOULD BE EQUIPPED WITH PROPER EMISSIONS CONTROL EQUIPMENT.
- 5. UNPAVED AREAS WILL BE WET DOWN (AS NECESSARY) DAILY OR AS NECESSARY DURING CONSTRUCTION TO MINIMIZE DUST GENERATION.
- 6. STREET SWEEPING WILL BE REQUIRED ON A WEEKLY BASIS FOR DUST CONTROL. NO SEPARATE PAYMENT SHALL BE MADE.

EROSION AND SEDIMENT CONTROL

- 1. THE CONTRACTOR IS RESPONSIBLE FOR SUBMITTING AN APPROVED EROSION CONTROL AND STORMWATER POLLUTION CONTROL PLAN FOR ALL IMPROVEMENTS. THIS SHALL INCLUDE SUBMITTAL OF A NOTICE OF INTENT PERMIT TO OHIO EPA. THIS SHALL BE INCLUDED AS A PART OF THE WORK DETAILED WITHIN THE CONTRACT AND NO ADDITIONAL PAYMENT SHALL BE MADE.
- 2. ALL MATERIALS TO BE DISPOSED OF OFF-SITE MUST BE DISPOSED OF IN AN ENVIRONMENTALLY SOUND MANNER IN ACCORDANCE WITH LOCAL, STATE AND FEDERAL REGULATIONS AT A SITE APPROVED BY THE ENGINEER. NO EXCESS MATERIALS ARE TO BE DISPOSED OF IN ANY WETLAND, FLOODPLAIN, SURFACE WATER, OR OTHER ENVIRONMENTALLY SENSITIVE AREAS. EROSION CONTROL MEASURES AT THE DISPOSAL SITE MUST BE INSTALLED AND MAINTAINED UNTIL DISPOSAL IS COMPLETE AND THE DISPOSAL SITE IS PERMANENTLY STABILIZED. GIVING EXCAVATED SOIL AWAY DOES NOT RELIEVE THE CONTRACTOR OR ENGINEER OF THIS RESPONSIBILITY.
- 3. PROPERLY INSTALL EROSION CONTROLS (E.G., SILT FENCES, STRAW BALES, ETC.) ON SLOPES, ALONG STREAMS AND DRAINAGE WAYS, AROUND DRAINAGE STRUCTURES, WETLANDS AND ANYWHERE ELSE THAT EXPOSED SOIL COULD RUN OFF. ALL SEDIMENT CONTROL MEASURES SHALL BE IN PLACE PRIOR TO STARTING CONSTRUCTION.
- 4. NO MORE THAN 200 FEET OF TRENCH SHALL BE OPEN AT ANY GIVEN TIME. TRENCH OPENING, PIPE LAYING, AND BACKFILLING SHOULD OCCUR SO AS TO MINIMIZE THE AMOUNT OF DISTURBED AREA.

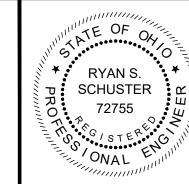

dantas

8150 STERLING COURMENTOR, OHIO 44060


ITY OF WILLOUGHBY	ISSUED FOR:	REVIEW	ON	REVISION	DATE
ESHORE EAST EO BASIN	ISSUE DATE:	10/3/2025			
	SCALE:	N/A			
Y WILLOUGHBY, OHIO	DESIGNED BY:	CAS			
GENERAL - 00 SERIES	DRAWN BY:	CAS			
GENERAL NOTES	CHECKED BY:	RSS			

GENERAL

SHEET NAME


00-G-05


SHEET OF

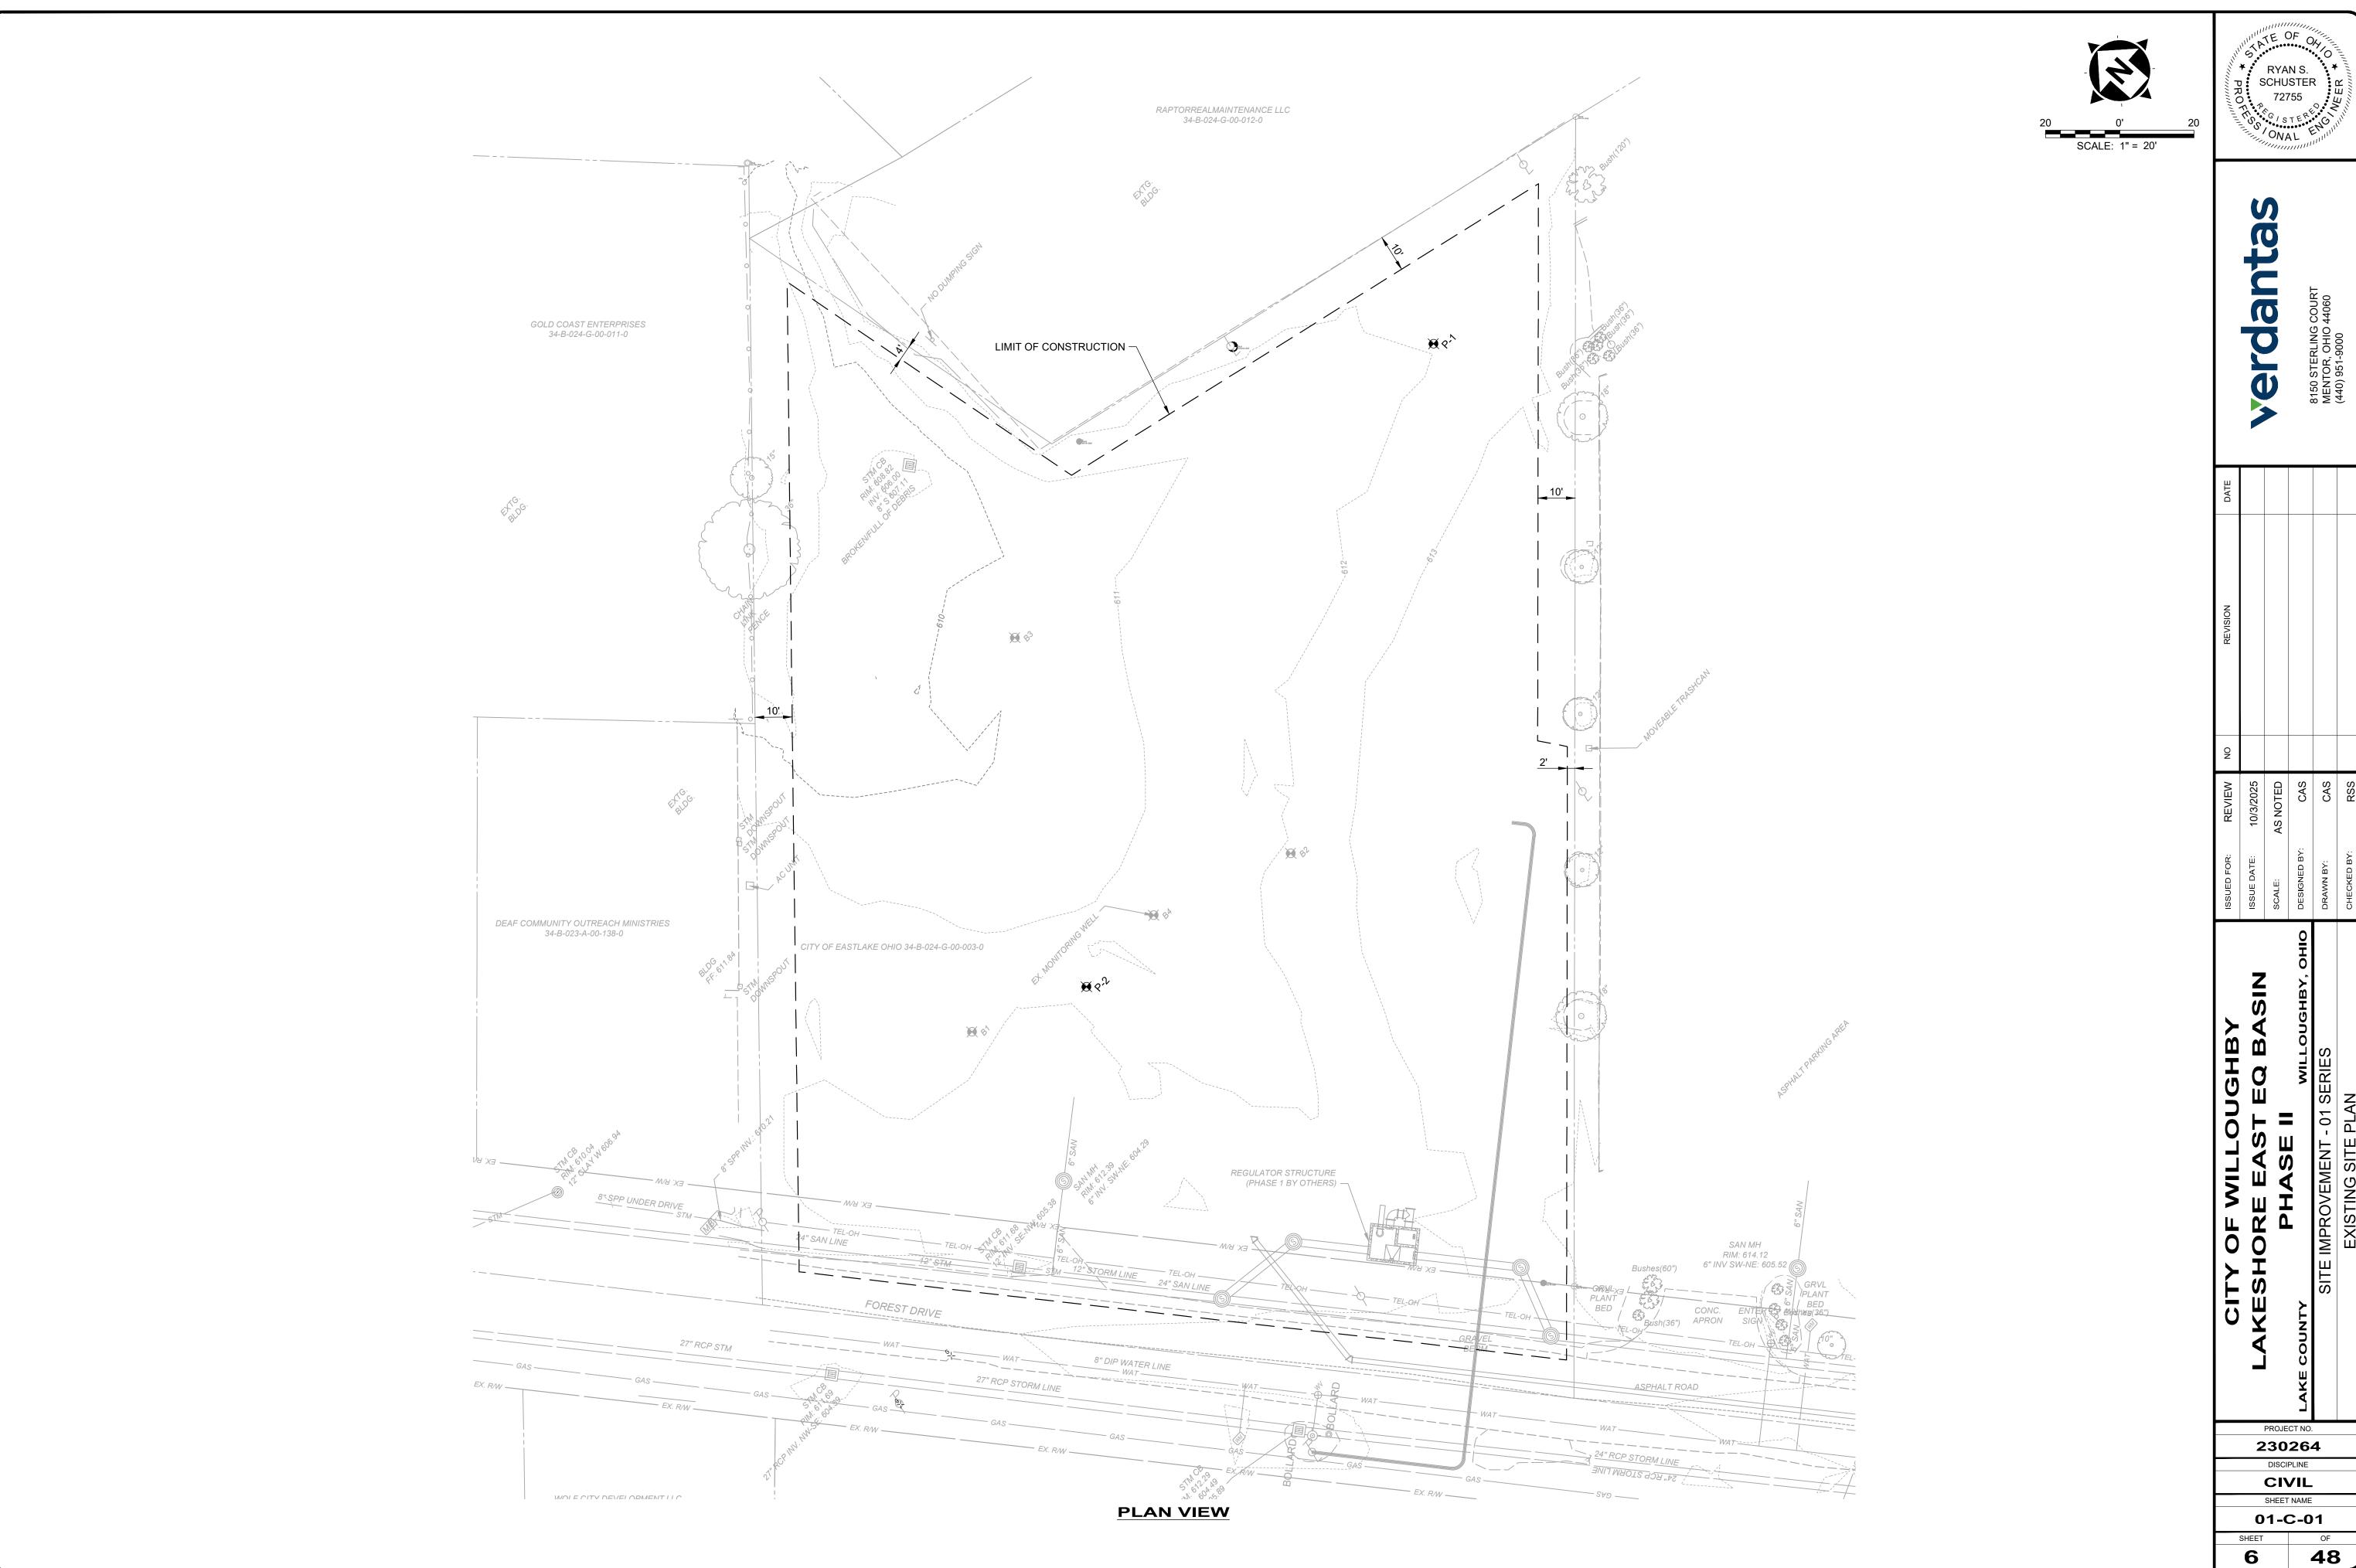


H:\2023\230264\DWG\SHEETS\PHASE II\C_230264 - EXISTING SITE PLAN PHASE II.DWG - 6 EXISTING SITE PLAN - 9/30/2025 1:09:15 PM - CORY SCOTT



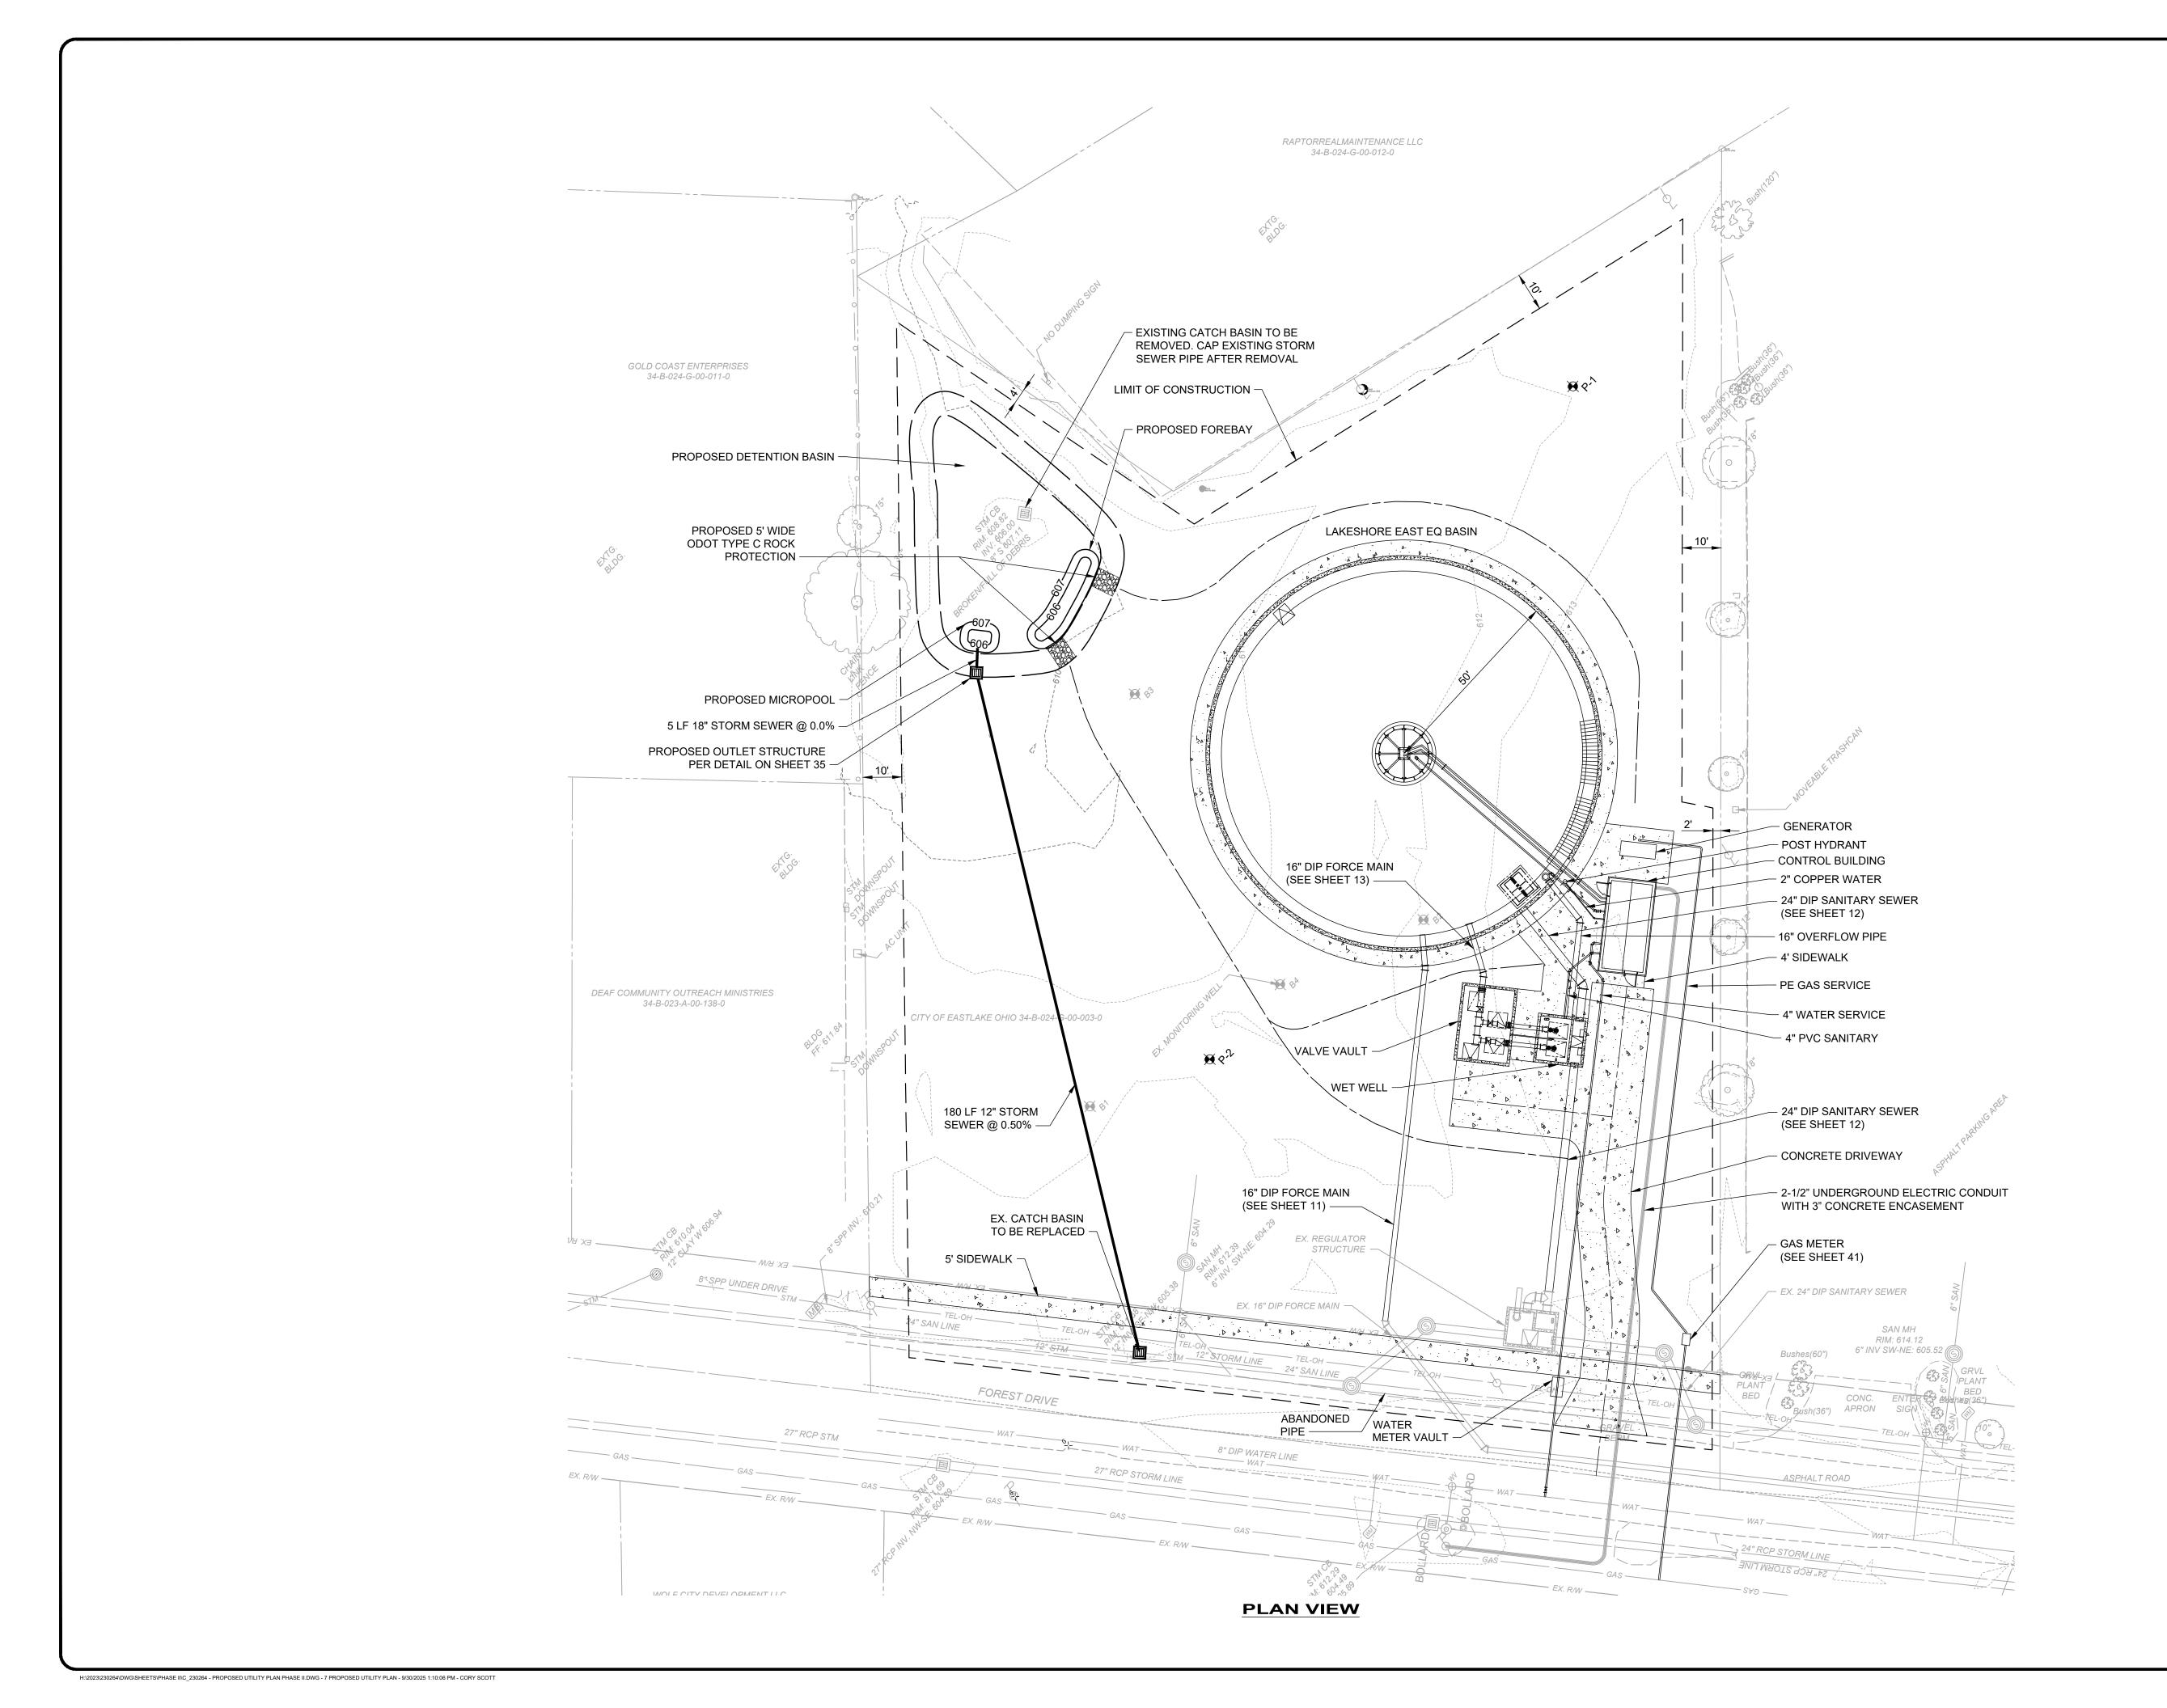

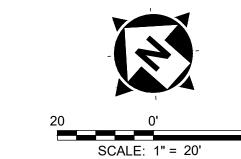

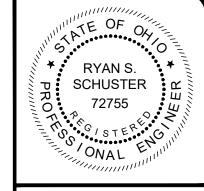

CITY OF WILLOUGHBY	ISSUED FOR:	REVIEW	ON	REVISION	DATE	1
LAKESHORE EAST EO BASIN	ISSUE DATE:	10/3/2025				
	SCALE:	AS NOTED				
LAKE COUNTY WILLOUGHBY, OHIO	DESIGNED BY:	CAS				
SITE IMPROVEMENT - 01 SERIES	DRAWN BY:	CAS				MENTOR, OHIO 44060
PROPOSED UTILITY PLAN	CHECKED BY:	RSS				(440) 951-9000

PROJECT NO.


230264

DISCIPLINE


CIVIL

SHEET NAME

01-C-02

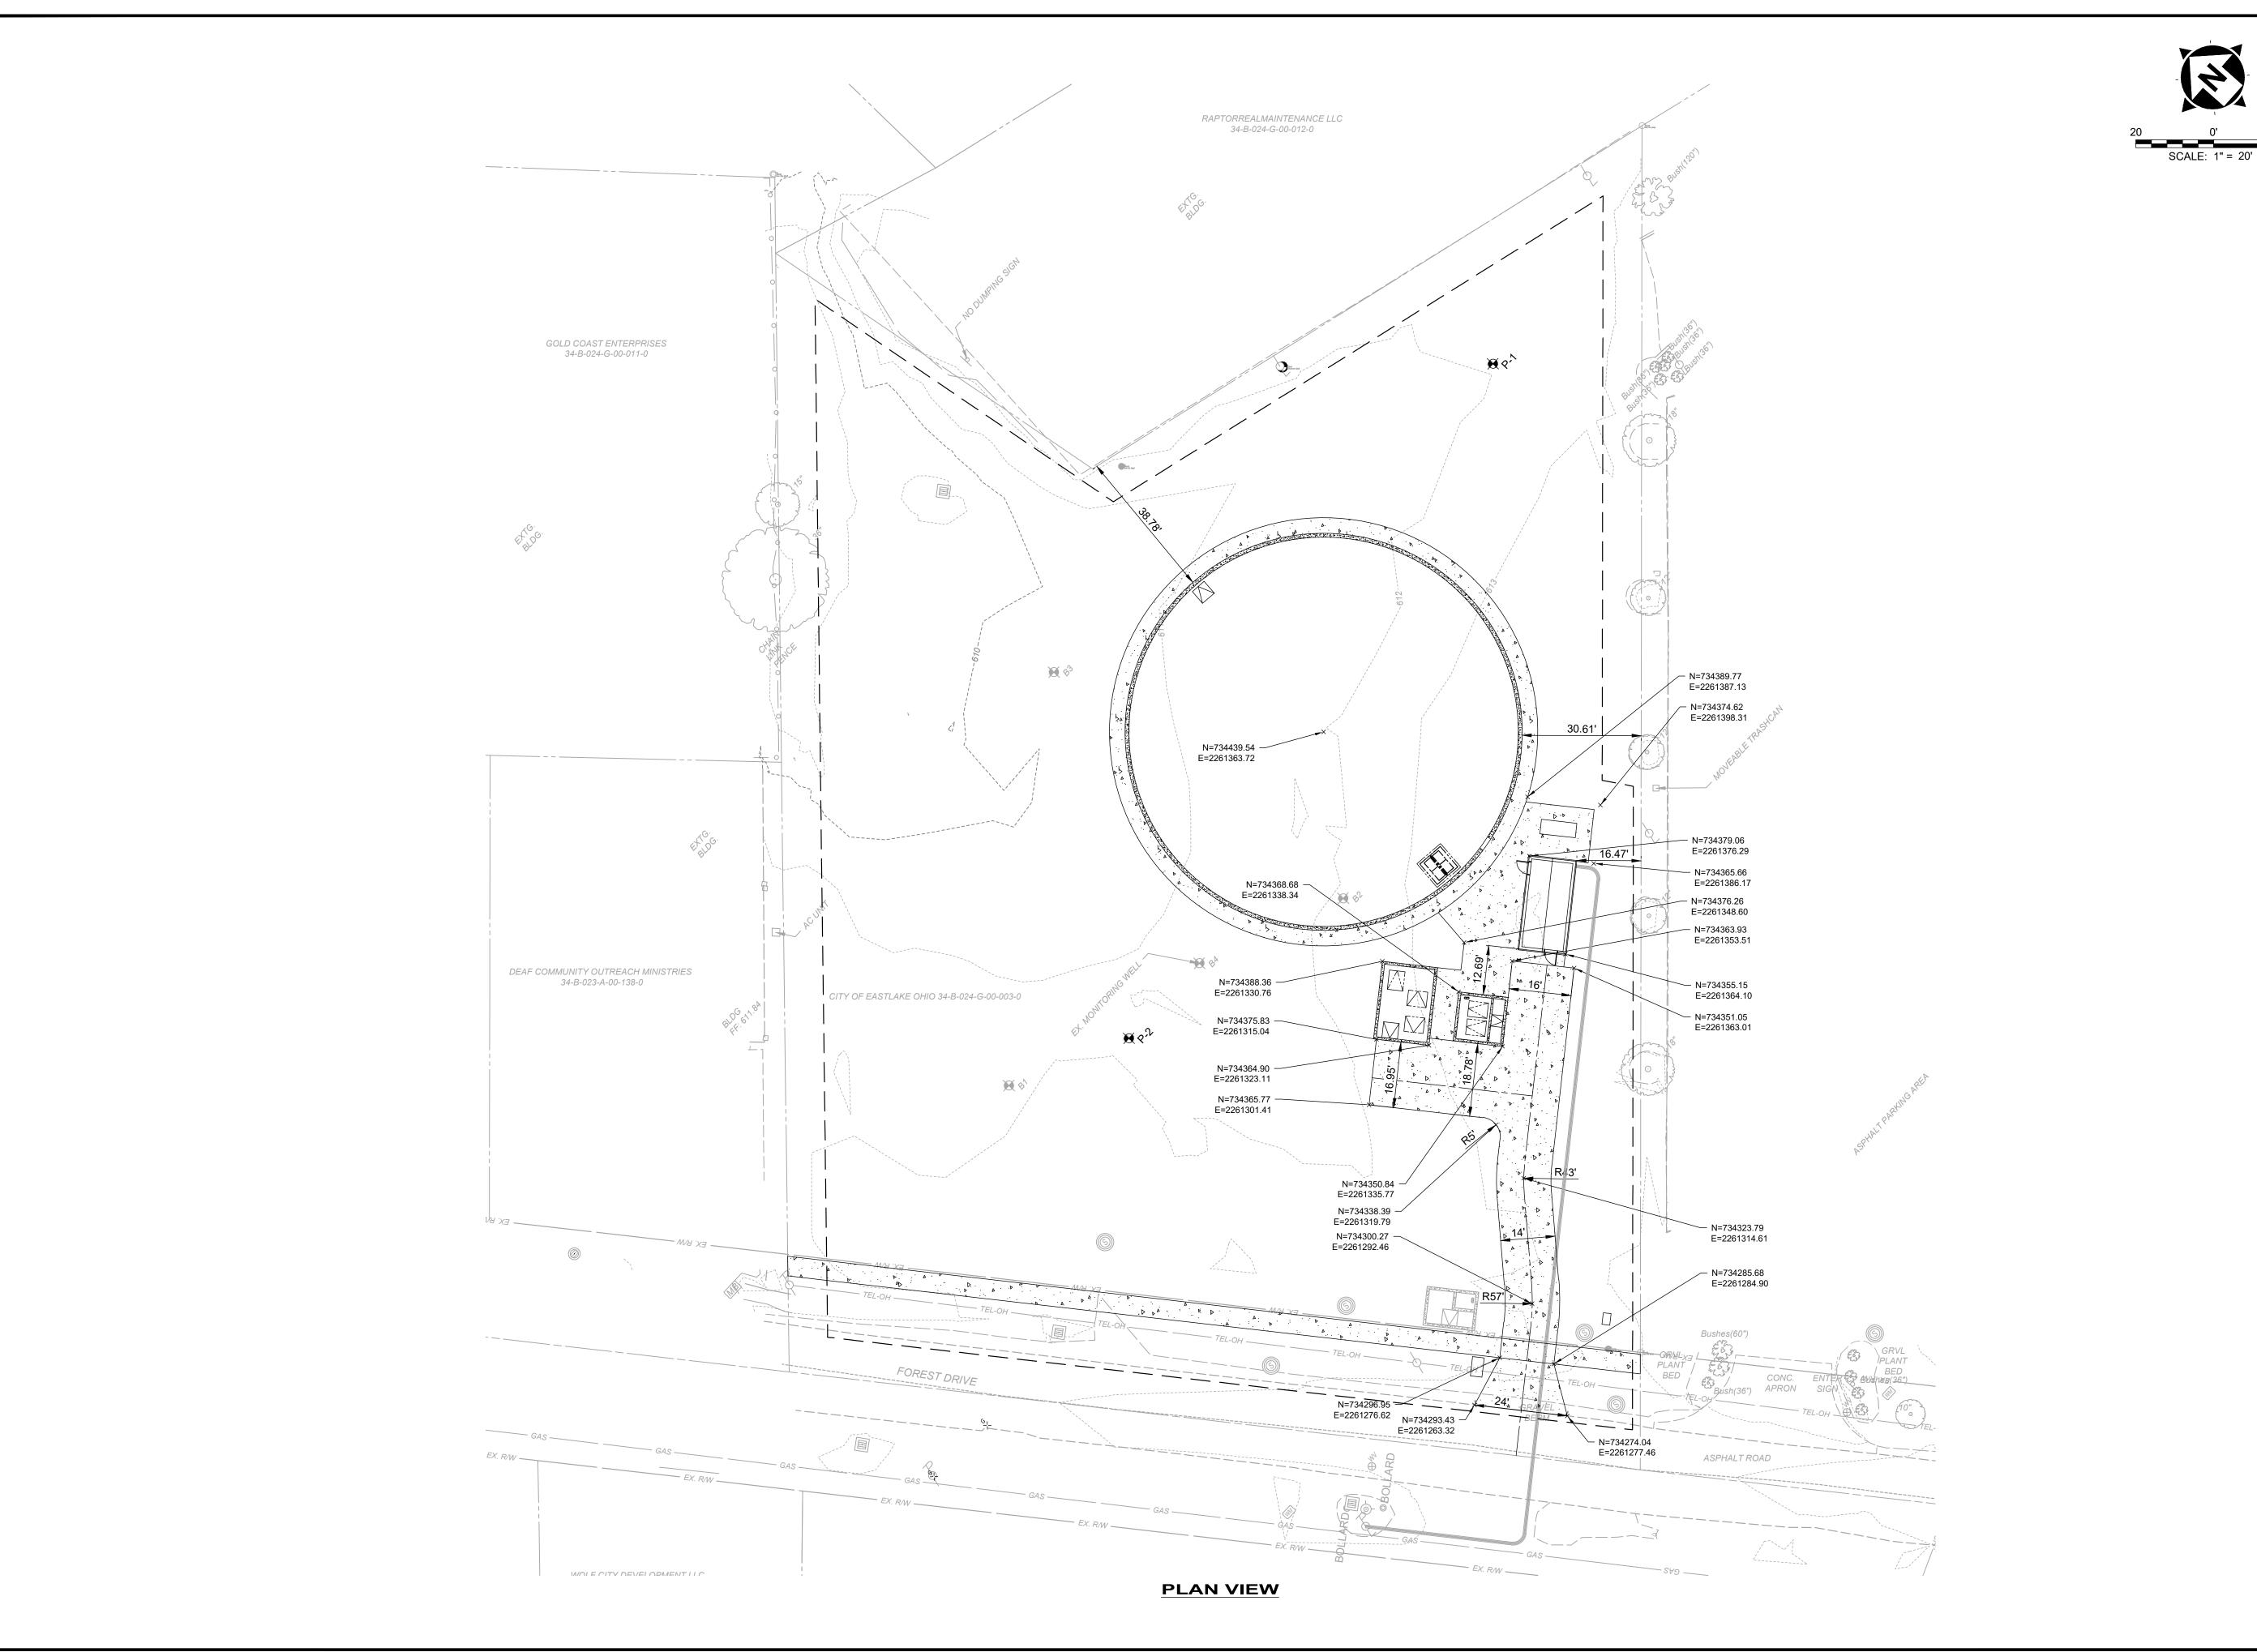

H:\2023\230264\DWG\SHEETS\PHASE II\C_230264 - PROPOSED SITE PLAN PHASE II\DWG - 8 PROPOSED SITE PLAN - 9/30/2025 1:11:40 PM - CORY SCOTT

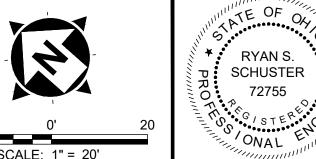

PROJECT NO.

230264


DISCIPLINE

CIVIL

SHEET NAME

01-C-03
SHEET OF

8 48

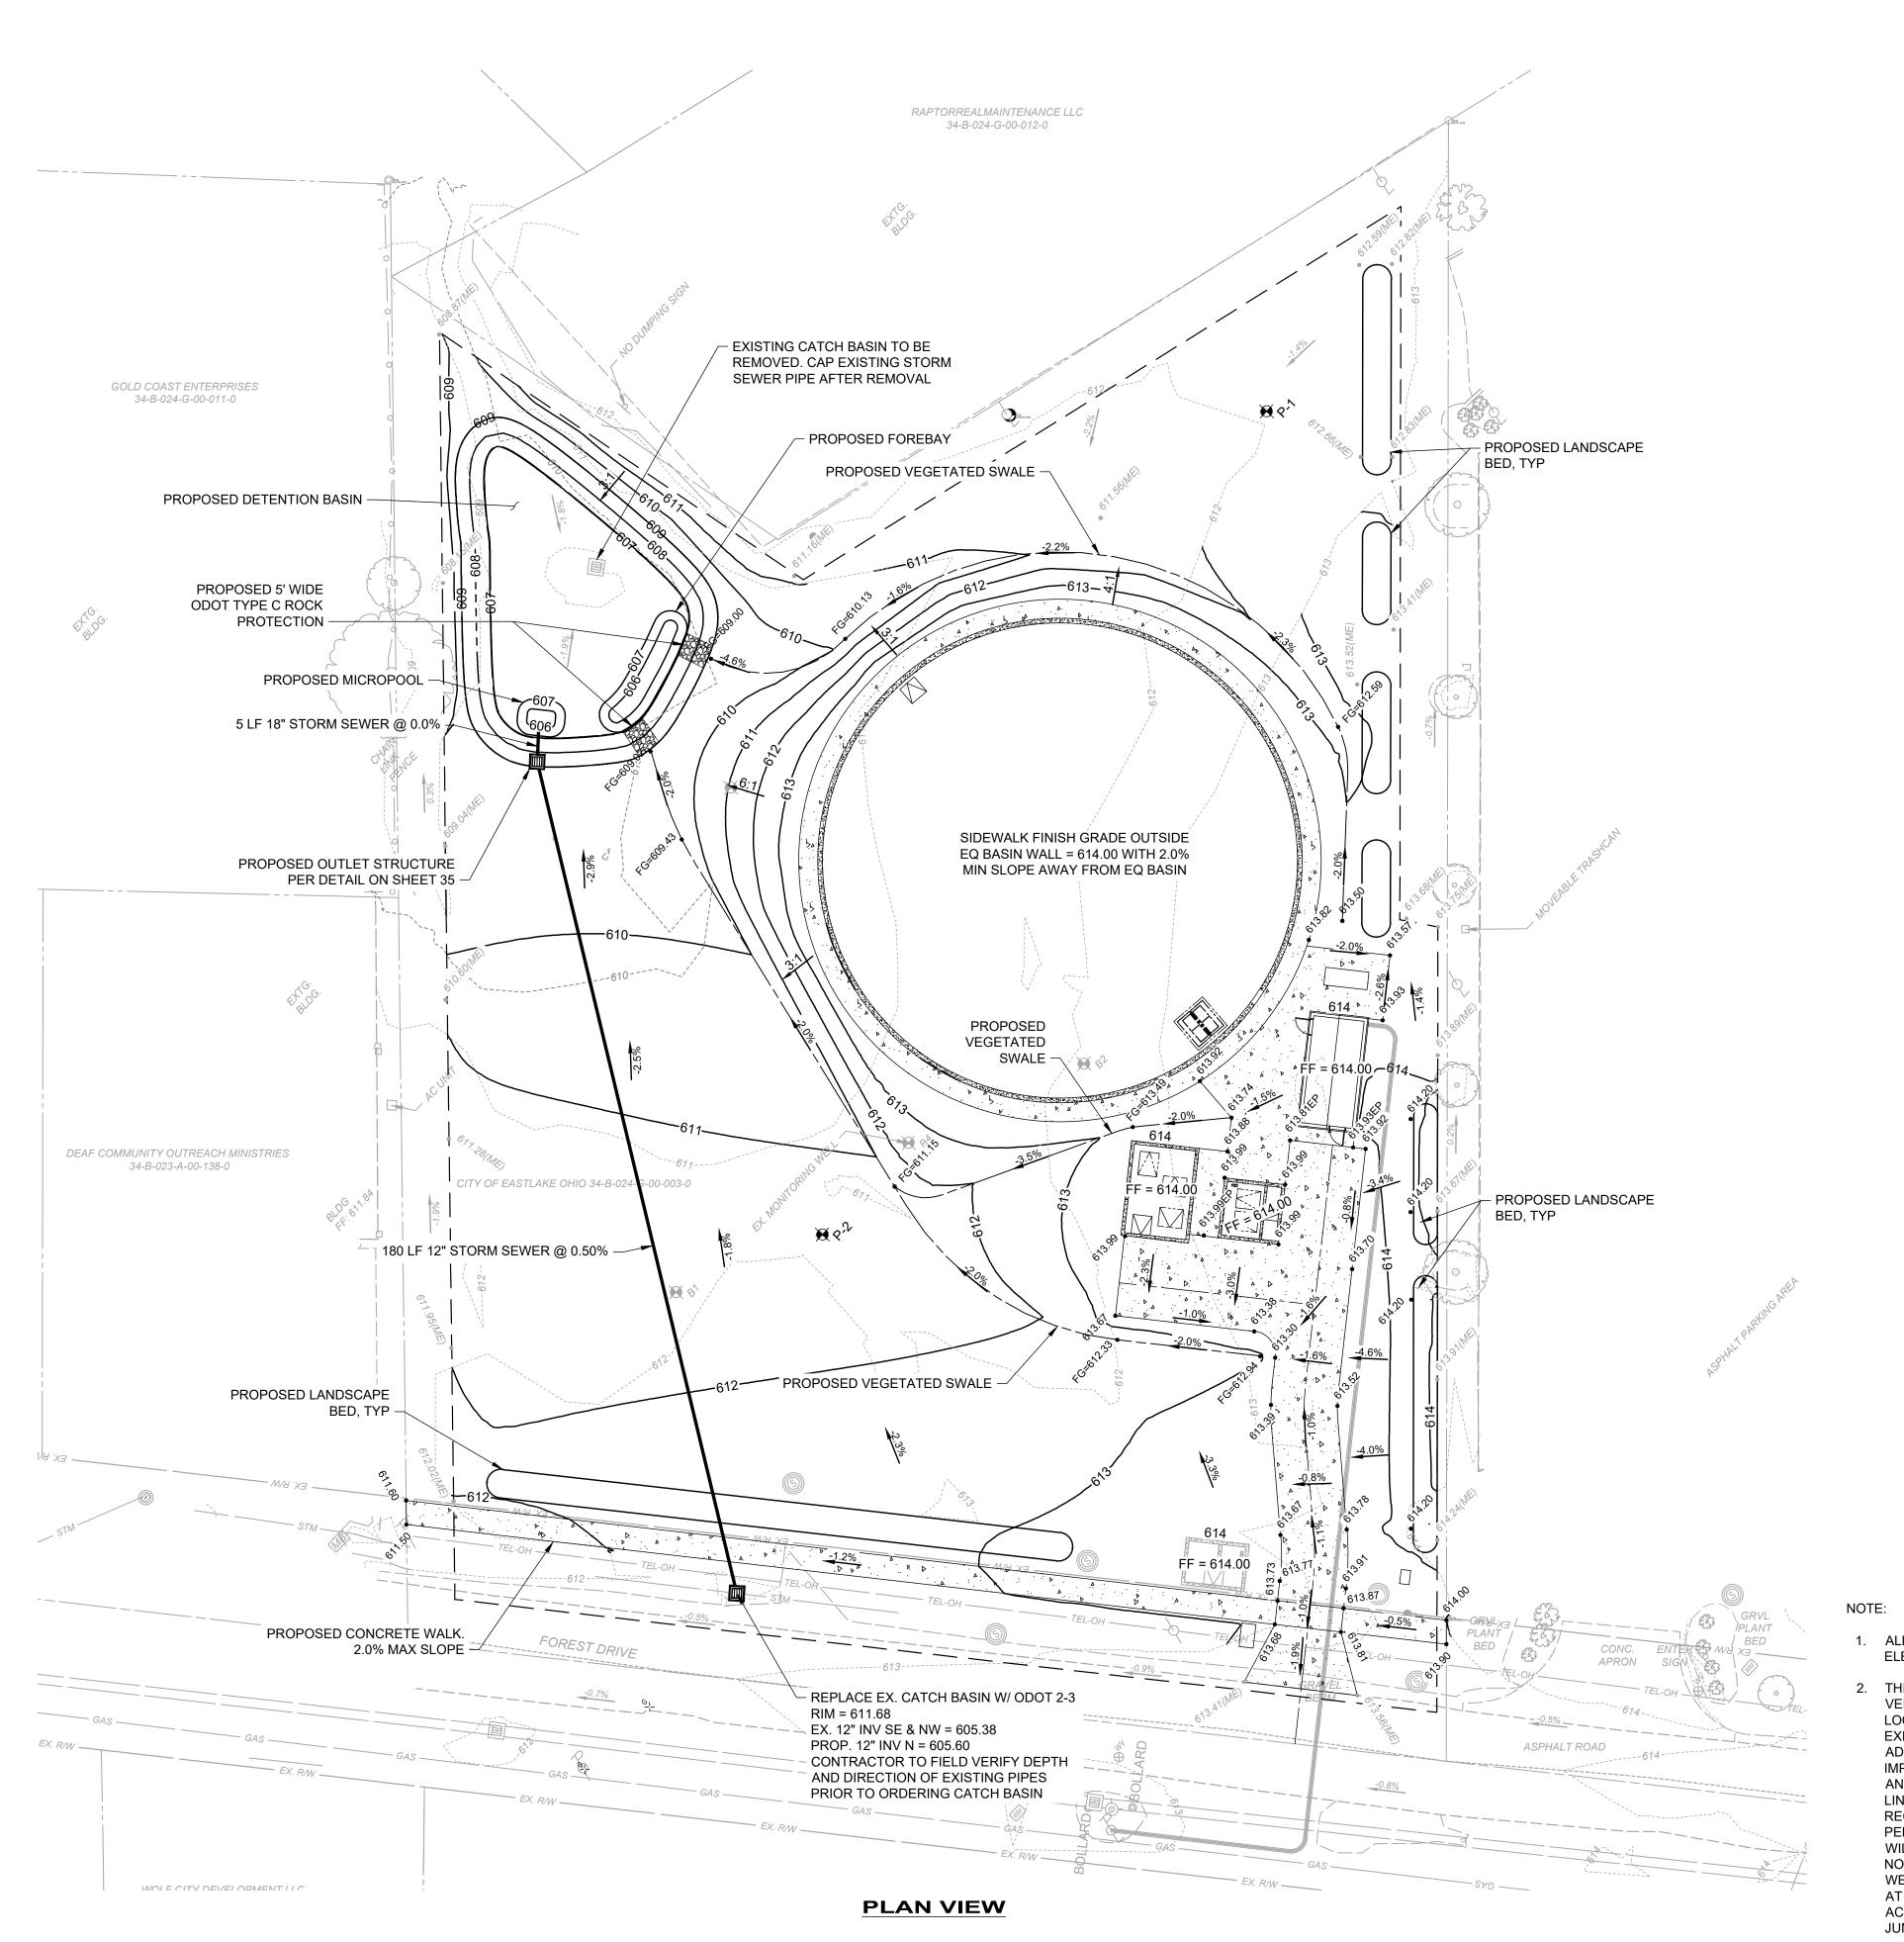

H:\2023\230264\DWG\SHEETS\PHASE II\C_230264 - PROPOSED GRADING PLAN.DWG - 9 PROPOSED GRADING PLAN - 9/30/2025 1:18:10 PM - CORY SCOTT

RYAN S.

RYAN S.

SCHUSTER

72755

W
ONAL

SCALE: 1" = 20'

dantas

8150 STERLING COURT MENTOR, OHIO 44060

10/3/2025	AS NOTED	VALUE	VALUE	RSS
ISSUE DATE:	SCALE:	DESIGNED BY:	DRAWN BY:	СНЕСКЕD ВҮ:
7	ı	ЈGНВҮ, ОНІО		
N S S	! !	IВY		

- ALL SPOT GRADES SHOWN ARE FINISH SURFACE ELEVATIONS UNLESS NOTED OTHERWISE.
- 2. THE CONTRACTOR SHALL BE RESPONSIBLE TO VERIFY THE EXISTENCE AS WELL AS THE ACTUAL LOCATION, ALIGNMENT, AND ELEVATIONS OF ALL EXISTING UTILITIES/FACILITIES WITHIN AND/OR ADJACENT TO THE GENERAL LIMITS OF THESE IMPROVEMENTS INCLUDING WATERLINES, SANITARY AND STORM SEWERS, GAS LINES, COMMUNICATION LINES/BANKS, ELECTRIC LINES, ETC. THIS MAY REQUIRE EXPLORATORY EXCAVATIONS TO BE PERFORMED BY THE CONTRACTOR FOR WHICH HE WILL NOT BE REIMBURSED. THE CONTRACTOR SHALL NOT ASSUME THAT EXISTING UTILITIES/CONDUITS WERE INSTALLED AT TYPICAL/STANDARD DEPTHS OR AT UNIFORM SLOPES/GRADES/DEPTHS BETWEEN ACCESS POINTS (CATCH BASINS, MANHOLES, JUNCTION CHAMBERS, ETC.)

PROJECT NO.

230264


DISCIPLINE


CIVIL

SHEET NAME

01-C-04

HEET OF

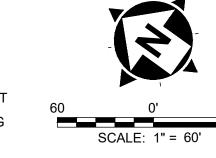

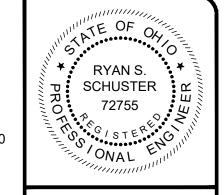


CIVIL SHEET NAME

01-C-05

10 48




PAVING PLAN

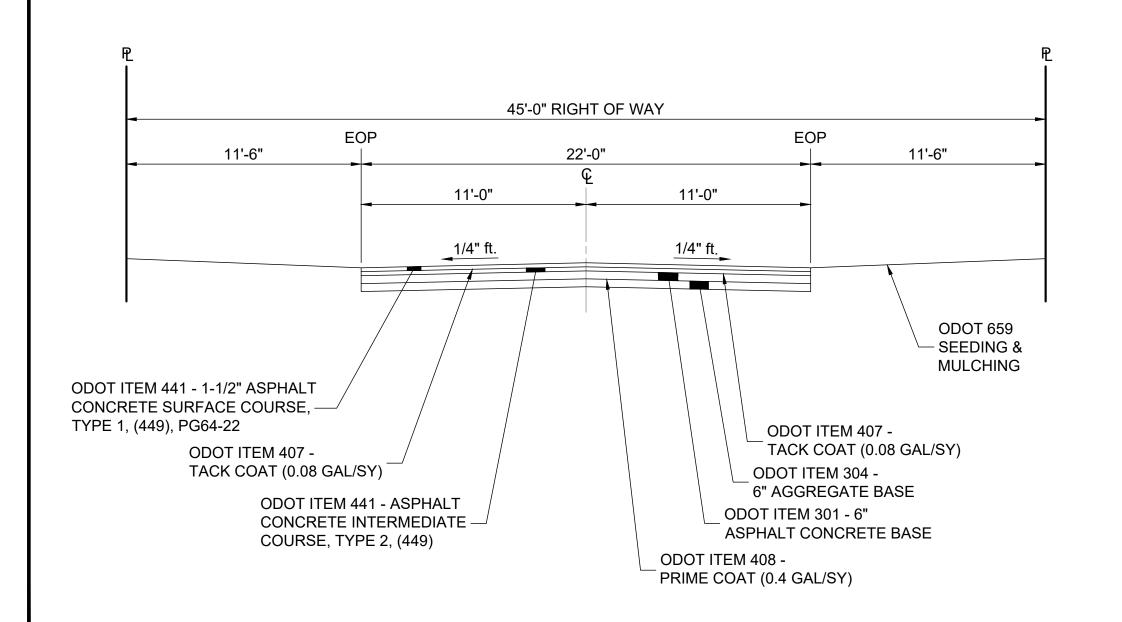


FOREST DRIVE TYPICAL SECTION


NOT TO SCALE

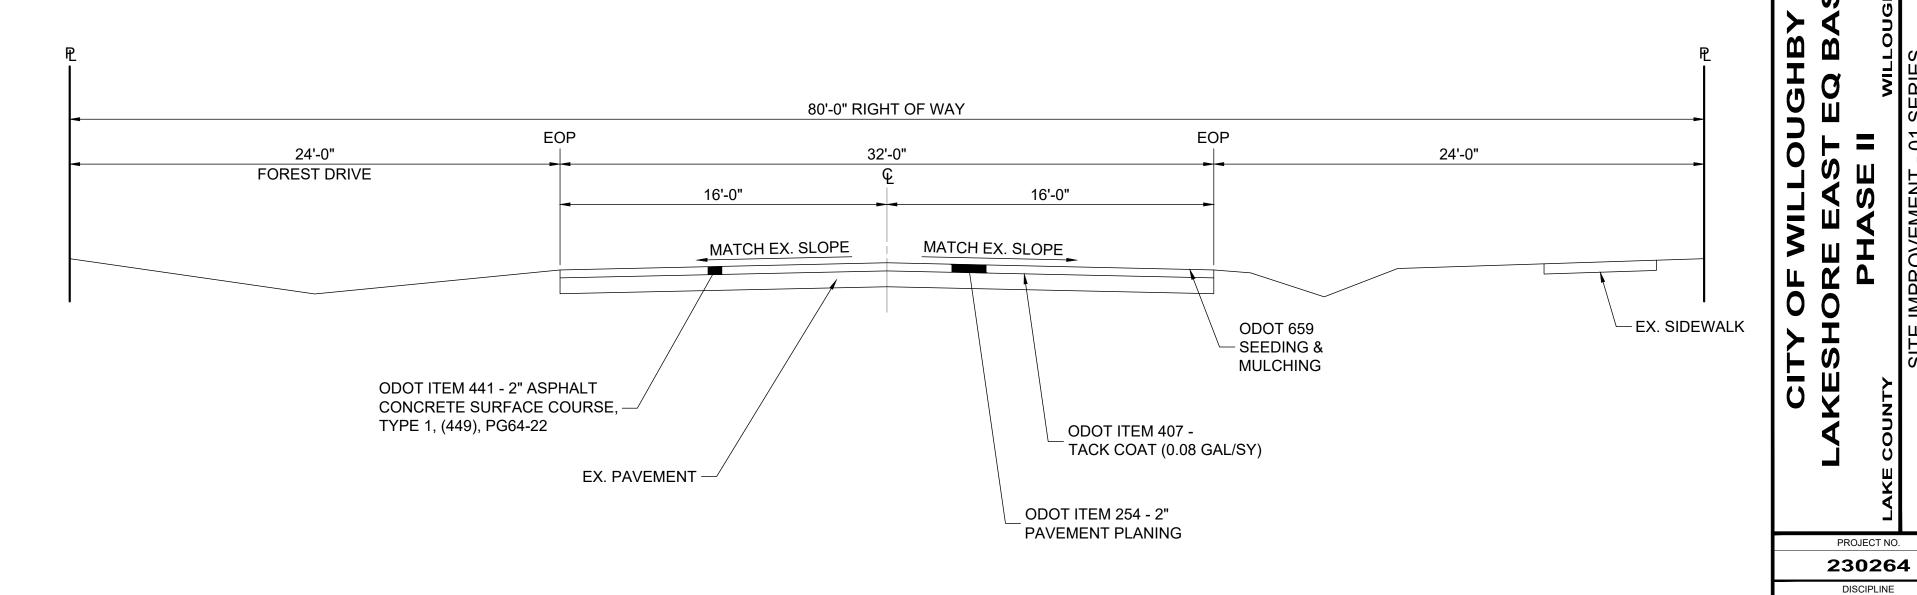

LAKESHORE BOULEVARD TYPICAL SECTION

NOT TO SCALE

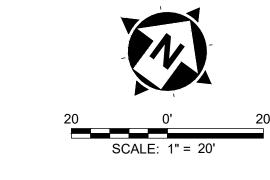

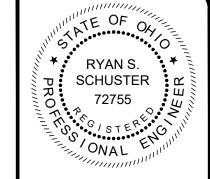

rdanta


8150 STERLING COURT MENTOR, OHIO 44060 (440) 951-9000




01-C-06

48


- 1. FORCE MAIN SHALL BE CONSTRUCTED FLAT OR SLOPED TO THE TANK TO ALLOW FOR DRAINING OF THE FORCE MAIN.
- 2. CONTRACTOR SHALL FIELD LOCATE EXISTING 16" FORCE MAIN. REMOVE CAP, AND CONNECT NEW FORCE MAIN.

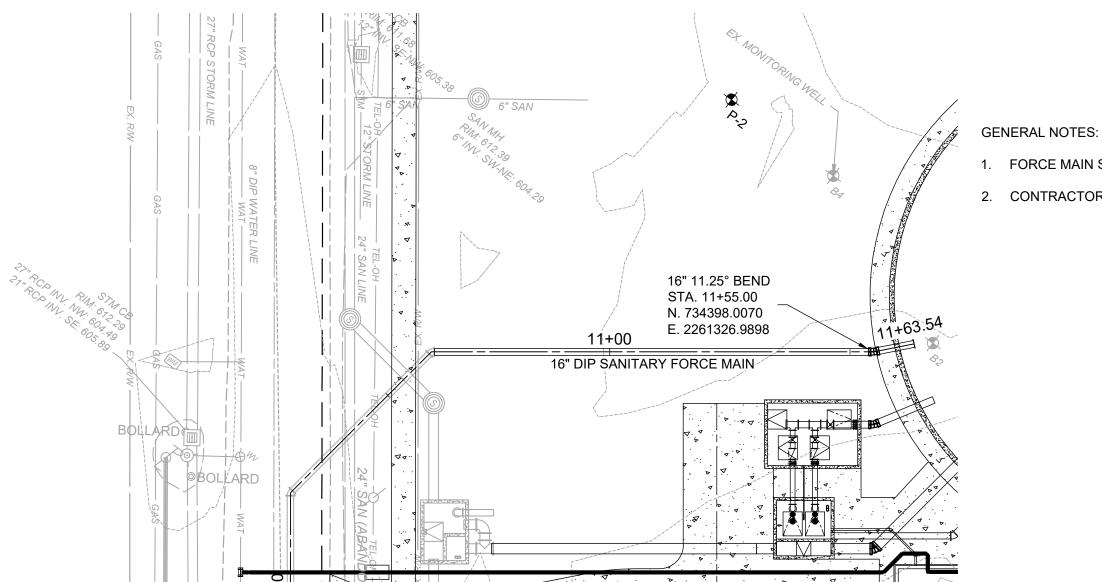


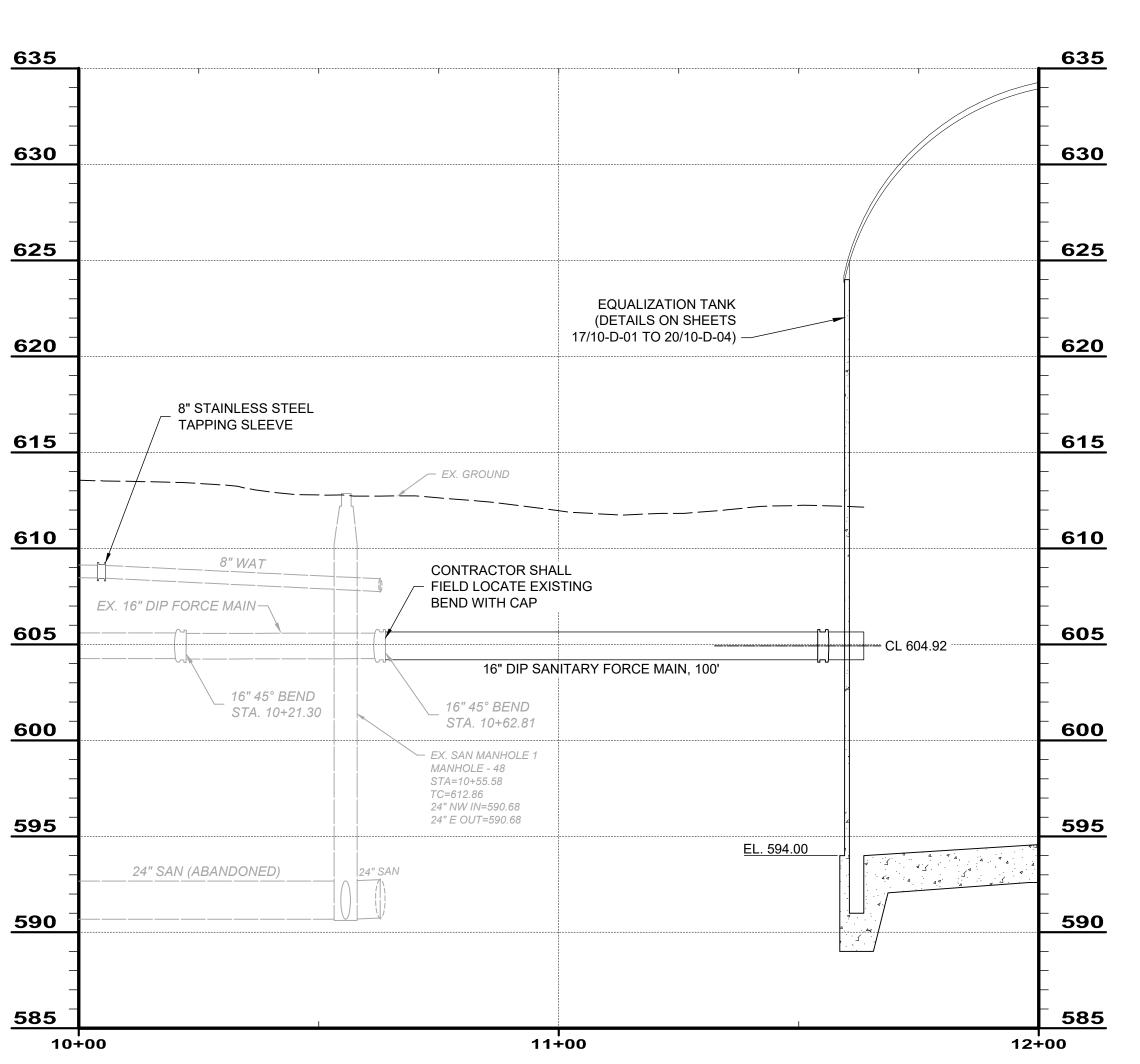

16" FORCE MAIN 10+00 - 12+00


SCALE: HORIZ. 1" = 20' VERT. 1" = 5'

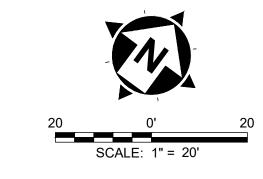

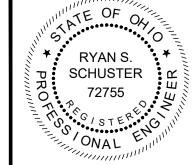

rdanta

8150 STERLING COUR MENTOR, OHIO 44060 (440) 951-9000

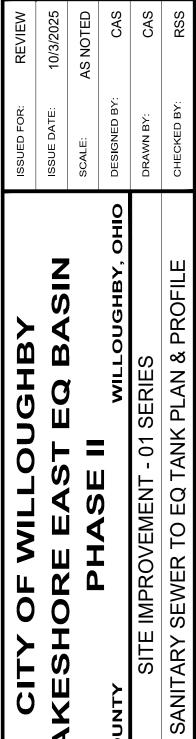

PROJECT NO.

230264

DISCIPLINE

CIVIL

SHEET NAME


01-C-07


48

12

GENERAL NOTES:


- 1. THE CONTRACTOR SHALL BRACE ANY EXISTING UTILITIES, ABOVE OR BELOW THE SURFACE, THAT INTERSECT OR ARE AFFECTED BY THE CONSTRUCTION OF ANY OF THE WORK WITHIN THE PROJECT LIMITS. UTILITY SUPPORT DETAIL FOR SUBSURFACE UTILITIES THAT INTERSECT WITHIN THE TRENCH IS INCLUDED IN THE CONSTRUCTION DETAILS.
- 2. 24" GRAVITY SEWER FROM REGULATOR STRUCTURE TO WET WELL AND WET WELL TO THE LAKESHORE EAST EQ BASIN SHALL BE CL 52 DIP WITH BOLTLESS PUSH-ON JOINTS.
- 3. CONTRACTOR SHALL FIELD LOCATE EXISTING 24" SANITARY SEWER. REMOVE CAP, AND CONNECT NEW SEWER.

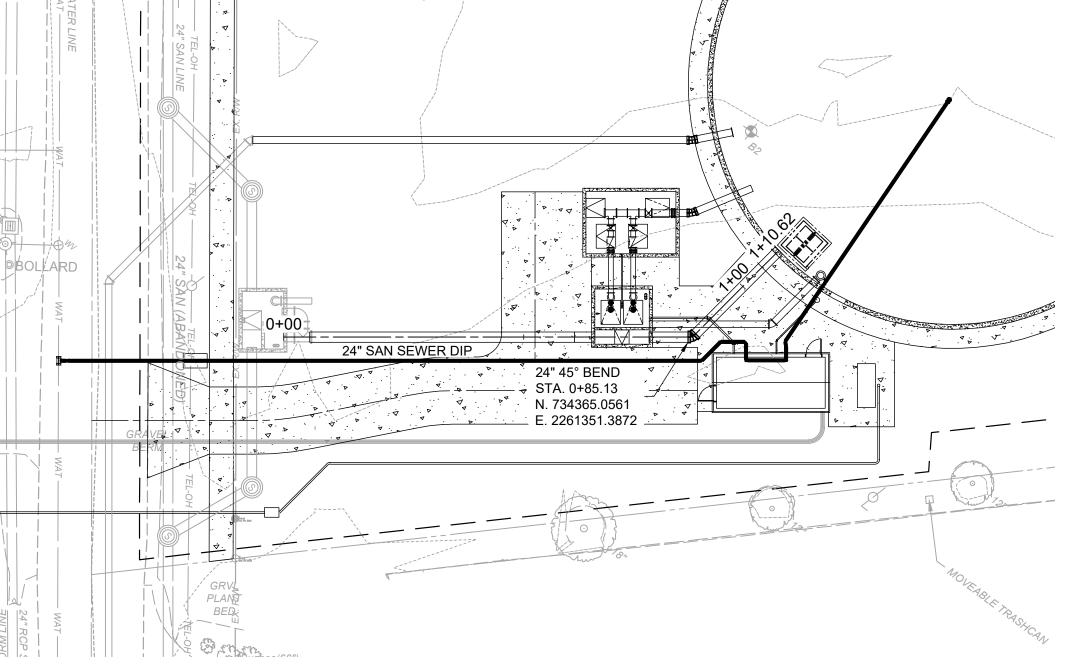

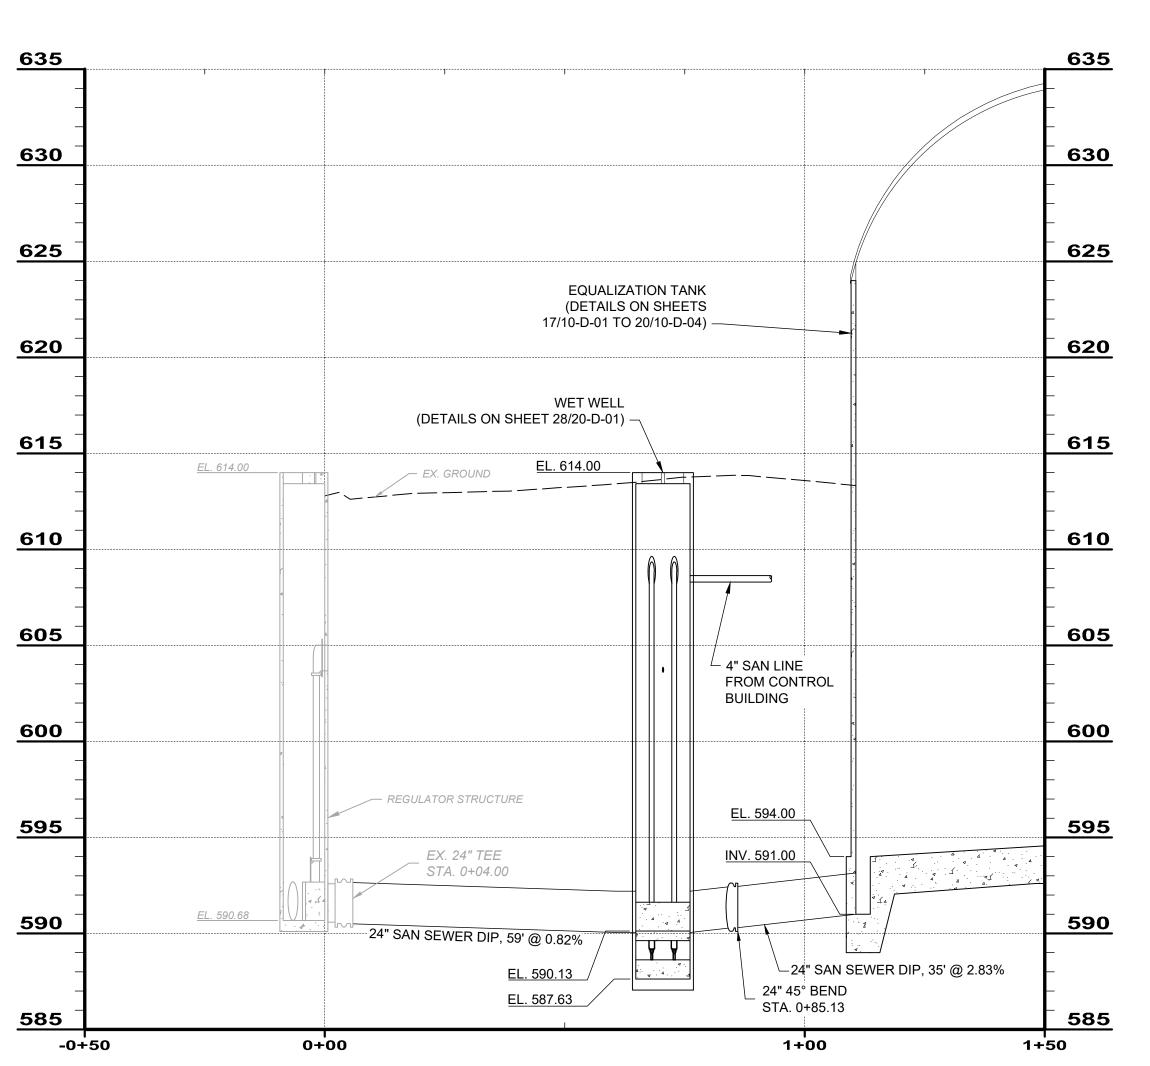

24" SANITARY SEWER TO EQ TANK

SCALE: HORIZ. 1" = 20' VERT. 1" = 5'

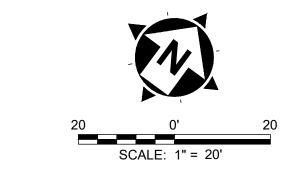



erdanta:

8150 STERLING COURT MENTOR, OHIO 44060 (440) 951-9000

ISSUE DATE: 10/3/2025

SCALE: AS NOTED

BY, OHIO

DESIGNED BY: CAS

DRAWN BY: CAS

CHECKED BY: RSS

ESHORE EAST EQ BASIN

PHASE II WILLOUGHBY, OHI

PROJECT NO.

230264

DISCIPLINE

CIVIL

DISCIPLINE
CIVIL
SHEET NAME
01-C-08


16° 22.5° EBND STA 0-91 99 N 7.34385.8025 E 2261335.9940


35	······				635
_		•			
30					630
25					625
25					625
_		(2574) 2 24 24 24	EQUALIZATION TANK		
20		(DETAILS ON SHEE	TS 17/10-D-01 TO 20/10-D-04) —————		620
_					
1		/DETAIL O	VALVE VAULT ON SHEET 28/20-D-01) —		
15		(DETAILS			615
	EL. 614.00	EX. GROUND	EL. 614.00		
-					
10			▗▗▗ ▗ ▗ ▗ ▗ ▗ ▗ ▗ ▗ ▗ ▗ ▗		610
-			EL. 607.17	CL 608.84	
0 5			<u> </u>		605
_	(INV. 603.67			605
_			16" 22.5° BEND STA. 0+91.99		
00			16" SAN FM, 17'		600
_	7				
95				_	595
_		REGULATOR STRUCTURE	EL. 594.00	4 3 4 4 7 4 7	
+	7			4 4 4	
90	EL. 590.68			4 4	590
1					
				-	=
-0+50	0+0		1	+00 1+2	585


16" FORCE MAIN TO EQ TANK

SCALE: HORIZ. 1" = 20'

VERT. 1" = 5'

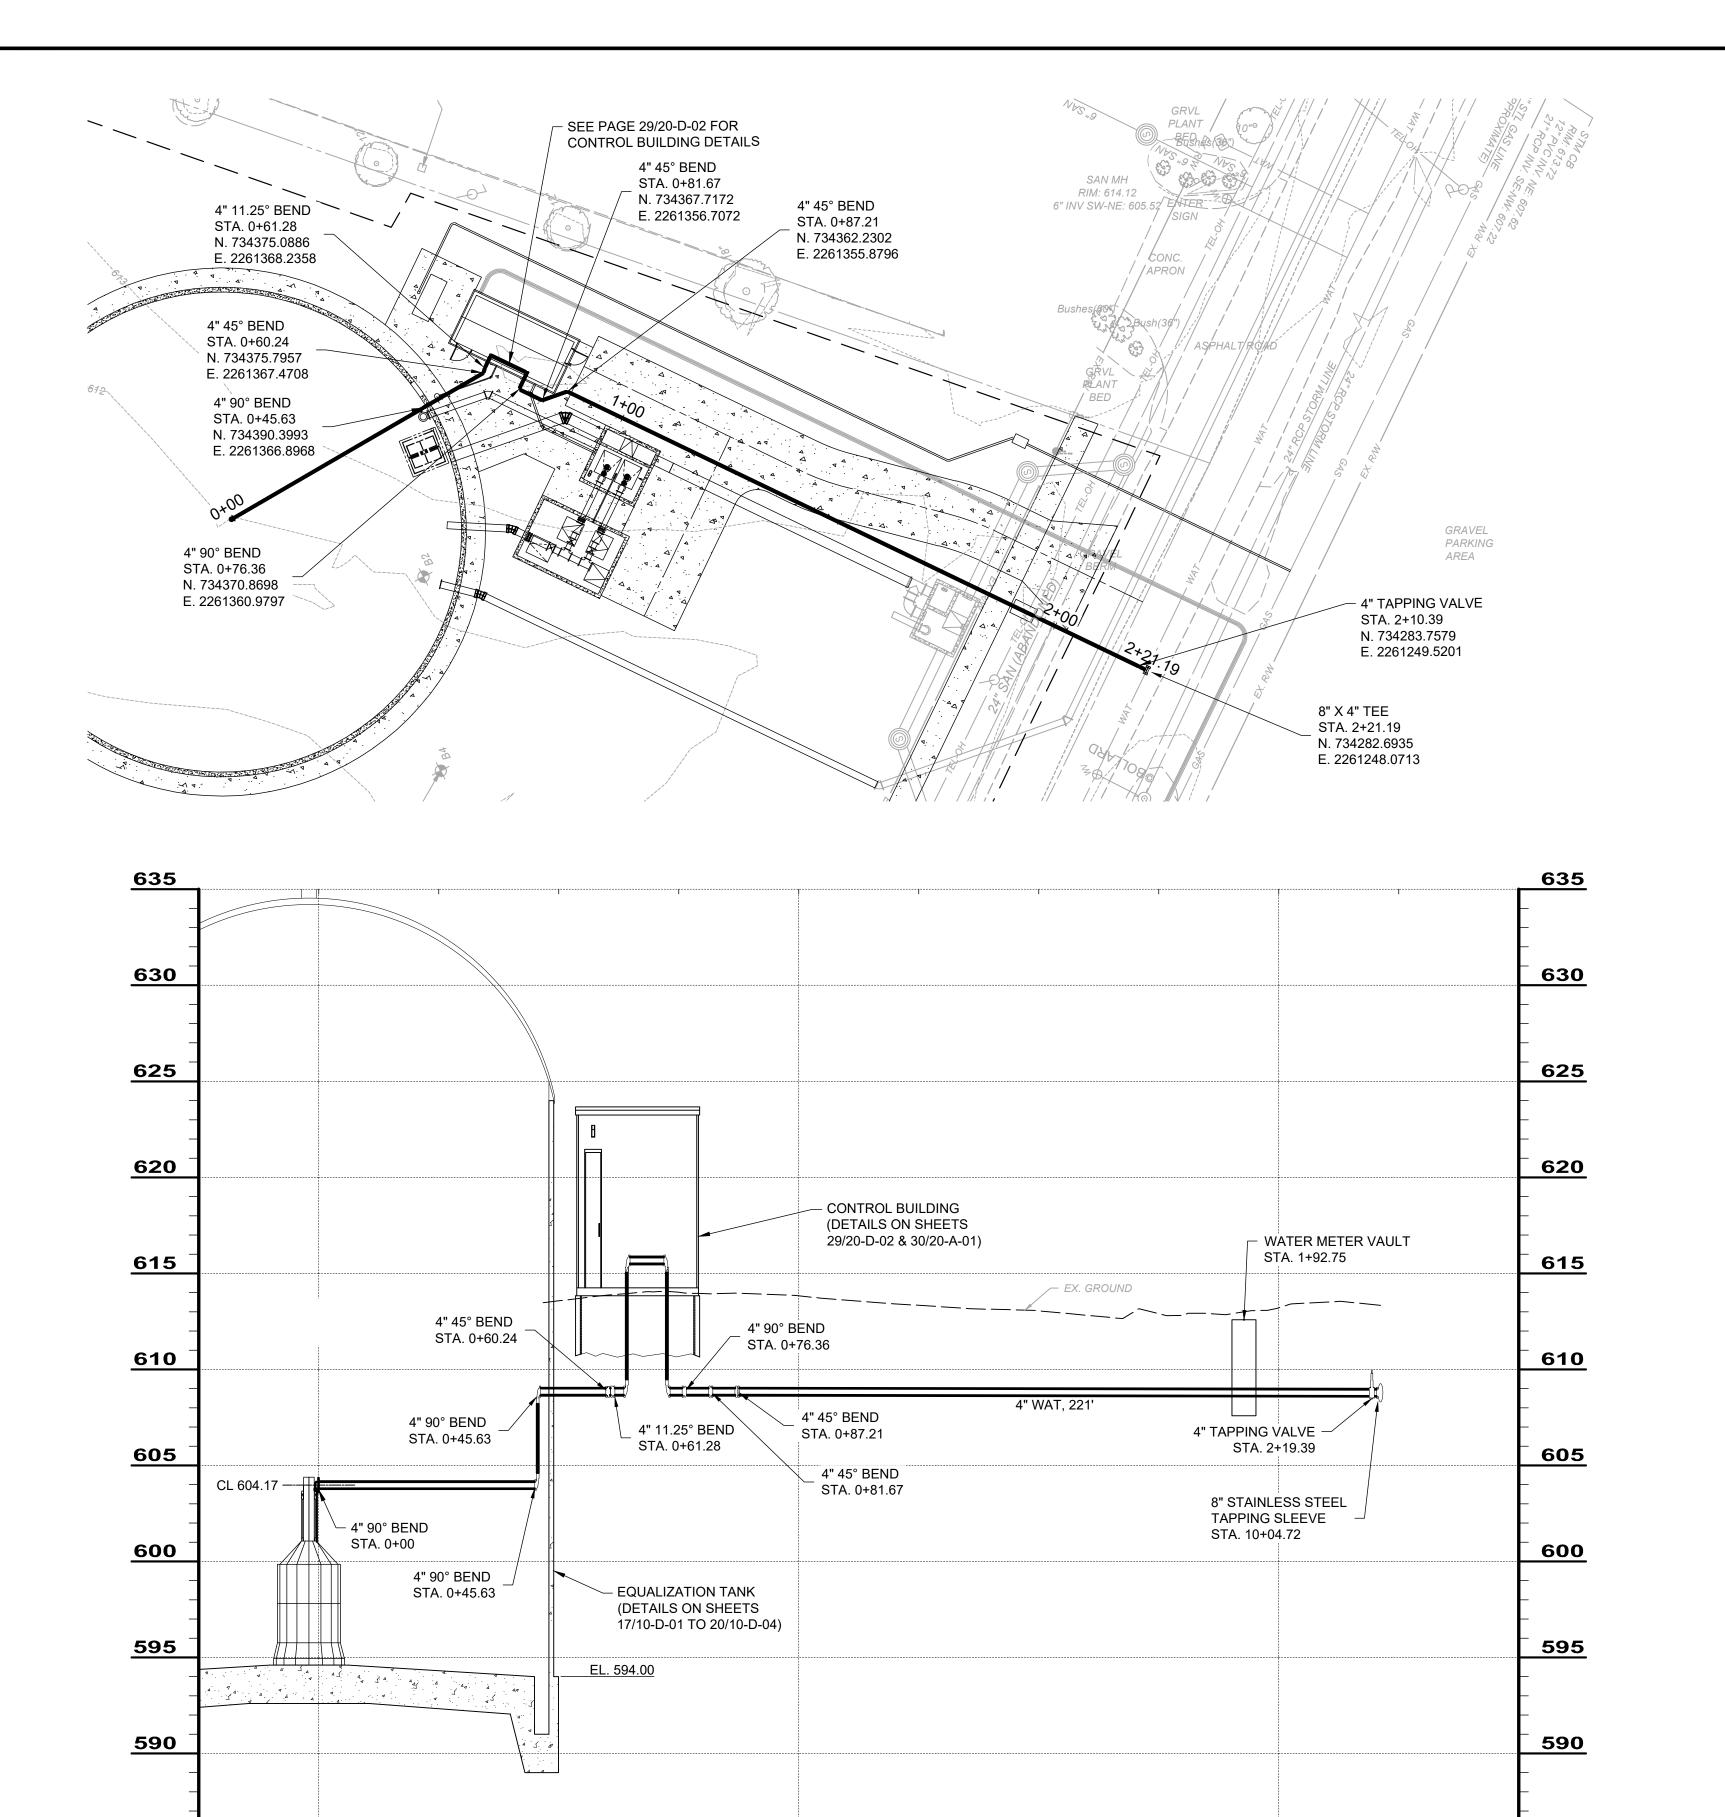

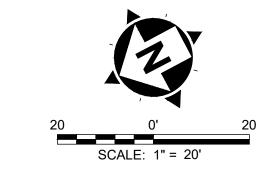

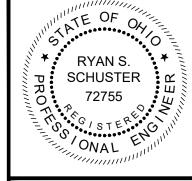

tas	
verdan	8150 STERLING COURT

10/3/2025	AS NOTED	CAS	CAS	RSS
ISSUE DATE:	SCALE:	DESIGNED BY:	DRAWN BY:	CHECKED BY:
LAKESHORE EAST EQ BASIN		LAKE COUNTY	SITE IMPROVEMENT - 01 SERIES	4" WATER SERVICE LINE PLAN & PROFILE
	PROJE	CT NO.		

DISCIPLINE CIVIL SHEET NAME 01-C-09

14

1+00

585

2+50


2+00


H:\2023\230264\DWG\SHEETS\PHASE II\C_230264 - FORCE MAIN PLAN & PROFILE PHASE II.DWG - 14 4" WATER SERVICE LINE PLAN & PROFILE - 9/30/2025 1:24:40 PM - CORY SCOTT

<u>585</u>

-0+25

0+00

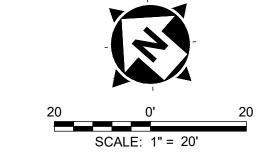

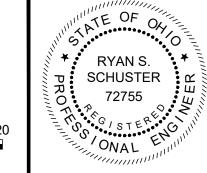





0 0 1 1	8150 STEK MENTOR, ((440) 951-9	


	CILY OF WILLOUGHBY	ISSUE DA
	LANESHORE EAST EQ BASIN	SCALE:
4	AKE COUNTY PIASE I WILLOUGHBY, OHIO	DESIGNE
	SITE IMPROVEMENT - 01 SERIES	DRAWN E
	I ANDSCAPE PI AN	CHECKE

SHEET NAME **01-C-10**

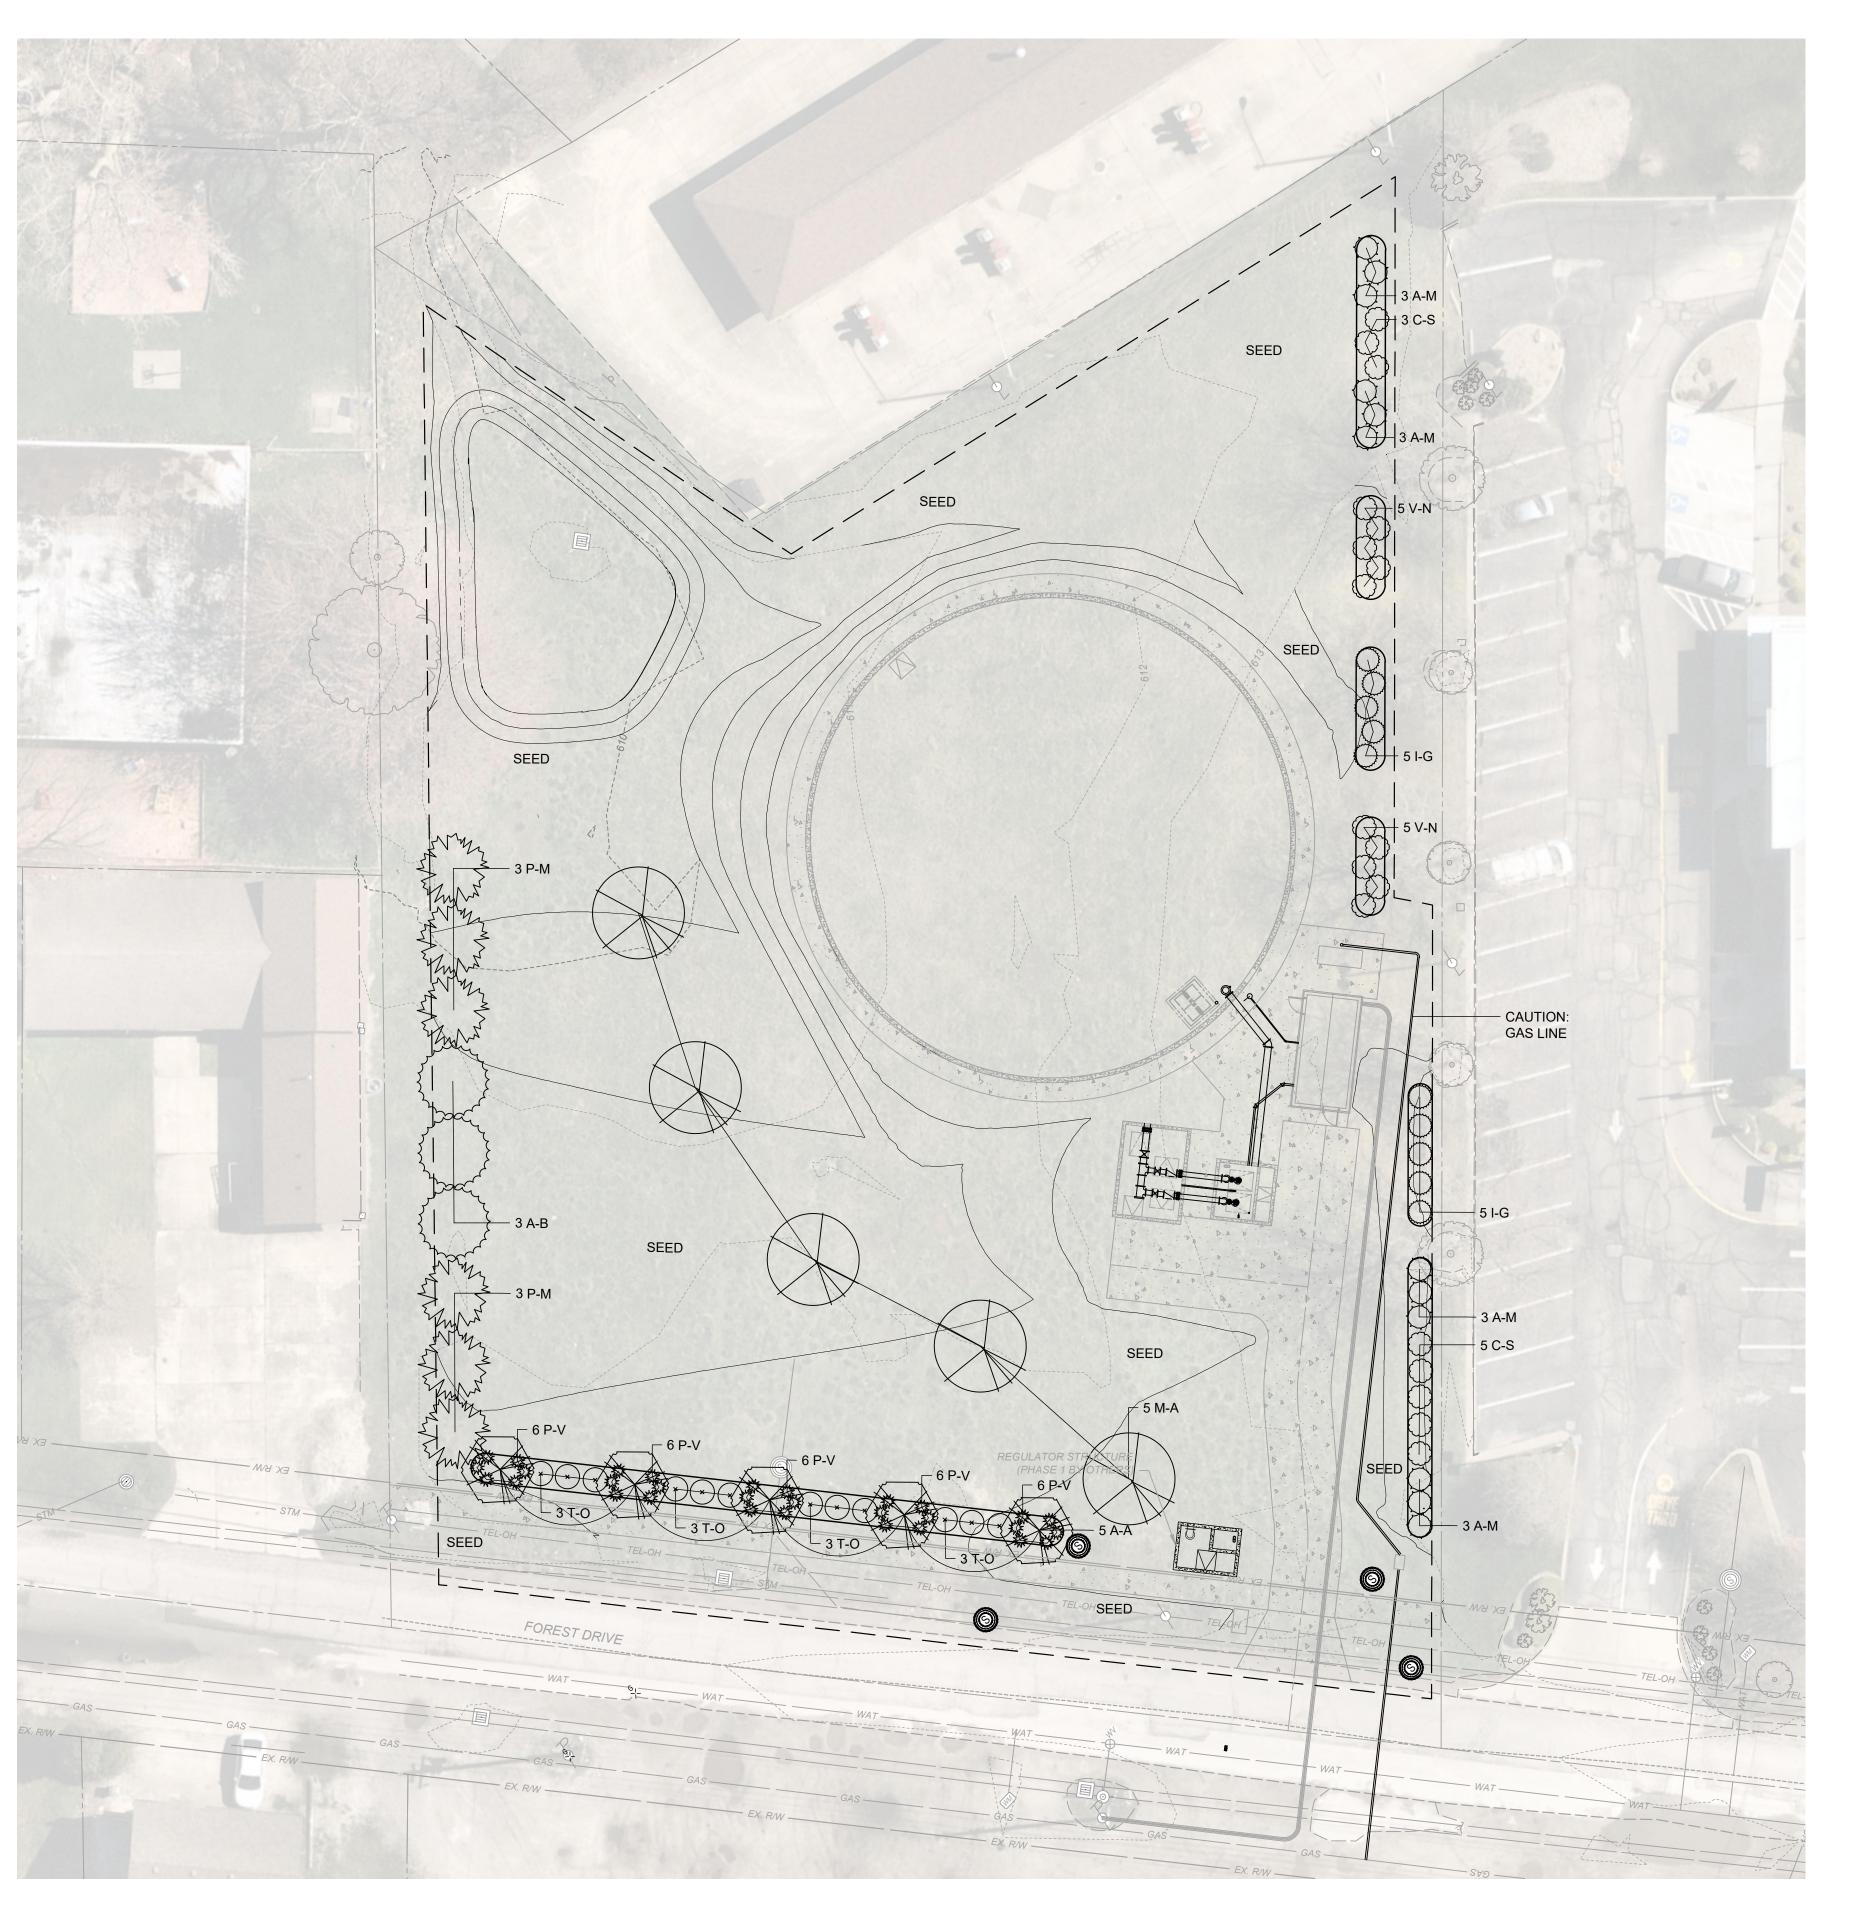

QTY.	KEY	BOTANICAL NAME	COMMON NAME	SIZE	NOTES
SHAD	E TREES				
5	M-A	MAGNOLIA ACUMINATA	CUCUMBERTREE MAGNOLIA	6'	#10 CONT.
ORNA	MENTAL T	REES			
5	A-A	AMELANCHIER X G. 'A BRILLIANCE'	AUTUMN BRILLIANCE SERVICEBERRY	5.5' CLUMP	MULTI-STI
EVER	GREEN TR	REES			
3	A-B	ABIES CONCOLOR	WHITE FIR	6' HT	B&B
6	P-M	PSEUDOTSUGA MENZIESII	DOUGLAS FIR	6' HT	B&B
SHRU	BS				
12	A-M	ARONIA MELANOCARPA	IROQUOIS BEAU. BLACK CHOKECHERRY	36"	#5 CONT.
8	C-S	CORNUS STOLONIFERA 'ARTIC FIRE'	ARCTIC FIRE DOGWOOD	36"	#5 CONT.
10	I-G	ILEX G. 'DENSA'	DENSA COMPACT INKBERRY	36"	#5 CONT.
12	T-O	THUJA O. 'WOODWARDII'	WOODWARD GLOBE ARBORVITAE	36"	#5 CONT.
10	V-N	VIBURNUM N. 'WINTERTHUR'	WINTERTHUR VIBURNUM	36"	#5 CONT.
PERE	NNIALS				
30	P-V	PANICUM V. 'SHENANDOAH'	SHENANDOAH RED SWITCH GRASS	CLUMP	#2 CONT.

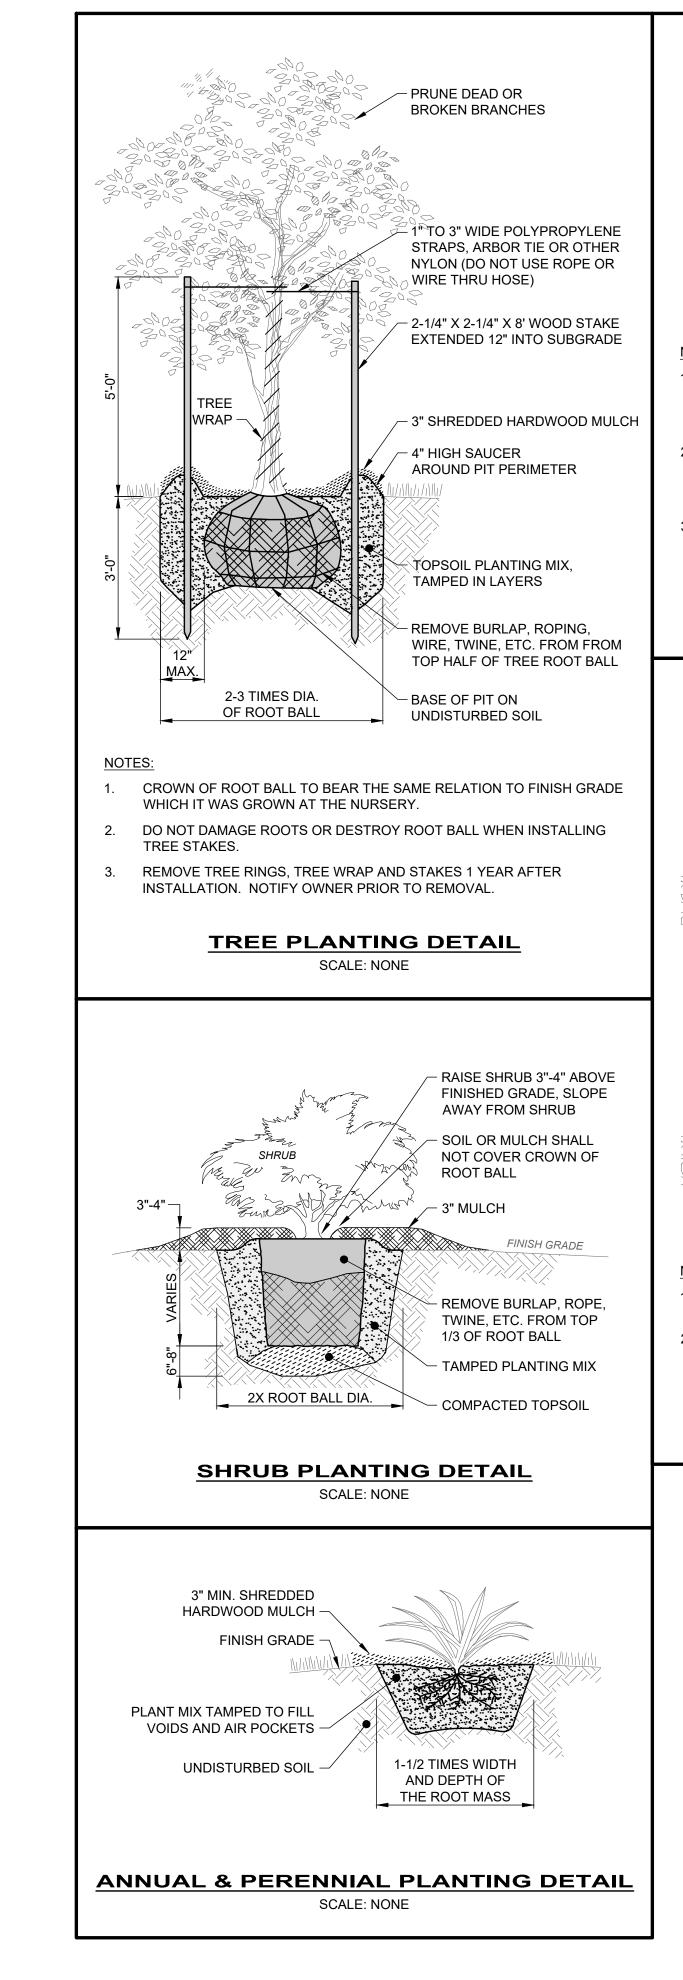


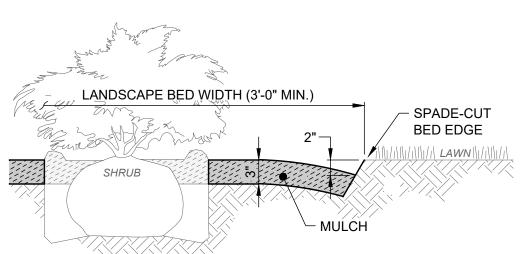


- MULCH SHALL BE DOUBLE SHREDDED HARDWOOD BARK MULCH, DARK BROWN OR BLACK COLOR PER OWNER CHOICE, EXTRA FINE WITH TEXTURE AT 1-1/2" OR LESS FREE OF WEEDS, CHAFF OR OTHER FOREIGN MATERIAL.
- 2. MULCH SHALL BE PLACED IN ALL PLANTING AREAS SPREAD TO A SMOOTH, UNIFORM SURFACE PLANE WITH CRISP STRAIGHT AND SMOOTH CURVED MULCH BED EDGES. BED EDGES SHALL BE CUT IN "V" SHAPE WITH 60° ANGLE TO GROUND.
- 3. THIS DETAIL SHOWS A SHRUB FOR REFERENCE ONLY. SEE LANDSCAPE PLAN FOR ACTUAL PLANT TYPES AND LOCATIONS, AND CONFIGURATION OF BEDS.

MULCH BED DETAIL

SCALE: NONE

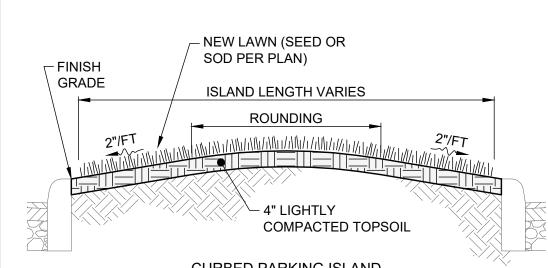

CURBED PARKING ISLAND

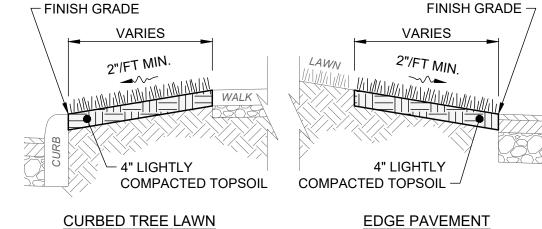

- 1. PLACE TOPSOIL TO TOP OF CURB OR EDGE OF SIDEWALK AND FINE GRADE TO A SMOOTH FINISH, FREE OF LUMPS AND DEPRESSIONS.
- 2. LAWN AREAS, AFTER LIGHT ROLLING, SHALL MEET THE GRADES, ELEVATIONS AND SLOPES SHOWN ON THE GRADING PLANS.

LAWN PLANTING DETAIL


SCALE: NONE

RYAN S. SCHUSTER 72755


ON					_
REVIEW	10/3/2025	AS NOTED	RDS	RDS	RRW
ISSUED FOR:	ISSUE DATE:	SCALE:	DESIGNED BY:	DRAWN BY:	CHECKED BY:
	L AKESHORE EAST		LAKE COUNTY	SITE IMPROVEMENT - 01 SERIES	LANDSCAPE DETAIL
	2	230		4	
		CI\			


01-C-11

16

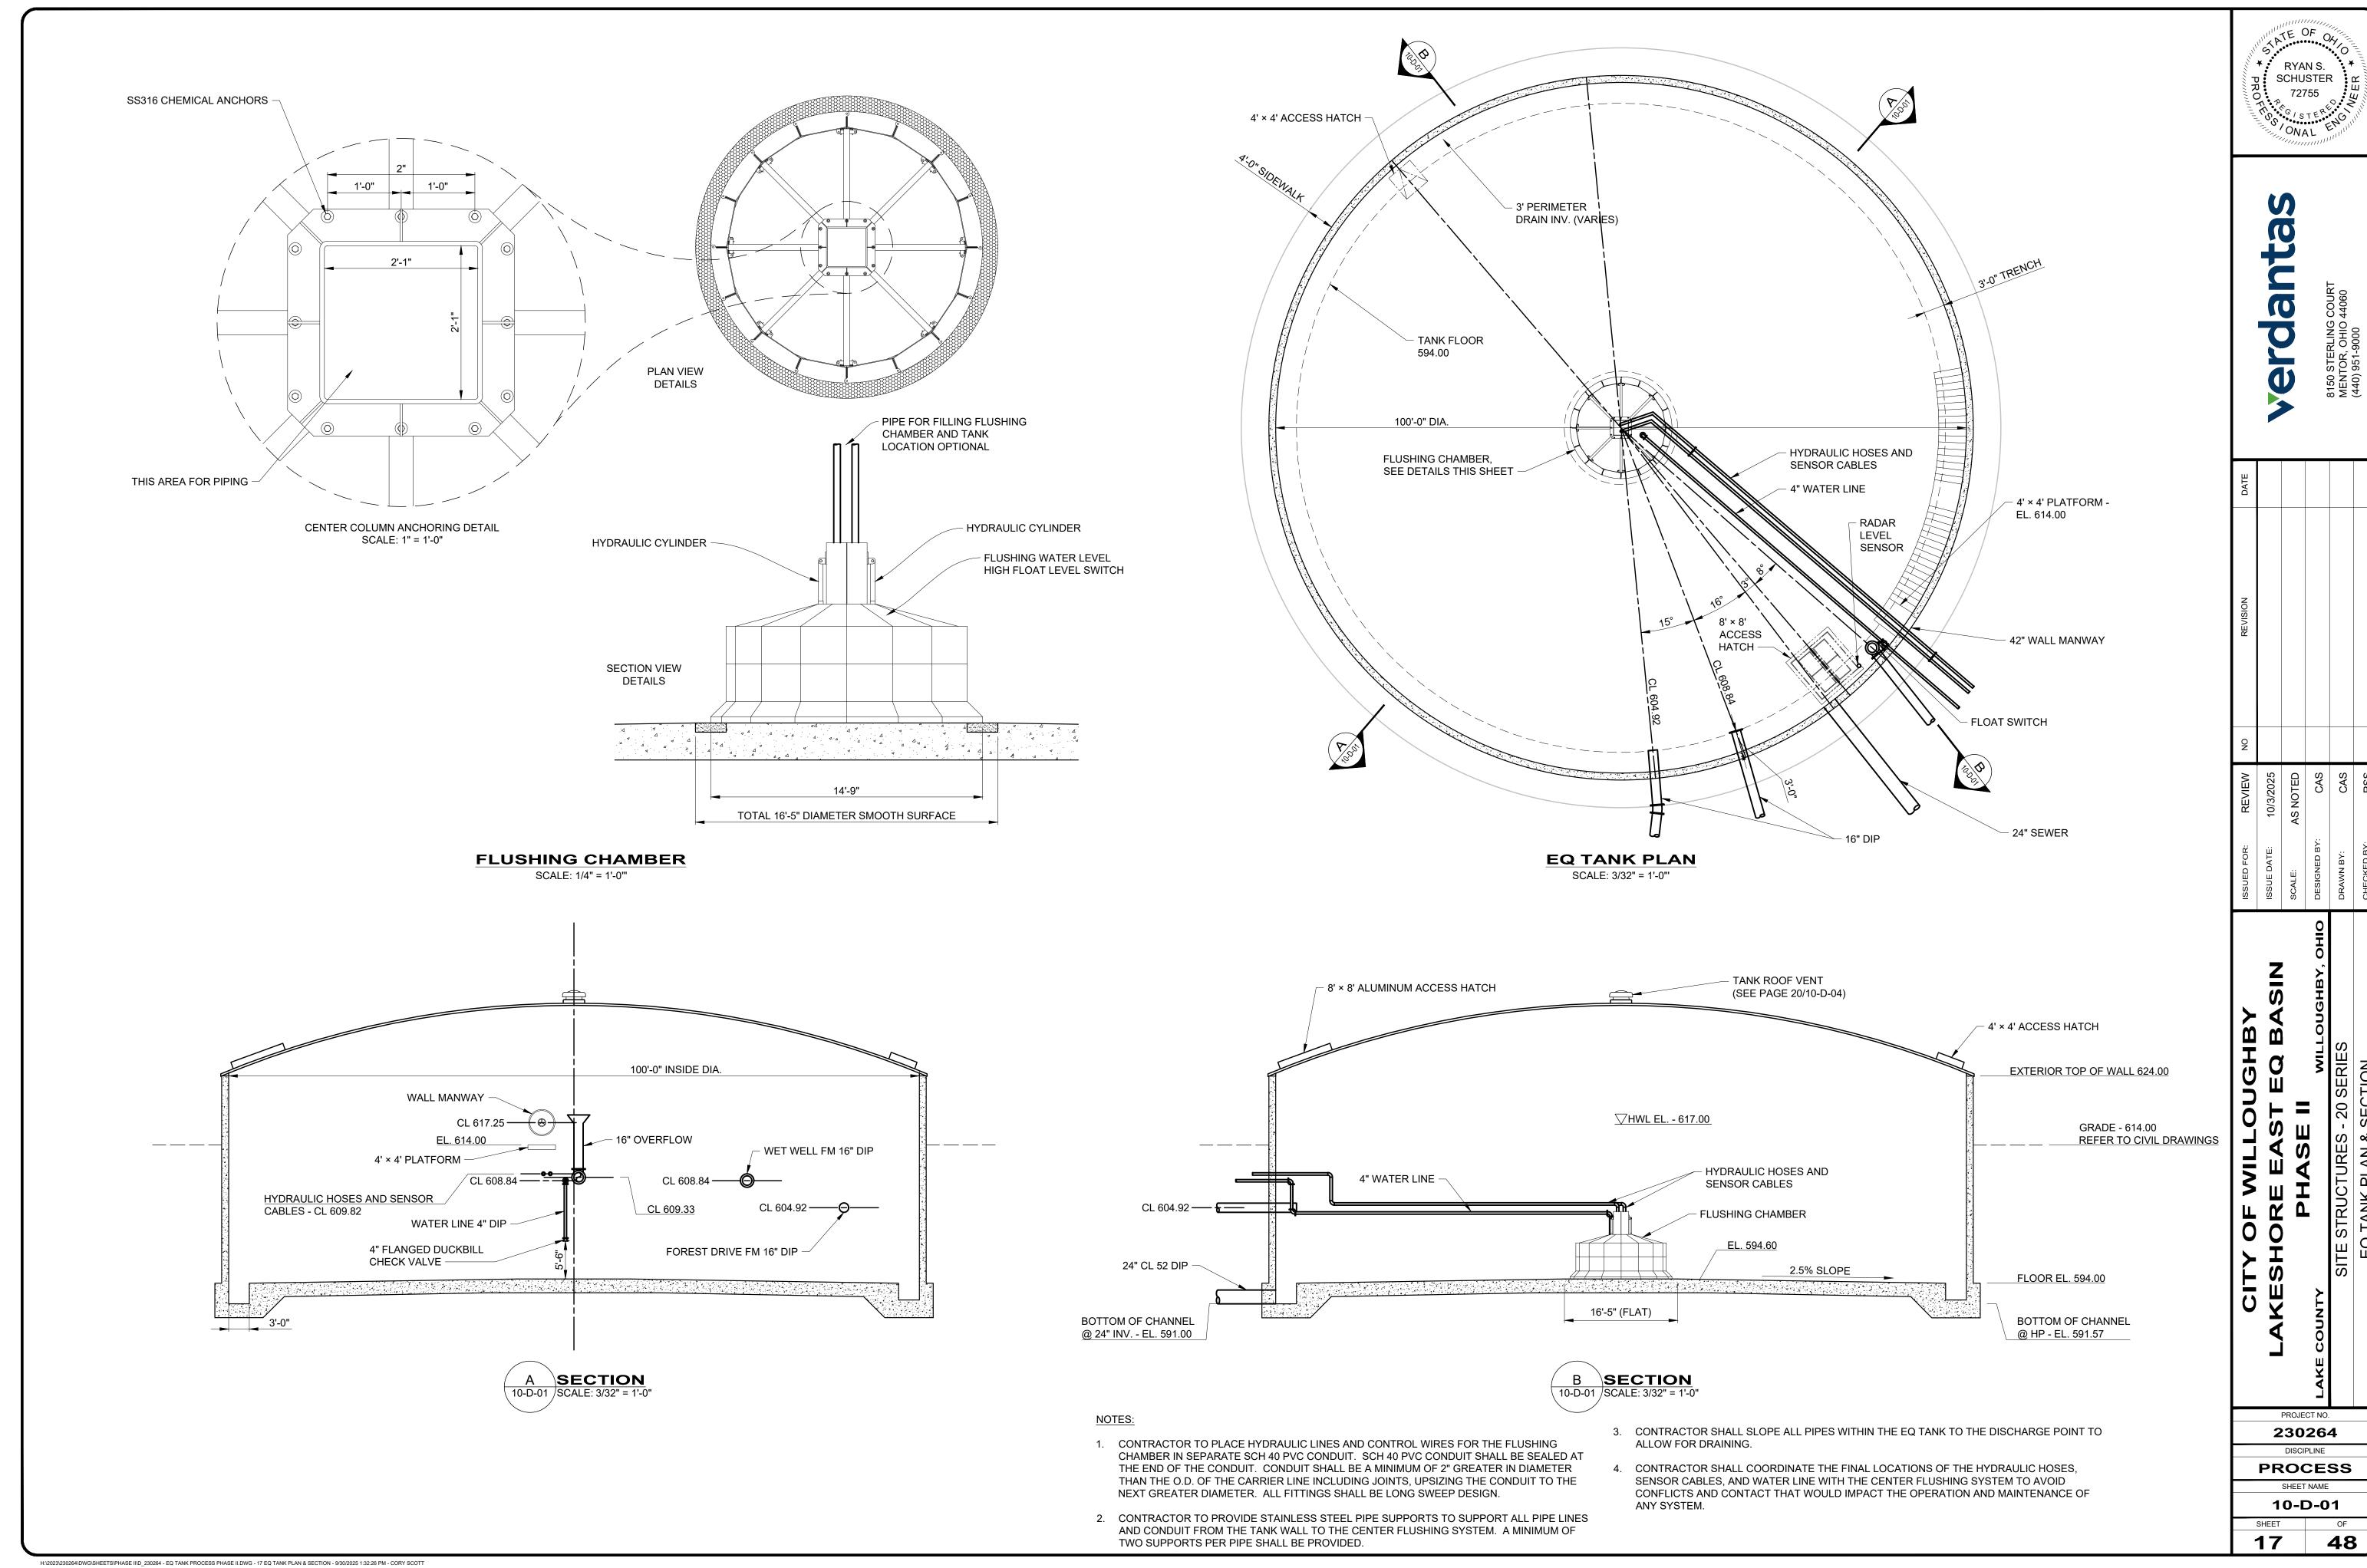


>	ISSUED FOR:	REVIEW	ON	REVISION
ZISA	ISSUE DATE:	10/3/2025		
	SCALE:	AS NOTED		
ЈGНВҮ, ОНЮ	DESIGNED BY:	CAS		
	DRAWN BY:	CAS		
	CHECKED BY:	RSS		

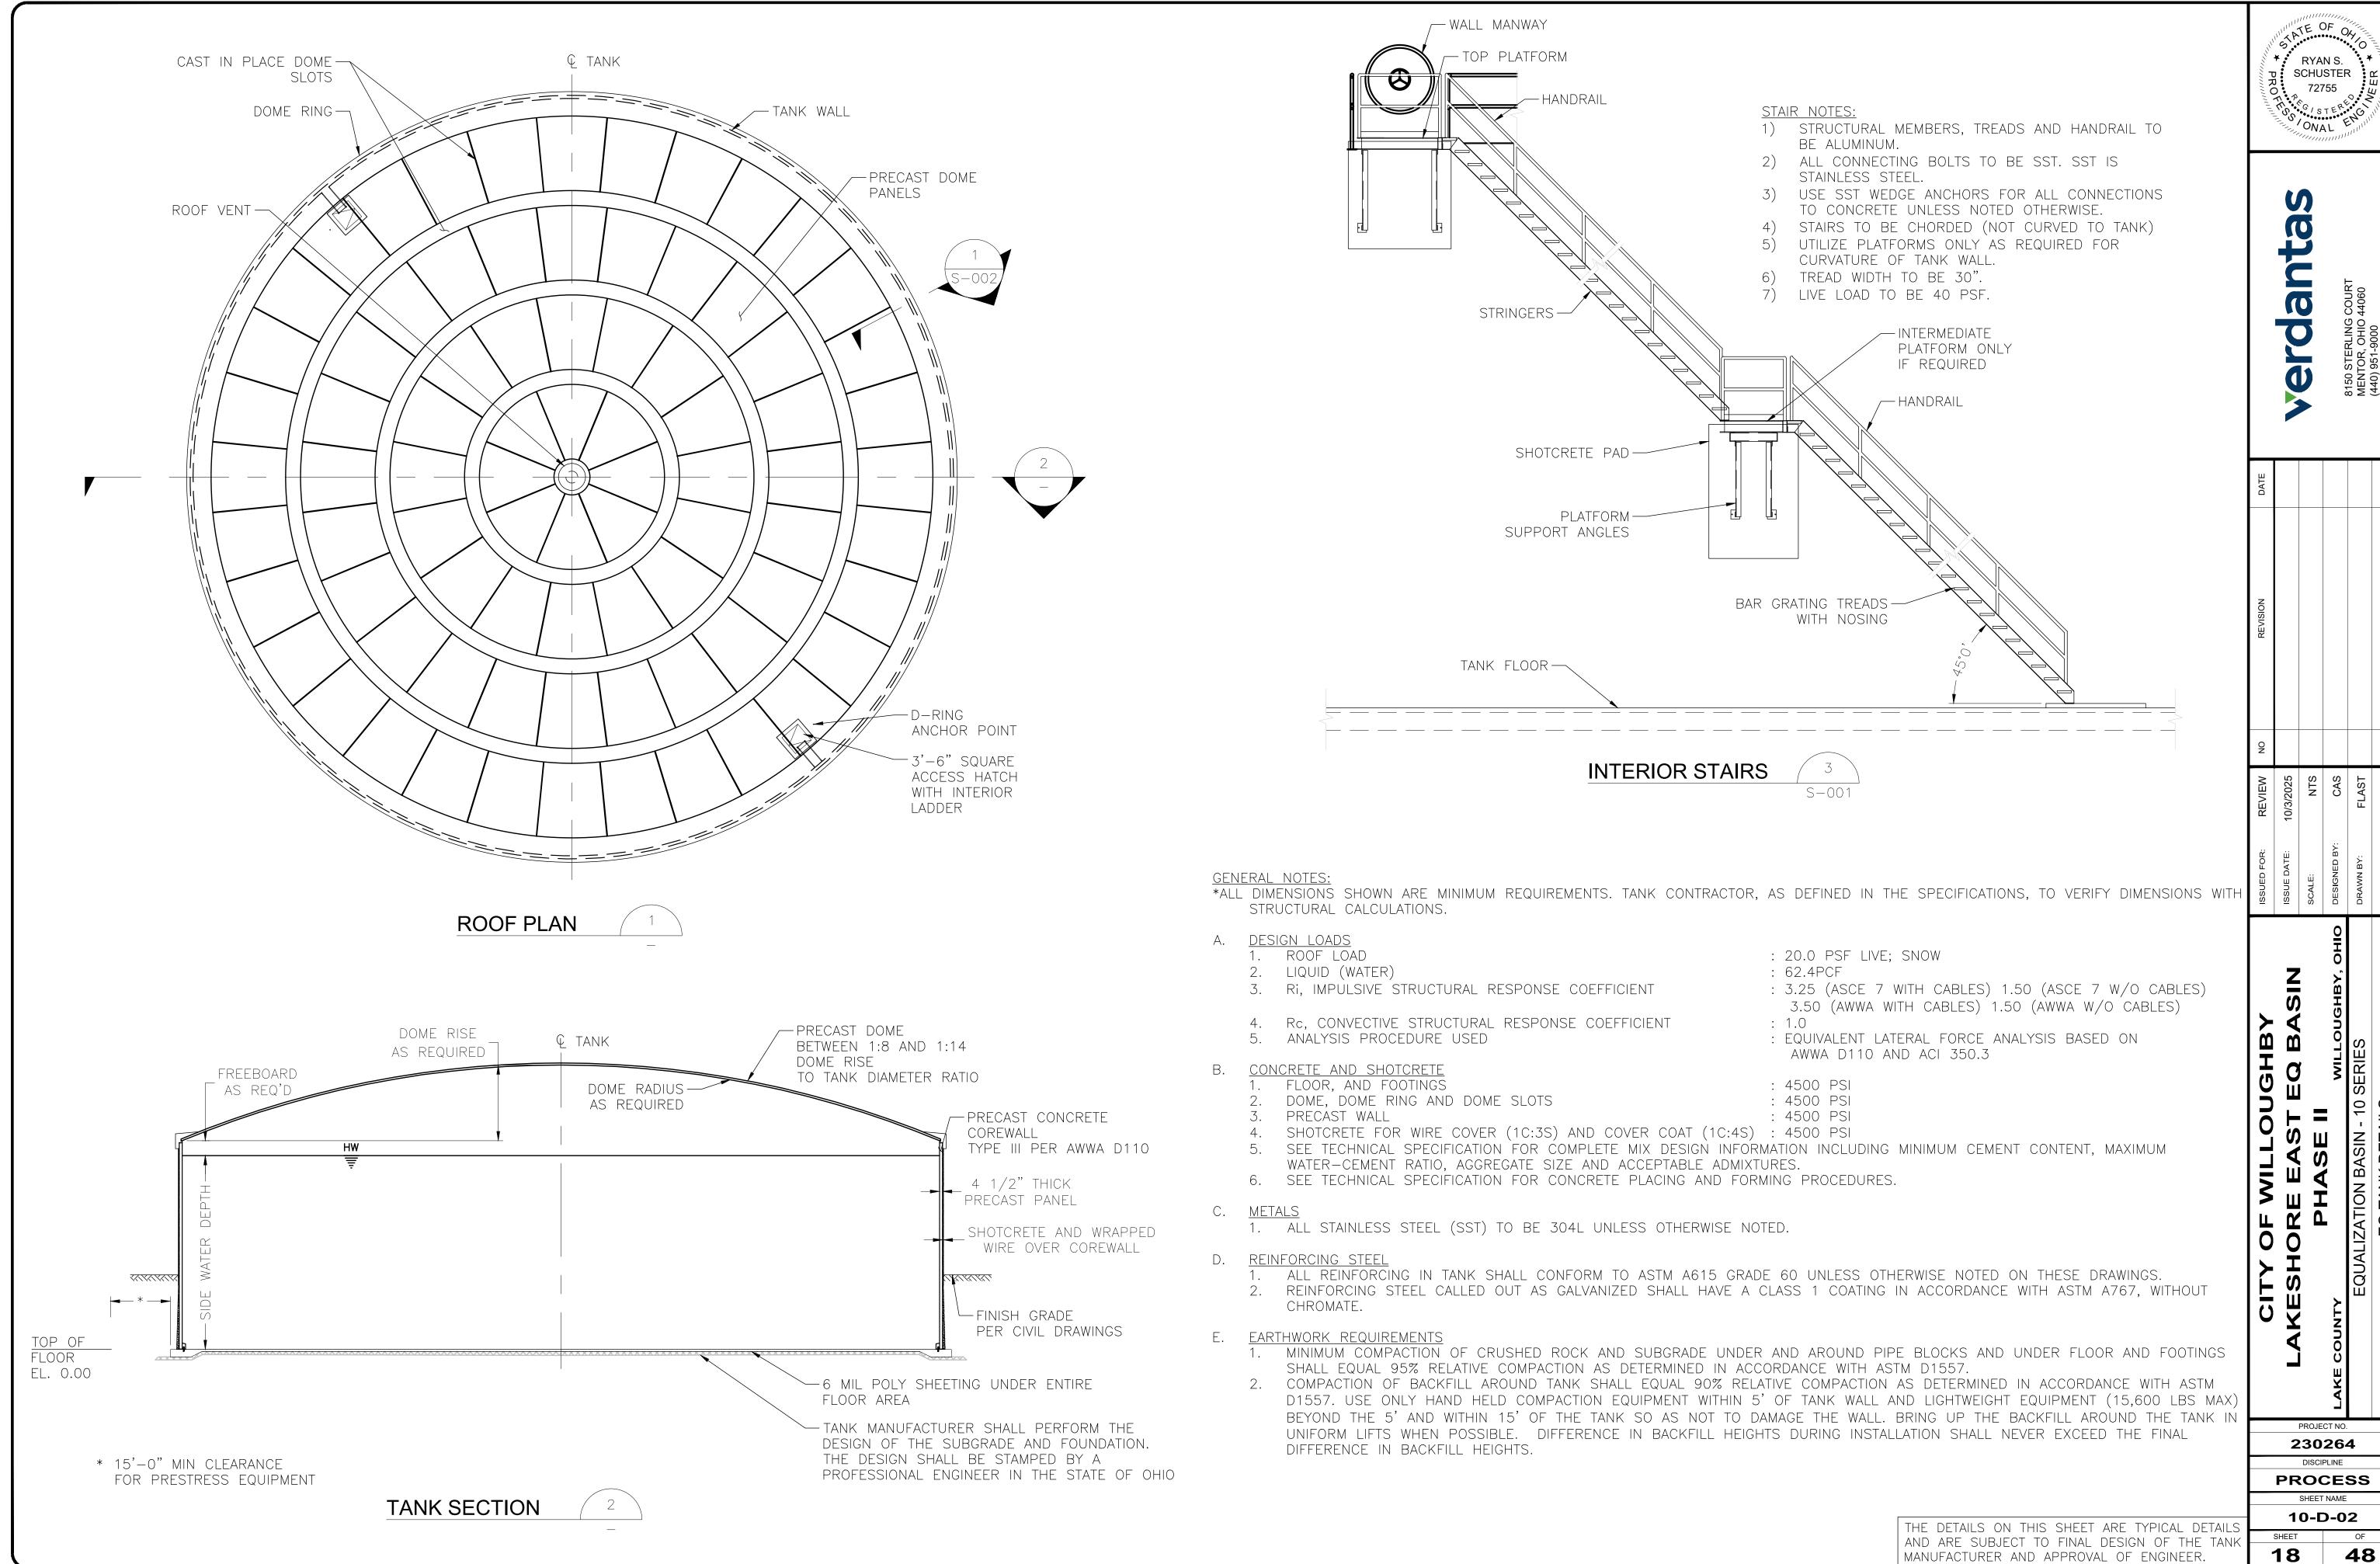

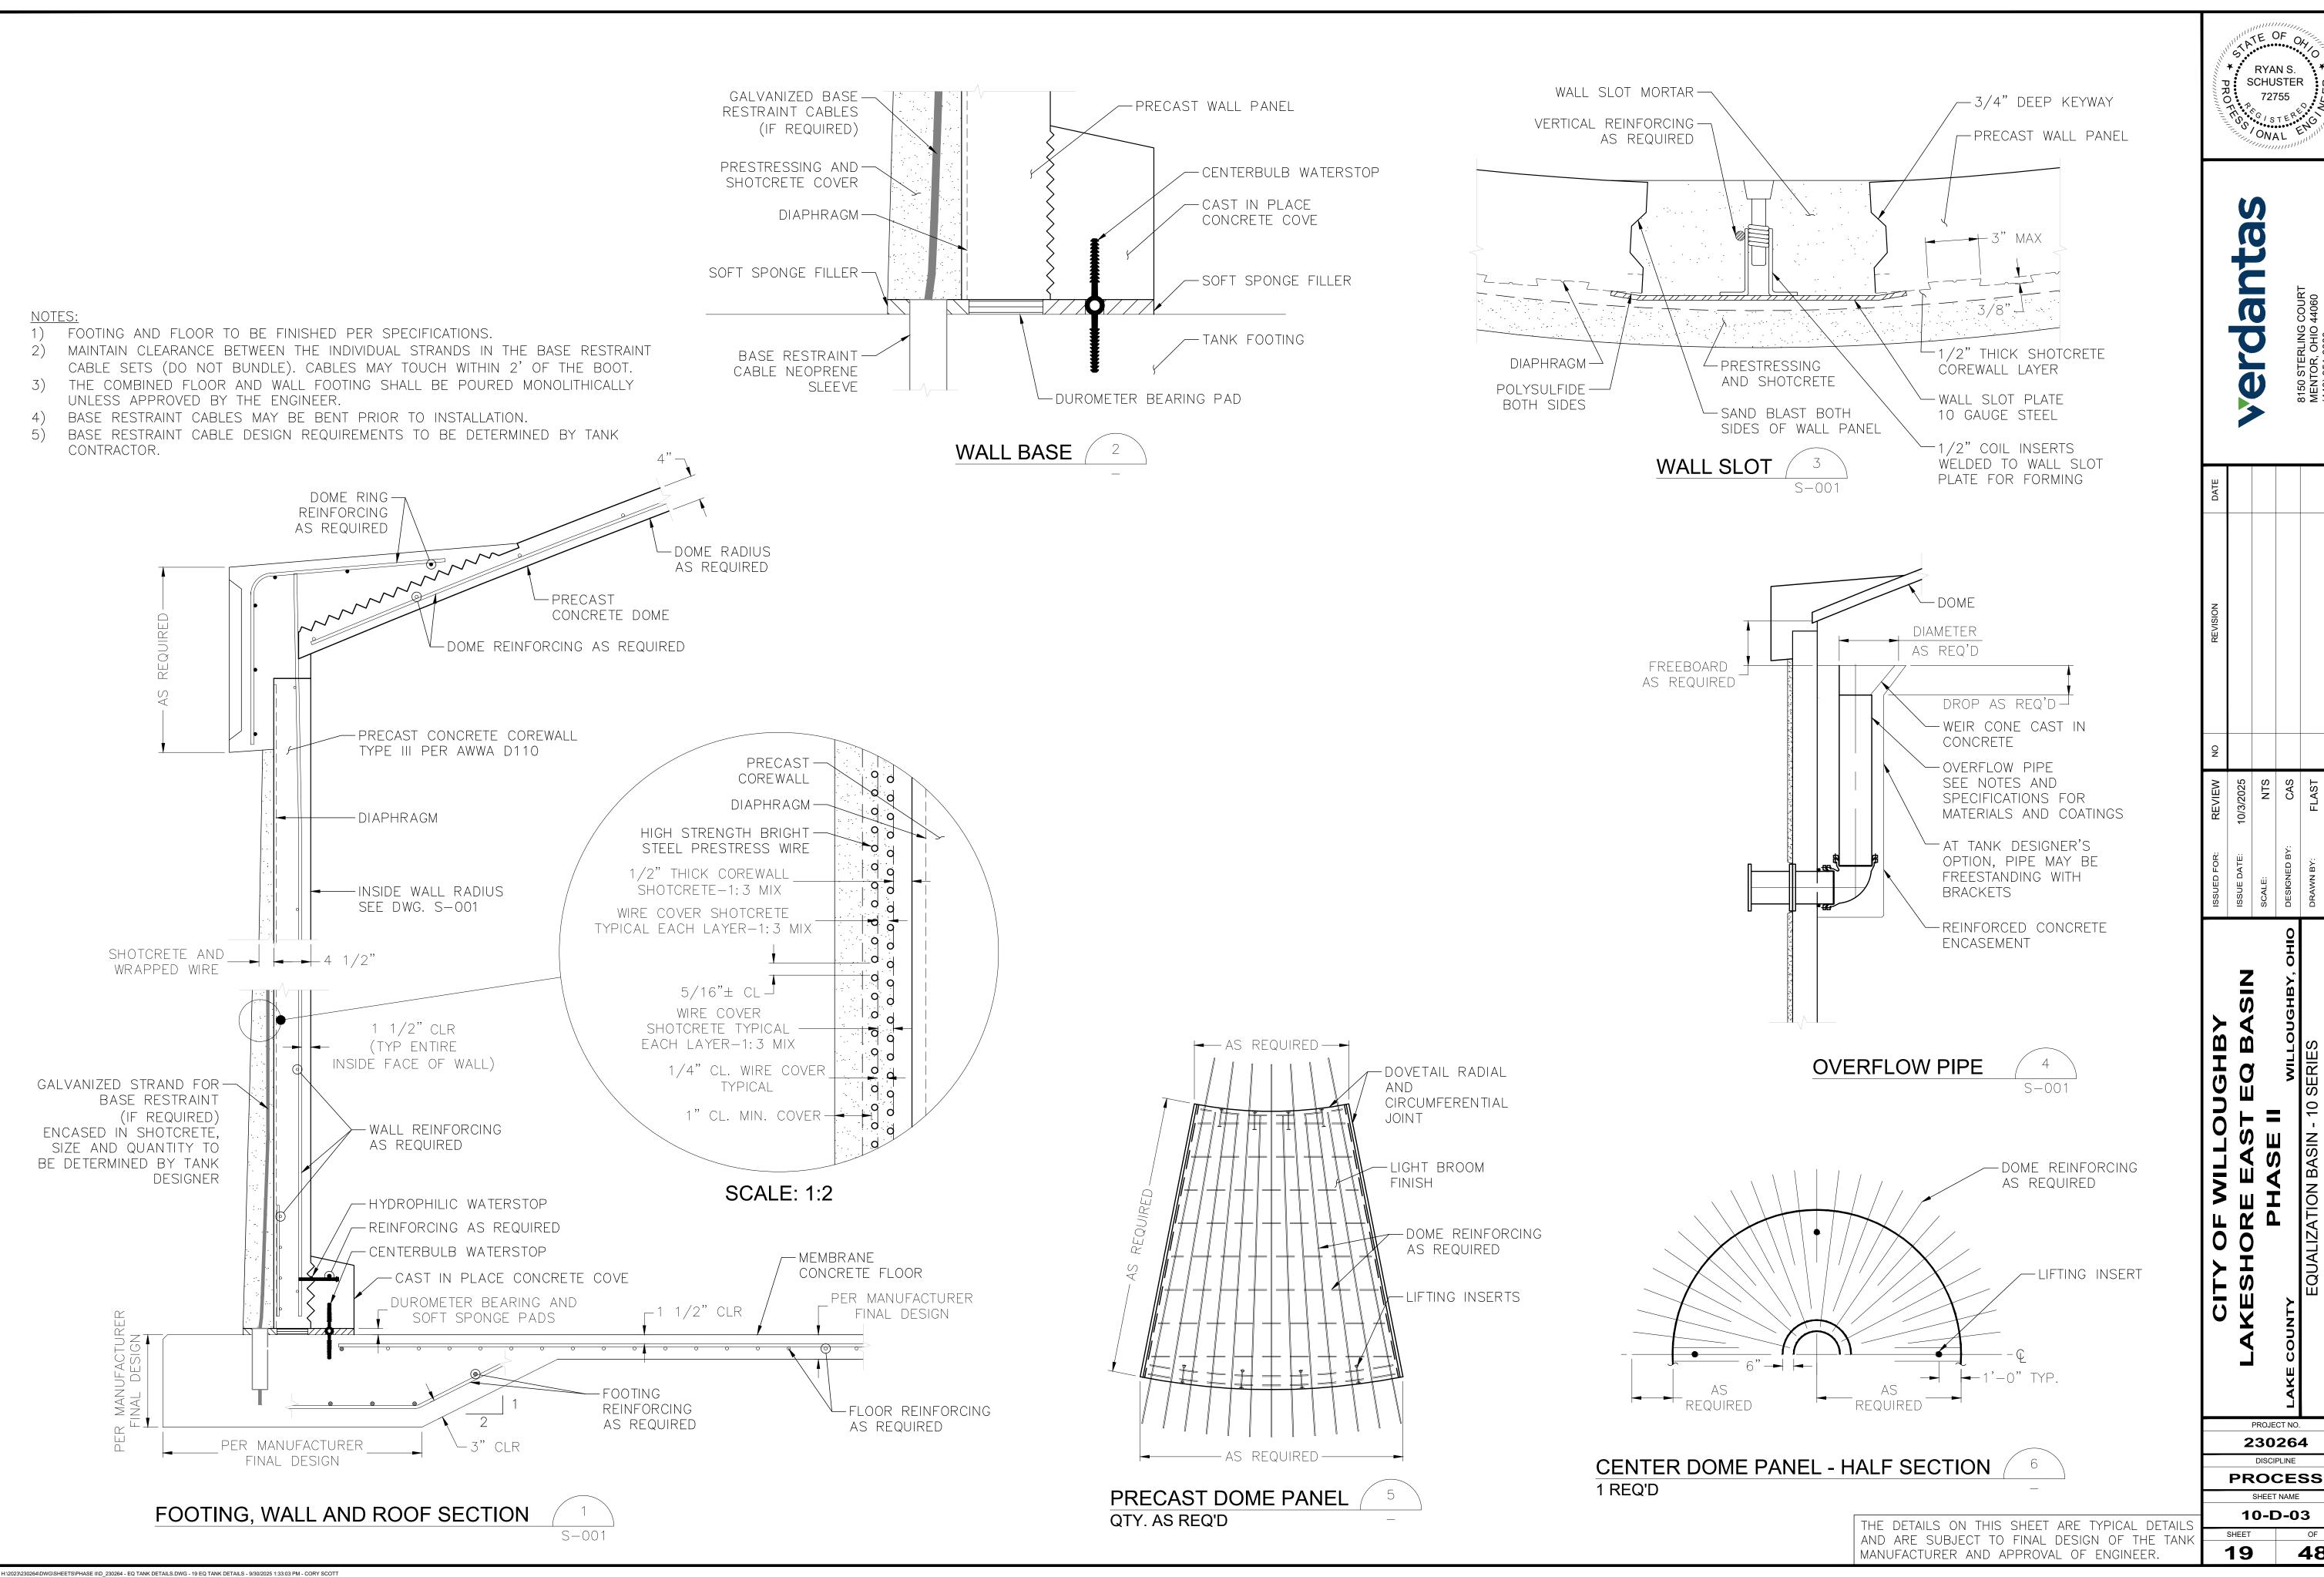

TATE OF ON RYAN S. SCHUSTER 72755

PROJECT NO. 230264

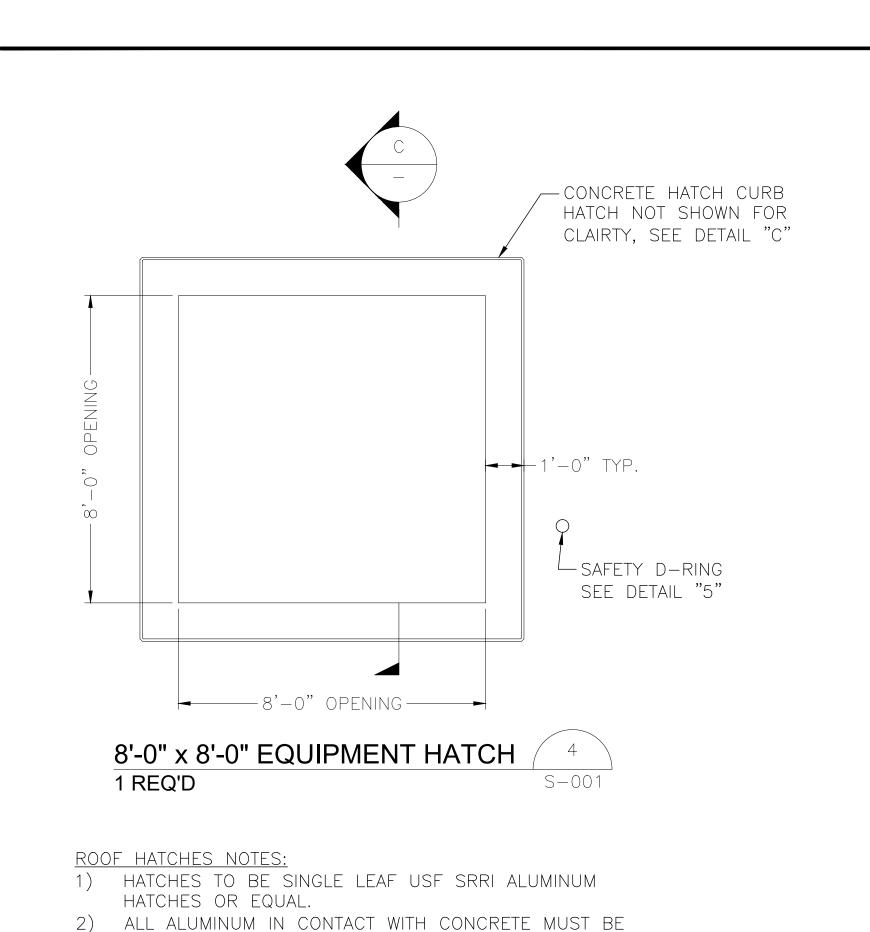

COATED WITH A HEAVY BITUMASTIC COATING, EPOXY

3) USE SST WEDGE ANCHORS FOR ALL CONNECTIONS

4) WHERE SST BOLTS ARE IN CONTACT WITH DISSIMILAR

WASHERS TO ELECTRICALLY ISOLATE THE BOLTS.

METALS, USE INSULATING SLEEVES AND PHENOLIC

TO CONCRETE UNLESS NOTED OTHERWISE.

PAINT OR SHIMMED USING PVC.

6" SST FLANGE x P.E. PIPE WITH WELDED WALL COLLAR /— WALL COLLAR -ROOF DOME SLEEVE 2 REQ'D S - 001

PENING -

SECTION


—USF SRRI

OR EQUAL

ALUMINUM HATCH


REINFORCING AS


REQUIRED

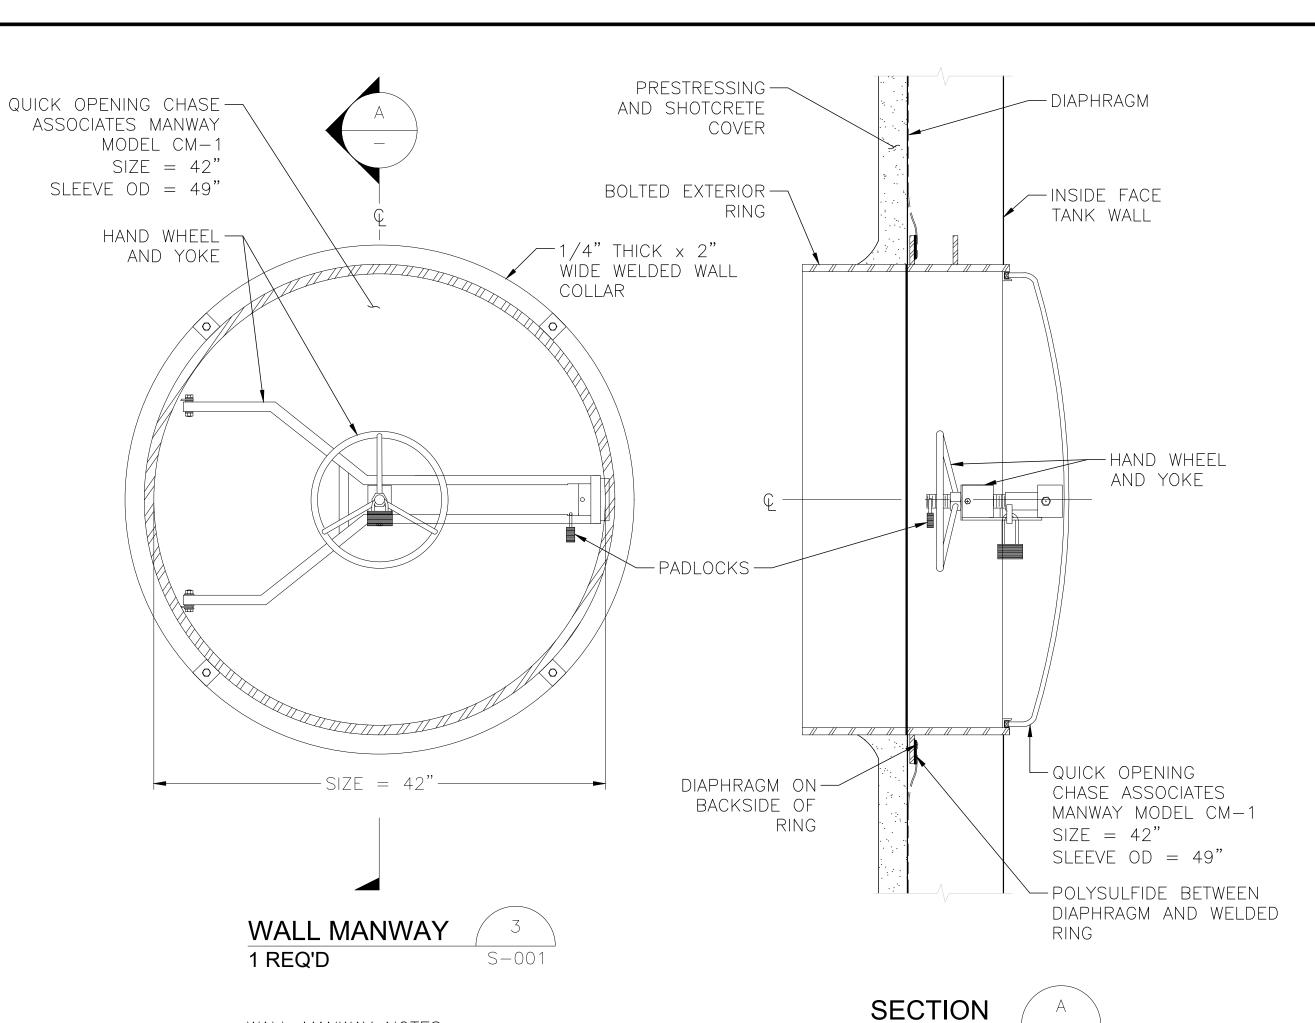



WALL MANWAY NOTES:

1) MANWAY MATERIAL TO BE SST. 2) THE MANWAY WILL BE CAST INTO THE WALL AND THE EXTERIOR MANWAY RING WILL BE BOLTED ON AFTER TANK PRESTRESSING IS COMPLETE, PRIOR TO FINAL COVERCOAT PLACEMENT.

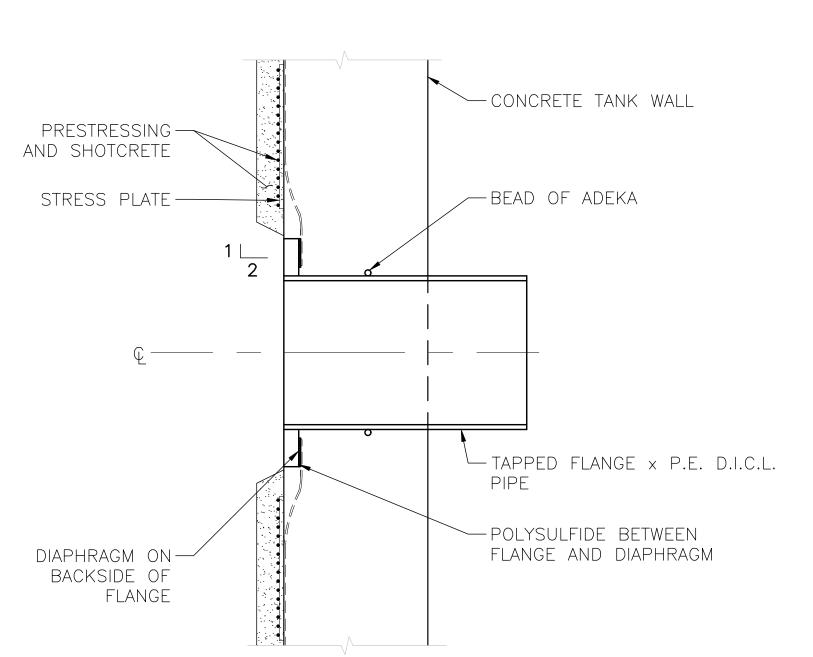

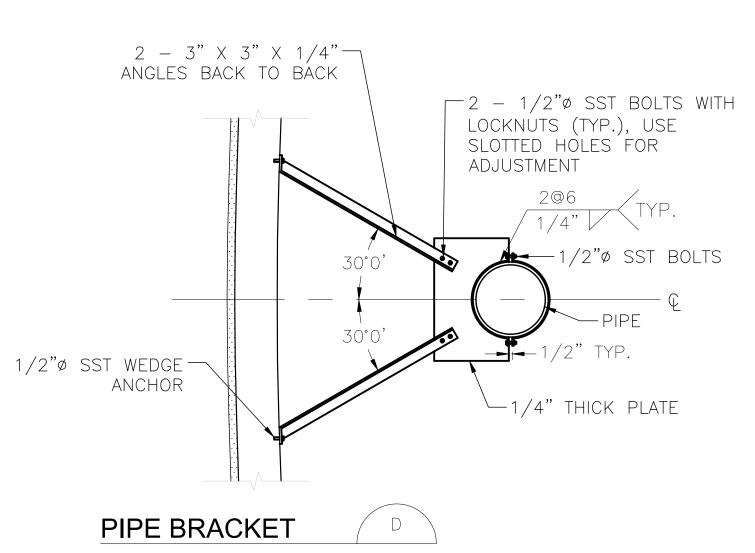

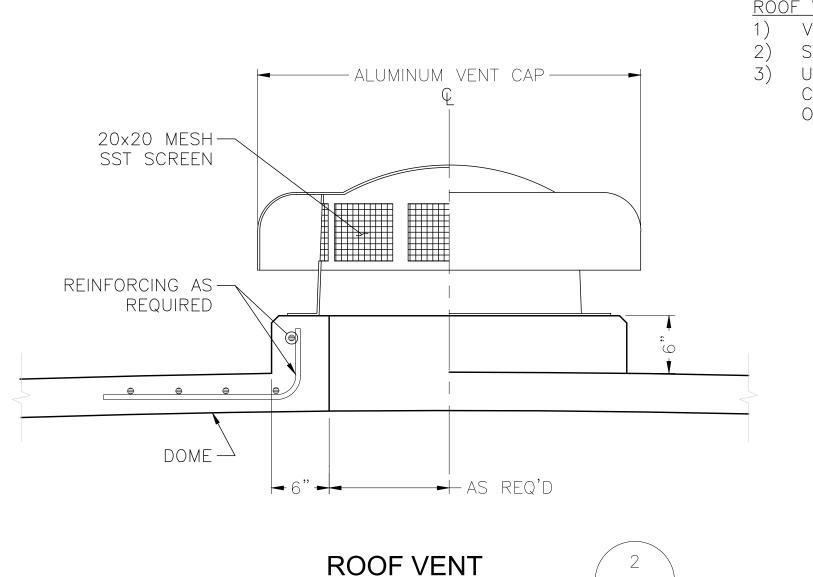

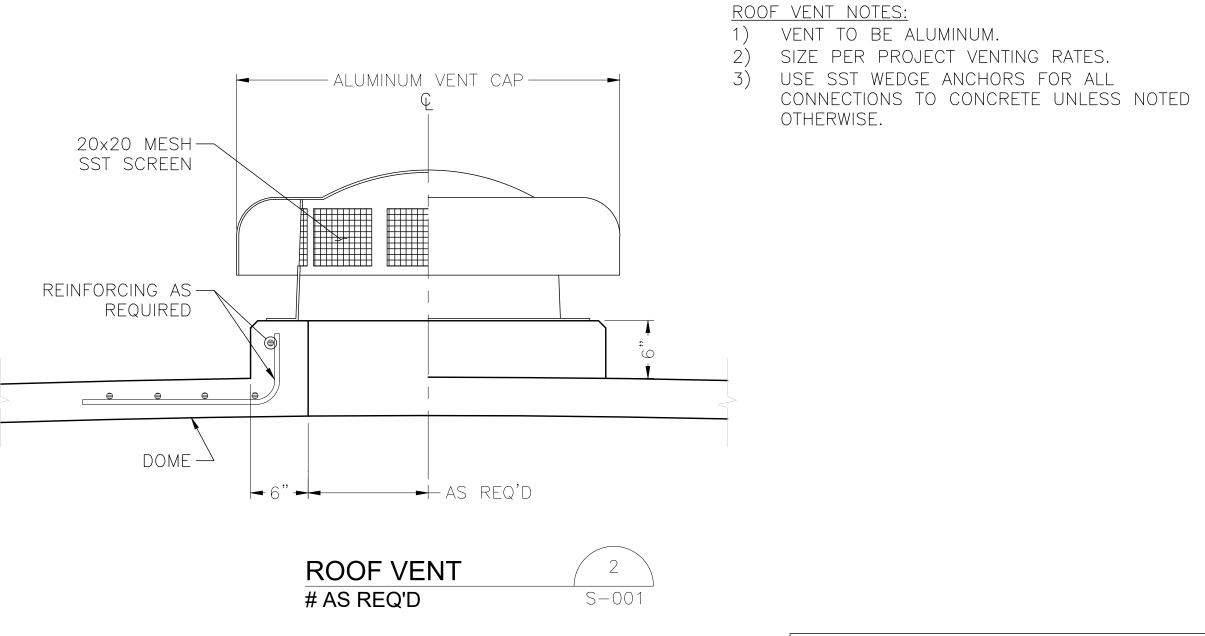

THE DETAILS ON THIS SHEET ARE TYPICAL DETAILS AND ARE SUBJECT TO FINAL DESIGN OF THE TANK MANUFACTURER AND APPROVAL OF ENGINEER.

TATE OF ON

RYAN S.

SCHUSTER

72755

O

5

PROJECT NO.

230264 DISCIPLINE

PROCESS

SHEET NAME

10-D-04

48

SHEET

20

. 1264\DWG\SHEETS\PHASE II\D 230264 - EQ TANK DETAILS.DWG - 20 EQ TANK DETAILS - 9/30/2025 1:33:03 PM - CORY SCOTT

TYPICAL WALL PIPE ENTRANCE

A. WHERE CONFLICT IS FOUND TO EXIST BETWEEN THE SPECIFICATIONS AND THESE NOTES, THE

- B. ALL WORK SHALL CONFORM TO THE MINIMUM REQUIREMENTS OF THE OHIO BUILDING CODE LATEST EDITION) OR THESE DOCUMENTS - WHICHEVER IS MORE STRINGENT.
- 3. UNLESS SHOWN OR NOTED OTHERWISE ON THE CONTRACT DRAWINGS OR IN THE SPECIFICATIONS, THE FOLLOWING NOTES SHALL APPLY TO THE MATERIALS LISTED HEREINAFTER FOR USE ON THIS PROJECT.
- 4. IF MATERIALS, QUANTITIES, STRENGTHS OR SIZES INDICATED BY THE DRAWINGS OR SPECIFICATIONS ARE
- 6. SHOP DRAWINGS PREPARED BY SUPPLIERS AND SUBCONTRACTORS SHALL BE REVIEWED AND APPROVED
- SHOP DRAWINGS PREPARED BY THE CONTRACTORS, SUPPLIERS, ETC., WILL BE REVIEWED BY THE ENGINEER/ARCHITECT ONLY FOR CONFORMANCE WITH DESIGN CONCEPT. NO WORK AFFECTED BY THE SHOP DRAWINGS SHALL BE STARTED WITHOUT SUCH REVIEW.
- 8. THE GENERAL CONTRACTOR SHALL COORDINATE ALL REVISIONS, CORRECTIONS, AND COMMENTS INDICATED ON THE SHOP DRAWINGS BY THE ARCHITECT/ENGINEER.
- 9. ALL DIMENSIONS AND ELEVATIONS SHOWN ON THE STRUCTURAL DRAWINGS SHALL BE VERIFIED BY THE CONTRACTOR AND SHALL CONFORM TO THOSE SHOWN ON THE ARCHITECTURAL DRAWINGS. BY THE CONTRACTOR PRIOR TO USING THEM FOR ANY CONSTRUCTION.
- 10. THE STRUCTURAL CONTRACT DOCUMENTS DO NOT INDICATE THE METHOD OF CONSTRUCTION. THE CONTRACTOR SHALL SUPERVISE AND DIRECT THE WORK AND SHALL BE SOLELY RESPONSIBLE FOR ALL CONSTRUCTION MEANS, METHODS, TECHNIQUES, SEQUENCES AND PROCEDURES. OBSERVATION VISITS TO THE SITE BY THE ENGINEER SHALL NOT INCLUDE INSPECTIONS OF THE PROTECTIVE MEASURES OR
- 11. ANY SUPPORT SERVICES PERFORMED BY THE ENGINEER DURING CONSTRUCTION SHALL BE DISTINGUISHED FROM CONTINUOUS AND DETAILED INSPECTION SERVICES WHICH ARE FURNISHED BY ASSISTING IN QUALITY CONTROL AND IN ACHIEVING CONFORMANCE WITH THE CONSTRUCTION DOCUMENTS. THEY DO NOT GUARANTEE CONTRACTOR'S PERFORMANCE AND SHALL NOT BE CONSTRUED AS SUPERVISION OF CONSTRUCTION.
- 12. ALL REQUIRED MATERIAL TESTING SHALL BE PERFORMED AT THE EXPENSE OF CONTRACTOR AND PERFORMED BY AN APPROVED TESTING AGENCY OR LABORATORY. TEST RESULTS SHALL BE SUBMITTED TO THE ENGINEER FOR REVIEW.
- 13. THE OWNER SHALL EMPLOY A TESTING AGENCY TO PERFORM SPECIAL INSPECTIONS. CONTRACTOR SHALL ADHERE TO THE STRUCTURAL QUALITY ASSURANCE PLAN AS PER SECTION 17 OF THE IBC 2018. THE CONTRACTOR SHALL COORDINATE WITH THE SPECIAL INSPECTOR.
- 14. THE CONTRACTOR SHALL BE SOLELY RESPONSIBLE FOR REPAIR OR REPLACEMENT OF ANY WORK THAT IS DAMAGED OR IS NON-COMPLIANT IN ACCORDANCE WITH THE GOVERNING CODE OR AS INDICATED IN THE CONTRACT DOCUMENTS OR AS DEMEANED BY THE BUILDING OFFICIAL, ARCHITECT OR ENGINEER OF
- 15. ALL STRUCTURES ARE DESIGNED TO BE STABLE AND SELF-SUPPORTING AT THE COMPLETION OF CONSTRUCTION. CONTRACTOR SHALL HAVE SOLE RESPONSIBILITY FOR THE DESIGN, ADEQUACY, AND SAFETY OF ERECTION BRACING, SHORING, AND TEMPORARY SUPPORTS OF THE STRUCTURE SO THAT IT WILL BE STABLE DURING ALL STAGES OF CONSTRUCTION. THE STRUCTURE IS DESIGNED FOR A COMPLETED CONDITION ONLY AND THEREFORE MAY REQUIRE ADDITIONAL SUPPORT TO MAINTAIN STABILITY BEFORE COMPLETION. PROVIDE TEMPORARY SHORING FOR EXISTING CONSTRUCTION UNTIL NEW CONSTRUCTION IS IN PLACE AND PROPERLY ANCHORED IN FINAL FORM.
- CONCRETE BASE SLAB, WALLS AND STRUCTURAL SLAB HAVE REACHED A 28 DAY CONCRETE STRENGTH
- A. EXCEPTION, TALL BELOW GRADE STRUCTURES MAY BE PARTIALLY BACKFILLED AFTER THE CONCRETE BASE SLAB AND WALLS HAVE REACHED A 28 DAY CONCRETE STRENGTH (F'C = 4.5 KSI). BACKFILL SHALL HELD BELOW THE TOP OF WALL BY AT LEAST TWICE THE WIDTH OR TWICE THE LENGTH OF THE LARGER DISTANCE. THE REMAINDER OF THE STRUCTURES SHALL NOT BE BACKFILLED UNTIL THE CONCRETE STRUCTURAL SLAB HAVE REACHED A 28 DAY CONCRETE STRENGTH (F'C = 4.5 KSI).
- 17. CAST-IN-PLACE CONCRETE STRUCTURAL SLAB(S) SHALL BE SHORED UNTIL THE STRUCTURAL SLAB HAS REACHED A 28 DAY CONCRETE STRENGTH (F'C = 4.5 KSI).
- 18. SHORING LOADS FOR EXISTING STRUCTURE ARE SHOWN IN THE DOCUMENTS. SHORING SHALL BE
- 19. ALL MATERIALS AND EQUIPMENT FURNISHED WILL BE NEW AND OF GOOD QUALITY, FREE FROM FAULTS AND DEFECTS AND IN CONFORMANCE WITH THE CONTRACT DOCUMENTS. ALL SUBSTITUTIONS MUST BE PROPERLY APPROVED AND AUTHORIZED PRIOR TO INSTALLATION. THE CONTRACTOR SHALL FURNISH SATISFACTORY EVIDENCE AS TO THE KIND AND QUALITY OF MATERIALS AND EQUIPMENT BEING
- 20. THE CONTRACTOR SHALL BE RESPONSIBLE FOR INITIATING, MAINTAINING AND SUPERVISING ALL SAFETY PRECAUTIONS AND PROGRAMS IN CONNECTION WITH THE WORK.
- 22. COORDINATE WITH CIVIL, MECHANICAL, PROCESS, AND ELECTRICAL DRAWINGS FOR PIPE SLEEVES. FLOOR DRAINS, ROOF DRAINS, INSERTS, HANGERS, TRENCHES, PITS, WALL AND SLAB OPENINGS. CONDUIT RUNS IN WALLS AND SLABS, SIZE AND LOCATION OF MACHINE OR EQUIPMENT SUPPORTS, BASE AND ANCHOR BOLTS, RAILING, ETC. THE CONTRACTOR SHALL PROVIDE THESE OPENINGS IN ACCORDANCE WITH THE OTHER CONTRACT DRAWINGS. REINFORCEMENT AROUND OPENINGS FOR NEW WALLS AND SLABS SHALL BE PER THE STANDARD DETAILS. UNLESS OTHERWISE SHOWN, SEE STANDARD
- 24. EARTHWORK, FOUNDATION DRAINS, WATERPROOFING, PERIMETER INSULATION, MASONRY AND OTHER REQUIRED NON-STRUCTURAL ITEMS ARE NOT SHOWN ON THE STRUCTURAL DRAWINGS. COORDINATE WITH CIVIL/SITE AND ARCHITECTURAL DRAWINGS.
- 25. THE CONTRACTOR SHALL COORDINATE ALL CONSTRUCTION ACTIVITIES WITH THE OWNER TO AVOID
- 26. MATERIALS AND EQUIPMENT NECESSARY TO COMPLETE THE WORK SHALL BE STORED AT OWNER'S

- 29. LIVE LOAD SIGNS SHALL BE PROVIDED IN AREAS DESIGNATED BY THE ARCHITECT, ENGINEER OR
- WHERE NOTED OTHERWISE ON THE PLANS
- 31. NO SUBSTITUTIONS OF MATERIAL WILL BE ALLOWED WITHOUT WRITTEN PERMISSION FROM THE

GOVERNING CODES AND STANDARDS:

THE FOLLOWING CODES AND STANDARDS SHALL BE UTILIZED BY THE CONTRACTOR TO ESTABLISH MINIMUM LEVELS OF QUALITY AND CONSTRUCTION TECHNIQUES. UNLESS NOTED OTHERWISE, REFERENCE THE BUILDING CODE AND/OR ASCE FOR THE REFERENCED STANDARD'S EDITION.

- OHIO BUILDING CODE, 2018 EDITION (OBC) AND THE INTERNATIONAL BUILDING CODE, (IBC) 2018 EDITION, LOCALLY AMENDED. THE ABOVE SHALL GOVERN EXCEPT WHERE OTHER APPLICABLE CODES OR CONTRACT PROVISIONS ARE MORE RESTRICTIVE.

- INTERNATIONAL EXISTING BUILDING CODE, 2018 EDITION - MINIMUM DESIGN LOADS FOR BUILDINGS AND OTHER STRUCTURES, 2016 EDITION ASCE 7 ACI 318 - BUILDING CODE REQUIREMENTS FOR STRUCTURAL CONCRETE

- CODE REQUIREMENTS FOR ENVIRONMENTAL ENGINEERING CONCRETE STRUCTURES ACI 350.3 - SEISMIC DESIGN OF LIQUID-CONTAINING CONCRETE STRUCTURES ACI 350.1 - TIGHTNESS TESTING OF ENVIRONMENTAL ENGINEERING CONCRETE STRUCTURES

ACI 301 - SPECIFICATIONS FOR STRUCTURAL CONCRETE FOR BUILDINGS - RECOMMENDED PRACTICE FOR CONCRETE FLOOR AND SLAB CONSTRUCTION ACI 544 - GUIDE FOR SPECIFYING, PROPORTIONING, MIXING, PLACING, AND FINISHING STEEL FIBER

REINFORCED CONCRETE - GUIDE TO FORMWORK FOR CONCRETE ACI 345R - HOT WEATHER CONCRETING

- COLD WEATHER CONCRETING ACI 306R - GUIDE TO MASS CONCRETE ACI 211.1 - SELECTING PROPORTIONS FOR NORMAL, HEAVY WEIGHT AND MASS CONCRETE ACI 217.4R - COOLING AND INSULATING SYSTEMS FOR MASS

ACI SP-66 - ACI DETAILING MANUAL - DESIGN AND CONTROL OF CONCRETE MIXTURES - MANUAL OF STANDARD PRACTICE

MNL 120 - PRECAST/PRESTRESSED CONCRETE INSTITUTE DESIGN HANDBOOK - DESIGN HANDBOOK FOR PRECAST AND PRESTRESSED CONCRETE - LOAD AND RESISTANCE FACTOR DESIGN SPECIFICATIONS FOR STRUCTURAL STEEL

BUILDINGS - SEISMIC PROVISIONS FOR STRUCTURAL STEEL BUILDINGS

AISC DESIGN GUIDE 27 - STRUCTURAL STAINLESS STEEL ALUMINUM DESIGN MANUAL AWS D1.1 - STRUCTURAL WELDING CODE - STEEL

AWS D1.2 - STRUCTURAL WELDING CODE - ALUMINUM AWS D1.3 - STRUCTURAL WELDING CODE - SHEET STEEL AWS D1.4 - STRUCTURAL WELDING CODE - REINFORCING STEEL AWS D1.6 - STRUCTURAL WELDING CODE - STAINLESS STEEL AWS D1.8 - STRUCTURAL WELDING CODE - SEISMIC SUPPLEMENT

NAAMM MGB 531 - METAL BAR GRATING MANUAL NAAMM MGB 532 - HEAVY DUTY METAL BAR GRATING MANUAL

COMPLY WITH THE CONSTRUCTION DOCUMENTS.

SHOP DRAWINGS AND SUBMITTALS

A. REPRODUCTION OF STRUCTURAL DRAWINGS FOR SHOP DRAWINGS IS NOT PERMITTED. B. ELECTRONIC DRAWING FILES WILL NOT BE PROVIDED TO THE CONTRACTOR. C. REVIEW OF SHOP DRAWINGS WILL BE FOR CONFORMANCE WITH THE CONSTRUCTION DOCUMENTS REGARDING ARRANGEMENT AND SIZES OF MEMBERS AND THE CONTRACTOR'S INTERPRETATION OF THE DESIGN LOADS, IF APPLICABLE, AND CONSTRUCTION DOCUMENT DETAILS. SUCH REVIEW SHALL NOT RELIEVE THE CONTRACTOR OF THE FULL RESPONSIBILITY TO

A. THE STRUCTURAL QUALITY ASSURANCE PLAN AND SPECIFICATIONS IDENTIFY THE REQUIRED SUBMITTALS. PRIOR TO (OR WITH) THE FIRST SUBMITTAL, CONTRACTOR SHALL SUBMIT A LIST OF ALL REQUIRED SUBMITTALS FOR ENGINEER'S REVIEW.

A. DEFERRED SUBMITTALS INCLUDE THOSE PORTIONS OF THE PROJECT THAT ARE FURNISHED BY THE CONTRACTOR AND DESIGNED BY SOMEONE OTHER THAN THE ENGINEER OF RECORD AND ARE SUBMITTED AT THE TIME OF THE APPLICATION. DEFERRED SUBMITTALS SHALL BE SUBMITTED TO THE BUILDING OFFICIAL PRIOR TO FABRICATION AND INSTALLATION.

B. SUBMITTAL DOCUMENTS FOR DEFERRED SUBMITTALS: SHALL BE INCLUDED IN THE CONTRACTOR'S SCOPE OF SERVICES AND SHALL BE SEALED BY AN ENGINEER LICENSED IN THE PROJECT STATE. DESIGN OF DEFERRED SUBMITTALS SHALL

BE IN ACCORDANCE WITH THE GOVERNING BUILDING CODE INDICATED ABOVE. b. SHALL BE SUBMITTED TO THE REGISTERED DESIGN PROFESSIONAL IN RESPONSIBLE CHARGE WHO SHALL REVIEW AND FORWARD THEM TO THE BUILDING OFFICIAL WITH A NOTATION INDICATING THE DEFERRED SUBMITTAL DOCUMENTS HAVE BEEN REVIEWED AND THAT THEY HAVE BEEN FOUND IN GENERAL CONFORMANCE WITH THE DESIGN OF THE BUILDING. DEFERRED SUBMITTAL ITEMS SHALL NOT BE INSTALLED UNTIL THE DESIGN AND SUBMITTAL DOCUMENTS HAVE BEEN APPROVED BY THE BUILDING OFFICIAL

c. SUBMITTAL DOCUMENTS MAY ALSO INCLUDE SUBSTANTIATING CALCULATIONS, WHEN

C. THE FOLLOWING SHALL BE CONSIDERED DEFERRED SUBMITTALS:

a. TEMPORARY/PERMANENT SHORING AND UNDERPINNING AGGREGATE PIER SOIL REINFORCEMENT

c. GROUND IMPROVEMENT METHODS

d. STRUCTURAL PRECAST CONCRETE

 e. ARCHITECTURAL PRECAST CONCRETE ENGINEERED BRICK LINTELS

STEEL CONNECTIONS - SEE "STRUCTURAL STEEL" SECTION COLD-FORMED METAL FRAMING

PREFABRICATED COLD-FORMED STEEL TRUSSES

STEEL STAIRS AND HANDRAILS SHOP-FABRICATED WOOD TRUSSES

CURTAIN WALL/WINDOW WALL SYSTEMS

m. SKYLIGHTS

n. METAL BUILDING SYSTEM

o. ELEVATORS

<u>DESIGN LOADS</u>:

LΙ\	/E LOADS: (REDUCIBLE PER GOVERNING CODE)	UNIFORM (PSF)	CONCENTRATED (LBS)
A.	ROOF	, ,	• •
	1. TYPICAL AREA	20	300
	HVAC MECHANICAL EQUIPMENT AREAS	150	2,000
R	FIRST FLOOR	100	2,000

ELECTRICAL CONTROL ROOM 3,000 D. PROCESS AREA SLAB-ON-GRADE 3.000 STRUCTURAL FLOOR 3.000 3. ELECTRICAL AND CONTROL ROOM FLOOR 3.000

NON-EGRESS WALKWAYS/CATWALKS 2,000 AASHTO HL93 LOADING E. TRUCK ACCESS AREAS USE AASHTO STANDARD SPECIFICATION FOR HIGHWAY BRIDGES FOR IMPACT FORCES

SNOW LOADS: RISK CATEGORY GROUND SNOW LOAD, Po 30 PSF FLAT ROOF SNOW LOAD, Pf 23 PSF SNOW EXPOSURE FACTOR, Ce 1.0 SNOW LOAD IMPORTANCE FACTOR, Is 1.1

WIND LOADS ULTIMATE DESIGN WIND SPEED (3-SECOND GUST), MPH 116 **RISK CATEGORY** WIND EXPOSURE

COMPONENTS AND CLADDING WIND EXPOSURE DESIGN WIND PRESSURE FOR COMPONENTS AND CLADDING SHALL BE COMPUTED PER GOVERNING BUILDING CODE

4. EARTHQUAKE DESIGN DATA: OCCUPANCY RISK CATEGORY SEISMIC IMPORTANCE FACTOR, Ie MAPPED SPECTRAL RESPONSE ACCELERATIONS DESIGN SPECTRAL RESPONSE ACCELERATIONS

DESIGN SPECTRAL RESPONSE ACCELERATIONS S_{ds} = 0.167

SEISMIC DESIGN CATEGORY BASIC SEISMIC REINFORCING SYSTEM: ORDINARY PRECAST SHEAR WALLS (ASSUMED)* SEISMIC RESPONSE COEFFICIENT C_s = TO BE DETERMINED*

RESPONSE MODIFICATION COEFFICIENT ANALYSIS PROCEDURE USED: EQUIVALENT LATERAL FORCE (ASSUMED)* * TO BE DETERMINED BY DELEGATED DESIGN ENGINEER

- FOUNDATION DESIGN IS BASED ON RECOMMENDATIONS IN THE GEOTECHNICAL REPORT NO. 230264, PREPARED BY CT CONSULTANTS, INC., DATED SEPTEMBER 14, 2023. CONTRACTOR SHALL REVIEW GEOTECHNICAL REPORT PRIOR TO CONSTRUCTION AND ADHERE TO THE RECOMMENDATIONS.
- GEOTECHNICAL REPORT. A. OTHER SOIL LOADING AND BEARING CHARACTERISTICS ARE DESCRIBED IN THE REPORT.
- B. REFERENCE GEOTECHNICAL REPORT FOR FROST DEPTH (OR FROST DEPTH IS 40"). EXTERIOR FOOTINGS SHALL BEAR AT FROST DEPTH, OR DOWN TO ACCEPTABLE SOILS, WHICHEVER IS
- 95% PER ASTM D698 (STANDARD PROCTOR) AND MEETING THE SPECIFIED DESIGN BEARING
- 4. OWNER SHALL EMPLOY A SOILS TESTING LABORATORY APPROVED BY THE ENGINEER TO PERFORM TESTING SERVICES AS REQUIRED BY THE SPECIFICATIONS AND TO INSPECT ALL BEARING SURFACES
- 5. NOTIFY ENGINEER IF FOUNDATION CONDITIONS ENCOUNTERED DIFFER FROM SOILS EXPLORATION INFORMATION MADE AVAILABLE TO THE CONTRACTOR.
- 6. EXCAVATIONS FOR FOUNDATIONS SHOULD BE OBSERVED BY THE GEOTECHNICAL ENGINEER PRIOR TO PLACEMENT OF REINFORCING STEEL AND CONCRETE. UNDERCUT UNSUITABLE SOILS AND BACKFILL AS DIRECTED BY THE GEOTECHNICAL ENGINEER.
- FILLS AND ORGANIC SOILS ENCOUNTERED WITHIN AND BELOW THE AREA TO BE OCCUPIED BY SLABS ON GRADE AND FOUNDATIONS. THESE MATERIALS SHALL NOT BE USED FOR FILL WITHIN OR ADJACENT TO THE BUILDING. AFTER EXCAVATING THE EXPOSED NATURAL SOIL SHALL BE THOROUGHLY COMPACTED PRIOR TO PLACEMENT OF FILL OR AS DIRECTED BY THE GEOTECHNICAL
- 8. BACKFILL AND BACKFILL PLACEMENT SHALL BE AS PER THE GEOTECHNICAL ENGINEERS MAXIMUM 8" LIFTS AND COMPACT AS PER THE GEOTECHNICAL.
- 9. CONTRACTOR SHALL KEEP ALL FREE-STANDING WATER OUT OF EXCAVATIONS. CONTRACTOR SHALL BE REMOVED FROM THE FOUNDATION BOTTOMS BEFORE CONCRETE OR REINFORCING STEEL IS
- 10. CHANGES IN ELEVATION OF WALL FOOTING SHALL BE MADE IN STEPS NOT MORE THAN 2'-0" HIGH AND
- 11. THE CONTRACTOR IS RESPONSIBLE FOR AND SHALL PROVIDE TEMPORARY SHORING, BRACING, UNDERPINNING, AND OTHER MEASURES NECESSARY TO INSURE STABILITY AND SAFETY DURING ERECTION AND CONSTRUCTION AND TO PREVENT MOVEMENT OF SOIL THAT COULD DAMAGE EXISTING STRUCTURES, PAVEMENT, UTILITIES, ETC.
- 12. CENTER FOOTINGS UNDER COLUMNS AND WALLS UNLESS NOTED.
- 13. THE DIFFERENCE IN ELEVATION OF THE BACKFILL ON THE INSIDE AND OUTSIDE OF WALLS SHALL NOT EXCEED TWO FEET UNTIL THE FIRST FLOOR STRUCTURE SUPPORTING THE WALLS IS IN PLACE, UNLESS THE WALL IS BRACED TO PREVENT MOVEMENT.
- 10-FEET OF THE PERIMETER OF THE FOUNDATION SYSTEM TO ALLOW SURFACE WATER TO DRAIN

15. DO NOT PLACE FILL OR CONCRETE ON FROZEN GROUND.

REINFORCEMENT

- ALL DETAILING, FABRICATION AND ERECTION OF REINFORCING BARS, UNLESS OTHERWISE NOTED SHALL BE IN ACCORDANCE WITH MANUAL OF STANDARD PRACTICE FOR DETAILING REINFORCED CONCRETE STRUCTURES (ACI-315, LATEST EDITION) AND MANUAL OF STANDARD PRACTICE FOR DETAILING REINFORCED CONCRETE STRUCTURES (CRSI, LATEST EDITION). REINFORCING STEEL SHALL NOT BE HEATED OR WELDED AND MUST BE DRY AND FREE OF CONTAMINANTS SUCH AS RUST,
- 2. ALL REINFORCING STEEL SHALL CONFORM TO ASTM A615 GRADE 60. ALL REINFORCING USED IN SEISMIC DESIGN CATEGORY (SDC) D AND HIGHER OR REINFORCING TO BE WELDED SHALL CONFORM TO ASTM A706 GRADE 60. REINFORCING STEEL SHALL NOT BE HEATED OR WELDED AND MUST BE DRY AND FREE OF CONTAMINANTS SUCH AS RUST, DIRT, GREASE, AND PROTECTIVE COATINGS.
- 3. WHERE GRADE BEAMS OR STRIP FOOTINGS INTERSECT COLUMN FOUNDATIONS, EXTEND GRADE BEAM OR STRIP FOOTING REINFORCEMENT CONTINUOUSLY THROUGH THE COLUMN FOUNDATION.
- 4. ALL WELDED WIRE REINFORCING SHALL CONFORM TO ASTM A185, A1064 PROVIDED IN FLAT SHEETS.
- 5. PROVIDE DOWELS FROM FOUNDATIONS TO MATCH COLUMN, PIER AND WALL VERTICAL REINFORCING. WHERE SHOWN, PROVIDE DOWELS OUT OF WALLS TO MATCH SLAB REINFORCING. PROVIDE ADEQUATE BOLSTERS, HI-CHAIRS, SUPPORT BARS, ETC., TO MAINTAIN SPECIFIED ON EXPOSED SURFACES SHALL BE A CRSI CLASS 1. STRUCTURAL SLABS SHALL UTILIZE A CRSI
- 6. ALL DEVELOPMENT AND SPLICE LENGTHS SHALL BE PER ACI 318 WITH CLEAR SPACING GREATER OR EQUAL TO 3 BAR DIAMETER. PROVIDE CLASS "B" TENSION LAP SPLICE OR FULL MECHANICAL SPLICE (ACI 318. SECT. 25.4.2) FOR ALL REINFORCING STEEL IN WALLS, COLUMNS, AND SLABS. SEE LAP SCHEDULE ON SHEET SD-S-02 FOR LAP LENGTHS, UNO.
- 7. LAP SPLICES SHALL NOT BE MADE AT POINTS OF MAXIMUM STRESS AS DETERMINED BY THE ENGINEER. LAP SPLICES FOR CONTINUOUS SLAB OR LONGITUDINAL BEAM BARS, WITH DOUBLE MAT OF REINFORCING, SHALL BE LOCATED IN THE MIDDLE 1/3 OF THE SPAN FOR TOP BARS AND CENTERED OVER THE SUPPORT FOR THE BOTTOM BARS. LAP SPLICE IN BEAMS, CONTINUOUS SLABS AND WALLS SHALL BE STAGGERED. CENTERLINE OF STAGGERS SHALL BE A MINIMUM OF A SPLICE LENGTH APART.
- 8. A TOP BAR IS A HORIZONTAL BAR WHERE MORE THAN 12 INCHES OF FRESH CONCRETE IS CAST DIRECTLY BELOW THE BAR. HORIZONTAL WALL BARS ARE CONSIDERED TOP BARS. FOR EPOXY-COATED REINFORCEMENT, MULTIPLY THE TABULATED VALUES BY 1.5 FOR 'REGULAR BARS' AND 1.3 FOR 'TOP BARS'.
- THE GENERAL PLACEMENT OF REINFORCING, CONSTRUCTION JOINTS, CONTROL JOINTS, EXPANSION JOINTS, CONCRETE MEMBER DIMENSIONS, DOWELS, BAR LENGTHS, SPLICE LENGTH, AND REINFORCING BEND TABLES.
- 10. TACK WELDING OR WELDING OF REBAR SHALL NOT BE PERMITTED UNLESS OTHERWISE CALLED FOR OR APPROVED BY THE ENGINEER. IF APPROVED, REINFORCING MAY BE WELDED IN ACCORDANCE WITH AWS SPECIFICATION D1.4. ALL REINFORCING TO BE WELDED SHALL CONFORM TO ASTM A706.
- A. IN SLABS, #5 RAISER BARS AT 36" ON CENTER MAXIMUM TO SUPPORT TOP REINFORCING STEEL B. IN WALLS WITH TWO CURTAINS, #3 U OR Z-SHAPE SPACERS AT 6'-0 " ON CENTER EACH WAY.

12. CONCRETE CONSTRUCTION SHALL BE REINFORCED CONCRETE EXCEPT WHERE PLAIN CONCRETE IS INDICATED ON THE DRAWINGS. UNLESS OTHERWISE NOTED, MINIMUM REINFORCING STEEL SHALL BE PROVIDED IN ACCORDANCE WITH THE FOLLOWING SCHEDULES:

SLAB THICKNESS	SIZE	SPACING E.W.	LOCATION
4"	#3	⊑.vv. 12"	CENTERED
5"	#4	12"	CENTERED
6"	#4	12"	CENTERED
8"	#4	12"	T & B
9"	#4	12"	T & B
10"	#4	12"	T & B
12"	#5	12"	T & B
WALL THICKNESS	SIZE	SPACING E.W.	LOCATION
6"	#4	12"	CENTERED
8"	#5	12"	CENTERED
10"	#4	12"	EF
12"	#5	12"	EF
14"	#5	12"	EF
16"	#6	12"	EF
18"	#6	12"	FF

MASS CONCRETE SHALL BE REINFORCED WITH #6 @ 12" E.W. MINIMUM IN ALL FACES. HIGHER MINIMUM STEEL IS PROVIDED IN WATER CONTAINING STRUCTURES.

- 14. ALL HOOKS SHALL BE ACI STANDARD HOOKS UNLESS DIMENSIONED OTHERWISE. BARS ENDING IN RIGHT ANGLE BENDS OR HOOKS SHALL CONFORM TO THE REQUIREMENTS OF ACI 318, SECT. 25.3. IN CASES WHERE REINFORCING BARS CANNOT BE EXTENDED AS REQUIRED TO PROVIDE SPECIFIED DEVELOPMENT LENGTH DUE TO AN ADJACENT STRUCTURE, EXTEND AS FAR AS POSSIBLE AND END IN STANDARD HOOKS.
- 15. LAP SPLICE WELDED WIRE FABRIC ONE SPACE PLUS 2 INCHES AT EDGES AND ENDS AND PROVIDE ADDITIONAL REINFORCING WHERE SHOWN ON DRAWINGS. PLACE MESH 2 INCHES FROM TOP OF SLAB FOR SLABS ON GROUND AND 1 INCH FROM TOP OF SUPPORTED SLABS UNLESS NOTED OTHERWISE.
- FIBER UNIFORMLY DISPERSED IN THE CONCRETE MIXTURE PER THE MANUFACTURER'S

- ALL CONCRETE WORK SHALL BE IN ACCORDANCE WITH ACI 318 AND ACI 350.
- 2. CONCRETE SHALL HAVE THE FOLLOWING 28-DAY COMPRESSIVE STRENGTHS: CAST-IN-PLACE CONCRETE: 4,500 PSI FILL CONCRETE:
- 3. USE 6% ±1.5%, ENTRAINED AIR PER ASTM C260 FOR ALL CONCRETE EXPOSED TO WEATHER.
- TESTED IN ACCORDANCE WITH AASHTO T260.
- 5. CONCRETE SHALL BE PROPORTIONED, BATCHED, MIXED, PLACED, CONSOLIDATED, AND CURED IN ACCORDANCE WITH ACI 301,304,308,309 AND 318. ALL CONCRETE SHALL BE MECHANICALLY VIBRATED IN ACCORDANCE WITH ACI 304 AND ACI 309.
- STRUCTURAL CONCRETE ACI 301 WITH SELECTED ACI REFERENCES", (ACI PUBLICATION SP-15) AT THE PROJECT FIELD OFFICE.
- 8. SUBMIT FOR APPROVAL CONCRETE MIX DESIGN AND CERTIFICATION OF CONCRETE MATERIALS

R SLAI
<u>SS</u> :

- 9. THE CONTRACTOR SHALL EMPLOY A TESTING LABORATORY APPROVED BY THE ENGINEER/ARCHITECT TO PERFORM THE TESTING SPECIFIED PER PARAGRAPH 1.6.4 OF ACI 301. THE TESTING LABORATORY SHALL MEET THE REQUIREMENTS OF ASTM E329. TESTING SHALL BE MADE BY AN ACI CONCRETE FIELD-TESTING TECHNICIAN GRADE 1 OR APPROVED EQUIVALENT. A TECHNICIAN GRADE 1 SHALL BE PRESENT DURING ALL CONCRETE PLACEMENT.
- 10. ALL SLABS SHALL BE POURED MONOLITHICALLY, EXCEPT FOR THE REQUIRED CONSTRUCTION JOINTS, CONTROL JOINTS, AND/OR EXPANSION JOINTS.
- ARCHITECTURAL DRAWINGS. 12. PROVIDE 3/4 INCH CHAMFER ON ALL EXPOSED CORNERS OF SLABS UNLESS OTHERWISE INDICATED
- 13. CURE ALL CONCRETE FOR A MINIMUM 7-DAYS. APPLY CURING COMPOUND AT THE MAXIMUM COVERAGE RATE OF 300 SQUARE FEET PER GALLON. USE PRODUCT IN STRICT ACCORDANCE WITH THE MANUFACTURER'S RECOMMENDATIONS. SEE SPECIFICATIONS.
- 14. DO NOT BACKFILL WATERHOLDING STRUCTURES UNTIL THE CONCRETE HAS REACHED A 28-DAY CONCRETE STRENGTH.
- 15. CONTRACTOR SHALL PROVIDE BONDING AGENT TO ALL SURFACES BETWEEN EXISTING AND FRESH CONCRETE. BONDING AGENT SHALL BE INSTALLED IN STRICT ACCORDANCE WITH MANUFACTURERS RECOMMENDATIONS. PRIOR TO APPLICATION OF BONDING AGENT, THE EXISTING CONCRETE BASE SURFACE SHALL BE THOROUGHLY CLEANED TO REMOVE ANY GREASE, OIL OR OTHER CONTAMINANTS THAT MAY PREVENT ADEQUATE BOND TO THE EXISTING CONCRETE. REMOVE WEAK
- 16. THE CONCRETE INTERFACE OF ALL CONSTRUCTION JOINTS SHALL BE ROUGHEN TO 1/4", MINIMUM, AMPLITUDE. PRIOR TO CASTING AGAINST THE GREEN CONCRETE, APPLY BONDING AGENT (OR GREEN CONCRETE SHALL BE SATURATED SURFACE DRY. WET GREEN CONCRETE FOR A MINIMUM OF 8". REMOVE ANY STANDING WATER).
- 17. CONTRACTOR SHALL SUBMIT PROPOSED LOCATIONS OF CONSTRUCTION JOINTS NOT INDICATED ON THE DRAWINGS FOR REVIEW BY THE ENGINEER/ARCHITECT.
- EPOXY PRIMER, EPOXY PRIMER SHALL BE PRE-APPROVED BY THE ENGINEER. 19. FORMWORK, FOR ALL CONCRETE THAT WILL BE EXPOSED IN THE COMPLETED STRUCTURE, SHALL BE CONSTRUCTED FROM A METAL OR SUITABLE SURFACE PLYWOOD THAT WILL PRODUCE AN
- 20. PITCH CONCRETE SLABS TO FLOOR DRAINS, SUMP PITS, OR STORM SEWER INLETS, COORDINATE WITH MECHANICAL, CIVIL OR ARCHITECTURAL DRAWINGS. SLOPE EXPOSED EXTERIOR SLABS TO SHED WATER. INTERIOR BASE SLABS, WITHOUT DRAINS OR SUMP PITS, SHALL BE MONLITHICALLY SLOPED TOWARD WALL WHERE PRIMARY ENTRY HATCH IS LOCATED.
- 21. FORM TIES SHALL BE FACTORY-FABRICATED SNAP-OFF GLASS-FIBER-REINFORCED PLASTIC OR METAL FORM TIES DESIGNED TO RESIST LATERAL PRESSURE DURING CONCRETE PLACEMENT. FORM TIES SHALL HAVE PLASTIC CONE AND, WHEN USED IN AN ENVIRONMENTAL STRUCTURE, HAVE A WATERSTOP LOCATED AT THE CENTER. FORM TIE UNITS, AFTER BREAKBACK, SHALL BE AT LEAST 1 INCH FROM THE FACE OF THE CONCRETE SURFACE.
- 22. CONCRETE EMBEDS AND PENETRATIONS PIPES AND CONDUITS EMBEDDED IN OR PASSING THROUGH STRUCTURAL ELEMENTS SHALL CONFORM TO ACI 318-6.3



PROJECT NO. 230264

SHEET NAME **20-S-01**

REQUIREMENTS OF THE SPECIFICATIONS SHALL GOVERN.

THESE NOTES ARE GENERAL REQUIREMENTS. SEE SPECIFICATIONS FOR ADDITIONAL REQUIREMENTS.

NOT IN AGREEMENT WITH THESE NOTES, THE CONTRACTOR SHALL CONTACT THE ARCHITECT/ENGINEER

5. TYPICAL DETAILS MAY NOT NECESSARILY BE CUT ON THE PLANS BUT APPLY UNLESS NOTED OTHERWISE.

BY THE GENERAL CONTRACTOR PRIOR TO SUBMISSION TO THE ENGINEER/ARCHITECT.

DIMENSIONS AND ELEVATIONS MARKED "REF" ARE FOR REFERENCE ONLY AND SHALL BE FIELD VERIFIED

THE CONSTRUCTION PROCEDURES. OTHERS. THESE SUPPORT SERVICES PERFORMED BY THE ENGINEER ARE SOLELY FOR THE PURPOSE OF

16. BELOW GRADE CAST-IN-PLACE CONCRETE STRUCTURES SHALL NOT BE BACKFILLED UNTIL THE

DESIGNED AND CERTIFIED BY AN ENGINEER LICENSED IN THE STATE OF OHIO.

SUBSTITUTED.

21. COORDINATE WITH THE ARCHITECTURAL DRAWINGS AND SPECIFICATIONS FOR MISCELLANEOUS STEEL ITEMS, LINTELS, METAL PAN STAIRS, SIZE AND LOCATION OF FLOOR SLOPES, DEPRESSED AREAS, FINISH FILLS, CHAMFERS, GROOVES, RAILING SLEEVES, ROOF EDGES, INSERTS, ETC.

DETAILS FOR CONSTRUCTION OF OPENINGS IN EXISTING WALLS AND SLABS.

23. COORDINATE WITH SITE, ARCHITECTURAL, ELECTRICAL, MECHANICAL, AND CIVIL DRAWINGS FOR RETAINING WALLS, PADS, PAVEMENT AND OTHER SITE STRUCTURES.

SYSTEM/OPERATION INTERRUPTIONS.

27. THE CONTRACTOR SHALL AT ALL TIMES KEEP THE WORK AREA AND SURROUNDING PREMISES FREE OF WASTE, SURPLUS MATERIALS, RUBBISH, AND DEBRIS RESULTING FROM THE WORK. 28. ALL CONTRACTORS SHALL CONFORM TO THE SAFETY REQUIREMENTS OF THE OWNER, AIA DOCUMENTS A201, OSHA SAFETY AND HEALTH STANDARDS, OWNERS SAFETY REGULATIONS, AND ANY OTHER LOCAL AUTHORITY IN CONNECTION WITH THE PROJECT. ALL EXCAVATIONS SHALL BE PROPERLY SHORED IN ACCORDANCE WITH OSHA STANDARDS AND REQUIREMENTS. ENGINEER DOES NOT ASSUME ANY

RESPONSIBILITY FOR CONSTRUCTION SITE SAFETY. REQUIRED BY THE BUILDING OFFICIAL. SIGNS SHALL BE AS REQUIRED IN THE SPECIFICATIONS.

30. SLOPE DRAINAGE SURFACES UNIFORMLY TO DRAIN. SLOPE SHALL BE 1/8" TO 1/4" PER FOOT EXCEPT

p. SLOTTED CHANNEL STRUT FRAMING (E.G. UNISTRUT) q. SEISMIC ANCHORAGE AND BRACING OF MPE EQUIPMENT

4. ELEVATED GRATING FLOORS (FOOT TRAFFIC ONLY) 100 2,000

DUE TO MOVING WHEEL LOADS THERMAL FACTOR, Ct 1.0

INTERNAL PRESSURE COEFFICIENT (ENCLOSED)

 $S_s = 0.156$ $S_1 = 0.049$ $S_{ds} = 0.167$ $S_{d1} = 0.079$ 2. FOUNDATIONS ARE DESIGNED TO BEAR ON UNDISTURBED NATURAL SOILS OR PROPERLY

BEARING CAPACITY OF DEEP FOUNDATIONS, SEE NOTES SPECIFIC TO THE DEEP FOUNDATION

3. TOPSOIL, FILL, AND/OR OTHER DELETERIOUS MATERIALS ENCOUNTERED DURING THE SITE PREPARATION MUST BE REMOVED AND REPLACED WITH SELECT ENGINEERED FILL COMPACTED TO CAPACITY. (SEE GEOTECHNICAL REPORT FOR MORE INFORMATION).

OF SLABS AND FOUNDATIONS.

7. REMOVE ALL EXISTING PAVEMENT, STRUCTURES AND FOUNDATIONS, AND TOPSOIL, UNSUITABLE

RECOMMENDATIONS. IN LIEU OF GEOTECHNICAL ENGINEERS RECOMMENDATIONS BACKFILL SHALL BE CLEAN, CRUSHED STONE (#57 STONE) OR SELECT ENGINEERED FILL AND SHALL BE PLACED IN

PROVIDE DEWATERING MEASURES AS NECESSARY PRIOR TO PLACING CONCRETE. WATER SHOULD

AT LEAST 4'-0" APART, UNLESS DETAILED OTHERWISE. SEE TYPICAL FOOTING STEP DETAIL.

14. UNLESS NOTED OTHERWISE ON THE CIVIL/SITE DRAWINGS, PROVIDE A MINIMUM 2% GRADE WITHIN

DIRT, GREASE, AND PROTECTIVE COATINGS.

CLEARANCES FOR THE ENTIRE LENGTH OF ALL REINFORCING BARS. SUPPORTS THAT BEAR DIRECTLY CLASS 2 SUPPORTS.

9. SUBMIT REINFORCING SHOP DRAWINGS FOR REVIEW. AT A MINIMUM, THESE DRAWINGS SHALL SHOW

11. IN ADDITION TO NORMAL ACCESSORIES USED TO HOLD REINFORCING STEEL FIRMLY IN POSITION, EXTRA ACCESSORY BARS SHALL BE USED AS FOLLOWS:

16. FIBER REINFORCING SHALL CONFORM TO ASTM C1116. FIBER REINFORCEMENT SHALL BE MACRO RECOMMENDATION, BUT NOT LESS THAN A RATE OF 4.0 lb/Cu Yd AND 1.5 INCHES LONG.

CAST-IN-PLACE CONCRETE:

IN CONTACT WITH WATER

CORROSION PROTECTION

4. ADMIXTURES SHALL CONTAIN NO MORE THAN 0.05% CHLORIDE IONS BY WEIGHT OF CEMENT WHEN

6. CONTRACTOR SHALL KEEP A COPY OF "FIELD REFERENCE MANUAL: STANDARD SPECIFICATIONS FOR

7. ALL REINFORCING DETAILS SHALL CONFORM TO THE ACI DETAILING MANUAL, SP-66, UNLESS DETAILED OTHERWISE ON THE STRUCTURAL DRAWINGS.

CONFORMING TO THE FOLLOWING EXPOSURE CATEGORIES:

11. PROVIDE PERIMETER INSULATION AGAINST EXTERIOR FOUNDATION WALLS AND GRADE BEAMS AND UNDER THE SLAB ADJACENT TO THE EXTERIOR OF THE BUILDING AS SHOWN ON THE

ON THE ARCHITECTURAL DRAWINGS. MINIMUM CLEARANCES FOR REINFORCING STEEL SHALL BE MAINTAINED. CHAMFERS SHALL EXTEND 2'-0", MINIMUM, BELOW GRADE.

OR DETERIORATED CONCRETE.

18. ALUMINUM OR DISSIMILAR METALS IN CONTACT WITH CONCRETE SHALL BE COATED WITH GRAY

ACCEPTABLY SMOOTH SURFACE. SEE SPECIFICATIONS.

 \mathbf{m}

STRUCTURAL

- 23. CONCRETE PROTECTION (CLEAR COVER) FOR REINFORCEMENT BARS SHALL BE AS FOLLOWS UNLESS NOTED OTHERWISE:
- A. FOOTINGS AND FOUNDATION MATS CAST ON GROUND:
- 3 INCHES, BOTTOM AND UNFORMED EDGES
- 2 INCHES, FORMED EDGES 2 INCHES, EXPOSED TO EARTH, WATER OR WEATHER
- 2 INCHES, BOTTOM, ON CONCRETE MUDMAT
- B. CONCRETE IN CONTACT WITH SEWAGE OR WATER: SLABS AND WALLS
- 2 INCHES
- COLUMNS AND BEAMS
- 2-1/2 INCHES, PRINCIPAL REINFORCEMENT
- 2 INCHES, STIRRUPS & TIES C. CONCRETE IN CONTACT WITH GROUND OR WEATHER:
- SLABS AND WALLS
- 2 INCHES
- COLUMNS AND BEAMS 2-1/2 INCHES, PRINCIPAL REINFORCEMENT
- 2 INCHES, STIRRUPS & TIES
- D. CONCRETE NOT TO BE EXPOSED TO GROUND, WEATHER OR LIQUID SLABS AND WALLS
- 3/4 INCHES, BARS GREATER THAN #5
- 1/2 INCHES, BARS #5 OR LESS COLUMNS AND BEAMS
- 1-1/2 INCHES, PRINCIPAL REINFORCEMENT
- E. 1 INCHES, STIRRUPS & TIES
- 24. ANCHOR BOLTS SHALL BE ASTM F1554-55 UNLESS OTHERWISE NOTED. EMBEDMENT, EDGE DISTANCES AND ALLOWABLE LOADS SHALL CONFORM TO IBC TABLE 1912.2 OR AS NOTED ON THE DRAWINGS. CONFORM TO ADDITIONAL REQUIREMENTS IN SPECIFICATION 05 SECTION AS APPLICABLE.
- 25. PROVIDE ANCHORAGE INSERTS WHERE SHOWN ON CONCRETE WALLS AND CONCRETE CEILINGS IN GALLERIES, PIPE CHASES, TUNNELS AND AS REQUIRED BY PROCESS, MECHANICAL, AND ELECTRICAL
- 26. ENVIRONMENTAL STRUCTURES SHALL HAVE WATERSTOPS AT CONCRETE JOINTS. WATERSTOPS SHALL BE CONTINUOUS AND LOCATED AT ALL JOINTS.
- A. WATERSTOPS SHALL BE PVC, UNLESS NOTED OTHERWISE. B. PVC WATERSTOP INTERSECTIONS SHALL BE ASSEMBLED AND BONDED IN THE FACTORY. DO NOT
- MAKE INTERSECTIONS IN THE FIELD. C. PVC WATERSTOPS SHALL BE PROPERLY SUPPORTED AND WIRED TO REINFORCING TO REMAIN STRAIGHT AND TRUE. HEAT SPLICE ALL JOINTS PER MANUFACTURER'S RECOMMENDATIONS.
- D. WATERSTOP FOR CONSTRUCTION JOINTS SHALL BE PVC SERRATED TYPE WITHOUT CENTER BULB, NOT LESS THAN 6" WIDTH AND 3/8" THICK, UNO.
- E. WATERSTOP FOR EXPANSION JOINTS SHALL BE PVC SERRATED TYPE, WITH CENTER BULB NOT LESS THAN 9" WIDTH AND 3/8" THICK, UNO.
- NON-PVC WATERSTOPS FOR NON-MOVING JOINTS SHALL BE USED IN APPROVED APPLICATIONS. G. NON-PVC WATERSTOPS SHALL BE A HYDROPHILIC RUBBER STRIP THAT IS ADHERED TO THE SMOOTH CONCRETE SURFACE. THE WATERSTOP SHALL BE LOCATED BETWEEN REINFORCING MATS OR LOCATED WHT 3", MINIMUM, OF CLEAR CONCRETE COVER. INSTALL AND UTILIZE PER MANUFACTURER'S RECOMMENDATIONS.
- 27. PROVIDE A MASS CONCRETE TEMPERATURE CONTROL PLANS. THE PROGRAM SHALL MANAGE CURING HEAT FROM HYDRATION FOR MASS CONCRETE THAT WILL MINIMIZE VOLUME AND PROVIDE ACCEPTABLE STRENGTH AND CRACK CONTROL. THE PLAN SHALL INCLUDE, BUT ARE NOT LIMITED TO, THE FOLLOWING:
- A. A COPY OF THE APPROVED MIX DESIGN AND PROPOSED MODIFICATIONS TO MIXES IF FIELD TEMPERATURES EXCEED ALLOWABLE LIMITS
- B. PROPORTIONS OF FINE AND COARSE AGGREGATES MAY BE ADJUSTED TO PRODUCE THE DESIRED WORKABILITY WITH A SOMEWHAT HIGHER PROPORTION OF FINE AGGREGATE THAN WOULD BE USED FOR NORMAL CONDITIONS.
- C. IDENTIFYING THE MASS CONCRETE ELEMENTS AND SHOWING THE LOCATIONS OF TEMPERATURE MONITORING DEVICES.
- D. CORRECTIVE ACTION, IN THE FIELD, IF THE TEMPERATURE DIFFERENTIAL EXCEEDS THE MASS PLAN PREVENTATIVE TEMPERATURE

WATERTIGHT STRUCTURES:

- WATERSTOPS SHALL BE PVC, UNLESS NOTED OTHERWISE. WATERSTOPS SHALL BE CONTINUOUS AND LOCATED AT ALL JOINTS. CONTROL JOINTS SHALL HAVE A BULB TYPE WATERSTOP. ALL PVC WATERSTOP INTERSECTIONS SHALL BE ASSEMBLED AND BONDED IN THE FACTORY. DO NOT MAKE INTERSECTIONS IN THE FIELD.
- THE ALLOWABLE LEAKAGE RATE OF STRUCTURES SHOULD NOT EXCEED 0.1% OF THE WATER VOLUME IN 24 HOURS, AFTER ABSORPTION AND STABILIZATION. VISIBLE LEAKAGE AND DAMPNESS WILL NOT BE ACCEPTABLE. THE WATERTIGHTNESS TEST SHALL BE PERFORMED FOLLOWING THE RECOMMENDATIONS GIVEN IN ACI-350.1.
- A. THE STRUCTURES SHALL BE CONSTRUCTED WITH ALL WALL OPENINGS SEALED TO PREVENT LOSS OF WATER. BACKFILL OR WATERPROOFING SHALL BE PLACED AGAINST OR APPLIED TO THE WALLS AFTER THE TIME OF TESTING SO THAT VISIBLE LEAKAGE MAY BE OBSERVED.
- B. THE TEST SHALL COMMENCE THREE (3) DAYS AFTER THE STRUCTURES ARE FILLED TO HIGH WATER ELEVATION TO ALLOW FOR STABILIZATION. CONCRETE SHALL BE AT SPECIFIED DESIGN
- C. THE TEST WILL BE CONTINUED FOR A PERIOD OF TIME SUFFICIENT TO PRODUCE AT LEAST A THREE-EIGHTHS INCH DROP IN THE WATER SURFACE BASED ON THE LEAKAGE OCCURRING AT THE MAXIMUM ALLOWABLE RATE GIVEN ABOVE. THE TEST DURATION FOR EACH STRUCTURE IS CALCULATED TO BE THE NUMBER OF DAYS WITH A WATER ELEVATION GIVEN ABOVE. TEST RESULTS TO BE CORRECTED FOR OBSERVATIONS FOR THE GAIN OF WATER DUE TO PRECIPITATION OR THE LOSS OF WATER DUE TO EVAPORATION. A PARTIALLY FILLED, CALIBRATED, TRANSPARENT, FLOATING, OPEN CONTAINER SHALL BE POSITIONED IN THE CONTAINMENT STRUCTURE. THE CONTAINER SHALL BE POSITIONED AWAY FROM THE SIDES OF THE STRUCTURE AND ANY OVERHEAD MEMBERS THAT MAY SHIELD OR SHADE THE CONTAINER. THE CONTAINER SHOULD HAVE SUFFICIENT FREEBOARD TO ACCOMMODATE THE PRECIPITATION FROM NORMAL RAINFALL AND NOT BE OVERTOPPED BY WAVES GENERATED BY THE WIND.
- D. IF THE LEAKAGE RATE AT THE END OF THE TEST PERIOD IS DETERMINED TO EXCEED THE ALLOWABLE RATE, THE STRUCTURE SHALL BE CONSIDERED TO HAVE FAILED THE TEST. ALSO, IF WATER IS OBSERVED FLOWING FROM THE STRUCTURE OR IF MOISTURE OTHER THAN FROM PRECIPITATION OR CONDENSATION CAN BE TRANSFERRED TO THE DRY HAND FROM EXTERIOR SURFACES, THE STRUCTURE WILL HAVE FAILED THE TEST.
- E. THE CONTRACTOR SHALL MAKE NECESSARY REPAIRS TO THE STRUCTURE IN ACCORDANCE WITH SECTION 033000 OF THE SPECIFICATIONS USING PROPER REPAIR MATERIALS AND PROCEDURES. THE REPAIRS MAY INCLUDE EPOXY INJECTION OR CHEMICAL INJECTION WITH A MOISTURE REACTIVE HYDROPHILIC POLYURETHANE FOAM GROUT. THE CONTRACTOR'S PROPOSED REPAIR METHODS SHALL BE SUBMITTED TO THE ENGINEER FOR REVIEW AND APPROVAL PRIOR TO ANY
- F. AFTER ACCEPTABLE REPAIRS ARE MADE, THE STRUCTURE MUST BE FILLED WITH WATER AND TESTED FOR WATERTIGHTNESS A SECOND TIME. THE STRUCTURE MUST PASS THE TEST BEFORE FINAL WORK AND ANY WATERPROOFING MAY PROCEED.
- G. THE CONTRACTOR SHALL BE RESPONSIBLE FOR ALL COSTS ASSOCIATED WITH THE REPAIRS TO MAKE THE STRUCTURE WATERTIGHT AND ACCEPTABLE TO THE ENGINEER.
- H. THE CONTRACTOR SHALL BE RESPONSIBLE FOR ALL COSTS ASSOCIATED WITH THE FILLING AND DEWATERING OF THE STRUCTURE. THE CONTRACTOR MAY OBTAIN WATER FROM THE PLANT EFFLUENT SYSTEM. THE CONTRACTOR SHALL SUPPLY ALL EQUIPMENT, HOSES, LABORS TO FILL AND DEWATER THE TANK. DEWATERING CAN BE ACCOMPLISHED BY DRAINING THE TANK THROUGH PROCESS DRAIN PIPES IF INSTALLED.

BUOYANT STRUCTURES:

- 1. WHEN EMPTY DURING CONSTRUCTION, THE STRUCTURES MAY BECOME BUOYANT. IN THE EVENT THAT THE EXCAVATIONS BECOME FLOODED, THE STRUCTURES MUST BE FILLED WITH WATER TO PREVENT FLOTATION OR THE EXCAVATION IS TO BE KEPT DEWATERED.
- 2. THE STRUCTURES ARE DESIGNED TO RESIST BUOYANCY WHEN COMPLETE AND EMPTY.

POST-TENSIONED CONCRETE:

- 1. ALL CONCRETE WORK SHALL BE IN ACCORDANCE WITH THE ACI 318 AND THE POST TENSIONED INSTITUTE'S "POST-TENSIONING MANUAL, SIXTH EDITION," OR ANY MORE STRINGENT REQUIREMENTS PRESENTED BY THE AUTHORITY HAVING JURISDICTION.
- CONTRACTOR SHALL ENGAGE A QUALIFIED PROFESSIONAL ENGINEER TO DESIGN THE POST-TENSION STRUCTURE INCLUDING THE POST-TENSION STRUCTURAL ITEMS, CAST-IN-PLACE STRUCTURAL ITEMS, STRUCTURAL PRECAST ITEMS, METAL STRUCTURAL ITEMS, AND OTHER STRUCTURAL ITEMS. THE ENGINEER SHALL DESIGN A WHOLE AND COMPLETE STRUCTURE. THE DELEGATED ENGINEER SHALL DETERMINE LATERAL AND VERTICAL LOADS BASED ON THE SITE CONDITIONS, SOIL PROPERTIES, WIND LOADING, AND SEISMIC LOADING.
- 3. CONTRACTOR SHALL ENGAGE A QUALIFIED PROFESSIONAL ENGINEER TO DESIGN THE POST-TENSION REINFORCEMENT ALONG WITH THE MILD REINFORCEMENT INCLUDING CONSTRUCTION JOINT, POUR STRIP, AND PUNCHING SHEAR REQUIREMENTS. THE DELEGATED POST-TENSION ENGINEER SHALL DETERMINE LATERAL AND VERTICAL LOADS BASED ON THE SITE CONDITIONS, SOIL PROPERTIES, WIND LOADING, AND SEISMIC LOADING.
- 4. IF PROVIDED, POST-TENSION IS AS INDICATED ON THE DRAWINGS. IT IS THE RESPONSIBILITY OF THE POST TENSION SUPPLIER TO PROVIDE POST-TENSION PLACEMENT DRAWINGS THAT COMPLY WITH
- 5. THE CONTRACTOR SHALL SUBMIT SHOP DRAWINGS AND CALCULATIONS SIGNED AND SEALED BY AN ENGINEER REGISTERED IN THE STATE WHERE THE PROJECT IS LOCATED. DRAWINGS AND CALCULATIONS SHALL BE FOR A WHOLE AND COMPLETE STRUCTURE. REFER TO OTHER SECTIONS OF THE GENERAL NOTES, AS NEEDED.
- 6. SHOP DRAWINGS SHALL INCLUDE, BUT NOT BE LIMITED TO, TENDON LAYOUTS AND PROFILES, STRESSING AND FIXED END ANCHORAGE DETAILS, STRESSING SEQUENCE, EFFECTIVE FORCE PER TENDON, OPENINGS, AND OTHER RELATED DETAILS. CALCULATIONS OF AFFECTIVE TENDON FORCES SHALL INCLUDE ALL SHORT AND LONG TERM LOSSES, AND BE SUBMITTED TO ARCHITECT/STRUCTURAL ENGINEER FOR REVIEW. PLEASE SEE SPECIFICATIONS.
- THE CONTRACTOR SHALL COORDINATE THE SHOP DRAWINGS BETWEEN THE REINFORCING STEEL FABRICATOR AND THE POST-TENSIONING FABRICATOR PRIOR TO SUBMITTING TO STRUCTURAL ENGINEER FOR REVIEW. THE CONTRACTOR SHALL BE RESPONSIBLE FOR VERIFYING ALL FIELD CONDITIONS AND DIMENSIONS.
- 8. POST-TENSION INSTALLER SHALL HAVE A FULL TIME PROJECT SUPERINTENDENT WHO HAS SUCCESSFULLY COMPLETED PTI'S LEVEL 1 FIELD FUNDAMENTALS COURSE OR EQUIVALENT VERIFIABLE EXPERIENCE AND KNOWLEDGE ACCEPTABLE TO ARCHITECT.
- 9. SPECIAL INSPECTOR PERFORMING FIELD INSPECTIONS AND MEASURING ELONGATION SHALL HAVE SUCCESSFULLY COMPLETED PTI'S LEVEL 1 FIELD FUNDAMENTALS COURSE OR EQUIVALENT VERIFIABLE EXPERIENCE AND KNOWLEDGE ACCEPTABLE TO ARCHITECT.
- 10. TENDONS SHALL BE MANUFACTURED AND DELIVERED IN SEQUENCE AND QUANTITY TO AVOID LENGTHY JOB SITE STORAGE. TENDONS SHALL BE PROTECTED FROM CORROSION AT ALL TIMES BY AN APPROVED SHEATHING AND COATING. SHEATHING SHALL HAVE TENSILE STRENGTH AND RESISTANCE SUFFICIENT TO RESIST DAMAGE AND DETERIORATION DURING TRANSPORT, STORAGE AT JOB SITE, AND INSTALLATION, AND SHALL BE CAPABLE OF PREVENTING THE PENETRATION OF CEMENT PASTE. TEARS IN SHEATHING SHALL BE REPAIRED BY A SYSTEM APPROVED BY THE ENGINEER OF RECORD. THE COATING SHALL NOT BECOME BRITTLE OR FLUID, AND SHALL BE CHEMICALLY STABLE, NON-REACTIVE, NON-CORROSIVE, AND IMPERVIOUS TO MOISTURE.
- 11. FOR CONCRETE AND NON-PRESTRESSED STEEL BARS, SEE CONCRETE AND REINFORCEMENT SECTION OF THESE NOTES.
- 12. THE SPECIAL INSPECTOR (THRESHOLD INSPECTOR) AND ARCHITECT SHALL BE NOTIFIED 48 HOURS IN ADVANCE BEFORE CONCRETE IS PLACED. CONCRETE SHALL NOT BE PLACED UNTIL PLACEMENT OF TENDONS AND NON-PRESTRESSED STEEL REINFORCEMENT HAS BEEN INSPECTED BY THE SPECIAL INSPECTOR (THRESHOLD INSPECTOR).
- 13. THE CONTRACTOR SHALL SUPERVISE ALL TENDON STRESSING OPERATIONS AND RECORD TENDON FORCES AND ELONGATIONS UNDER THE OBSERVATION OF THE SPECIAL INSPECTOR (THRESHOLD INSPECTOR).
- 14. THE MINIMUM CONCRETE COVER SHALL FOLLOW THE REQUIREMENTS OF ACI 318, UNLESS NOTED OTHERWISE.
- 15. THE CONTRACTOR SHALL TAKE MEASURES TO ENSURE COMPLETE CONSOLIDATION AND DENSIFICATION OF CONCRETE, PARTICULARLY BEHIND ALL POST-TENSIONING ANCHOR POINTS.
- 16. CONTRACTOR SHALL NOT CUT STRAND TAILS OR COVER ANCHORAGES UNTIL STRESSING RECORDS HAVE BEEN REVIEWED AND APPROVED BY ARCHITECT.

PRECAST CONCRETE:

- 1. ALL PRECAST MEMBERS SHALL BE DESIGNED AND FABRICATED IN ACCORDANCE WITH ACI 318. "BUILDING CODE REQUIREMENTS FOR STRUCTURAL CONCRETE;" ACI 301, "SPECIFICATIONS FOR STRUCTURAL CONCRETE;" PCI 116-13, "MANUAL FOR QUALITY CONTROL FOR PLANTS AND PRODUCTION OF PRECAST PRESTRESSED PRODUCTS;" AND PCI 135-00, "TOLERANCE MANUAL FOR PRECAST AND PRESTRESSED CONCRETE CONSTRUCTION;" AND "THE PCI DESIGN HANDBOOK."
- 2. THE MANUFACTURER OF THE PRECAST CONCRETE MEMBERS SHALL BE CERTIFIED BY THE "PRECAST CONCRETE INSTITUTE" (PCI) BY THE BID DATE. THE CERTIFICATION GROUP SHALL BE GROUP "C" FOR STRUCTURAL MEMBERS.
- 3. PRECAST CONCRETE MEMBERS SHALL CONFORM TO THE APPLICABLE "CONCRETE AND REINFORCEMENT" NOTES.
- 4. THE FIELD ERECTION CREW FOR PRECAST MEMBERS SHALL BE QUALIFIED BY PCI'S CERTIFICATE OF COMPLIANCE TO ERECT CATEGORY S1- SIMPLE STRUCTURAL SYSTEMS.
- 5. CONTRACTOR SHALL ENGAGE A QUALIFIED PROFESSIONAL ENGINEER TO DESIGN THE PRECAST STRUCTURE INCLUDING THE PRECAST STRUCTURAL ITEMS, CAST-IN-PLACE STRUCTURAL ITEMS, METAL STRUCTURAL ITEMS, AND OTHER STRUCTURAL ITEMS. THE ENGINEER SHALL DESIGN A WHOLE AND COMPLETE STRUCTURE. THE DELEGATED ENGINEER SHALL DETERMINE LATERAL AND VERTICAL LOADS BASED ON THE SITE CONDITIONS, SOIL PROPERTIES, WIND LOADING, AND SEISMIC LOADING.
- 6. THE CONTRACTOR SHALL SUBMIT SHOP DRAWINGS AND CALCULATIONS SIGNED AND SEALED BY AN ENGINEER REGISTERED IN THE STATE WHERE THE PROJECT IS LOCATED. DRAWINGS AND CALCULATIONS SHALL BE FOR A WHOLE AND COMPLETE STRUCTURE. REFER TO OTHER SECTIONS OF THE GENERAL NOTES, AS NEEDED.
- 7. PRECAST MANUFACTURER SHALL SUBMIT SHOP DRAWINGS WITH DESIGN CALCULATIONS SIGNED AND SEALED BY A REGISTERED ENGINEER IN THE STATE OF THE PROJECT FOR REVIEW PRIOR TO MANUFACTURING. SHOP DRAWINGS SHALL BE PREPARED IN ACCORDANCE WITH THE PCI "DRAFTING HANDBOOK - PRECAST AND PRESTRESSED CONCRETE, SECOND EDITION, MNL-119-90."
- 8. SHOP DRAWINGS SHALL BE COORDINATED BY THE CONTRACTOR WITH ARCHITECTURAL MECHANICAL, PLUMBING AND OTHER DRAWINGS AS REQUIRED FOR EQUIPMENT WEIGHTS, PADS, OPENINGS, CONSTRUCTION JOINTS AND OTHER DETAILS PRIOR TO SUBMITTAL TO THE ARCHITECT/ENGINEER FOR REVIEW.
- 9. PRECAST CONCRETE MEMBERS SHALL BE DESIGNED AND CONSTRUCTED UTILIZING THE FOLLOWING MATERIALS, UNLESS NOTED OTHERWISE: A. CONCRETE:
 - COMPRESSIVE STRENGTH AT 28 DAYS: 5,000 PSI
 - COMPRESSIVE STRENGTH AT RELEASE: 3.500 PSI TILT-UP WALL PANELS: 3,000 PSI AT LIFTING 5,000 PSI AT 28 DAYS
- B. REINFORCING STEEL
- DEFORMED BARS:
- ASTM A615, GRADE 60 ASTM A706, GRADE 60 FOR REINFORCING TO BE WELDED ASTM A996, GRADE 60 FOR RAIL/AXLE STEEL
- TENDONS: ASTM A416, GRADE 250
- 10. PRECAST MANUFACTURER SHALL PROVIDE 3/4 INCH MINIMUM COVER FOR ALL REINFORCING STEEL.
- 11. PRECAST MANUFACTURER SHALL PROVIDE CAST-IN-PLACE ANCHORS, INSERTS, ETC., WITH SUFFICIENT ANCHORAGE AND EMBEDMENT FOR THE SPECIFIED DESIGN REQUIREMENTS. AIR RELIEF HOLES SHALL BE PROVIDED IN THE HORIZONTAL SURFACES OF ALL CAST-IN PLATES AND ANGLES OVER 3" IN WIDTH WHEN SUCH SURFACES ARE ABOVE THE BOTTOM OF THE PRECAST MEMBER IN THE CASTING POSITION.

- 10. ELASTOMERIC MATERIALS OF A STRUCTURAL (NON-COMMERCIAL) GRADE CONFORMING TO THE REQUIREMENTS OF SECTION 18, DIVISION 2, OF THE AASHTO STANDARD SPECIFICATIONS FOR HIGHWAY BRIDGES 17TH EDITION HAVING A MINIMUM DUROMETER HARDNESS OF 70 SHOULD BE USED UNDER BEARING SURFACES OF PRECAST FLOOR AND ROOF PLANKS. ALL MATERIAL SHALL BE NEW WITH NO RECLAIMED MATERIAL INCORPORATED IN THE FINISHED BEARING PAD.
- 11. PRECAST INSTALLER SHALL SET UNITS LEVEL AND SQUARE, KEEPING UNITS TIGHT AND IN PROPER ALIGNMENT WITH SUPPORTS. MAXIMUM DIFFERENTIAL CAMBER BETWEEN ADJACENT ELEMENTS SHALL NOT EXCEED 1/4" PER 10'-0" OF LENGTH BUT NOT GREATER THAN 3/4". CONTRACTOR SHALL TAKE ALL MEASURES NECESSARY TO CONFORM TO THESE TOLERANCES INCLUDING, BUT NOT LIMITED TO THE ADJUSTMENT OF BEARING HEIGHTS.
- 12. PRECAST CONCRETE SLABS AND TEES SHALL HAVE A MINIMUM BEARING SURFACE OF 3" ON ALL SUPPORTING ELEMENTS, UNLESS NOTED OTHERWISE.
- 13. PRECAST INSTALLER SHALL WELD MEMBERS TO SUPPORTS, AS SHOWN ON THE DRAWINGS. ALL WELDS SHALL BE PERFORMED IN ACCORDANCE WITH AWS D1.1.
- 14. PRECAST MANUFACTURER SHALL PROVIDE STANDARD SHEAR CONNECTORS IN THE FLANGES OF PRECAST TEES AS SHOWN ON DETAILS. FIELD WELD AS INDICATED IN ACCORDANCE WITH AWS D1.1
- 15. REINFORCING STEEL THAT MAY BE SHOWN IN DETAILS IS FOR IN-PLACE CONDITION. ALL INSERTS, BRACES, STRONGBACKS AND OTHER REQUIRED ACCESSORIES SHALL BE FURNISHED AND INSTALLED BY THE CONTRACTOR, AND SHALL BE LOCATED IN ACCORDANCE WITH THE RECOMMENDATIONS OF RICHMOND BULLETIN NO. 8, "PRODUCTS FOR PRECAST/PRESTRESSED CONCRETE CONSTRUCTION." THE CONTRACTOR IS ALSO RESPONSIBLE FOR PROVIDING SPECIAL REINFORCING ELEMENTS THAT MAY BE REQUIRED TO PREVENT FLEXURAL CRACKS FROM OCCURRING IN THE PANELS DURING LIFTING AND HANDLING OPERATIONS.
- 16. THE CONTRACTOR SHALL GROUT PRECAST MEMBERS AS OUTLINED BELOW: A. BETWEEN SLAB EDGES: FILL GROUT KEYS FULL AND STRIKE OFF FLUSH WITH TOP SURFACE. REMOVE ANY GROUT WHICH SEEPS THROUGH TO UNDERSIDE OF UNITS BEFORE IT HARDENS. CLEAN EXCESS FROM FACES AND FLOORS BELOW.
- B. AT SLAB ENDS: WHERE END GROUTING IS SHOWN ON THE DRAWINGS, PROVIDE SUITABLE END CAP OR DAM IN VOIDS.

17. PRECAST MANUFACTURER/DESIGNER AND CONTRACTOR SHALL COORDINATE WITH OTHER TRADES

18. PRECAST MANUFACTURER AND GENERAL TRADES CONTRACTOR SHALL COORDINATE SIZE AND LOCATION OF ALL HOLES AND OPENINGS REQUIRED THROUGH THE HOLLOW CORE SLABS WITH THE

IN PERMITTING THE INSERTION OF ANCHORS, HANGERS, ELECTRICAL OUTLETS, ETC.

- 19. NOT ALL HOLES AND OPENINGS ARE SHOWN ON THE STRUCTURAL DRAWINGS. THOSE WHICH ARE SHOWN SHALL BE CAST-IN OR CUT-IN BY THE MANUFACTURER. ALL OPENINGS LARGER THAN ONE SLAB WIDTH ARE TO BE FRAMED WITH CONCRETE OR STRUCTURAL STEEL HEADERS, DESIGNED AND PROVIDED BY THE MANUFACTURER. ADJACENT UNITS SHALL BE DESIGNED TO SUPPORT THE ADDITIONAL LOAD.
- 20. OPENINGS NOT SHOWN ON THE STRUCTURAL DRAWINGS SHALL BE FIELD CUT BY THE GENERAL TRADES CONTRACTOR AT THE EXPENSE OF THE TRADE REQUIRING THE OPENING. THE MANUFACTURER, HOWEVER, IS RESPONSIBLE FOR DESIGNING THE AFFECTED HOLLOW CORE PLANKS TO ACCOMMODATE THESE OPENINGS BY PROVIDING NECESSARY ADDITIONAL REINFORCING IN UNIT WITH OPENING AND IN ADJACENT UNITS. FIELD CUT HOLES MAY BE DRILLED OR CUT AND TRIMMED WITH A CHISEL. CUT OUTLINE OF HOLE THROUGH LOWER PORTION OF SLAB FROM UNDERSIDE, AFTER WHICH THE TOPSIDE MAY BE REMOVED FROM ABOVE. DO NOT CUT PRESTRESSING STRANDS WITHOUT APPROVAL OF THE MANUFACTURER AND THE ARCHITECT.

STRUCTURAL STEEL:

TRADES REQUIRING THE OPENINGS.

- . STEEL SHALL BE FABRICATED BY A FABRICATOR HAVING AN AISC QUALITY CERTIFICATION CATEGORY: "STANDARD FOR STEEL BUILDING STRUCTURES (STD)."
- STRUCTURAL STEEL WORK SHALL CONFORM TO THE "STEEL CONSTRUCTION MANUAL, AISC 360."
- 3. THE CONTRACTOR SHALL BE RESPONSIBLE FOR THE DESIGN OF MEMBERS AND CONNECTIONS FOR ANY PORTION OF THE STRUCTURE NOT INDICATED ON THE PLANS. ALL SPECIAL CONDITIONS AND CONNECTIONS SHALL BE CAREFULLY AND COMPLETELY DETAILED AND SUBMITTED FOR APPROVAL.
- 4. CONTRACTOR SHALL VERIFY THE EXACT LOCATION AND SIZE OF ALL OPENINGS FOR MECHANICAL EQUIPMENT WITH THE MECHANICAL CONTRACTOR PRIOR TO FABRICATION OF MATERIALS.
- 5. ANY STEEL SHOWN ON DRAWINGS FOR SUPPORTING OR CONNECTING MECHANICAL, ELECTRICAL. OR PLUMBING EQUIPMENT IS FOR BID PURPOSES ONLY. CONTRACTOR SHALL COORDINATE EXACT SIZE AND LOCATION PRIOR TO PROCEEDING WITH CONSTRUCTION.
- 6. UNLESS SHOWN ON STRUCTURAL DRAWINGS, CONTRACTOR SHALL NOT CUT ANY HOLES IN
- MILL TOLERANCE) LOCATED ABOVE THE HORIZONTAL CENTERLINE BETWEEN THE END

7. ALL STEEL BEAMS SHALL BE FABRICATED AND ERECTED WITH THE NATURAL CAMBER (WITHIN THE

- 8. THE STEEL FRAME AS DESIGNED IS A NON-SELF SUPPORTING STEEL FRAME. CONTRACTOR SHALL COORDINATE THE ERECTION WITH THE INSTALLATION OF OTHER BUILDING ELEMENTS REQUIRED FOR THE STRUCTURES STABILITY. THESE ELEMENTS INCLUDE, BUT ARE NOT LIMITED TO, SLABS, METAL DECK, MASONRY WALLS, AND CONCRETE WALLS.
- 9. STEEL SHALL CONFORM TO THE FOLLOWING UNLESS OTHERWISE NOTED:
- A. W-SHAPES: ASTM A992
- B. ANGLES, PLATES, RODS, ETC: ASTM A36 . CHANNELS: ASTM A36 (A572, GRADE 50)
- D. PIPES: ASTM A53, GRADE B E. STRUCTURAL TUBING:
- ROUND ASTM A500, GRADE B, 42 KSI SQUARE & RECTANGULAR, ASTM A500, GRADE B, 46 KSI
- ANCHOR RODS: ASTM F1554, GRADE 36 G. SHEAR STUD CONNECTORS: ASTM A108
- 10. WELDED CONNECTIONS SHALL CONFORM TO THE REQUIREMENTS OF THE AMERICAN WELDING SOCIETY, AWS D1.1. WELDING ELECTRODE MATERIAL SHALL BE E70XX.
- 11. WELDING OF SHEAR STUD CONNECTORS SHALL CONFORM TO AWS D1.1 SECTION 7.
- 12. ALL WELDED CONNECTIONS SHALL BE DESIGNED TO BE FULLY EQUIVALENT IN STRENGTH TO BOLTED CONNECTIONS FOR THE SAME SIZE BEAM.
- 13. MINIMUM WELDS, WHERE NOT SHOWN ON DRAWINGS, SHALL BE 3/16 INCH FILLET WELD, ALL
- 14. IN GENERAL, IT IS THE INTENT OF THESE PLANS AND SPECIFICATIONS THAT ALL SHOP CONNECTIONS BE WELDED OR BOLTED AND ALL FIELD CONNECTIONS BE BOLTED EXCEPT WHERE NOTED
- 15. ALL CONNECTIONS SHALL BE MADE WITH 3/4-INCH ASTM A325 BOLTS TIGHTENED TO SNUG-TIGHT CONDITION UNLESS OTHERWISE NOTED.
- 16. ALL CONNECTIONS NOT DETAILED ON THE DRAWINGS SHALL BE DESIGNED AND DETAILED BY THE FABRICATOR UTILIZING THE REQUIREMENTS IN AISC 360. AND THE CONTRACT DOCUMENTS. THE FABRICATOR SHALL USE LOAD AND RESISTANCE FACTOR DESIGN, ALLOWABLE STRESS DESIGN METHODOLOGY TO COMPLETE ALL CONNECTION DESIGNS INCLUDING THE FOLLOWING GUIDELINES. A. DETAIL ALL BOLTED CONNECTIONS AS BEARING TYPE CONNECTIONS WITH THREADS IN THE SHEAR PLANE, EXCEPT THE FOLLOWING CONNECTIONS, WHICH SHALL BE DESIGNED AS SLIP-
 - CRITICAL CONNECTIONS: ALL CONNECTIONS IN DIRECT TENSION.
 - THE WEB SHEAR CONNECTION OF ALL MOMENT CONNECTIONS. ALL BEAM OR GIRDER CONNECTIONS USING OVERSIZED HOLES OR LONG SLOTS
- ANY CONNECTION NOTED ON THE CONTRACT DRAWINGS AS SLIP-CRITICAL CONNECTION. B. NON-COMPOSITE BEAM CONNECTIONS SHALL BE DESIGNED TO DEVELOP 55% OF THE LOAD CAPACITY OF THE MEMBER AS TABULATED IN BEAM TABLE 3-6, PART 3, OF THE AISC "MANUAL OF
- STEEL CONSTRUCTION", UNLESS THE REACTION IS SHOWN ON THE DRAWINGS. C. COMPOSITE BEAM CONNECTIONS SHALL BE DESIGNED TO DEVELOP 75% OF THE LOAD CAPACITY OF THE MEMBER AS TABULATED IN THE BEAM TABLES, BUT NOT LESS THAN THE STANDARD "V/n" VALUE (MAXIMUM END REACTION FOR 3-1/2" BEARING AS SHOWN IN BEAM TABLE 3-6, PART 3, OF THE AISC "MANUAL OF STEEL CONSTRUCTION", UNLESS THE REACTION IS SHOWN ON THE DRAWINGS.


- 17. IN NO CASE SHALL THE MINIMUM NUMBER OF ROWS OF BOLTS FOR THE GIVEN BEAM SIZE BE LESS THAN THAT WHICH IS SHOWN IN TABLE 10-1, PART 10, OF THE AISC "MANUAL OF STEEL
- 18. ALL SHELF ANGLES AND LINTELS IN EXTERIOR WALLS, INCLUDING BEARING PLATES AND ANCHOR RODS, SHALL BE GALVANIZED AFTER FABRICATION.
- 19. ALL STEEL AND CORRESPONDING CONNECTIONS EXPOSED TO WEATHER SHALL BE HOT-DIP GALVANIZED IN ACCORDANCE WITH ASTM A123 AND A153, RESPECTIVELY.
- 20. ALL STEEL, AND ANCHOR RODS THAT WILL BE GALVANIZED, ENCASED IN CONCRETE, OR RECEIVE SPRAYED ON FIREPROOFING SHALL NOT BE PAINTED.
- 21. PROVIDE 3/8-INCH DIAMETER WEEP HOLES AT BASE OF HSS AND PIPE COLUMNS AND IN BOTTOM OF CAPPED HSS BEAMS.
- 22. PROVIDE 1/4" MIN CLOSURE PLATES TO ALL HOLLOW STRUCTURAL SECTIONS WITH A 1/4" FILLET
- WELD ALL AROUND. 23. SET COLUMN BASE PLATES UPON NON-METALLIC, SHRINK RESISTANT GROUT CONFORMING TO ASTM
- 24. PROVIDE HARDENED STEEL WASHERS CONFORMING TO ASTM F436 AND HEAVY HEX NUTS ON ANCHOR RODS.
- 25. STEEL THAT EXTENDS BELOW GRADE SHALL BE ENCASED IN CONCRETE WITH A MINIMUM OF 3-INCHES OF CLEAR COVER.
- 26. CONNECTIONS FOR BRACING SHALL DEVELOP THE TENSILE CAPACITY OF THE BRACING MEMBER.

27. ALL STEEL COLUMNS AND BEAMS ARE TO RECEIVE SPRAYED FIREPROOFING TO ACHIEVE THE RESTRAINED FIRE RESISTANCE RATING AS SPECIFIED IN THE ARCHITECTURAL DRAWINGS.

- 1. ALUMINUM MEMBERS SHALL BE FABRICATED, TRANSPORTED, AND ERECTED PER THE ALUMINUM DESIGN MANUAL BY THE ALUMINUM ASSOCIATION, INC.
- ALUMINUM MEMBERS SHALL BE CUT BY SHEARING, SAWING, NIBBLING, ROUTING, ARC CUTTING, LASER OR ABRASIVE WATER JET. OXYGEN CUT SHALL BE PROHIBITED.
- 3. CONTRACTOR SHALL NOT WELD ALUMINUM MEMBERS WITHOUT WRITTEN PERMISSION FROM THE STRUCTURAL ENGINEER OF RECORD.
- ALUMINUM MEMBERS SHALL CONFORM TO THE FOLLOWING UNLESS OTHERWISE NOTED:
- A. PLATES: ALUMINUM ALLOY 6061-T6, ASTM B209 MINIMUM TENSILE STRESS = 42 KSI
- MINIMUM YIELD STRESS = 35 KSI B. TUBING: ALUMINUM ALLOY 6061-T6, ASTM B308
- MINIMUM TENSILE STRESS = 42 KSI MINIMUM YIELD STRESS = 35 KSI C. SOLID BAR: ALUMINUM ALLOY 6061-T651, ASTM B211
- MINIMUM TENSILE STRESS = 38 KSI MINIMUM YIELD STRESS = 35 KSI
- D. BOLTS: ALUMINUM ALLOY 2024-T4, ASTM F468 OR STAINLESS STEEL, ASTM F593
- 5. WHERE ALUMINUM IS IN CONTACT WITH OR FASTENED TO STEEL, WOOD, FIBERBOARD, CONCRETE OR MASONRY, A COMPATIBLE, NONPOROUS ISOLATOR BETWEEN THE ALUMINUM AND OTHER MATERIAL SHALL BE SUPPLIED.
- 6. A COMPATIBLE, NONPOROUS ISOLATER SHALL CONSIST OF EITHER A HEAVY COATING OF ALKALI RESISTANT BITUMINOUS PAINT OR AN APPROVED ALTERNATIVE METHOD.
- 7. ALUMINIZED, HOT-DIP GALVANIZED OR ELECTRO-GALVANIZED STEEL IN CONTACT WITH ALUMINUM NEED NOT BE PAINTED.
- ALL BOLTS SHALL BE INSTALLED TO A SNUG-TIGHT CONDITION, UNLESS NOTED OTHERWISE. ALL BOLTS SHALL BE PROVIDED WITH LOCK WASHERS, PALNUTS, OR LOCK NUTS.

POST-INSTALLED FASTENERS:

- 1. POST-INSTALLED ANCHORS SHALL BE USED ONLY WHERE SPECIFIED ON THE STRUCTURAL
- 2. ACI/CRSI ADHESIVE ANCHOR INSTALLER CERTIFICATION IS REQUIRED FOR ALL INSTALLERS OF ADHESIVE ANCHORS IN HORIZONTAL OR UPWARDLY INCLINED ORIENTATION. THIS CERTIFICATION CAN BE OBTAINED THROUGH ACI OR APPROVED EQUIVALENT.
- 3. FASTENERS SHALL BE INSTALLED IN ACCORDANCE WITH THE MANUFACTURER'S PRINTED INSTALLATION INSTRUCTIONS, AS INCLUDED IN THE ANCHOR PACKAGING IN COORDINATION WITH INFORMATION HEREIN. THE STRUCTURAL ENGINEER SHALL BE NOTIFIED IF CONFLICTS EXIST BETWEEN THE MANUFACTURER'S PRINTED INSTALLATION INSTRUCTIONS AND THE REQUIREMENTS
- 4. REINFORCEMENT STEEL SHALL NOT BE CUT. PRIOR TO DRILLING THE CONCRETE, THE REINFORCING SHALL BE LOCATED WITH A MAGNETIC BAR LOCATOR. POST-INSTALLED BOLTS AND FASTENERS SHALL BE INSTALLED TO MISS REINFORCEMENT STEEL IN CONCRETE. EXISTING REINFORCING BARS IN THE CONCRETE STRUCTURE MAY CONFLICT WITH SPECIFIC ANCHOR LOCATIONS.
- 5. DRILL HOLES USING ROTARY PERCUSSION DRILL WITH A DEPTH GAGE. DO NOT DRILL THROUGH FULL THICKNESS OF CONCRETE. USE OF A DIAMOND CORE BIT WITH ROUGHENING TOOL FOR ANCHOR HOLES MUST BE APPROVED BY THE STRUCTURAL ENGINEER OF RECORD PRIOR TO DRILLING. UNLESS OTHERWISE SHOWN IN THE DRAWINGS. ALL HOLES SHALL BE DRILLED PERPENDICULAR TO THE CONCRETE SURFACE. CLEAN HOLES IN ACCORDANCE WITH THE MANUFACTURER'S PRINTED INSTALLATION INSTRUCTIONS. IF CONCRETE IS DAMP, BLOW DRY HOLE WITH OIL-FREE COMPRESSED AIR. CLEAN HOLE WITH WATER ONLY IF RECOMMENDED BY MANUFACTURER. ADHESIVE ANCHORS MAY NOT BE SET IF WATER IS SEEPING INTO HOLE AND THE STRUCTURAL ENGINEER. OF RECORD SHALL BE NOTIFIED.
- 6. ANCHOR SUBSTITUTION REQUESTS FOR ALTERNATE PRODUCTS MUST BE SUBMITTED AND APPROVED IN WRITING BY THE STRUCTURAL ENGINEER OF RECORD PRIOR TO USE. CONTRACTOR SHALL PROVIDE DOCUMENTATION DEMONSTRATING THAT THE SUBSTITUTED PRODUCT IS CAPABLE OF MEETING THE PERFORMANCE OF THE SPECIFIED PRODUCT. SUBSTITUTIONS WILL BE EVALUATED BY THEIR HAVING AN ICC ESR SHOWING COMPLIANCE WITH THE RELEVANT BUILDING CODE FOR ITS USE, LOAD RESISTANCE, INSTALLATION CATEGORY, AND AVAILABILITY OF COMPREHENSIVE INSTALLATION INSTRUCTIONS. ADHESIVE ANCHOR EVALUATION WILL ALSO CONSIDER CREEP, IN-SERVICE TEMPERATURE, INSTALLATION TEMPERATURE, MOISTURE CONDITION OF CONCRETE, AND DRILLING METHODS.
- 7. THE CONTRACTOR SHALL ARRANGE AN ANCHOR MANUFACTURER'S REPRESENTATIVE TO PROVIDE ONSITE INSTALLATION TRAINING FOR ALL ANCHOR PRODUCTS SPECIFIED. THE STRUCTURAL ENGINEER OF RECORD MUST RECEIVE DOCUMENTED CONFIRMATION THAT ALL PERSONNEL WHO INSTALL ANCHORS ARE TRAINED PRIOR TO THE COMMENCEMENT OF ANCHOR INSTALLATION.
- 8. ANCHOR CAPACITY IS DEPENDENT UPON SPACING BETWEEN ADJACENT ANCHORS AND PROXIMITY OF ANCHORS TO EDGE OF CONCRETE. INSTALL ANCHORS IN ACCORDANCE WITH SPACING AND EDGE CLEARANCES INDICATED ON THE DRAWINGS. CONTRACTOR SHALL CONTACT STRUCTURAL ENGINEER SHOULD THE LAYOUT OF THE ANCHOR, EMBEDMENT, SPACING OR EDGE DISTANCES, IS MODIFIED.

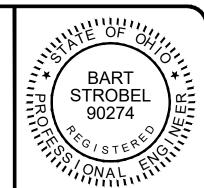

 \mathbf{m}

PROJECT NO. 230264 DISCIPLINE

STRUCTURAL

SHEET NAME

20-S-02

H:\2023\230264\DWG\SHEETS\PHASE II\SD 230264 - STRUCTURAL PHASE II.DWG - 22 GENERAL NOTES - 9/30/2025 2:20:31 PM - CORY SCOTT

- 9. EXCEPT WHERE INDICATED ON THE DRAWINGS, POST-INSTALLED ANCHORS SHALL CONSIST OF THE FOLLOWING ANCHOR TYPES:
- A. ANCHORAGE TO CONCRETE:
- ADHESIVE ANCHORS:
- HILTI HIT-HY 200 SAFE SET SYSTEM WITH HILTI HIT-Z ROD
- 2. HILTI HIT-HY 200 SAFE SET SYSTEM INSTALLED USING HILTI HOLLOW DRILL BIT AND VACUUM WITH HAS-V-36 GRADE 36 THREADED ROD
- HILTI HIT-RE 500v3 SAFE SET SYSTEM INSTALLED USING HILTI HOLLOW DRILL BIT AND VACUUM WITH HAS THREADED ROD
- SIMPSON SET-XP WITH ASTM A36 THREADED ROD
- SIMPSON SET-XP INSTALLED USING SIMPSON SPEED CLEAN DXS SYSTEM WITH ASTM A36 THREADED ROD
- APPROVED EQUAL
- MECHANICAL ANCHORS:
- 1. HILTI KWIK HUS-EZ (KH-EZ), KH-EZ CRC, KH-EZ SS316, KH-EZ C, KH-EZ E, KH-EZ I, AND KH-EZ P SCREW ANCHOR SAFE SET SYSTEM INSTALLED USING HOLLOW DRILL BIT AND VACUUM
- HILTI KWIK BOLT-1 EXPANSION ANCHOR HILTI KWIK BOLT-TZ2 EXPANSION ANCHOR
- 4. SIMPSON TITEN HD SCREW ANCHOR
- 5. SIMPSON STRONG-BOLT 2 WEDGE ANCHOR APPROVED EQUAL
- REBAR DOWELING INTO CONCRETE:
- 1. HILTI HIT-HY 200 SAFE SET SYSTEM INSTALLED USING HILTI HOLLOW DRILL BIT AND VACUUM WITH CONTINUOUSLY DEFORMED REBAR
- HILTI HIT-HY 500v3 SAFE SET SYSTEM INSTALLED USING HILTI HOLLOW DRILL BIT AND
- VACUUM WITH CONTINUOUSLY DEFORMED REBAR
- SIMPSON SET-XP WITH CONTINUOUSLY DEFORMED REBAR SIMPSON SET-XP INSTALLED USING SIMPSON SPEED CLEAN DXS SYSTEM WITH
- CONTINUOUSLY DEFORMED REBAR APPROVED EQUAL
- B. ANCHORAGE TO SOLID GROUTED MASONRY: ADHESIVE ANCHORS:
 - 1. HILTI HIT-HY 270 SAFE SET SYSTEM INSTALLED USING HILTI HOLLOW DRILL BIT AND VACUUM WITH HILTI HAS CONTINUOUSLY THREADEDED ROD OR DEFORMED REBAR.
 - SIMPSON SET-XP WITH ASTM A36 THREADED ROD OR CONTINUOUSLY DEFORMED REBAR SIMPSON SET-XP INSTALLED USING SIMPSON SPEED CLEAN DXS SYSTEM WITH ASTM A36 THREADED ROD OR CONTINUOUSLY DEFORMED REBAR
- APPROVED EQUAL
- MECHANICAL ANCHORS USE:
- HILTI KWIK BOLT-1 EXPANSION ANCHOR HILTI KWIK BOLT-TZ2 EXPANSION ANCHOR
- HILTI KH-EZ, KH-EZ CRC, KH-EZ SS316, KH-EZ C, AND KH-EZ P SCREW ANCHORS
- 4. SIMPSON STRONG-BOLT 2 WEDGE ANCHOR SIMPSON WEDGE-ALL WEDGE ANCHOR
- 6. APPROVED EQUAL
- C. ANCHORAGE TO HOLLOW / MULTI-WYTHE MASONRY: ADHESIVE ANCHORS USE:
- 1. HILTI HIT-HY 270 SAFE SET SYSTEM INSTALLED USING THE APPROPRIATE SIZE SCREEN TUBE PER THE ADHESIVE MANUFACTURER'S PRINTED INSTALLATION INSTRUCTIONS AND A HILTI HOLLOW DRILL BIT AND VACUUM WITH HILTI HAS CONTINUOUSLY THREADEDED
 - ROD OR DEFORMED REBAR. SIMPSON SET-XP THE APPROPRIATE SIZE SCREEN TUBE PER THE ADHESIVE MANUFACTURER'S PRINTED INSTALLATION INSTRUCTIONS WITH ASTM A36 THREADED
- 2. SIMPSON SET-XP INSTALLED USING SIMPSON SPEED CLEAN DXS SYSTEM WITH ASTM A36
- THREADED ROD APPROVED EQUAL

PER THE IBC SECTION 1705, SPECIAL INSPECTIONS ARE REQUIRED FOR THE FOLLOWING ITEMS:

- 1. DUTIES AND RESPONSIBILITIES OF THE SPECIAL INSPECTOR:
- A. THE SPECIAL INSPECTOR SHALL OBSERVE THE WORK DESIGNATED TO ASSURE IT IS CONSTRUCTED IN CONFORMANCE TO THE APPROVED CONSTRUCTION DOCUMENTS.
- B. THE SPECIAL INSPECTOR SHALL SUBMIT INSPECTION REPORTS AND TESTS TO THE BUILDING OFFICIAL AND REGISTERED DESIGN PROFESSIONAL IN RESPONSIBLE CHARGE
- C. DISCREPANCIES SHALL BE BROUGHT TO THE IMMEDIATE ATTENTION OF THE CONTRACTOR FOR CORRECTION. IF THE DISCREPANCIES ARE NOT CORRECTED. THE DISCREPANCIES SHALL BE BROUGHT TO THE ATTENTION OF THE BUILDING OFFICIAL AND THE REGISTERED DESIGN PROFESSIONAL IN RESPONSIBLE CHARGE PRIOR TO THE COMPLETION OF THAT PHASE OF THE
- D. A FINAL REPORT DOCUMENTING REQUIRED SPECIAL INSPECTIONS AND TESTS, AND CORRECTION OF ANY DISCREPANCIES NOTED IN THE INSPECTIONS OR TESTS, SHALL BE SUBMITTED WITHIN THE AGREED UPON TIME TO THE BUILDING OFFICIAL PRIOR TO THE START ISSUANCE OF A
- CERTIFICATE OF OCCUPANCY. PRIOR TO START OF CONSTRUCTION. THE CONTRACTOR SHALL SUBMIT A STATEMENT OF RESPONSIBILITY ACKNOWLEDGING THE AWARENESS OF THE SPECIAL INSPECTION REQUIREMENTS CONTAINED IN THE STATEMENT OF SPECIAL INSPECTIONS.
- STRUCTURAL STEEL:
- A. PRIOR TO WELDING:
- WELDER QUALIFICATION RECORDS AND CONTINUITY RECORDS. (PERIODIC) WELDING PROCEDURE SPECIFICATION (WPS) AVAILABLE. (CONTINUOUS)
- MANUFACTURER CERTIFICATIONS FOR WELDING CONSUMABLES AVAILABLE. (CONTINUOUS)
- MATERIAL IDENTIFICATION –TYPE/GRADE (PERIODIC) WELDER IDENTIFICATION SYSTEM MAINTAÎNED BY FÁBRICATOR OR ERECTOR TO IDENTIFY
- WHICH WELDER HAS WELDED A JOINT OR MEMBER. (PERIODIC) FIT UP OF GROOVE WELDS INCLUDING JOINT GEOMETRY (PERIODIC)
- A. JOINT PREPARATIONS B. DIMENSIONS (ALIGNMENT, ROOT OPENING, ROOT FACE, BEVEL)
- CLEANLINESS (CONDITION OF STEEL SURFACES)
- D. TACKING (TACK WELD QUALITY AND LOCATION) BACKING TYPE AND FIT, IF APPLICABLE.
- FIT UP OF COMPLETE JOINT PENETRATION WELDS OF HSS T-, Y- AND K- JOINTS WITHOUT BACKING INCLUDING JOINT GEOMETRY (PERIODIC)
- A. JOINT PREPARATIONS B. DIMENSIONS (ALIGNMENT, ROOT OPENING, ROOT FACE, BEVEL)
- CLEANLINESS (CONDITION OF STEEL SURFACES) D. TACKING (TACK WELD QUALITY AND LOCATION)
- CONFIGURATION AND FINISH OF ACCESS HOLES (PERIODIC)
- FIT UP OF FILLET WELDS (PERIODIC) A. DIMENSIONS (ALIGNMENT, GAPS AT ROOT)
- CLEANLINESS (CONDITION OF STEEL SURFACES) TACKING (TACK WELD QUALITY AND LOCATION)
- CHECK WELDING EQUIPMENT
- B. DURING WELDING CONTROL AND HANDLING OF WELDING CONSUMABLES (PERIODIC)
- B. EXPOSURE CONTROL NO WELDING OVER CRACKED TACK WELDS (PERIODIC)
- ENVIRONMENTAL CONDITIONS (PERIODIC) A. WIND SPEED WITHIN LIMITS
- B. PRECIPITATION AND TEMPERATURE
- WPS FOLLOWED (PERIODIC) A. SETTINGS ON WELDING EQUIPMENT
- B. TRAVEL SPEED C. SELECTED WELDING MATERIALS
- D. SHIELDING GAS TYPE/FLOW RATE
- E. PREHEAT APPLIED INTERPASS TEMPERATURE MAINTAINED (MIN/MAX)
- G. PROPER POSITION (F, V, H, OH) WELDING TECHNIQUES (PERIODIC)

H:\2023\230264\DWG\SHEETS\PHASE II\SD_230264 - STRUCTURAL PHASE II.DWG - 23 GENERAL NOTES - 9/30/2025 2:20:31 PM - CORY SCOTT

- A. INTERPASS AND FINAL CLEANING B. EACH PASS WITHIN PROFILE LIMITATIONS
- EACH PASS MEETS QUALITY REQUIREMENTS
- PLACEMENT AND INSTALLATION OF STEEL HEADED STUDS. (CONTINUOUS).

- C. AFTER WELDING:
 - WELDS CLEANED (PERIODIC)
- SIZE, LENGTH AND LOCATION OF WELDS (CONTINUOUS) WELDS MEET VISUAL ACCEPTANCE CRITERIA (CONTINUOUS)
 - CRACK PROHIBITION
- WELD/BASE-METAL FUSION
- CRATER CROSS-SECTION WELD PROFILES
- WELD SIZE UNDERCUT POROSITY
- ARC STRIKES (CONTINUOUS)
- k-AREA (CONTINUOUS) WELD ACCESS HOLES IN ROLLED HEAVY SHAPES AND BUILT-UP HEAVY SHAPES
- (CONTINUOUS)
- BACKING REMOVED AND WELD TABS REMOVED, IF REQUIRED (CONTINUOUS) REPAIR ACTIVITIES (CONTINUOUS)
- DOCUMENT ACCEPTANCE OR REJECTION OF WELDED JOINT OR MEMBER (CONTINUOUS) NO PROHIBITED WELDS HAVE BEEN ADDED WITHOUT THE APPROVAL OF THE STRUCTURAL ENGINEER OF RECORD (PERIODIC) D. PRIOR TO BOLTING:
- MANUFACTURER'S CERTIFICATIONS AVAILABLE FOR FASTENER MATERIALS (CONTINUOUS)
- FASTENERS MARKED IN ACCORDANCE WITH ASTM REQUIREMENTS (PERIODIC) CORRECT FASTENER SELECTED FOR THE JOINT DETAIL INCLUDING GRADE, TYPE, BOLT
- LENGTH IF THREADS ARE TO BE EXCLUDED FROM SHEAR PLANE (PERIODIC)
- CORRECT BOLTING PROCEDURE SELECTED FOR JOINT DETAIL (PERIODIC) CONNECTING ELEMENTS, INCLUDING THE APPROPRIATE FAYING SURFACE CONDITION AND
- HOLE PREPARATION, IF SPECIFIED, MEET APPLICABLE REQUIREMENTS (PERIODIC) PRE-INSTALLATION VERIFICATION TESTING BY INSTALLATION PERSONNEL OBSERVED AND DOCUMENTED FOR FASTENER ASSEMBLIES AND METHODS USED. (PERIODIC) PRTOECTED STORAGE PROVIDED FOR BOLTS, NUTS, WASHERS AND OTHER FASTENER
- COMPONENTS (PERIODIC) E. DURING BOLTING: FASTENER ASSEMBLIES PLACED IN ALL HOLES AND WASHERS AND NUTS ARE POSITIONED AS
- REQUIRED. (PERIODIC) JOINT BROUGHT TO THE SNUG-TIGHT CONDITION PRIOR TO THE PRE-TENSIONING OPERATION (PERIODIC)
- FASTENER COMPONENT NOT TURNED BY THE WRENCH PREVENTED FROM ROTATING. (PERIODIC)
- FASTENERS ARE PRE-TENSIONED IN ACCORDANCE WITH THE RCSC SPECIFICATION. PROGRESSING SYSTEMATICALLY FROM THE MOST RIGID POINT TOWARD THE FREE EDGES. (PERIODIC)
- F. AFTER BOLTING DOCUMENT ACCEPTANCE OR REJECTION OF BOLTED CONNECTIONS. (CONTINUOUS) G. INSPECTION OF GALVANIZED STRUCTURAL STEEL MAIN MEMBERS AND EXPOSED CORNERS OF
- RECTANGULAR HSS FOR CRACKS SUBSEQUENT TO GALVANIZING (PERIODIC) H. SPECIAL INSPECTIONS ARE NOT REQUIRED FOR WORK DONE ON THE PREMISES OF A FABRICATOR REGISTERED AND APPROVED TO PERFORM SUCH WORK WITHOUT SPECIAL INSPECTIONS. APPROVAL SHALL BE BASED UPON REVIEW OF THE FABRICATOR'S WRITTEN
- PROCEDURAL AND QUALITY CONTROL MANUALS AND PERIODIC AUDITING OF FABRICATION PRACTICES BY A BOARD RECOGNIZED INDUSTRY TRADE ASSOCIATION CERTIFICATION PROGRAM OR A BOARD RECOGNIZED FABRICATOR INSPECTION AGENCY.
- CONCRETE: A. INSPECT REINFORCEMENT, INCLUDING PRESTRESSING TENDONS, AND VERIFY PLACEMENT.
- (PERIODIC) B. REINFORCING BAR WELDING:
- VERIFY WELDABILITY OF REINFORCING BARS OTHER THAN ASTM A706. (PERIODIC)
- INSPECT SINGLE-PASS FILLET WELDS, MAXIMUM 5/16" (PERIODIC) INSPECT ALL OTHER WELDS (CONTINUOUS)
- C. INSPECT ANCHORS CAST IN CONCRETE (PERIODIC)
- D. INSPECT ANCHORS POST-INSTALLED IN HARDENED CONCRETE MEMBERS: ADHESIVE ANCHORS INSTALLED IN HORIZONTALLY OR UPWARDLY INCLINED ORIENTATIONS
- TO RESIST SUSTAINED TENSION LOADS. (CONTINOUS) MECHANICAL ANCHORS AND ADHESIVE ANCHORS NOT DEFINED ABOVE. (PERIODIC) E. VERIFY USE OF REQUIRED MIX DESIGN. (PERIODIC)
- SLUMP AND AIR CONTENT TESTS, AND DETERMINE THE TEMPERATURE OF THE CONCRETE. (CONTINUOUS) G. INSPECT CONCRETE AND SHOTCRETE PLACEMENT FOR PROPER APPLICATION TECHNIQUES.

F. PRIOR TO CONCRETE PLACEMENT, FABRICATE SPECIMENS FOR STRENGTH TESTS, PERFORM


- (CONTINUOUS) H. VERIFY MAINTENANCE OF SPECIFIED CURING TEMPERATURE AND TECHNIQUES. (PERIODIC)
- I. INSPECT PRESTRESSED CONCRETE FOR:
- APPLICATION OF PRESTRESSING FORCES. (CONTINUOUS) GROUTING OF BONDED PRESTRESSING TENDONS. (CONTINUOUS) INSPECT ERECTION OF PRECAST CONCRETE MEMBERS. (PERIODIC)
- K. VERIFY IN-SITU CONCRETE STRENGTH, PRIOR TO STRESSING OF TENDONS IN POST-TENSIONED CONCRETE AND PRIOR TO REMOVAL OF SHORES AND FORMS FROM BEAMS AND STRUCTURAL SLABS. (PERIODIC)
- L. INSPECT FORMWORK FOR SHAPE, LOCATION AND DIMENSIONS OF THE CONCRETE MEMBER BEING FORMED. (PERIODIC)
- M. NO INSPECTION IS REQUIRÉD FOR SLABS-ON-GRADE.

HAS BEEN PROPERLY PREPARED. (PERIODIC)

- A. VERIFY MATERIALS BELOW SHALLOW FOUNDATIONS ARE ADEQUATE TO ACHIEVE THE DESIGN BEARING CAPACITY. (PERIODIC) B. VERIFY EXCAVATIONS ARE EXTENDED TO PROPER DEPTH AND HAVE REACHED PROPER
- MATERIAL. (PERIODIC) C. PERFORM CLASSIFICATION AND TESTING OF CONTROLLED FILL MATERIALS. (PERIODIC)
- D. VERIFY USE OF PROPER MATERIALS, DENSITIES AND LIFT THICKNESS DURING PLACEMENT AND COMPACTION OF COMPACTED FILL. (CONTINUOUS) E. PRIOR TO PLACEMENT OF COMPACTED FILL, OBSERVE SUBGRADE AND VERIFY THAT THE SITE

LAP

- STRENGTH OF 60,000 PSI. LENGTHS ARE IN INCHES. 2. CASES 1 AND 2, WHICH DEPEND ON THE TYPE OF
- BEAMS AND COLUMNS
- OC SPACING AT LEAST 2.0 db
- OC SPACING AT LEAST 3.0 db
- 3. TOP BARS ARE HORIZONTAL BARS WITH MORE THAN

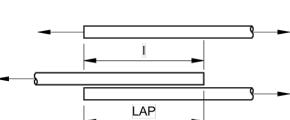

LAP TABLE (f' _c = 4,500 PSI)											
BAR	LAP	UNCOATED BARS									
SIZE	CLASS	TOP	BARS	OTHER	RBARS						
SIZE	CLASS	CASE 1	CASE 2	CASE 1	CASE 2						
#3	Α	18	26	14	20						
#3	В	23	34	18	26						
#4	Α	23	35	18	27						
#4	В	30	45	23	35						
#5	Α	29	44	23	34						
#5	В	38	56	29	44						
#6	Α	35	53	27	40						
#0	В	45	68	35	53						
#7	Α	51	87	39	59						
#1	В	66	100	51	77						
#8	Α	58	88	45	67						
#8	В	76	114	58	88						

1. TABULATED VALUES ARE BASED ON A MINIMUM YIELD

- OC SPACING AT LESS THAN 2.0 db

STRUCTURAL MEMBER, CONCRETE COVER, AND OC

ADDL ADJ AESS ALT	ADDITIONAL ADJACENT ARCH EXPOSED STRUCTURAL STEEL ALTERNATE	NO or# NOM NS	NUMBER NOMINAL NEARSIDE
&	AND	NTS	NOT TO SCALE
APPROX ARCH @	APPROXIMATELY ARCHITECT or ARCHITECTURAL AT or SPACING	OC OD OF	ON CENTER OUTSIDE DIAMETER OUTSIDE FACE
B/ BL BLDG	BOTTOM OF BUILDING LINE BUILDING	O/OOUT OPNG OPP	TO OUT OPENING OPPOSITE
BLKG	BLOCKING	PAF	POWDER ACTUATED FASTENERS
BM BRDG	BEAM BRIDGING	PAR	PARALLEL
BRG	BEARING	PC PERP	PRECAST DEPRENDICULAR
BTWN	BETWEEN	PL	PERPENDICULAR PLATE
вот	BOTTOM	PLF	POUNDS PER LINEAL FOOT
CANT	CANTILEVER	PLYWD PREFAB	PLY WOOD PREFABRICATED
CL	CENTERLINE	PSF	POUNDS PER SQUARE FOOT
CLR CLSM	CLEAR CONTROLLED LOW STRENGTH MATERIAL	PSI	POUNDS PER SQUARE INCH
CTR	CENTER	PT PTFE	POST TENSIONED
COL	COLUMN	PTR	POLYTETRAFLUOROETHYLENE PRESSURE TREATED
CONC	CONCRETE CONNECTION		
CONST	CONSTRUCTION	QL QTY	SEISMIC LOAD QUANTITY
CONT	CONTINUOUS	QII	QUANTITY
CJ CMU	CONTROL/CONSTRUCTION JOINT CONCRETE MASONRY UNIT	RAD	RADIUS
CONT	CONTINUOUS	REF REINF	REFERENCE REINFORCEMENT, REINFORCING, REINFORCEI
CUFT	CUBIC FEET	REQD	REQUIRED
CY	CUBIC YARDS		
OBL	DOUBLE	SCHED SECT	SCHEDULE SECTION
DBA DEG or °	DEFORMED BAR ANCHOR	SER	STRUCTURAL ENGINEER OF RECORD
DEMO	DEGREE DEMOLITION	SF	SQUARE FOOT
DET	DETAIL	SHT SIM	SHEET SIMILAR
OF DIAC	DOUGLAS FIR LARCH	SOG	SLAB-ON-GRADE
DIAG DIA or ø	DIAGONAL DIAMETER	SPA	SPACING
DIM	DIMENSION	SPEC(S) SPF	SPECIFICATION(S) SPRUCE PINE FIR
DO DN	DITTO DOWN	SQ	SQUARE
DP DP	DEEP	SS	STAINLESS STEEL
OWG	DRAWING	STD STIFF	STANDARD STIFFENER
DWL	DOWEL	STL	STEEL
EA	EACH	STR	STRUCTURAL
EF	EACH FACE	STRUCT SUP	STRUCTURAL SUPPORT
EJ EL	EXPANSION JOINT ELEVATION	SYM	SYMMETRICAL
ELEC	ELECTRICAL	SYP	SOUTHERN YELLOW PINE
EMBED	EMBEDDED, EMBEDMENT	Т	TOP
EQ EQUIP	EQUAL EQUIPMENT	T/	TOP OF
ES	EACH SIDE	T&B	TOP AND BOTTOM
EW	EACH WAY	T&G TEMP	TONGUE AND GROOVE TEMPERATURE STEEL
EX EXIST	EXISTING EXISTING	THD	THREAD
E)	EXISTING	THK	THICK
EXP	EXPANSION	THRU TOL	THROUGH TOLERANCE
EXT	EXTERIOR	TRANS	TRANSVERSE
FAB	FABRICATE	TYP	TYPICAL
FDN	FOUNDATION	LIN or LINO	UNLESS NOTED (OTHERWISE)
=V =IN	FIELD VERIFY	011 01 0110	ONLESS NOTES (OTTLENWISE)
-IIN FLG	FINISH FLANGE	VERT	VERTICAL
FLR	FLOOR	VIF	VERIFY IN FIELD
S	FARSIDE	w/	WITH
FT	FOOT, FEET FOOTING	w/o	WITHOUT
FTG		10/15	1017 15 31 3
FTG		WD WP	WOOD WORKPOINT
GA	GAGE	WP WT	WORKPOINT WEIGHT
		WP	WORKPOINT

GEN

GLB

GYP BD

HORIZ

HVY

INFO

INV

KSF

KSI

LBS

LG

LLH LLV

LOC LONG

LP

LSH

LSV

LT WT

MANUF

MAS

MATL

MAX

MECH

MEZZ

MFR

MIN

MISC

MK

MO

MTL

GR

GENERAL

GYPSUM BOARD

HOLLOW CORE

HIGH STRENGTH

INSIDE DIAMETER

KIPS PER SQUARE FOOT

KIPS PER SQUARE INCH

LONG LEG HORIZONTAL

LONG SIDE HORIZONTAL

LONG SIDE VERTICAL

LONG LEG VERTICAL

INSIDE FACE

INFORMATION INTERIOR

HORIZONTAL

HIGH POINT

HEIGHT

HEAVY

INVERT

JOIST

JOINT

ANGLE

LONG

POUNDS

LINEAL FEET

LIVE LOAD

LOCATION

LONGITUDINAL

LOW POINT

LIGHT WEIGHT

MASONRY

MATERIAL

MAXIMUM

MECHANICAL

MEZZANINE

MINIMUM

METAL

MANUFACTURER

MANUFACTURER

MISCELLANEOUS

MASONRY OPENING

GRADE

GLUE LAMINATED BEAM

- SPACING OF THE BARS ARE DEFINED AS: CASE 1: CONCRETE COVER AT LEAST 1.0db AND
- CASE 2: CONCRETE COVER LESS THAN 1.0d₀ OR
- CASE 1: CONCRETE COVER AT LEAST 1.0db AND CASE 2: CONCRETE COVER LESS THAN 1.0db OR
- 12 INCHES OF CONCRETE CAST BELOW THE BARS.

OC SPACING AT LESS THAN 3.0 db



PROJECT NO.


230264


DISCIPLINE

STRUCTURAL

SHEET NAME

20-S-03

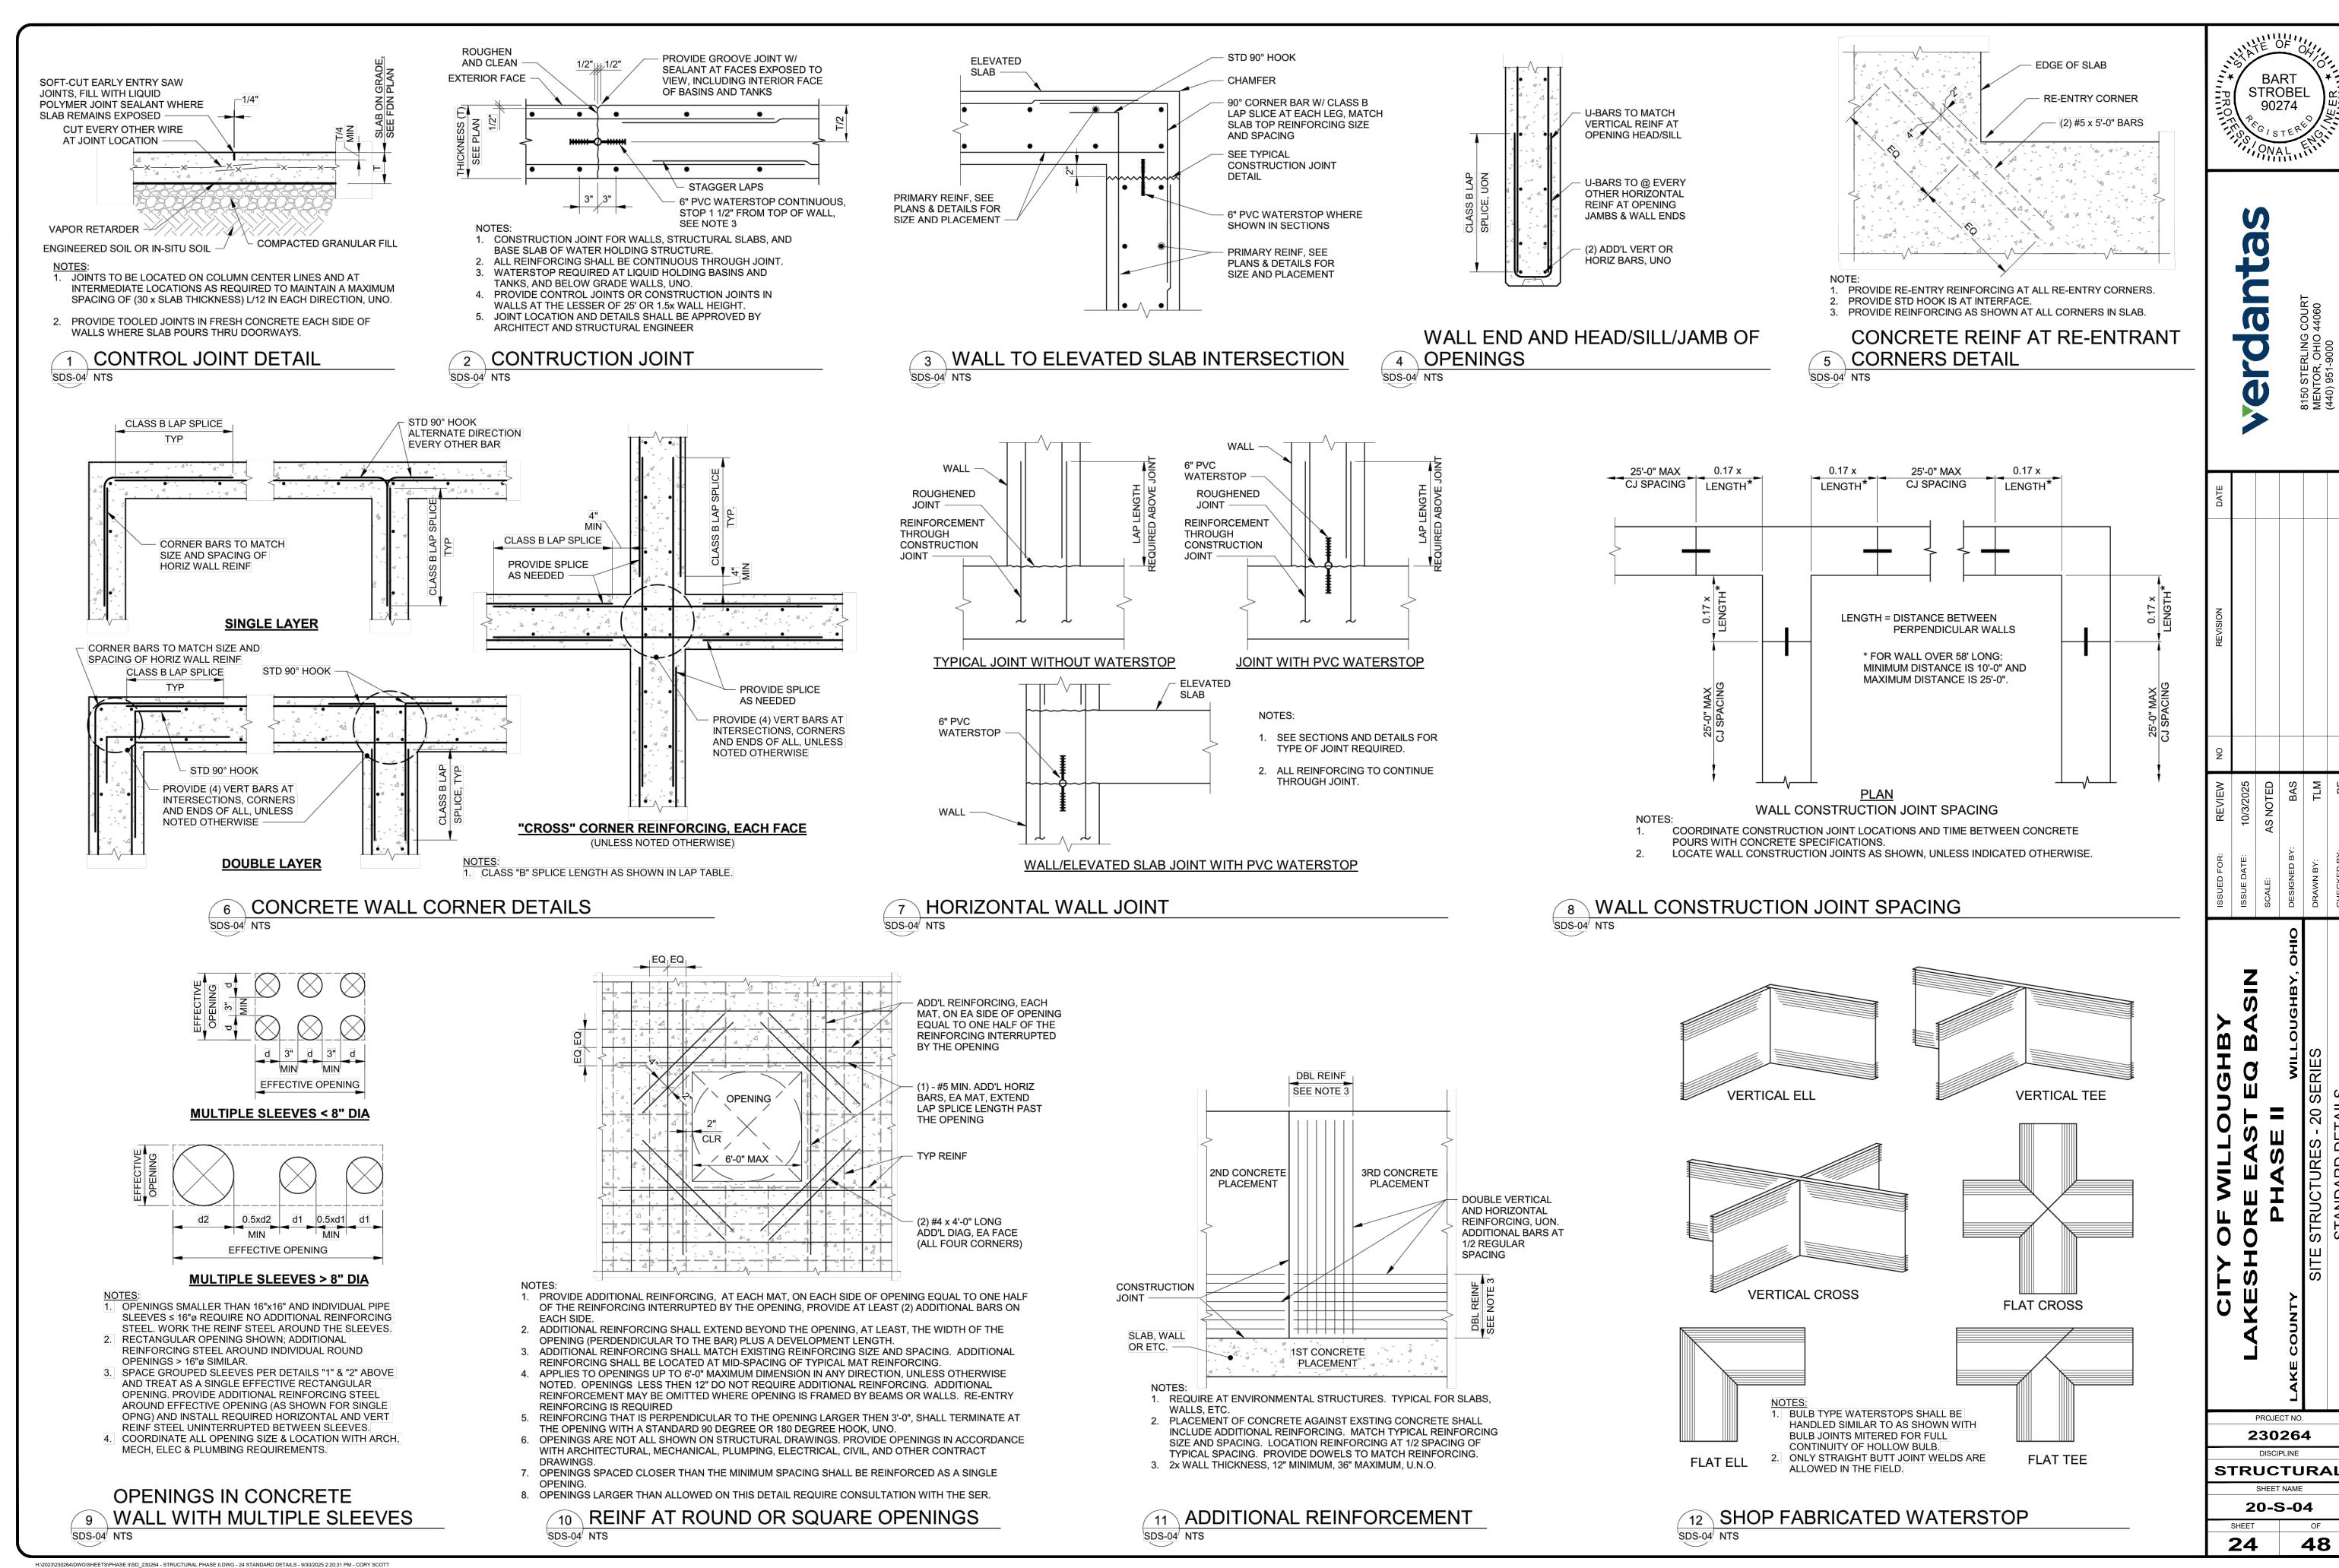

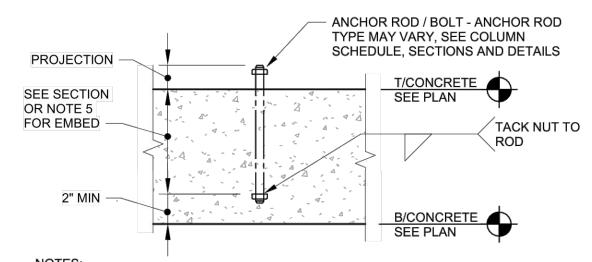


NOTES: 1. USE HEAD BOLTS OR TACK WELD

- 2. COORDINATE PROJECTION WITH EQUIPMENT SUPPLIER UNLESS
- NOTED OTHERWISE
- 3. DO NOT USE 'J' BOLTS. 'J' BOLTS ARE NOT ACCEPTABLE
- 4. ANCHOR BOLTS TO BE STAINLESS STEEL UNLESS NOTED OTHERWISE 5. PROVIDE 12" MINIMUM ANCHOR EMBED FOR PEMB COLUMNS AND

1 ANCHOR BOLT DETAIL


SDS-05 NTS


SDS-05 NTS

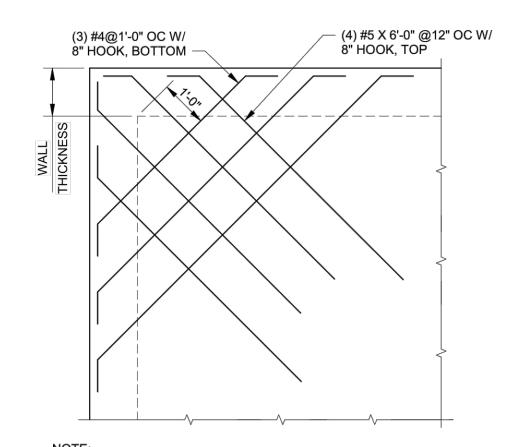

2 OUTSIDE CORNER REINFORCING

ADDITIONAL CORNER BARS REQUIRED FOR ALL CORNERS OF STRUCTURAL SLABS THAT ARE LARGER THEN 10'-0".

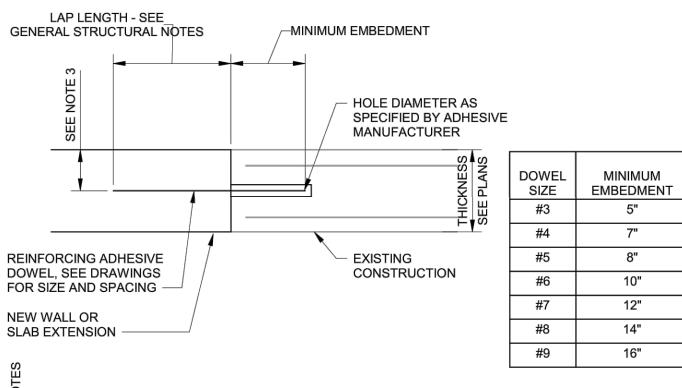

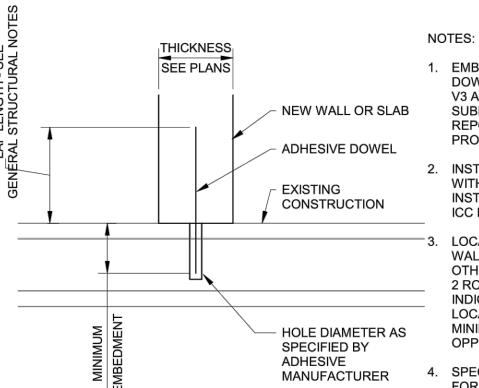


 EMBEDMENT LENGTH IS BASED ON DOWELS SET WITH HILTI HIT-RE 500-V3 ADHESIVE ANCHOR SYSTEM. SUBMIT ICC EVALUATION SERVICE REPORT (ES REPORT) IF ALTERNATE PRODUCT IS PROPOSED.

2. INSTALL DOWELS IN ACCORDANCE WITH MANUFACTURER'S INSTALLATION INSTRUCTIONS AND ICC ES REPORT ESR-3814. LOCATE DOWELS CENTERED IN

WALL OR SLAB UNLESS NOTED OTHERWISE ON DRAWINGS. WHERE 2 ROWS OF DOWELS ARE INDICATED, STAGGER SPACING AND LOCATE ALTERNATING DOWELS AT MINIMUM EDGE DISTANCE FROM OPPOSITE FACES.

4. SPECIAL INSPECTION IS REQUIRED FOR ADHESIVE DOWEL INSTALLATION.

3 REBAR DOWELS SET WITH ADHESIVE

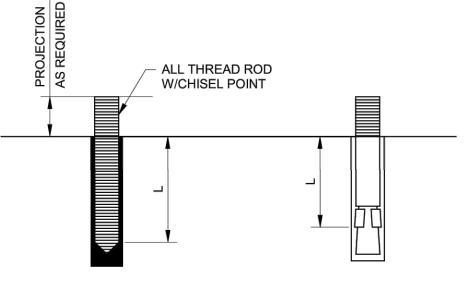


ADHESIVE ANCHOR **EXPANSION ANCHOR**

	MINIMUM EMBEDMENT	LENGTH, L
DIAMETER	ADHESIVE ANCHOR	EXPANSION ANCHOR
3/8"	4 1/2"	3 1/2"
1/2"	6"	4 3/4"
5/8"	7 1/2"	5 1/2"
3/4"	9"	6 1/2"
7/8"	10 1/2"	-
1"	12"	-

- 1. CONFORM TO ICC EVALUATION SERVICE REPORT (ES REPORT) REQUIREMENTS AND MANUFACTURER'S RECOMMENDATIONS FOR INSTALLATION.
- 2. PROVIDE TYPE 316 STAINLESS STEEL ALL-THREAD ROD MATERIAL.
- 3. PROVIDE HOLE DIAMETER IN ACCORDANCE WITH MANUFACTURER'S RECOMMENDATION.
- 4. EXPANSION ANCHOR SHALL BE STAINLESS STEEL ANCHORS.
- 5. EXPANSION ANCHOR EMBEDMENT LENGTHS ARE BASED ON HILTI KWIK BOLT TZ STAINLESS STEEL ANCHORS. SUBMIT ICC EVALUATION SERVICE REPORT (ES REPORT) FOR ALTERNATE PRODUCTS.
- 6. ADHESIVE ANCHOR EMBEDMENT LENGTHS ARE BASED ON HILTI HIT-RE 500-V3 ADHESIVE SUBMIT ICC ES REPORT FOR ALTERNATE PRODUCTS.




9 PIPE SADDLE SUPPORT

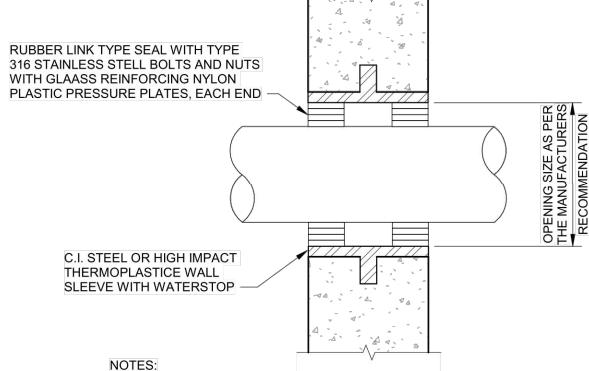


- 1. COORDINATE W/ MECHANICAL DRAWINGS. MECHANICAL DRAWINGS TAKE PRECEDENCE.
- 2. FOR EXISTING CONCRETE, PROVIDE CORED HOLE IN LIEU OF SLEEVE. DO NOT CORE WITHOUT PRIOR WRITEN APPROVAL FROM THE ENGINEER

COMPRESSIVE RUBBER LINK TYPE

PIPE SLEEVE 5 THRU CONCRETE WALL DETAIL SDS-05 NTS

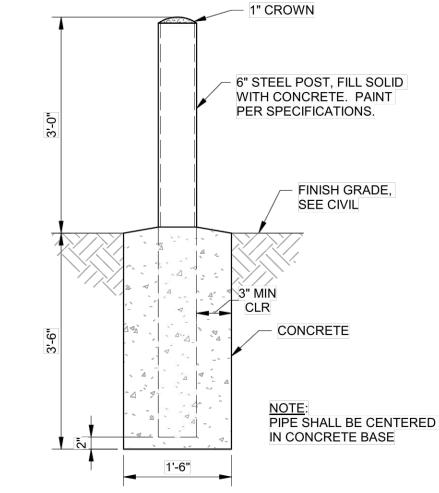



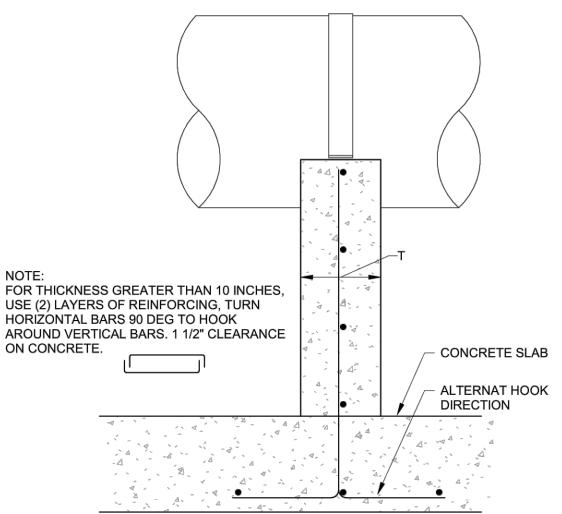

PIPE SIZE			DIMEN	ISIONS		
FIFE SIZE	Α	В	С	D	Т	U
6" - 12"	1/4"	2"	3/4"	3"	8"	3/16"
14" - 18"	1/4"	4"	3/4"	3"	9"	1/4"
20" - 36"	3/8"	5"	3/4"	3"	10"	3/8"
42" - 54"	3/8"	6"	1"	4"	12"	3/8"
60" - 72"	3/8"	6"	1 1/8"	5"	16"	1/2"

10 PIPE SADDLE SUPPORT SECTION


				SDS	-05 NTS				
TYPE 316 SST PIPE STR REQUIRED, DIMENSION MECHANICAL DRAWING LOCATIONS	"AxB" SEE	PIPE OD + "D"	C"C" DIA x 12" LONG SST ANCHOR BOLT EACH SIDE WHEN STRAP IS REQUIRED 4 1/2" MIN TYP						
#3 BARS		DIAMETER DIAMETER	6" 45 AT 12"	USE (2) LAYERS HORIZONTAL B	SS GREATER THAS OF REINFORCI ARS 90 DEG TO ICAL BARS. 1 1/2	NG, TURN HOOK	J ,		
(2) LAYERS 30# ROOFING FELT, SECURE TIGHT TO PIPE DURING CONCRETE PLACEMENT			2" CLR TYP #5 AT 12" MAX, EXTEND TO 1 1/2" CLEAR AT TOP OF CONCRETE		PIPE SIZE			DIMEN	JS
<u> </u>						A	В	C	L
4		4	4 -4 44	-	6" - 12" 14" - 18"	1/4"	2" 4"	3/4"	\vdash
	4.4.				20" - 36"	3/8"	5"	3/4"	\vdash
			A	-	42" - 54"	3/8"	6"	1"	\vdash
SAME CLEARANCE AS BOTTOM LAYER OF SLAB REINFORCING TYP	CONCRETE SLAB				60" - 72"	3/8"	6"	1 1/8"	


STROBEL 90274

PROJECT NO. 230264

STRUCTURAL

SHEET NAME 20-S-05 SHEET **25** 48

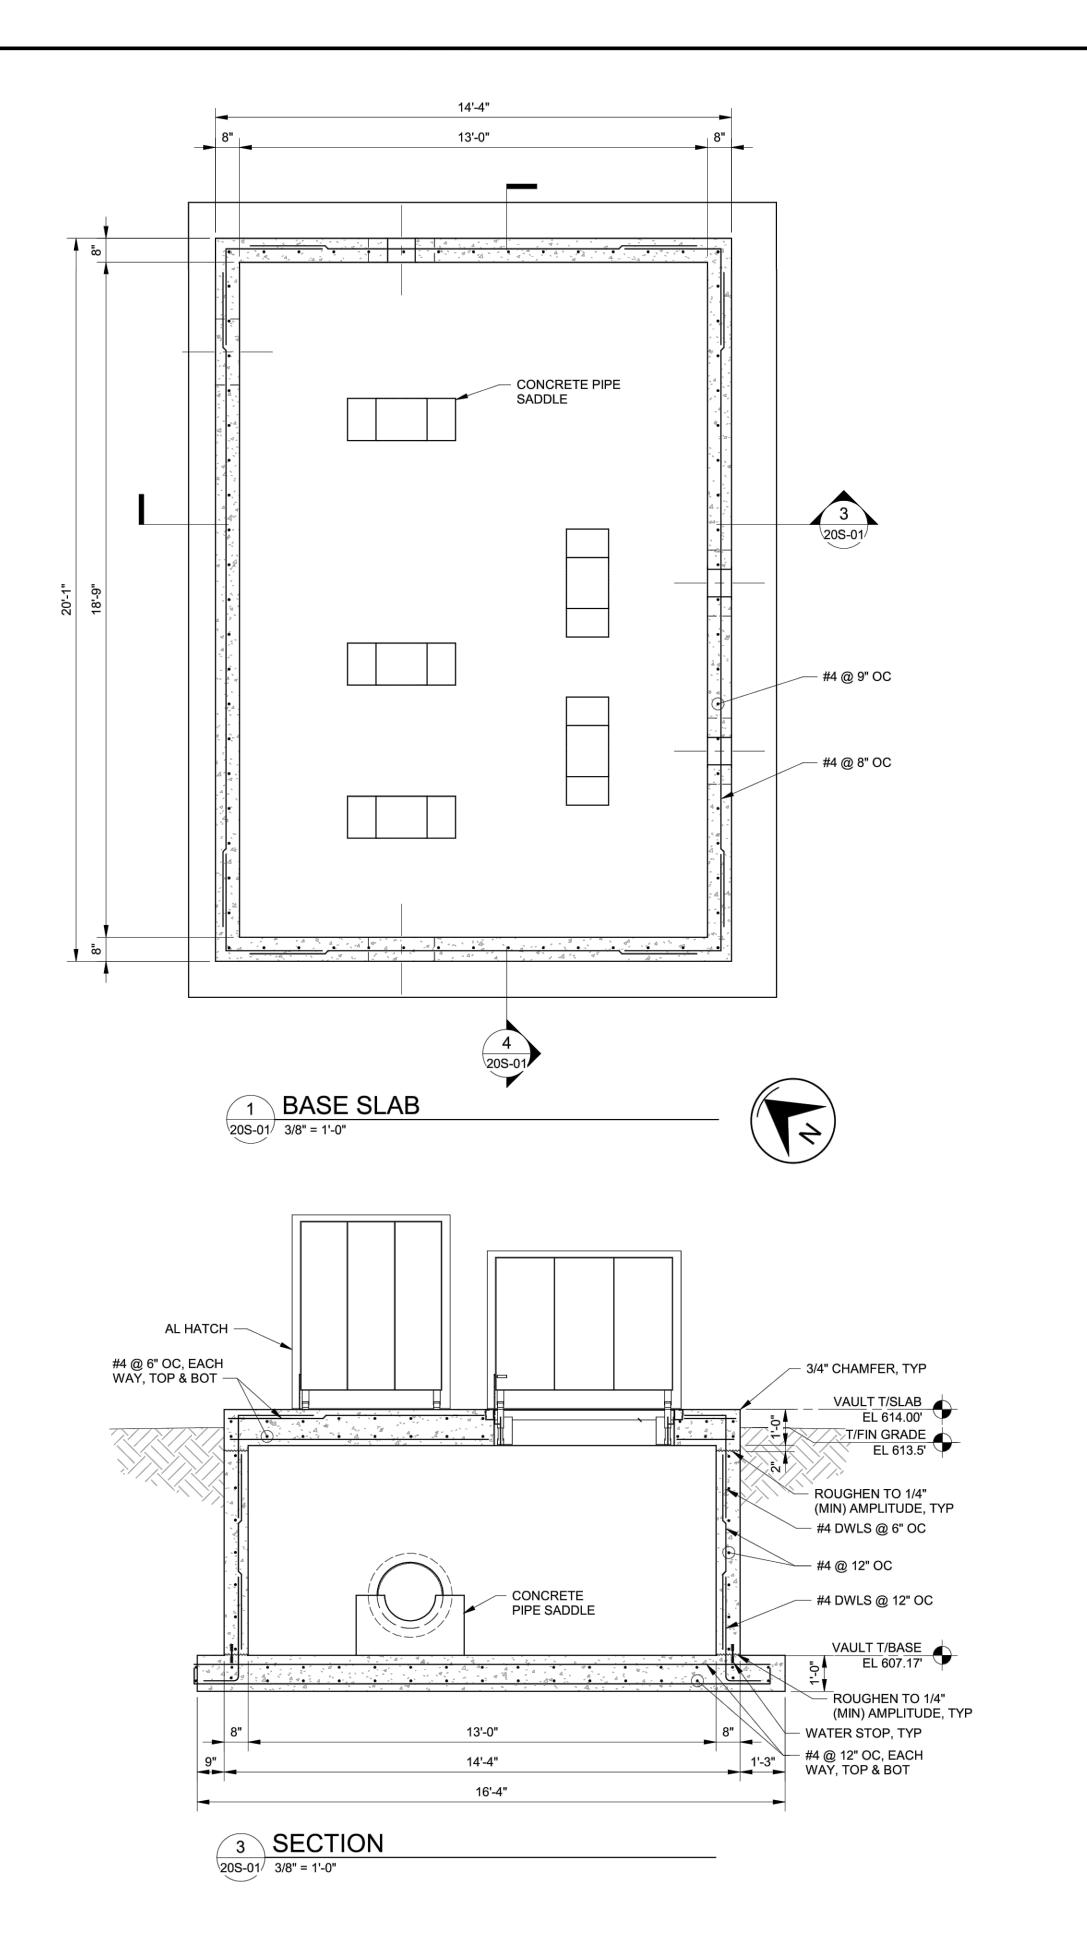

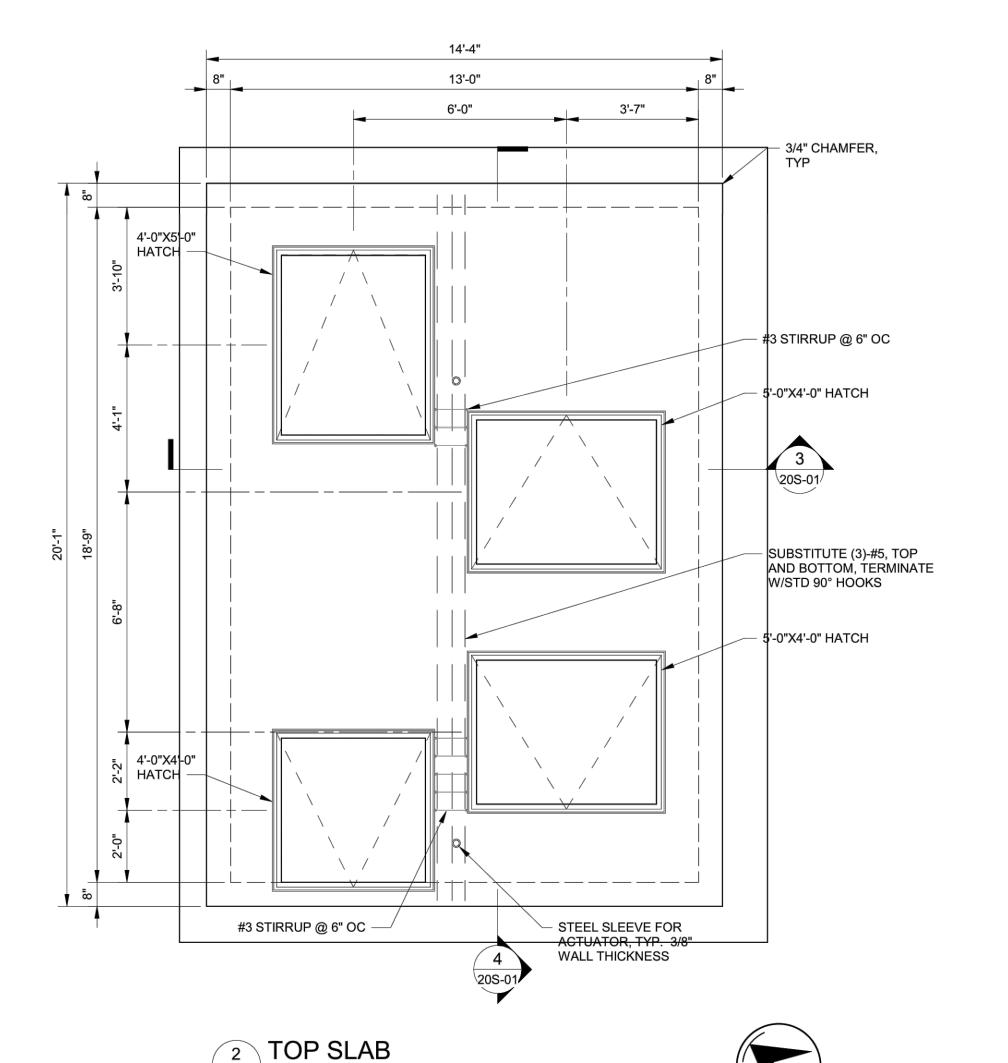

\20S-01/ 3/8" = 1'-0"


VALVE VAULT PLAN NOTES:

- 1. SEE SHEETS SD-S-01 THRU SD-S-04 FOR GENERAL STRUCTURAL
- 2. SEE SHEET SD-S-05 AND SD-S-06 FOR TYPICAL DETAILS.
- 3. COORDINATE DIMENSIONS NOT SHOWN WITH PROCESS MECHANICAL AND CIVIL DRAWINGS. DIMENSIONS SHALL

CONFORM TO THE PROCESS DRAWINGS.

ON PLAN AND SECTIONS, UNO.


- 4. COORDINATE LOCATION AND SIZE OF PENETRATIONS AND OPENINGS WITH PROCESS. MECHANICAL, ELECTRICAL, AND CIVIL DRAWINGS, TYP. OPENING SHALL BE PER PROCESS MECHANICAL AND CIVIL STANDARDS FOR SIZE AND SEALING REQUIREMENTS.
- 5. TOP OF GRADE SHALL BE 6" BELOW THE STRUCTURE,UNO, TO PREVENT STORM WATER SEDIMENT FROM IMPACTING THE HATCH DRAIN CHANNELS.
- 6. TOP OF STRUCTURAL SLAB ELEVATION SHALL BE AS INDICATED
- 7. TOP OF WALL ELEVATION SHALL BE AS INDICATED ON PLAN AND SECTIONS, UNO.
- 8. TOP OF BASE SLAB ELEVATION SHALL BE AS INDICATED ON PLAN AND SECTIONS, UNO.
- 9. BOTTOM OF FOOTING DETAILS SHOWN ARE BASED UPON FOUNDATIONS BEARING ON MATERIALS AS LISTED IN FOUNDATION GENERAL NOTES. BEARING ELEVATIONS HAVE BEEN ESTABLISHED FROM THE GRADING PLAN AND SOILS REPORT. FOUNDATION BEARING SURFACES MUST BE INSPECTED AND APPROVED IN ACCORDANCE WITH FOUNDATION GENERAL NOTES AND BOTTOM OF FOOTING ELEVATIONS ADJUSTED ACCORDINGLY.
- 10. ADDITIONAL BASE MATERIAL, ALL SLABS AND FOOTINGS SHALL BEAR ON, AT LEAST, 6" COMPACTED ENGINEERED GRANULAR MATERIAL.
- 11. PROVIDE STANDARD HOOKS AS SHOWN
- 12. REINFORCING IN 8" WALLS SHALL BE CENTERED IN THE WALL.
- 13. PROVIDE WATERSTOPS AT ALL CONSTRUCTION JOINTS. WATERSTOPS NOT REQUIRED WITHIN 12" FROM TOP OF GRADE OR AT WEIR WALL JOINTS
- 14. HATCHES SHALL BE ALUMINUM WITH RECESSED HASPS AND REMOVABLE HANDLES. HATCHES WITHIN FENCED AREAS SHALL HAVE A 300 PSF LOAD RATING. HATCHES WITHIN ROW SHALL HAVE AN HS-20/RL-93 LOAD RATING.
- 15. CHAMFER AT TOP SLAB SHALL RUN DOWN VERTICAL EXTERIOR CORNER TO, AT LEAST 12" BELOW GRADE.
- 16. CONTRACTOR SHALL EXERCISE EXTREME CAUTION SO AS NOT TO UNDERMINE, DISTURB, DAMAGE OR, IN ANY WAY, CAUSE UNDESIRABLE MOVEMENT, CRACKING, AND/OR SETTLEMENT OF THE ADJACENT STRUCTURES OR CONSTRUCTION.
- 17. PROVIDE RE-ENTRY REINFORCING AT ALL RE-ENTRY CORNERS.
- 18. REFERENCE DETAIL 6 AND 7 ON 20S-02 FOR STIRRUP AND REINFORCE ARRANGEMENT AT NARROW STRIP BETWEEN HATCHES.

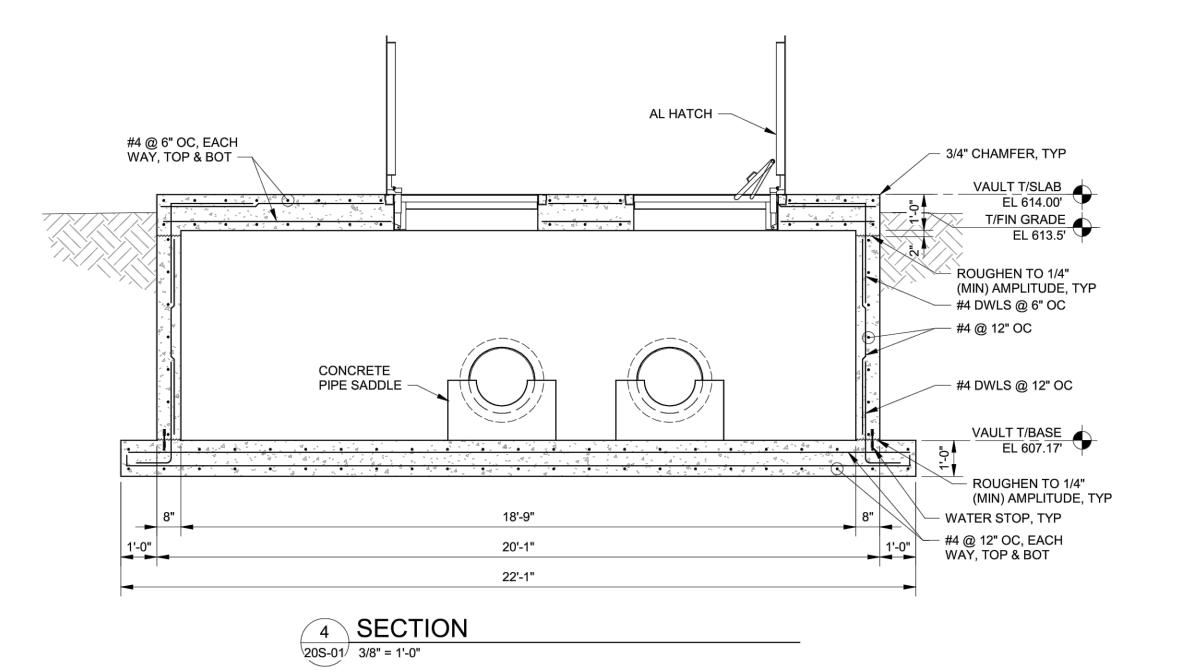





ORE EAST EQ BASIN	ISSUE DATE:	10/3/2025	
	SCALE:	AS NOTED	
WILLOUGHBY, OHIO	DESIGNED BY:	BAS	
STRUCTURES - 20 SERIES	DRAWN BY:	TLM	
VALVE VAULT	CHECKED BY:	BF	

PROJECT NO. 230264 DISCIPLINE **STRUCTURAL** SHEET NAME **20-S-06**

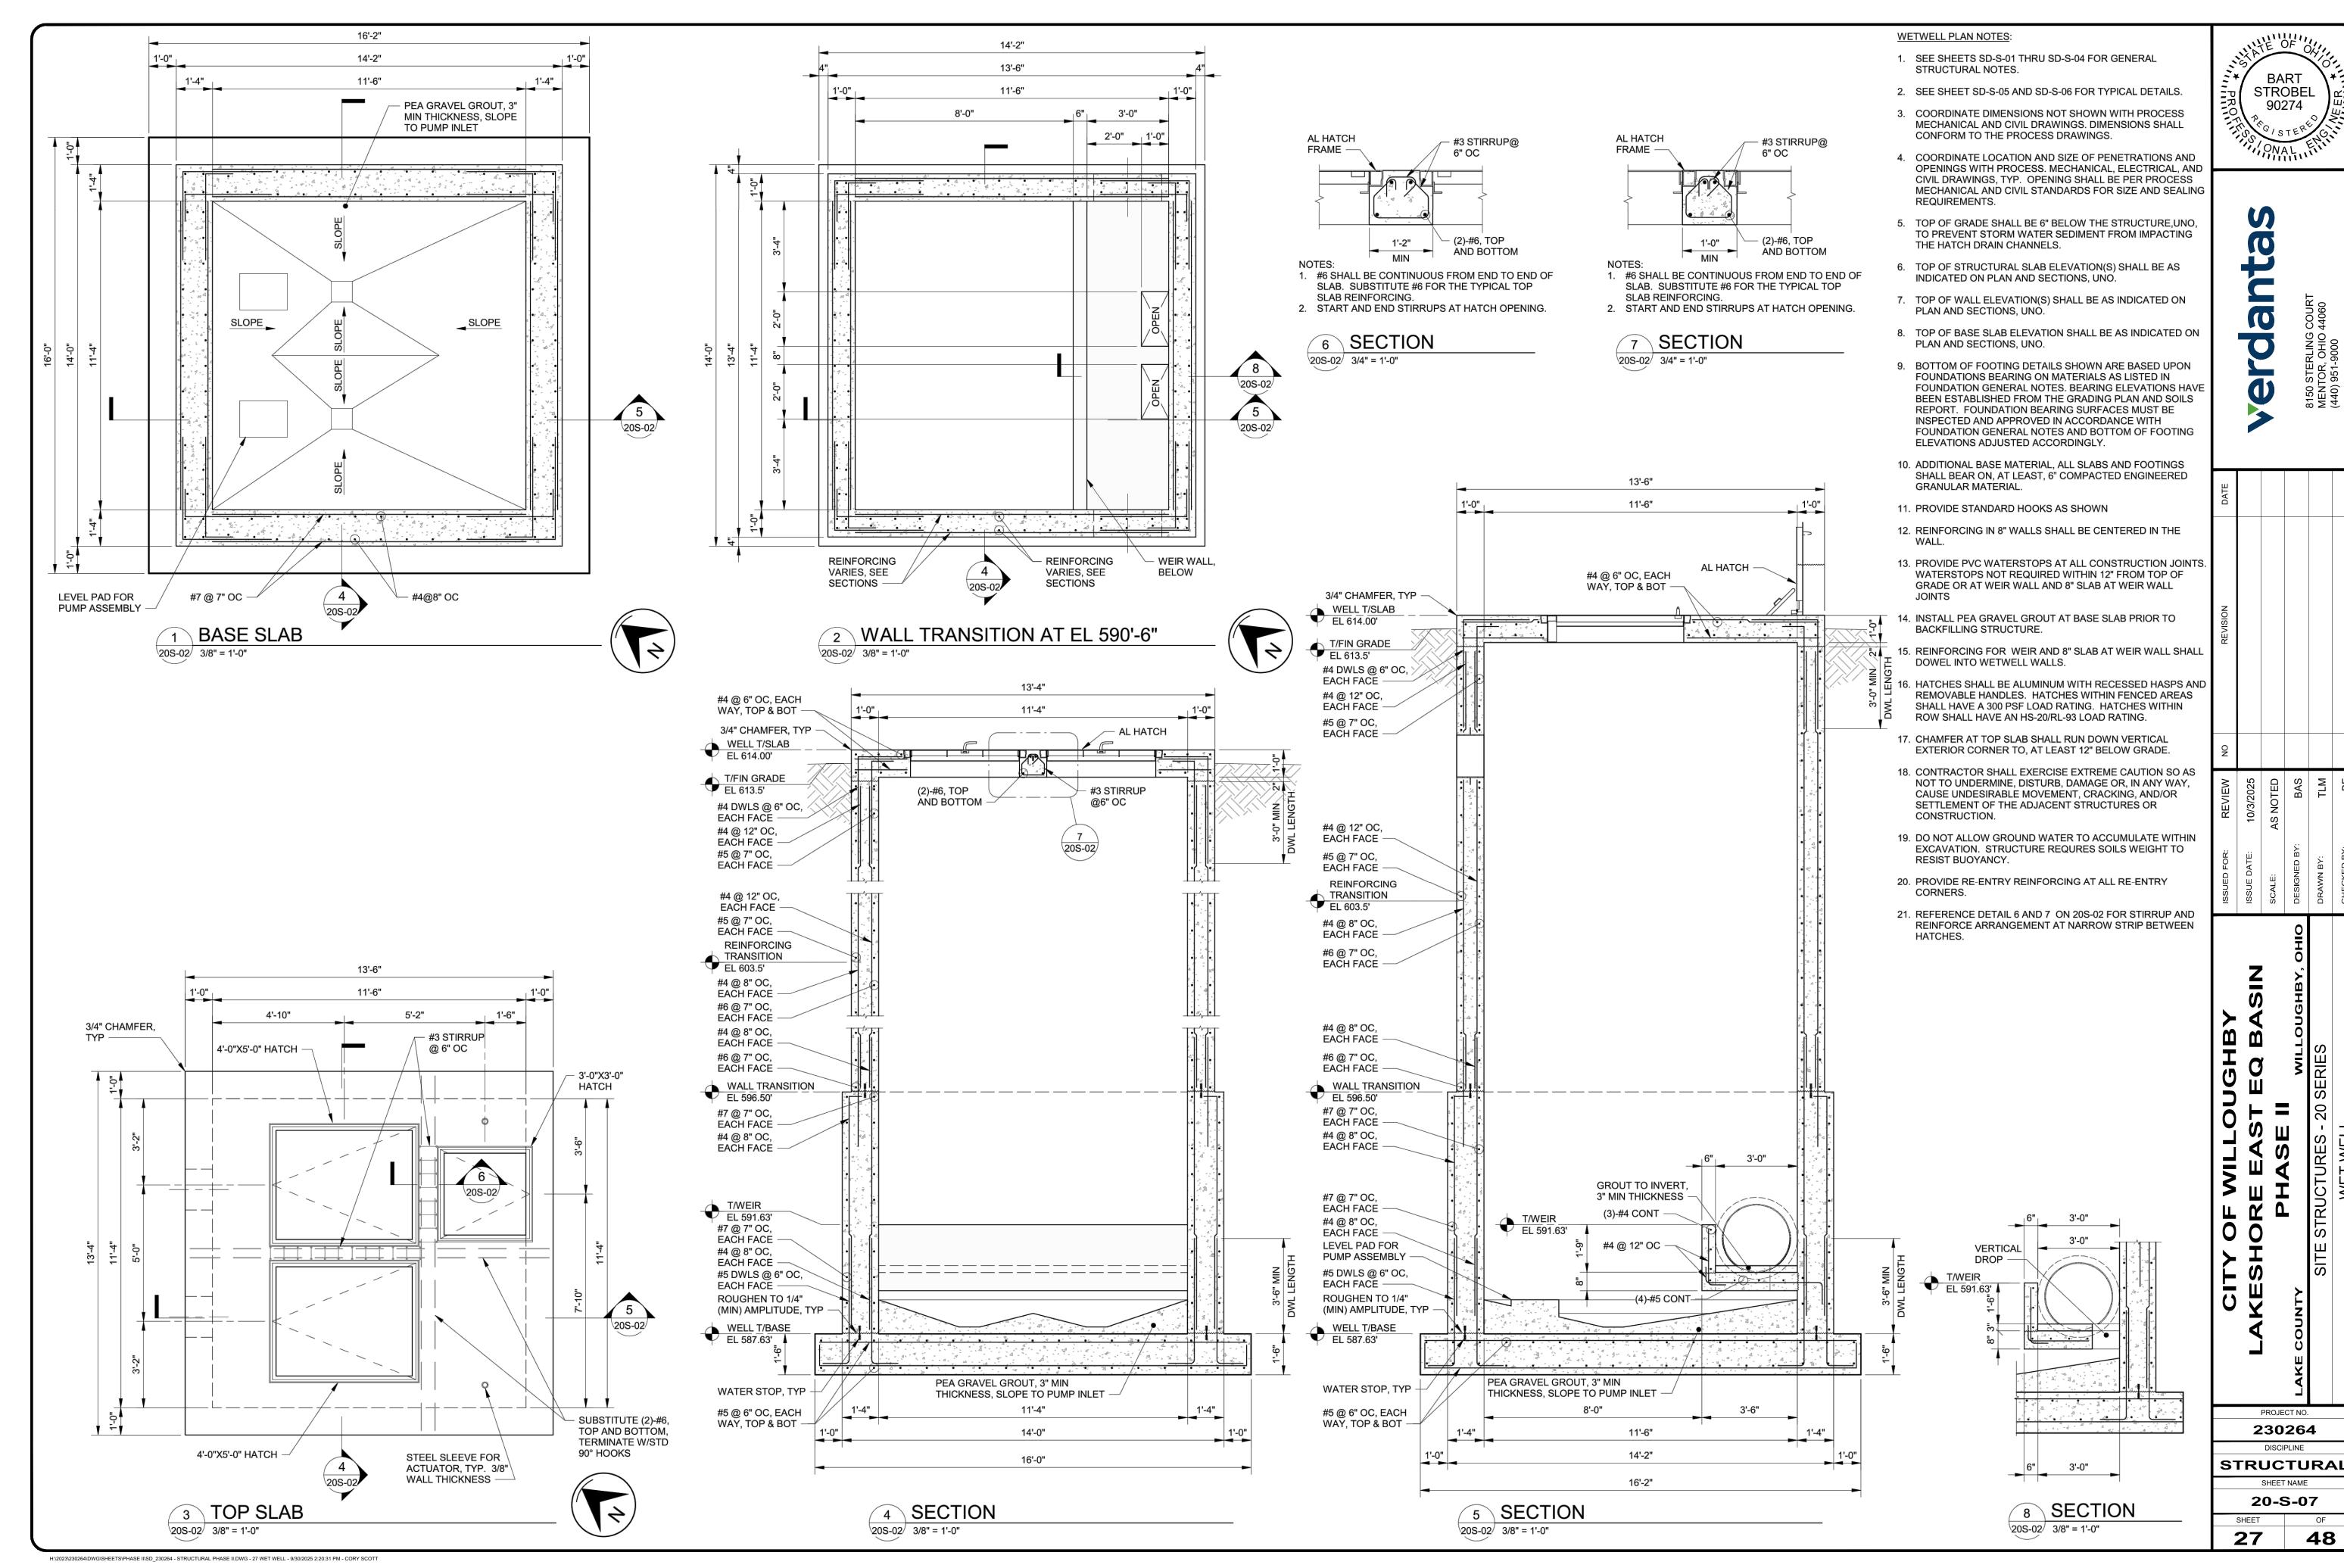

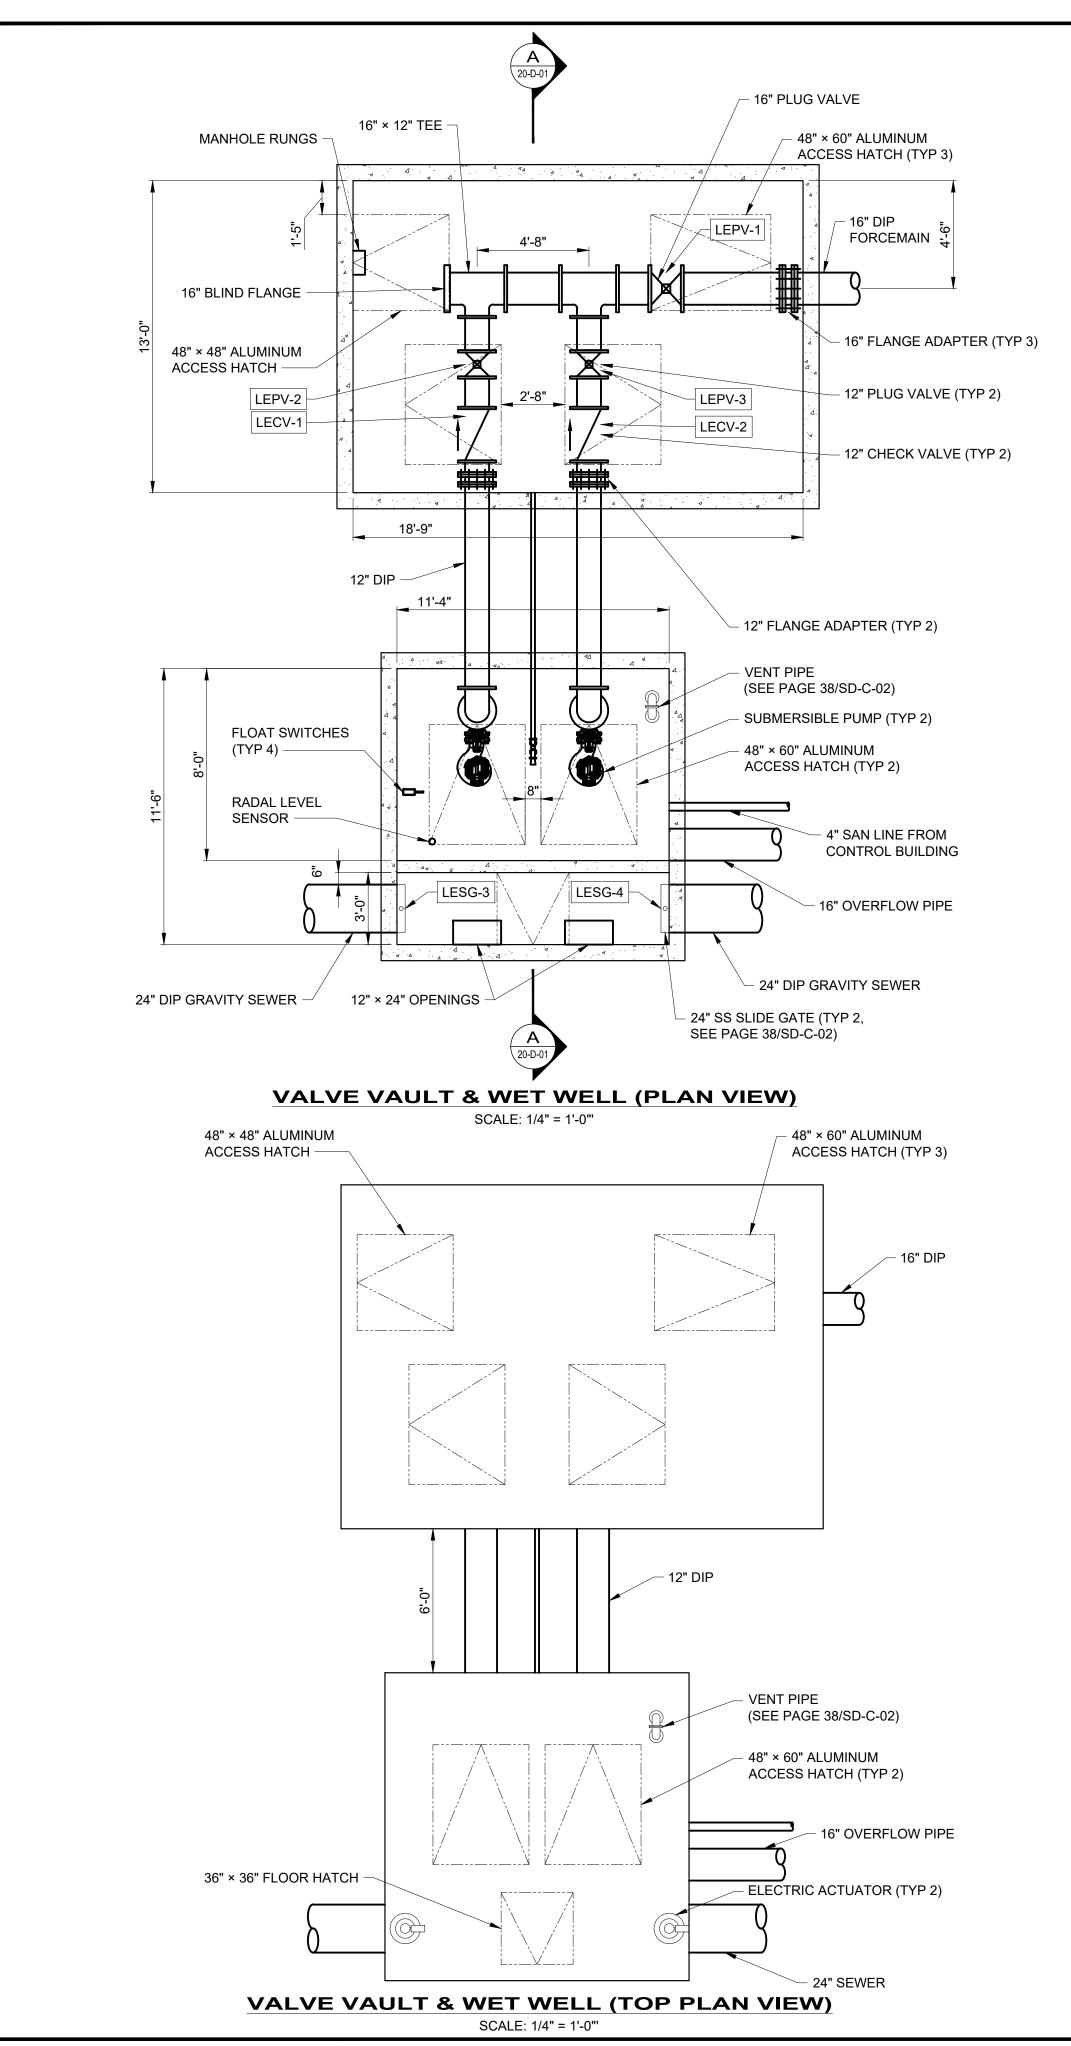

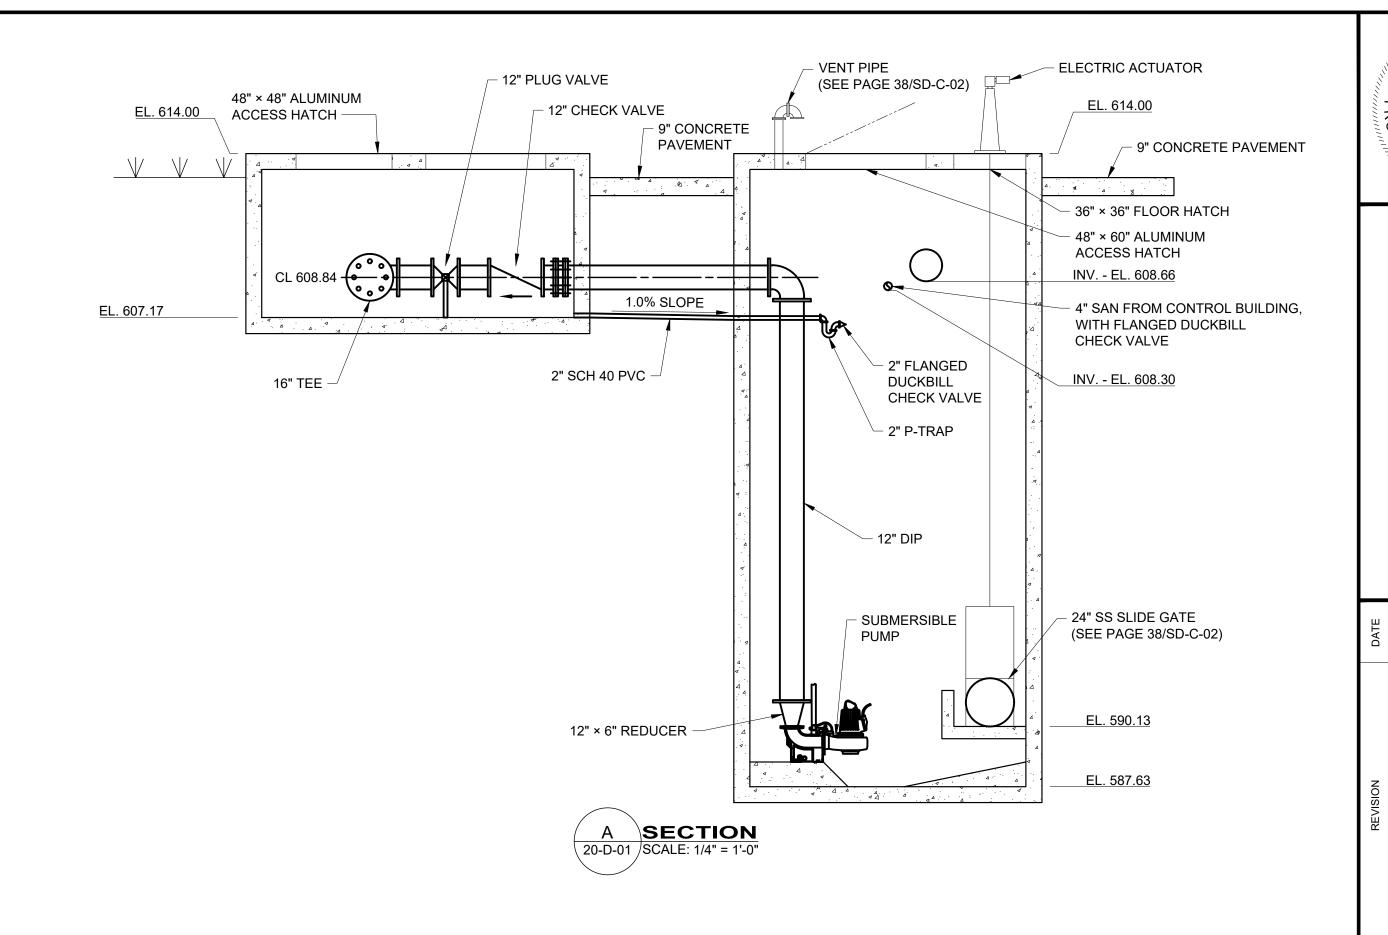

					VALVE SCHEDULE	
TAG#	TYPE	SIZE	END TYPE	OPERATOR	SERVICE	REMARKS
LECV-1	CV	12"	FL	OWL	VALVE VAULT	
LECV-2	CV	12"	FL	OWL	VALVE VAULT	
LEPV-1	PV	16"	FL	ON	VALVE VAULT	
LEPV-2	PV	12"	FL	ON	VALVE VAULT	
LEPV-3	PV	12"	FI	ON	VALVE VAULT	


					GATE SCHEDULE	
TAG#	TYPE	HEIGHT	WIDTH	OPERATOR	SERVICE	REMARKS
LESG-3	SG	24"	24"	EM	WET WELL	FLOOR PEDALSTAL WITH VANDAL RESISTANT COVER ON EM
LESG-4	SG	24"	24"	EM	WET WELL	FLOOR PEDALSTAL WITH VANDAL RESISTANT COVER ON EM

	PUMP SCHEDULE											
			DESIGN		MOTOR	MOTOR	POWER	DISCHRAGE	HIGH WATER	PUMP 1	PUMP 2	
DESCRIPTION	TYPE OF PUMP	PUMPED LIQUID	CAPACITY, GPM	TDH, FT	HORSEPOWER	SPEED	REQUIREMENTS	SIZE, IN	ALARM	ON	ON	PUMPS OFF
LAKESHORE EAST PUMP #1	SUBMERSIBLE	WASTEWATER	1,000	28	12	1800	3PH/60 HZ/460V	6	608.30	590.13	594.13	588.66
LAKESHORE EAST PUMP #2	SUBMERSIBLE	WASTEWATER	1,000	28	12	1800	3PH/60 HZ/460V	6	608.30	590.13	594.13	588.66

TATE OF ON RYAN S. SCHUSTER 72755

ntas	F
verda	8150 STERLING COURT

CITY OF WILLOUGHBY	LAKESHORE EAST EQ BA	PHASE II	LAKE COUNTY WILLOUG	SITE STRUCTURES - 20 SERIES
		ROJECT		
		302		4
		ISCIPLI		
-		OC HEET NA		SS
	20			1
CI		<u> </u>		OF

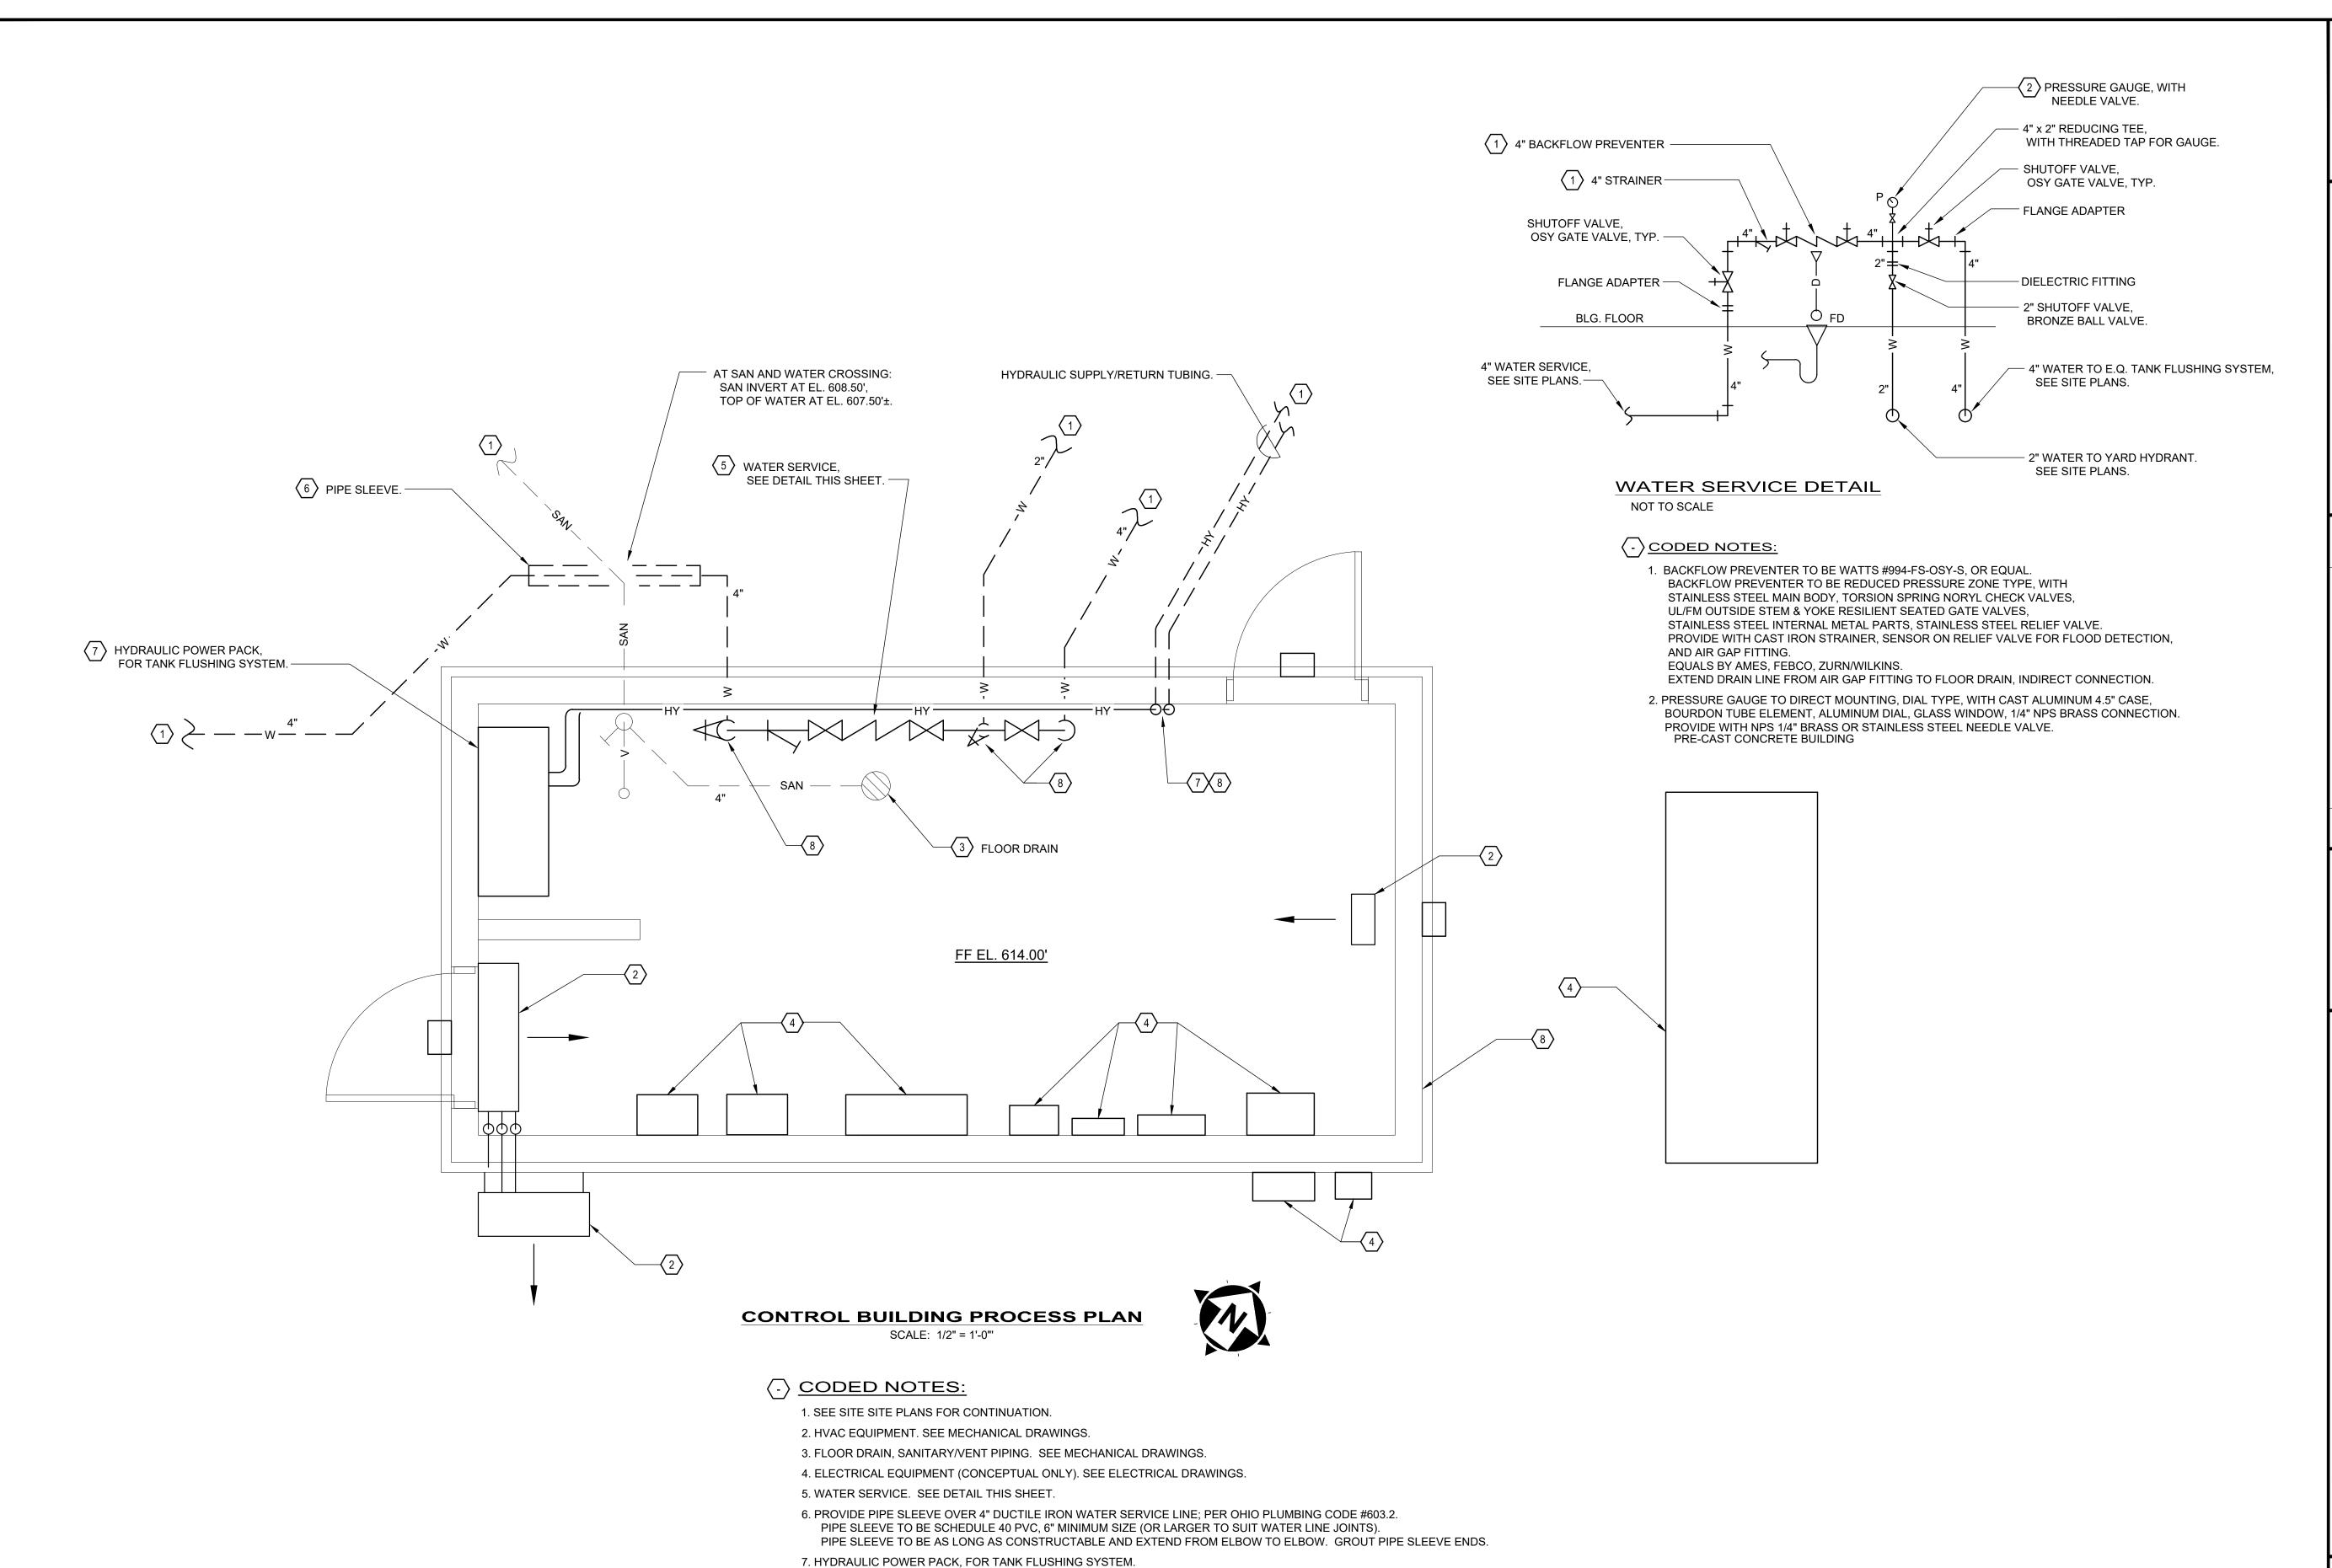

ROUTE HYDRAULIC LINES ALONG WALL, THEN DOWN THROUGH FLOOR UNDERGROUND TO TANK.

UNDERGROUND HYDRAULIC TUBING TO BE INSTALLED IN PVC CONTAINMENT PIPES.

8. BUILDING IS PRE-CAST CONCRETE. COORDINATE ALL PRE-CAST OPENINGS (FOR PIPING, ETC.)

WITH GENERAL TRADES CONTRACTOR AND BUILDING MANUFACTURER. TYPICAL FOR ALL.

SEE SPECIFICATION #464614 FOR ADDITIONAL INFORMATION.

RYAN S.

RYAN S.

SCHUSTER

72755

ONAL

rdanta

8150 STERLING COURT

10/3/2025	AS NOTED	Y: JRM/RSS	JRM	: JRM/RSS
ISSUE DATE:	SCALE:	DESIGNED BY:	DRAWN BY:	CHECKED BY:
LAKESHORE EAST EO BASIN		LAKE COUNTY WILLOUGHBY, OHIO	SITE STRUCTURES - 20 SERIES	CONTROL BUILDING PLAN & DETAILS

PROJECT NO.

230264

DISCIPLINE

PROCESS

20-D-02

	2024 OHIO BU	ILDING CODE	
	CODE COM	MPLIANCE	
X	NEW CONSTRUCTION		
CONSTRUCTION TYPE	1B	RISK CATEGORY	III
OCCUPANT LOAD	2		
USE GROUP	U	DESCRIPTION	UTILITY BUILDING
PLUMBING: 2024 OPC	MECHANICAL: 2024 OMC	ELECTRIC: NEC 2023	ENERGY: ASHRAE 90.1-19
BUILDING HEIGHT	9'-10"	BUILDING AREA	338 SQ. FT.
REMARKS			
ACCESIBILITY COMPLIANCE		ICC / ANSI A117.1- 2017	

OBC SECTION 108.2.14 INDUSTRIALIZED UNIT (I.U.) INSPECTIONS.

INSPECTION OF ON-SITE CONSTRUCTION TO COMPLETE INSTALLATION OF APPROVED INDUSTRIALIZED UNITS IS THE RESPONSIBILITY OF THE BUILDING DEPARTMENT WITH JURISDICTION. SUCH INSPECTIONS INCLUDE:

- 1. CONNECTION TO ON-SITE CONSTRUCTION, INTERCONNECTION OF MODULES, AND CONNECTION TO UTILITIES. THE INSPECTIONS AND CONDUCTING OF REQUIRED TESTS ARE NOT TO REQUIRE THE DESTRUCTION OR DISASSEMBLY OF ANY FACTORY CONSTRUCTED COMPONENT AUTHORIZED BY THE BOARD.
- 2. INSPECTION OF THE UNIT FOR DAMAGE RESULTING FROM TRANSPORTATION, IMPROPER PROTECTION OF EXPOSED PARTS FROM INCLEMENT WEATHER OR OTHER CAUSES. DAMAGE IS TO BE REPAIRED AS REQUIRED BY THE BUILDING OFFICIAL TO COMPLY WITH THE APPLICABLE PROVISIONS OF THE RULES OF THE BOARD.
- 3. INSPECTION OF THE UNIT TO DETERMINE IF IT IS MARKED BY AN INSIGNIA FURNISHED BY THE BOARD.
- 4. INSPECTION OF THE UNIT TO DETERMINE IF THE FLOOR PLAN, EXTERIOR ELEVATIONS, & EXPOSED DETAILS ARE IN CONFORMANCE WITH THE PLANS APPROVED BY THE BOARD.
- 5. MANUFACTURER SHALL PROVIDE OHIO PE STAMPED DRAWINGS OF THE BUILDING AND FOUNDATION.

OBC SECTION 108.2

INSPECTIONS FOR SITE INSTALLED WORK FOR INDUSTRIALIZED UNITS, AND BUILDING SERVICES EQUIPMENT, ARE WITHIN THE RESPONSIBILITY OF THE BUILDING DEPARTMENT HAVING JURISDICTION.

108.6.4 INDUSTRIALIZED UNITS, OBSERVATIONS OF NONCOMPLIANCE.

IF A UNIT OF CLOSED CONSTRUCTION DOES NOT BEAR AN INSIGNIA ISSUED BY THE BOARD, THE UNIT HAS NOT BEEN APPROVED BY THE BOARD AND THEREFORE IS WITHIN THE JURISDICTION OF THE BUILDING DEPARTMENT. UNITS NOT APPROVED BY THE BOARD AND PLACED ON-SITE ARE WORK WITHOUT APPROVAL AND THE BUILDING OFFICIAL IS TO PROCEED IN ACCORDANCE WITH SECTION 109.


THE BUILDING OFFICIAL IS TO NOTIFY THE BOARD OF AN VARIANCE OF FLOOR PLAN, EXTERIOR ELEVATIONS, AND EXPOSED DETAILS WITH THE PLANS APPROVED BY THE BOARD OR PLACEMENT OF A UNIT WITHOUT AN INSIGNIA.

OBC SECTION 113.1 INDUSTRIALIZED UNITS. REFER TO DIVISION 4101:10 OF THE ADMINISTRATIVE CODE FOR REQUIREMENTS OF INDUSTRIALIZED UNITS.


GENERAL NOTES

**MANUFACTURER SHALL PROVIDE OHIO P.E. STAMPED DRAWINGS OF THE BUILDING AND THE FOUNDATION.

- 1. CONCRETE: 5000 PSI @ 28 DAYS
- 2. AIR: 6% +/- 2%
- 3. REINFORCING: ASTM A615 GRADE 60
- 4. WALLS PRECAST CONCRETE ROOF PRECAST CONCRETE
- 6. FLOOR PRECAST CONCRETE
- 7. CONCRETE MIX DESIGN AND PLACEMENT PER ACI-318-14 8. MINIMUM REQUIRED FIRE SEPARATION IS 10'-0"
- 9. BUILDING SHALL NOT BE PLACED WITHIN 60'-0" OF AN UNLIMITED AREA
- 10. BUILDING IS A STAND ALONE STRUCTURE 11. EXTERIOR EGRESS COMPONENTS ARE TO BE SITE INSTALLED.
- 12. PROVIDE COMCHECK, OR STATE THAT IT WILL BE PROVIDED AS A PART OF
- THE IU DWGS.

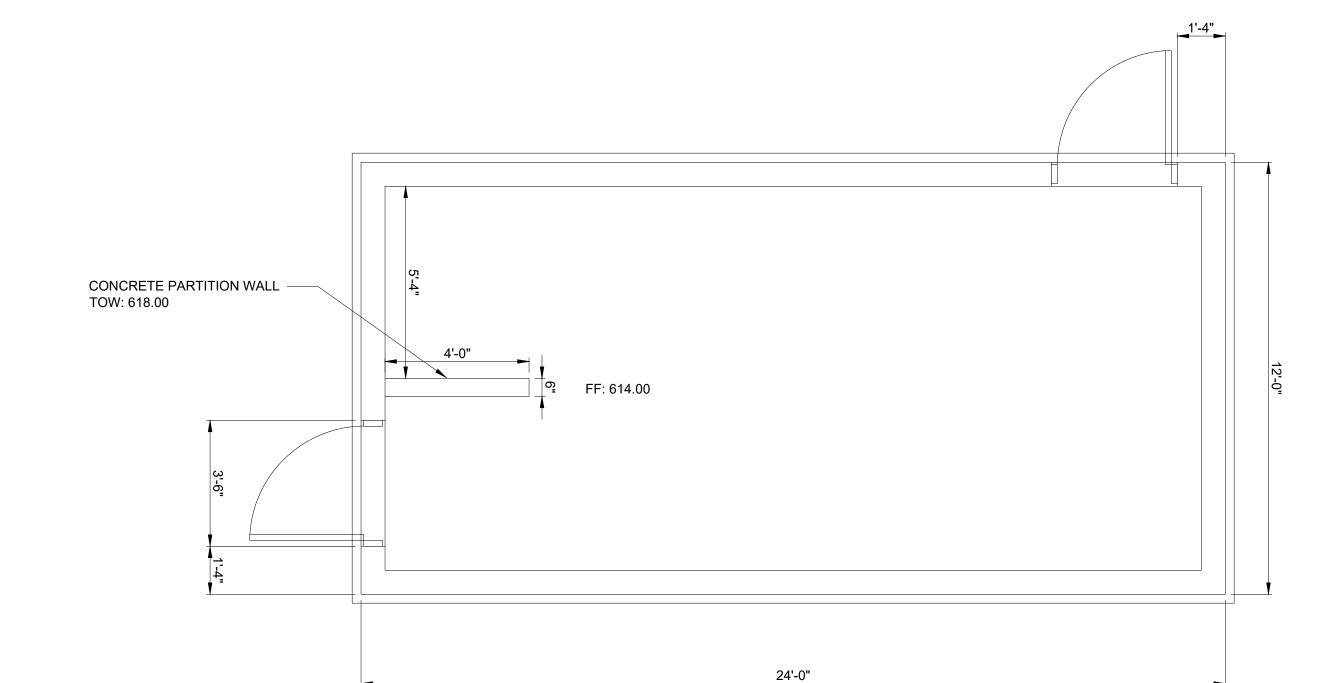

PLAN SCALE: 3/8" = 1'-0"

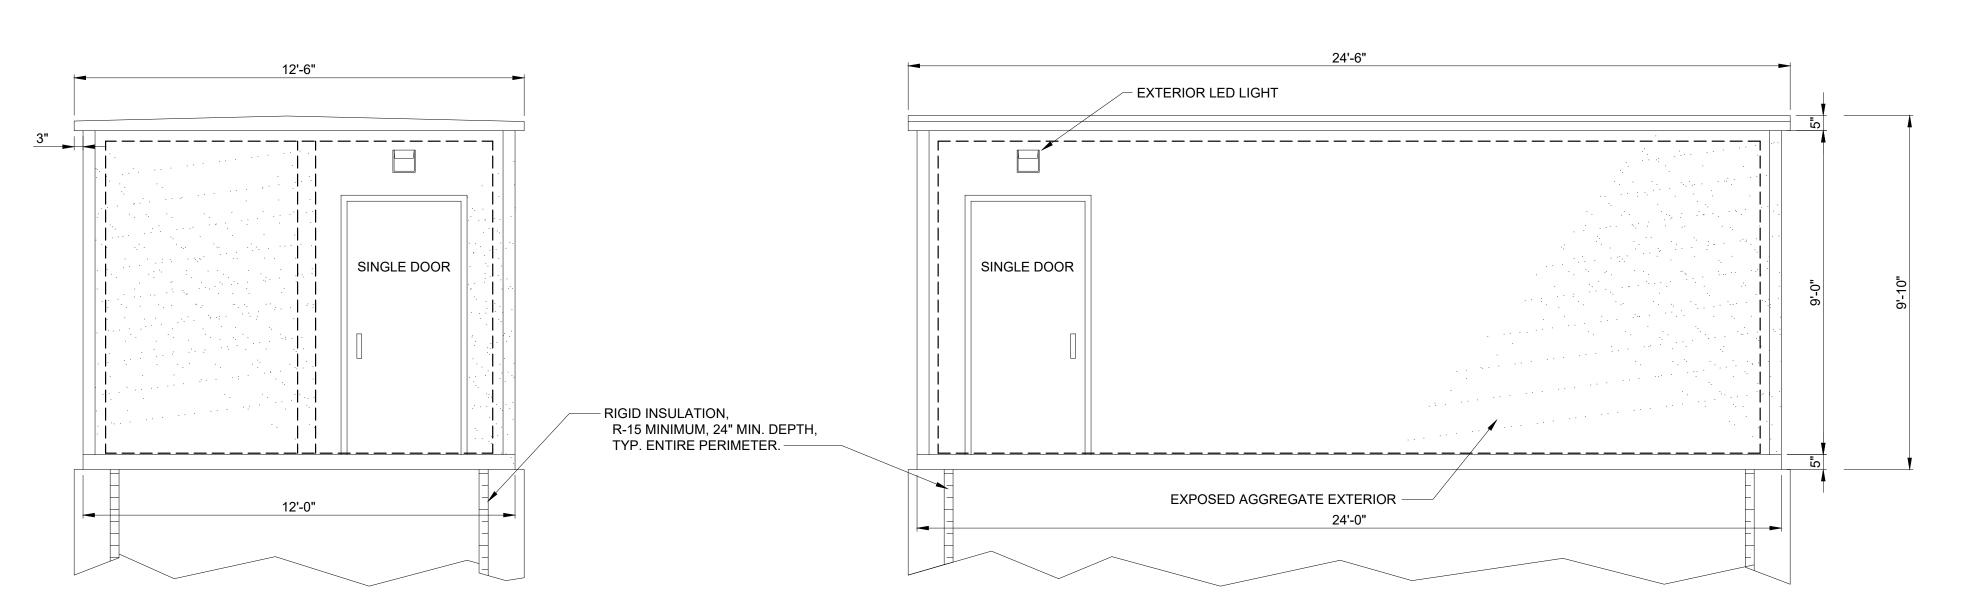

SIDE ELEVATION

SCALE: 3/8" = 1'-0"

FRONT ELEVATION

SCALE: 3/8" = 1'-0"



PROJECT NO.

230264 DISCIPLINE **ARCHITECTURAL**

SHEET NAME 20-A-01

PROJECT INFORMATION

CONSTRUCTION ACTIVITIES LOCATED AT:

LAKESHORE EAST EQ BASIN

FOREST DRIVE, CITY OF EASTLAKE, LAKE COUNTY, OHIO 44095 LATITUDE: 41.6775°N LONGITUDE: -81.4283°W

SWP3 PREPARED FOR:

CITY OF WILLOUGHBY, 1 PUBLIC SQUARE, WILLOUGHBY, OHIO 44095 CONTACT: RICH PALMISANO

EMAIL: RPALMISANO@WILLOUGHBYOHIO.COM

SWP3 PREPARED BY SITE-CIVIL ENGINEER: VERDANTAS LLC

8150 STERLING COURT, MENTOR, OHIO 44060

CONTACT: LENE C. HILL, PE PHONE: 440-951-9000

EMAIL: LHILL@VERDANTAS.COM

GENERAL CONTRACTOR INFORMATION:

BUSINESS NAME

STREET ADDRESS

STATE ZIP CODE CITY

PERSON RESPONSIBLE FOR AMENDING SWP3:

NAME

ESTIMATED PROJECT CONSTRUCTION START DATE

04/01/2026 ESTIMATED PROJECT CONSTRUCTION COMPLETION DATE: 12/01/2026

PHONE

DESCRIPTION OF PROJECT:

EMAIL

CONSTRUCTION OF A NEW EQ TANK, PUMP BUILDINGS WITH DRIVEWAYS, UTILITIES AND LANDSCAPING.

SOIL DISTURBING ACTIVITIES INCLUDE:

EROSION AND SEDIMENT CONTROL INSTALLATION; REMOVAL OF VEGETATION, TOPSOIL, EARTHWORK GRADING AND INSTALLATION OF NEW TANK, UTILITIES AND PAVEMENTS.

DESCRIPTION OF PRIOR AND EXISTING LAND USE: VACANT LOT WITH MOWED GRASS

SITE AREA INFORMATION:

_			
	TOTAL PROPERTY BOUNDARY AREA =	1.43	_ AC.
	CONSTRUCTION LIMIT AREA =	1.26	_ AC.
	TOTAL SOIL DISTURBANCE AREA =	1.26	_ AC.
	EXISTING IMPERVIOUS AREA =	0	_ AC.
	PROPOSED IMPERVIOUS AREA =	0.31	_ AC.
	INCREASE OR DECREASE IMPERVIOUS AREA =	25	_ %

NAME OF IMMEDIATE RECEIVING STREAM, SURFACE WATER OR MS4: CITY OF EASTLAKE MS4 TO THE CHAGRIN RIVER TO LAKE ERIE.


DESCRIPTION OF ON-SITE WETLANDS: THERE ARE NO WETLANDS ON-SITE.

DESCRIPTION OF QUALITY OF STORM WATER DISCHARGE FROM SITE: UNKNOWN

DESCRIPTION OF ON-SITE CONTAMINATED SOILS: THERE IS NO KNOWN OR PROBABLE CONTAMINATED SOIL.

SEQUENCE OF MAJOR CONSTRUCTION **ACTIVITIES**

- INSTALL SILT FENCE, FILTER SOCK, INLET PROTECTION AND CONSTRUCTION ENTRANCE.
- INSTALL OTHER TEMPORARY EROSION AND SEDIMENT CONTROL ITEMS AS SOON AS POSSIBLE, BUT NO LATER THAN 7 DAYS AFTER SOIL DISTURBANCE.
- INSPECT AND MAINTAIN BMPS FOR THE PROJECT DURATION UNTIL UPSLOPE AREAS ARE PERMANENTLY STABILIZED.
- BEGIN CLEARING AND GRUBBING.
- INSTALL DEWATERING MEASURES.
- BEGIN EXCAVATING, GRADING AND OTHER EARTHWORK OPERATIONS.
- APPLY TEMPORARY SEED.
- INSTALL UTILITIES AND EQ BASIN.
- INSTALL PAVING.
- 10. APPLY PERMANENT SEED.
- INSTALL LANDSCAPING.
- CONTINUE INSPECTIONS, MAINTENANCE, RECORD KEEPING, AND SITE POSTING UNTIL FINAL STABILIZATION ACHIEVED.
- REMOVE TEMPORARY BMPS.
- 14. DISPOSE OF ALL DEBRIS AND WASTE MATERIAL

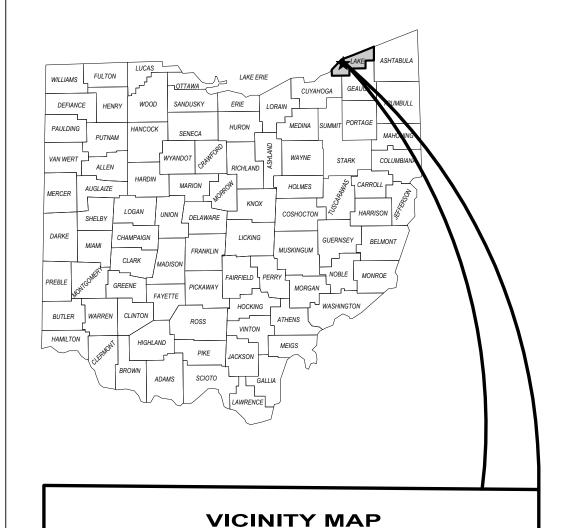

SCALE: 1" = 2,000' SITE MENTOR GARDEN ESTA

SOIL TYPES

SOIL ABBRV.	SOIL NAME	% AREA
CtB	CONNEAUT SILT LOAM	100%

GENERAL NOTES

- 1. THIS SWP3 HAS BEEN PREPARED SHOWING THE ITEMS LISTED BELOW, BUT THE CONTRACTOR MAY NEED TO MOVE OR ADD ITEMS AS CONSTRUCTION PROGRESSES OR DURING THE VARIOUS STAGES OF CONSTRUCTION. SOME SWP3 ITEMS MAY ALREADY BE SHOWN ON THE SWP3, BUT MOVED TO BETTER SUIT THE CONTRACTOR'S MEANS AND METHODS.
 - LIMITS OF EARTH DISTURBING ACTIVITY
 - CONSTRUCTION ENTRANCE
 - **EROSION AND SEDIMENT CONTROL MEASURES**
 - INLET PROTECTIONS
 - CONCRETE WASHOUT PITS
 - EQUIPMENT STAGING
 - FUEL STORAGE AND VEHICLE FUELING AREA
 - CONSTRUCTION TRAILER
 - SANITATION FACILITY
 - MATERIAL STOCKPILE LOCATION CHEMICAL COMPOUND MIXING AND STORAGE AREA
- ANY OTHER EROSION CONTROL REQUIRED
- ALL WORK REQUIRED TO IMPLEMENT THE SWP3 INCLUDING INSPECTION FEES, MAINTENANCE AND REPAIRS SHALL BE DONE BY AND AT THE EXPENSE OF THE CONTRACTOR.
- THE CONTRACTOR SHALL AMEND THE SWP3 WHEN THERE IS A CHANGE IN DESIGN, CONSTRUCTION, OPERATION OR MAINTENANCE THAT HAS A SIGNIFICANT POTENTIAL FOR DISCHARGE OF POLLUTANTS TO SURFACE WATERS OF THE STATE.
- ADDITIONAL OR DIFFERENT BMPS MAY BE NEEDED AS CONSTRUCTION PROGRESSES OR REQUIRED BY THE OWNER AND LAKE COUNTY SWCD.
- 5. NO CONDITION OF THE SWP3 PERMIT SHALL RELEASE THE CONTRACTOR OF THEIR RESPONSIBILITY OR REQUIREMENTS UNDER ANY OTHER ENVIRONMENTAL STATUE OR REGULATION.

ADMINISTRATIVE NOTES

- THE CONTRACTOR SHALL FOLLOW THE PRACTICES AND REQUIREMENTS PROVIDED IN THE OHIO EPA NPDES CONSTRUCTION SITE STORMWATER GENERAL PERMIT OHC000006, THE ODNR RAINWATER AND LAND DEVELOPMENT MANUAL AND THE CITY OF EASTLAKE ORDINANCE CHAPTER 906 SOIL SEDIMENT POLLUTION CONTROL
- ALL PROCEDURES AND REQUIREMENTS CONTAINED IN THE SWP3 APPLY TO ALL GENERAL AND SUBCONTRACTORS. THE CONTRACTOR SHALL IMPLEMENT, INFORM, REQUIRE AND ENFORCE ALL ASPECTS AND PROCEDURES OF THE SWP3.
- EROSION AND SEDIMENT CONTROL WORK SHALL BE SUBJECT TO INSPECTION BY THE OWNER'S REPRESENTATIVE AND LAKE COUNTY

MAINTENANCE REQUIREMENTS

- QUALIFIED INSPECTION PERSONNEL SHALL INSPECT BMPS AFTER ANY STORM EVENT GREATER THAN 1/2-INCH OF RAIN PER 24-HOUR PERIOD BY THE END OF THE NEXT CALENDAR DAY, EXCLUDING NON-WORKING WEEKENDS AND HOLIDAYS, AND AT LEAST EVERY 7 CALENDAR DAYS.
- INSPECTION FREQUENCY MAY BE REDUCED TO ONCE PER MONTH FOR DORMANT SITES IF THE ENTIRE SITE IS TEMPORARILY STABILIZED OR RUNOFF IS UNLIKELY DUE TO WINTER CONDITIONS FOR EXTENDED PERIODS OF TIME (I.E. SNOW COVER OR GROUND IS FROZEN). A WAIVER OF INSPECTION REQUIREMENTS IS AVAILABLE UNTIL 1 MONTH BEFORE THAWING CONDITIONS ARE EXPECTED IF ALL THE FOLLOWING CONDITIONS ARE MET:
- FROZEN CONDITIONS ARE ANTICIPATED TO CONTINUE FOR EXTENDED PERIODS OF TIME (I.E. MORE THAN 1 MONTH).
- SOIL DISTURBANCE ACTIVITIES HAVE BEEN SUSPENDED.
- BEGINNING AND ENDING DATES OF THE WAIVER PERIOD ARE DOCUMENTED IN THE SWP3.
- AREAS TO BE INSPECTED SHALL INCLUDE DISTURBED AREAS, BMPS EROSION AND SEDIMENT CONTROLS, DISCHARGE LOCATIONS, MATERIAL STORAGE AREAS, VEHICLE ENTRANCE/EXIT LOCATIONS, ETC.
- ANY NON-COMPLIANCE INCIDENCES SHALL BE IDENTIFIED AND MAINTENANCE OR REPAIR MUST BE COMPLETED WITHIN 3 DAYS, AND SEDIMENT POND MAINTENANCE OR REPAIR WITHIN 10 DAYS, OF THE
- WHEN AN INSPECTION REVEALS A BMP IS NOT EFFECTIVE AND A MORE APPROPRIATE BMP IS REQUIRED, THE ABBREVIATED SWP3 SHALL BE AMENDED AND THE NEW BMP INSTALLED WITHIN 10 DAYS OF THE
- WHEN AN INSPECTION REVEALS A REQUIRED BMP HAS NOT BEEN INSTALLED, THE BMP MUST BE INSTALLED PRIOR TO THE NEXT STORM EVENT OR WITHIN 10 DAYS FROM THE INSPECTION.
- IF AN INSPECTION REVEALS A REQUIRED BMP IS NOT NEEDED, THE RECORD SHALL CONTAIN AN EXPLANATION AS TO WHY NOT.
- BMPS SHALL BE MAINTAINED IN GOOD WORKING ORDER UNTIL ALL UPSLOPE AREAS THEY CONTROL ARE STABILIZED.
- 10. ONCE A DEFINABLE AREA HAS BEEN FULLY STABILIZED, IT MAY BE MARKED ON THE SWP3 AND NO FURTHER INSPECTION REQUIREMENTS ARE REQUIRED FOR THAT AREA OF THE SITE.

SWP3 CERTIFICATION STATEMENT

I CERTIFY UNDER PENALTY OF LAW THAT THIS DOCUMENT AND ALL ATTACHMENTS WERE PREPARED UNDER MY DIRECTION OR SUPERVISION IN ACCORDANCE WITH A SYSTEM DESIGNED TO ASSURE THAT QUALIFIED PERSONNEL PROPERLY GATHERED AND EVALUATED THE INFORMATION SUBMITTED. BASED ON MY INQUIRY OF THE PERSON OR PERSONS WHO MANAGE THE SYSTEM OR THOSE PERSONS DIRECTLY RESPONSIBLE FOR GATHERING THE INFORMATION. THE INFORMATION SUBMITTED IS, TO THE BEST OF MY KNOWLEDGE AND BELIEF, TRUE, ACCURATE AND COMPLETE. I AM AWARE THAT THERE ARE SIGNIFICANT PENALTIES FOR SUBMITTING FALSE INFORMATION, INCLUDING THE POSSIBILITY OF FINE AND IMPRISONMENT FOR KNOWING VIOLATIONS.

C:\Users\LeneHill\OneDrive - Verdantas\Pictures\signature.jp

CONTRACTOR:

LENE HILL, PE (PREPARED SWP3) SENIOR PROJECT MANAGER DESIGN ENGINEER: VERDANTAS LLC	DATE
FIRST & LAST NAME (NPDES PERMITTEE) TITLE: OWNER: CITY OF WILLOUGHBY	DATE
NAME (IMPLEMENT SWP3) TITLE	DATE

10/01/2025

GOOD HOUSEKEEPING AND OTHER WASTE CONTROL NOTES

MATERIALS OR SUBSTANCES LISTED BELOW ARE ANTICIPATED TO BE PRESENT ON-SITE DURING CONSTRUCTION:

> (X) CONCRETE (X) FERTILIZER (X) CLEANING SOLVENT () ASPHALT (X) DETERGENT

(X) PETROLEUM BASED PRODUCT (X) CMU BLOCK (X) PAINT

- STORE ONLY ENOUGH PRODUCT REQUIRED TO DO THE JOB. ALL MATERIALS STORED ON-SITE SHALL BE STORED IN AN ORDERLY MANNER IN APPROPRIATE CONTAINERS AND, IF POSSIBLE, UNDER A ROOF OR OTHER ENCLOSURE.
- PRODUCTS SHALL BE KEPT IN ORIGINAL CONTAINERS WITH THE ORIGINAL MANUFACTURER LABEL UNLESS NOT RESEALABLE. PETROLEUM PRODUCTS SHALL BE STORED IN TIGHTLY SEALED CONTAINERS AND CLEARLY LABELED.
- ALL OF A PRODUCT SHALL BE USED BEFORE DISPOSING OF THE CONTAINER WHENEVER POSSIBLE. DO NOT MIX PRODUCTS WITH ONE
- ANOTHER UNLESS RECOMMENDED BY THE MANUFACTURER. DAILY INSPECTION SHALL OCCUR TO ENSURE PROPER USE AND
- SAFETY DATA SHEETS (SDS) SHALL BE KEPT ON-SITE.
- 7. SPILL CONTROL PRACTICES:

DISPOSAL OF MATERIALS.

- A. MANUFACTURER RECOMMENDED METHODS FOR SPILL CLEANUP MUST BE POSTED AND SITE PERSONNEL MADE AWARE OF THE PROCEDURES, LOCATION OF THE INFORMATION AND LOCATION OF CLEANUP SUPPLIES.
- SPILL CLEANUP SUPPLIES (I.E. DUST PANS, BROOMS, MOPS, RAGS, GLOVES, GOGGLES, TRASH CONTAINERS, ETC.) AND MATERIALS (I.E. SAWDUST, KITTY LITTER, SAND, ABSORBENT MATERIAL, ETC.) SHALL BE KEPT IN AN ON-SITE MATERIAL STORAGE AREA.
- C. SPILLS SHALL BE CLEANED IMMEDIATELY AFTER DISCOVERY AND PERSONNEL SHALL WEAR APPROPRIATE PROTECTIVE CLOTHING. SMALL PETROLEUM PRODUCT SPILLS (LESS THAN 25 GALLONS) SHALL BE CLEANED PER MANUFACTURER RECOMMENDED METHODS AND DISPOSED WITH THE TRASH. LARGE PETROLEUM PRODUCT SPILLS (25 OR MORE GALLONS) OR ANY TOXIC OR HAZARDOUS MATERIAL SPILL, REGARDLESS OF SIZE, MUST BE REPORTED TO THE APPROPRIATE FEDERAL GOVERNMENT AGENCY, OHIO EPA SPILL HOTLINE (800-282-9378), LOCAL FIRE DEPARTMENT AND LOCAL EMERGENCY PLANNING COMMITTEE (LEPC) WITHIN 30 MINUTES OF THE SPILL. SPILLS THAT RESULT IN CONTACT WITH WATERS OF THE STATE, REGARDLESS OF SIZE OR TYPE, MUST BE REPORTED TO THE OHIO EPA SPILL HOTLINE.
- D. ON-SITE VEHICLES SHALL BE MONITORED FOR LEAKS AND RECEIVE REGULAR PREVENTIVE MAINTENANCE TO REDUCE THE CHANCE OF LEAKAGE
- 8. IT IS PROHIBITED TO BURN, BURY OR POUR ONTO THE GROUND OR INTO STORM INLETS OR SURFACE WATERS OF THE STATE ANY LIQUID OR SOLID WASTE (I.E. CONSTRUCTION AND DEMOLITION DEBRIS (C&DD), TRASH, BUILDING MATERIALS, SOLVENTS, PAINTS, FUELS, MOTOR OIL, ANTIFREEZE, HYDRAULIC FLUIDS, CURING COMPOUNDS, FORM RELEASE OILS, OTHER TOXIC OR HAZARDOUS WASTE, ETC.)
- TRASH AND C&DD SHALL BE COLLECTED IN A SECURELY LIDDED AND LEAK-PROOF DUMPSTER, HAULED OFF-SITE AND EMPTIED AS NECESSARY, AND DISPOSED IN AN OHIO EPA APPROVED LANDFILL. ALL OTHER WASTE MATERIALS SHALL BE DISPOSED IN ACCORDANCE WITH FEDERAL, STATE AND LOCAL REGULATIONS OR AS SPECIFIED BY THE MANUFACTURER.
- CONTAMINATED SOILS MUST BE TREATED AND/OR DISPOSED IN AN OHIO EPA APPROVED SOLID WASTE MANAGEMENT FACILITY OR HAZARDOUS WASTE TREATMENT, STORAGE OR DISPOSAL FACILITY. THE FOLLOWING PRACTICES SHALL BE USED AS APPROPRIATE TO PREVENT CONTAMINATION FROM SPREADING:
 - A. BERMS, TRENCHES AND PITS TO COLLECT CONTAMINATED
 - B. RUNOFF PUMPED INTO A CONTAINER FOR TRANSPORT TO A
 - CONTAMINATED AREA COVERED WITH TARPS OR OTHER METHODS THAT PREVENT STORM WATER CONTACT.
- 11. FUEL STORAGE TANKS SHALL BE STORED IN DIKED AREAS WITH A VOLUME OF AT LEAST 110% OF THE LARGEST TANK. A DIKED AREA IS NOT NECESSARY IF A SELF-CONTAINED SPILL PROOF TANK IS USED. AREAS USED FOR FUEL STORAGE TANK STORAGE, FUELING OR VEHICLE MAINTENANCE SHALL NOT BE LOCATED NEAR STORM INLETS, WATERCOURSES OR SURFACE WATERS OF THE STATE.
- 12. APPLY FERTILIZER ONLY IN THE MINIMUM AMOUNTS RECOMMENDED BY THE MANUFACTURER. ONCE APPLIED, FERTILIZER SHALL BE WORKED INTO THE SOIL TO LIMIT EXPOSURE TO STORM WATER. CONTENTS OF PARTIALLY USED BAGS OF FERTILIZER SHALL BE TRANSFERRED TO A SEALABLE PLASTIC BIN TO AVOID SPILLS.
- 13. CONCRETE TRUCKS ARE PROHIBITED TO WASH OUT OR DISCHARGE SURPLUS CONCRETE OR DRUM WASH WATER ONTO THE GROUND OR INTO STORM INLETS OR SURFACE WATERS OF THE STATE. ALL EXCESS CONCRETE AND WASHOUT, INCLUDING FROM HAND MIXERS AND LIGHT EQUIPMENT, MUST BE DISPOSED IN A CONCRETE WASHOUT AREA.
- 14. TEMPORARY SANITARY FACILITIES SHALL BE PROVIDED ON-SITE, SERVICED BY A LICENSED SANITARY WASTE MANAGEMENT CONTRACTOR, AND COLLECTED AT LEAST ONCE PER WEEK.
- 15. OFF-SITE VEHICLE TRACKING OF SEDIMENT AND DUST SHALL BE MINIMIZED. ADJACENT OFF-SITE PAVED STREETS SHALL BE SWEPT DAILY, OR MORE OFTEN AS NECESSARY, TO REMOVE MUD, DIRT OR ROCK TRACKED FROM THE SITE. DUST CONTROL SHALL BE PROVIDED WITH WATER OR CALCIUM CHLORIDE DUST PALLIATIVE AS NECESSARY. USED OIL MAY NOT BE USED. DUMP TRUCKS HAULING MATERIAL OFF-SITE MUST BE COVERED WITH A TARPAULIN.

EROSION & SEDIMENT CONTROL

SPECIAL MEASURES SHALL BE TAKEN TO STABILIZE DRAINAGE

- CHANNELS AND STORM WATER OUTFALLS. 2. PHASE CONSTRUCTION ACTIVITIES TO MINIMIZE LAND DISTURBED AT
- ANY ONE TIME AND LEAVE EXISTING VEGETATION IN PLACE AS LONG AS POSSIBLE.
- STORMWATER DIVERSION PRACTICES SHALL BE USED TO KEEP SURFACE RUNOFF AWAY FROM DISTURBED AREAS AND STEEP SLOPES WHERE PRACTICABLE.
- 4. STABILIZATION OF DISTURBED AREAS SHALL, AT A MINIMUM, BE INITIATED WITHIN THE TIME FRAMES IN THE FOLLOWING TABLES:

PERMANENT STABILIZATION

AREA REQUIRING PERMANENT STABILIZATION	TIME FRAME TO APPLY EROSION CONTROLS
ANY AREAS TO LIE DORMANT FOR 1 YEAR OR MORE.	WITHIN 7 DAYS OF MOST RECENT DISTURBANCE.
ANY AREAS WITHIN 50 FEET OF A SURFACE WATER OF THE STATE (*) AND AT FINAL GRADE.	WITHIN 2 DAYS OF REACHING FINAL GRADE.
OTHER AREAS AT FINAL GRADE.	WITHIN 7 DAYS OF REACHING FINAL GRADE.
	PERMANENT STABILIZATION ANY AREAS TO LIE DORMANT FOR 1 YEAR OR MORE. ANY AREAS WITHIN 50 FEET OF A SURFACE WATER OF THE STATE (*) AND AT FINAL GRADE.

AREA REQUIRING TIME FRAME TO APPLY TEMPORARY STABILIZATION EROSION CONTROLS ANY DISTURBED AREAS WITHIN WITHIN 2 DAYS OF MOST

TEMPORARY STABILIZATION

RECENT DISTURBANCE IF TO 50 FEET OF A SURFACE WATER OF THE STATE (*) AND NOT AT REMAIN IDLE MORE THAN 14 FINAL GRADE. ANY DISTURBED AREAS TO BE WITHIN 7 DAYS OF MOST RECENT DISTURBANCE. DORMANT FOR MORE THAN 14 DAYS, BUT LESS THAN 1 YEAR, AND NOT WITHIN 50 FEET OF A FOR RESIDENTIAL SUBDIVISION,

SURFACE WATER OF THE

DISTURBED AREAS THAT WILL

BE IDLE OVER WINTER.

STATE (*).

PRIOR TO TRANSFER OF PERMIT COVERAGE FOR INDIVIDUAL LOT(S).

WEATHER.

DISTURBED AREAS MUST BE

STABILIZED AT LEAST 7 DAYS

PRIOR TO ONSET OF WINTER

(*) SURFACE WATERS OF THE STATE INCLUDE WETLANDS, STREAMS, LAKES, PONDS, MARSHES, WATERCOURSES, WELLS, SPRINGS, IRRIGATION SYSTEMS, DRAINAGE SYSTEMS, AND OTHER ACCUMULATIONS OF WATER, SURFACE AND UNDERGROUND, NATURAL OR ARTIFICIAL.

- INLET PROTECTION AND SEDIMENT CONTROLS MUST BE INSTALLED PRIOR TO CLEARING AND GRUBBING.
- SEDIMENT PONDS, TEMPORARILY MODIFIED PERMANENT PONDS AND PERIMETER SEDIMENT BARRIERS MUST BE INSTALLED AS THE FIRST STEP OF GRADING AND WITHIN 7 DAYS FROM THE START OF CLEARING AND GRUBBING, AND CONTINUE TO FUNCTION UNTIL ALL DISTURBED UPLAND AREAS ARE STABILIZED.
- 7. SEDIMENT CONTROLS MUST POND RUNOFF TO BE CONSIDERED FUNCTIONAL.
- 8. SEDIMENT-LADEN TRENCH OR GROUND WATER MUST PASS THROUGH A SEDIMENT-SETTLING POND OR BE DEWATERED IN-PLACE USING A SUMP PIT. FILTER BAG OR OTHER COMPARABLE METHOD PRIOR TO DISCHARGE FROM THE SITE. TRENCH AND GROUND WATER FREE FROM SEDIMENT OR OTHER POLLUTANTS MAY BE DISCHARGED WITHOUT TREATMENT. PROVIDED THIS WATER DOES NOT BECOME POLLUTANT-LADEN BY TRAVERSING OVER DISTURBED SOILS OR
- OTHER POLLUTANT SOURCES. SEDIMENT BARRIERS SHALL NOT EXCEED THEIR DESIGN CAPACITIES. INSTALLING SEDIMENT BARRIERS IN PARALLEL SERIES DOES NOT INCREASE THE DESIGN CAPACITY.
- 10. SETTLED MATERIAL SHALL BE DISPOSED IN A LOCATION WHERE IT WILL NOT BE CARRIED OFF-SITE OR INTO A STORM SEWER BY RAINFALL.
- 11. SOIL STOCKPILES SHALL BE RINGED WITH SILT FENCE ALONG THE BOTTOM FOOTPRINT. IF THE STOCKPILE WILL BE INACTIVE FOR 14 DAYS OR MORE, THE SURFACE SHALL BE SEEDED OR STABILIZED WITHIN 7 DAYS OF LAST DISTURBANCE.

EROSION CONTROL TIMETABLE

DESCRIPTION					CAL	END	AR Y	EAR				
STABILIZATION TYPE	J	F	М	Α	М	J	J	Α	S	0	Ν	D
TEMPORARY SEEDING			0	0	8	8	8	8	0	0		
PERMANENT SEEDING				0	8	8	8	8	0	0		
MATTING	0	0	0	0	0	0	0	0	0	0	0	0
SODDING			8	8	8	8	8	8	8	8		
MULCHING	0	0	0	0	0	0	0	0	0	0	0	0
PAVING					0	0	0	0	0	0	0	

⊗ IRRIGATION NEEDED

E-66017

m m

PROJECT NO. 230264

DISCIPLINE **EROSION** SHEET NAME

30C-01 48 31


1:\2023\230264\DWG\SHEETS\PHASE |I\C_230264 - SWPPP DETAILS AND NOTES.DWG - 31 SWPPP COVER - 10/1/2025 8:06:11 AM - CORY SCOT

ADMINISTRATIVE NOTES


- 1. AN OHIO EPA NPDES PERMIT IS REQUIRED WHERE CONSTRUCTION ACTIVITIES (I.E. CLEARING, GRUBBING, GRADING, EXCAVATING, FILLING AND/OR TRENCH DEWATERING) AND/OR SUPPORT ACTIVITIES (I.E. CONCRETE OR ASPHALT BATCH PLANT, EQUIPMENT STAGING YARD, MATERIAL STORAGE AREA, AND ON-SITE OR OFF-SITE BORROW AREA OR SOIL DISPOSAL AREA) DISTURB 1 OR MORE ACRES OF LAND, OR SMALLER SITES LESS THAN 1 ACRE THAT ARE PART OF A LARGER COMMON DEVELOPMENT. DISTURBED LAND IS LAND IN WHICH SOILS ARE EXPOSED TO STORM WATER.
- 2. A NOI IS REQUIRED FOR THIS PROJECT AND MUST BE FILED WITH THE OHIO EPA AT LEAST 21 DAYS PRIOR TO THE START OF CONSTRUCTION BECAUSE THE TOTAL LAND DISTURBANCE IS GREATER THAN 1 ACRE
- 3. THE CONTRACTOR SHALL FOLLOW THE PRACTICES AND REQUIREMENTS PROVIDED IN THE OHIO EPA NPDES CONSTRUCTION SITE STORMWATER GENERAL PERMIT OHC000006 AND THE ODNR RAINWATER AND LAND DEVELOPMENT MANUAL, AND BE RESPONSIBLE FOR ALL NPDES TERMS AND CONDITIONS UNTIL A NOT IS FILED.
- 4. NO CONSTRUCTION ACTIVITIES MAY BEGIN UNTIL ALL OF THE FOLLOWING OCCUR:
 - OHIO EPA NPDES AUTHORIZATION LETTER RECEIVED.
 - THE CONTRACTOR FILES A CO-PERMITTEE APPLICATION TO THE OHIO EPA.
 - THE CONTRACTOR ATTENDS A PRE-CONSTRUCTION MEETING WITH THE SWCD TO DISCUSS OHIO EPA NPDES PERMIT REQUIREMENTS.
- 5. OHIO EPA APPLICATION FORMS (I.E. NOI, NOT, CO-PERMITTEE NOI/NOT, INDIVIDUAL LOT NOI/NOT AND PERMIT TRANSFER) ARE ONLY ACCESSIBLE ELECTRONICALLY VIA THE OHIO EPA STREAMS APPLICATION SUBMITTAL SYSTEM USING AN INDIVIDUAL EBUSINESS CENTER ACCOUNT. VISIT THE OHIO EPA'S ELECTRONIC BUSINESS SERVICES WEBSITE (HTTPS://EBIZ.EPA.OHIO.GOV/) FOR MORE INFORMATION, GUIDANCE AND REPORTING QUESTIONS.
- 6. THE CONTRACTOR SHALL SELECT QUALIFIED INSPECTION PERSONNEL KNOWLEDGEABLE IN THE PRINCIPLES AND PRACTICES OF EROSION AND SEDIMENT CONTROLS FOR INSPECTIONS, MAINTENANCE, REPAIRS, AND COMPLETING INSPECTION AND MAINTENANCE REPORTS. THE CONTRACTOR SHALL COMPLETE A "DELEGATION OF AUTHORITY FOR STORMWATER POLLUTION PREVENTION PLAN".
- 7. ALL PROCEDURES AND REQUIREMENTS CONTAINED IN THE SWP3 APPLY TO ALL GENERAL AND SUBCONTRACTORS. THE CONTRACTOR SHALL IMPLEMENT, INFORM, REQUIRE AND ENFORCE ALL ASPECTS AND PROCEDURES OF THE SWP3. THE CONTRACTOR SHALL HAVE ALL SUBCONTRACTORS THAT ARE OR MAY BE ENGAGED IN ACTIVITIES THAT COULD IMPACT STORMWATER COMPLETE A "SUBCONTRACTOR AGREEMENT FOR EROSION AND SEDIMENT CONTROL" TO ACKNOWLEDGE THEY REVIEWED AND UNDERSTOOD THE SWP3.
- 8. ALL NPDES PERMITS, NOI, SWP3, INSPECTION LOGS, REPORTS AND CERTIFICATIONS MUST BE SIGNED, KEPT ON-SITE AND IMMEDIATELY AVAILABLE UPON REQUEST BY THE OWNER, SWCD, MS4 OR OHIO EPA.
- 9. EROSION AND SEDIMENT CONTROL WORK SHALL BE SUBJECT TO INSPECTION BY THE OWNER, SWCD, MS4 AND OHIO EPA.

PERMIT CLOSURE REQUIREMENTS

- 1. FINAL STABILIZATION MEANS ALL THE FOLLOWING HAVE OCCURRED:
 - A. SOIL DISTURBING ACTIVITIES HAVE BEEN COMPLETED.
 - B. ALL TEMPORARY EROSION AND SEDIMENT CONTROLS HAVE BEEN REMOVED, DISPOSED OFF-SITE AND SEDIMENT TRAPPED BY THOSE CONTROLS IS PERMANENTLY STABILIZED.
 - C. A UNIFORM PERENNIAL VEGETATIVE COVER (I.E. EVENLY DISTRIBUTED WITHOUT LARGE BARE AREAS) WITH A DENSITY OF AT LEAST 70% COVER HAS BEEN ESTABLISHED ON ALL UNPAVED AREAS AND AREAS NOT COVERED BY PERMANENT STRUCTURES.
- 2. ONCE THE SITE REACHES FINAL STABILIZATION, THE CONTRACTOR MUST COMPLETE A "FINAL CERTIFICATION AND NOTIFICATION FOR EROSION AND SEDIMENT CONTROL" AND FILE A NOT WITH THE OHIO EPA WITHIN 45 DAYS TO TERMINATE NPDES PERMIT COVERAGE.
- 3. THE CONTRACTOR SHALL MAINTAIN ALL NPDES PERMITS, NOI, NOT, SWP3, INSPECTION LOGS, REPORTS AND CERTIFICATIONS FOR 3 YEARS AFTER THE NOT IS FILED, AND PROVIDE DIGITAL COPIES TO THE OWNER FOR THE SAME RECORD KEEPING REQUIREMENT.

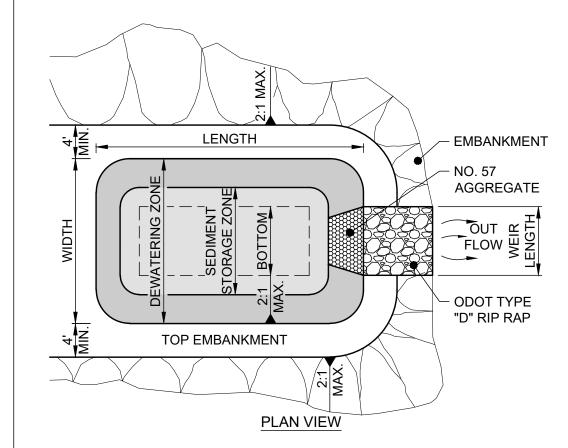

DRAINAGE AREA	WEIR LENGTH
≤ 1 AC.	4 FT.
≤ 2 AC.	6 FT.
≤ 3 AC.	8 FT.
≤ 4 AC.	10 FT.
<u><</u> 5 AC.	12 FT.

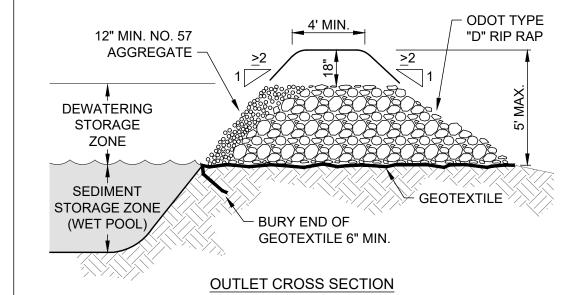

NOTES:

IS REMOVED.

- 1. WORK SHALL CONSIST OF INSTALLATION, MAINTENANCE AND REMOVAL OF SEDIMENT TRAP.
- 2. SEDIMENT TRAP MUST BE CONSTRUCTED AND OPERATIONAL PRIOR TO UPSLOPE LAND DISTURBANCE.
- 3. THE AREA BENEATH THE EMBANKMENT SHALL BE CLEARED, GRUBBED AND STRIPPED OF VEGETATION TO A MINIMUM DEPTH OF 6". THE POOL SHALL BE CLEARED AS NEEDED TO FACILITATE SEDIMENT CLEANOUT.
- 4. EMBANKMENT FILL SHALL BE FREE OF ROOTS OR OTHER WOODY VEGETATION, LARGE ROCKS, ORGANICS OR OTHER OBJECTIONABLE MATERIALS. FILL MATERIAL SHALL BE PLACED IN 6" LIFTS AND COMPACTED. CONSTRUCTION SHALL NOT BE PERMITTED IF THE FILL OR COMPACTION SURFACE IS FROZEN.
- 5. DIKES DIRECTING WATER TO THE TRAP SHALL BE HIGHER THAN THE HEIGHT OF THE EMBANKMENT.
- 6. 67 C.Y. OF STORAGE VOLUME IS REQUIRED BELOW THE OUTLET CREST FOR EACH 1 AC. OF CONTRIBUTING DRAINAGE AREA. THIS STORAGE VOLUME IS ACHIEVED BY THE DIMENSIONS SHOWN ON THE PLANS.
- 7. ESTABLISH TEMPORARY SEEDING ON ALL NON-SUBMERGED AREAS AND MAINTAIN OVER THE LIFE OF THE SEDIMENT TRAP.
- WHERE GEOTEXTILE IS USED, OVERLAPS SHALL BE 2' MINIMUM WITH THE UPPER MOST LAYER PLACED LAST.
- WARNING SIGNS AND SAFETY FENCE SHALL BE PLACED AROUND THE ENTIRE SEDIMENT TRAP AND MAINTAINED UNTIL THE SEDIMENT TRAP
- 10. REMOVE SEDIMENT AND RESTORE THE SEDIMENT TRAP TO ITS ORIGINAL DIMENSIONS WHEN SEDIMENT HAS FILLED 40% OF THE TRAP'S ORIGINAL DEPTH. SPREAD REMOVED SEDIMENT IN A SUITABLE AREA AND STABILIZED SO IT WILL NOT ERODE.
- 11. AFTER UPSLOPE SEDIMENT PRODUCING AREAS HAVE BEEN PERMANENTLY STABILIZED, THE SEDIMENT TRAP AND ALL SEDIMENT SHALL BE REMOVED, BACKFILLED AND SEEDED.

SEDIMENT TRAP DETAIL

SCALE: NONE

WATER QUALITY VOLUME (WQv)

TYPE OF CONSTRUCTION:

(X) NEW () REDEVELOPMENT

TYPE OF EXTENDED DETENTION POST-CONSTRUCTION PRACTICE:

(X) DRY EXTENDED DETENTION BASIN WITH FOREBAY & MICROPOOL

PER OHIO EPA NPDES CGP #OHC000006, WATER QUALITY VOLUME FOR POST-CONSTRUCTION BMPS SHALL BE DETERMINED USING EQUATIONS:

WQv = Rv * P * A_{TOT} / 12 Rv = 0.05 + (0.9 * i)

STEP 1: DETERMINE POST-VOLUMETRIC RUNOFF COEFFICIENT

 $A_{TOT} = 1.26 \text{ AC}$ $A_{IMP} = 0.31 \text{ AC}$

 $i = A_{IMP} / A_{TOTAL}$

= <u>0.31</u> AC / <u>1.26</u> AC = <u>0.25</u>

v = 0.05 + (0.9 * I)

= 0.05 + [0.9 * <u>0.25</u>] = <u>0.27</u>

STEP 2: DETERMINE WATER QUALITY VOLUME

WQv = Rv * P * A_{TOT} / 12 = 0.27 * 0.90 IN * [(1.26 AC) / (12 IN/FT)]

= 0.026 AC-FT = 1,117 CF

STEP 3: DETERMINE SEDIMENT STORAGE VOLUME

V_{SED} = 0.20 * WQv = 0.20 * 1,117 CF = 223 CF

STEP 4: DETERMINE TOTAL WATER QUALITY VOLUME

 $WQv_{TOT} = WQv + V_{SED}$

= <u>1,117</u> CF + <u>223</u> CF = <u>1,340</u> CF

STEP 5: DETERMINE FOREBAY VOLUME

V_{FORE} = 0.10 * WQv = 0.10 * <u>1,117</u> CF = <u>112</u> CF

STEP 6: DETERMINE MICROPOOL VOLUME

 V_{MICRO} = 0.10 * WQv = 0.10 * 1,117 CF = 112 CF

STEP 7: DETERMINE WATER QUALITY VOLUME AVERAGE RELEASE RATE

 $Q_{AVG} = WQv_{TOT} / t_D$

= <u>1,117</u> CF / [(<u>48</u> HR) * (3,600 S/HR)]

= <u>0.01</u> CFS

STEP 8: ESTIMATE OUTLET ORIFICE AREA

 $H_{AVG} = H_{MAX} / 2$ = 0.57 FT / 2

= <u>0.28</u> FT C = 0.6 (SHARP-EDGE ORIFICE)

 $A_{ORIF} = Q_{AVG} / [C * (2 * g * H_{AVG})^{0.5}]$

= $(0.01 \text{ CFS}) / [0.6 * (2 * 32.2 \text{ FT/S}^2 * 0.28 \text{ FT})^{0.5}]$

= 0.003 SF = 0.36 SQ IN

STEP 9: DETERMINE ORIFICE DIMENSIONS FOR CIRCULAR ORIFICE: $D_{ORIF} = [(4 * A_{ORIF}) / \pi]^{0.5}$

= [(4 * <u>0.38</u> SF) / 3.14159] ^{0.5}

= <u>0.06</u> FT = 0.68 IN

USE $D_{ORIF} = \underline{0.70} IN$

WHERE:

= IMPERVIOUS AREA DRAINING INTO BMP (AC)

A_{ORIF} = ORIFICE AREA (SF)

 A_{TOT} = TOTAL AREA DRAINING INTO BMP (AC)

= COEFFICIENT OF DISCHARGE = ORIFICE DIAMETER (IN)

g = ACCELERATION OF GRAVITY (32.2 FT/S^2)

= H_{MAX} / 2 = AVERAGE HYDRAULIC HEAD (FT)

H_{MAX} = (BRIMFUL WQV ELEVATION) - (WQV OUTLET ELEVATION) = FRACTION OF POST-CONSTRUCTION IMPERVIOUS AREA

i = FRACTION OF POST-CON i = IMPERVIOUS FRACTION

= PRECIPITATION DEPTH (0.90 IN)

Q_{AVG} = AVERAGE DISCHARGE RATE (CFS) Rv = VOLUMETRIC RUNOFF COEFFICIENT

= MINIMUM DRAIN TIME (HR)

 V_{FORE} = FOREBAY VOLUME (CF)

icro = MICROPOOL VOLUME (CF)

= SEDIMENT STORAGE VOLUME

V_{SED} = SEDIMENT STORAGE VOLUME (CF) WQv = WATER QUALITY VOLUME (AC-FT)

/Qv_{TOT} = TOTAL WATER QUALITY VOLUME WITH 20% SEDIMENT (AC-FT)



TTASS

8150 STERLING COU

LOUGHBY		115,15,0	2	
AST EO BASIN	ISSUE DATE:	10/3/2025		
	SCALE:	AS NOTED		
WILLOUGHBY, OHIO	DESIGNED BY:	ГСН		
ILS - SD SERIES	DRAWN BY:	ГСН		
AND CALCS	CHECKED BY:	RSS		

CITY OF WILLOUGHBY
AKESHORE EAST EQ BAS
PHASE II

PROJECT NO.

230264


DISCIPLINE


SHEET NAME

30C-02

32 48

H:\2023\230264\DWG\SHEETS\PHASE II\C_230264 - SWPPP DETAILS AND NOTES.DWG - 32 SWPPP NOTES AND CALCS - 10/1/2025 8:06:11 AM - CORY SCOTT

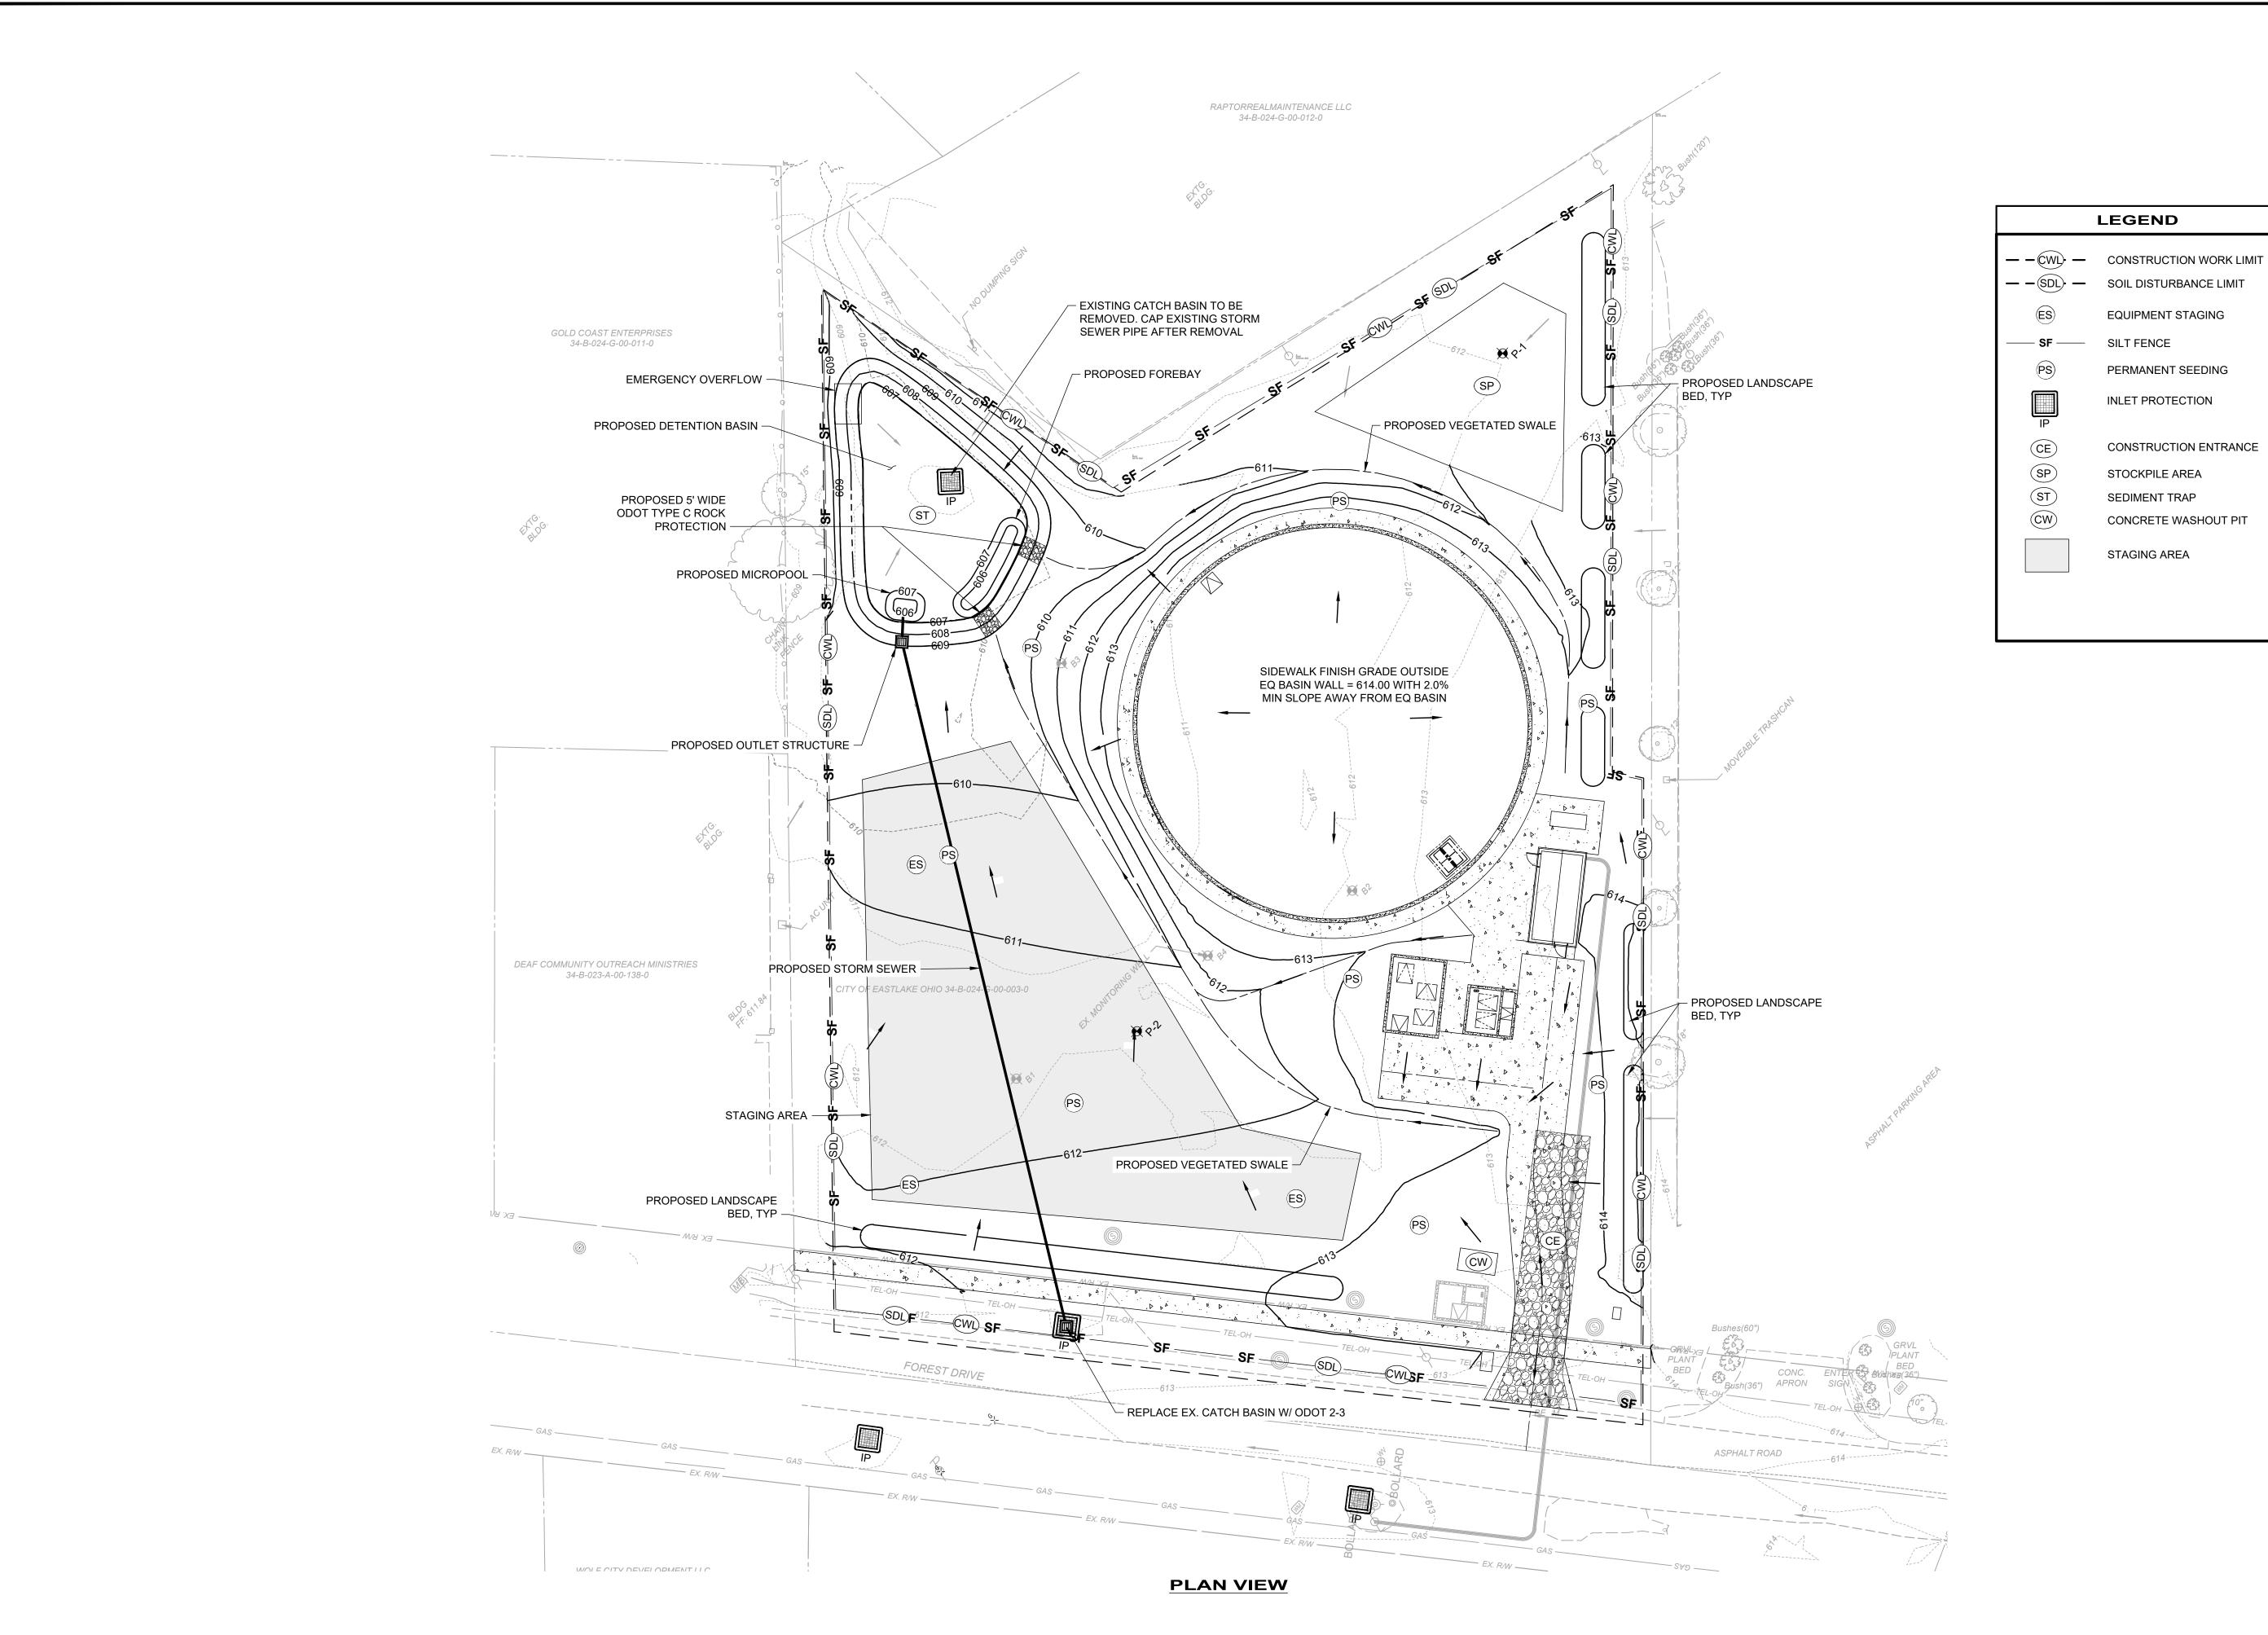

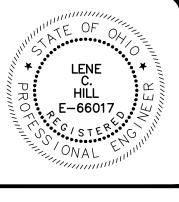

+20T2	

LEGEND

EQUIPMENT STAGING

PERMANENT SEEDING

CONSTRUCTION ENTRANCE

CONCRETE WASHOUT PIT

INLET PROTECTION

STOCKPILE AREA

SEDIMENT TRAP

STAGING AREA

10/3/2025	AS NOTED	ГСН	ГСН	RSS
ISSUE DATE:	SCALE:	DESIGNED BY:	DRAWN BY:	CHECKED BY:
EO BASIN		WILLOUGHBY, OHIO	01 SERIES	
	PROJE	LAKE COUNTY		SWPPP PLAN
	PROJE	D TO FINE COUNTY		SWPPP PLAN

SHEET NAME

30C-03

EROSION AN	D SEDIMENT CONTROL
PROJECT NAME:	
PROJECT ADDRESS:	
THE PURPOSE OF OVERSEEING COMPLIA THE OHIO EPA NPDES CONSTRUCTION GI	, HEREBY DESIGNATE ELOW TO BE A DULY AUTHORIZED REPRESENTATIVE FOR NOCE WITH ENVIRONMENTAL REQUIREMENTS, INCLUDING ENERAL PERMIT, AT THE DESIGNATED PROJECT. THE DRTS, STORM WATER POLLUTION PREVENTION PLANS (SWPBY THE NPDES PERMIT.
NAME OF QUALIFIED PERSON AND/OR PO	PSITION
COMPANY NAME	PHONE NO.
STREET ADDRESS	
DOCUMENTS WILL BE PREPARED UNDER	FIFY UNDER THE PENALTY OF LAW THAT ALL REQUIRED MY DIRECTION OR SUPERVISION IN ACCORDANCE WITH A
DOCUMENTS WILL BE PREPARED UNDER SYSTEM DESIGNED TO ASSURE THAT QUINFORMATION SUBMITTED. BASED ON MYOR IS DIRECTLY RESPONSIBLE FOR GATH SUBMITTED WILL BE, TO THE BEST OF MY COMPLETE. I AM AWARE THERE ARE SUBMITTED WILL BE PREPARE SUBMITTED WILL BE PREPARED UNDER PROPERTY OF MY AMARE THERE ARE SUBMITTED WILL BE PREPARED UNDER PROPERTY OF MY AMARE THERE ARE SUBMITTED WILL BE PREPARED UNDER PROPERTY OF MY AMARE THERE ARE SUBMITTED WILL BE PREPARED UNDER PROPERTY OF MY AMARE THERE ARE SUBMITTED WILL BE PREPARED UNDER PROPERTY OF MY AMARE THERE ARE SUBMITTED WILL BE PREPARED UNDER PROPERTY OF MY AMARE THERE ARE SUBMITTED WILL BE PREPARED UNDER PROPERTY OF MY AMARE THERE ARE SUBMITTED WILL BE PREPARED UNDER PROPERTY OF MY AMARE THERE ARE SUBMITTED WILL BE PROPERTY OF MY AMARE THERE ARE SUBMITTED WILL BE PROPERTY OF MY AMARE THERE ARE SUBMITTED.	
DOCUMENTS WILL BE PREPARED UNDER SYSTEM DESIGNED TO ASSURE THAT QUINFORMATION SUBMITTED. BASED ON MYOR IS DIRECTLY RESPONSIBLE FOR GATH SUBMITTED WILL BE, TO THE BEST OF MY COMPLETE. I AM AWARE THERE ARE SUBMITTED WILL BE AND THE SUBMITTED WILL BE AND THE BEST OF MY COMPLETE.	MY DIRECTION OR SUPERVISION IN ACCORDANCE WITH A ALIFIED PERSONNEL PROPERLY GATHER AND EVALUATE THE INQUIRY OF THE PERSON(S) WHO MANAGES THE SYSTEM HERING THE INFORMATION, THE INFORMATION TO BE KNOWLEDGE AND BELIEF, TRUE, ACCURATE AND BESTANTIAL PENALTIES FOR SUBMITTING FALSE
DOCUMENTS WILL BE PREPARED UNDER SYSTEM DESIGNED TO ASSURE THAT QUANTOR MATION SUBMITTED. BASED ON MY OR IS DIRECTLY RESPONSIBLE FOR GATH SUBMITTED WILL BE, TO THE BEST OF MY COMPLETE. I AM AWARE THERE ARE SUBMITORMATION, INCLUDING THE POSSIBILI	MY DIRECTION OR SUPERVISION IN ACCORDANCE WITH A ALIFIED PERSONNEL PROPERLY GATHER AND EVALUATE TH Y INQUIRY OF THE PERSON(S) WHO MANAGES THE SYSTEM HERING THE INFORMATION, THE INFORMATION TO BE Y KNOWLEDGE AND BELIEF, TRUE, ACCURATE AND BISTANTIAL PENALTIES FOR SUBMITTING FALSE TY OF FINE AND IMPRISONMENT FOR KNOWING VIOLATIONS
DOCUMENTS WILL BE PREPARED UNDER SYSTEM DESIGNED TO ASSURE THAT QUANTOR MATION SUBMITTED. BASED ON MY OR IS DIRECTLY RESPONSIBLE FOR GATH SUBMITTED WILL BE, TO THE BEST OF MY COMPLETE. I AM AWARE THERE ARE SUBMITORMATION, INCLUDING THE POSSIBILION COMPANY NAME	MY DIRECTION OR SUPERVISION IN ACCORDANCE WITH A ALIFIED PERSONNEL PROPERLY GATHER AND EVALUATE TH Y INQUIRY OF THE PERSON(S) WHO MANAGES THE SYSTEM HERING THE INFORMATION, THE INFORMATION TO BE Y KNOWLEDGE AND BELIEF, TRUE, ACCURATE AND BISTANTIAL PENALTIES FOR SUBMITTING FALSE TY OF FINE AND IMPRISONMENT FOR KNOWING VIOLATIONS
DOCUMENTS WILL BE PREPARED UNDER SYSTEM DESIGNED TO ASSURE THAT QUANTOR MATION SUBMITTED. BASED ON MY OR IS DIRECTLY RESPONSIBLE FOR GATH SUBMITTED WILL BE, TO THE BEST OF MY COMPLETE. I AM AWARE THERE ARE SUBMITTED WILL BE, TO THE POSSIBILION OF THE POSSIBILI	MY DIRECTION OR SUPERVISION IN ACCORDANCE WITH A ALIFIED PERSONNEL PROPERLY GATHER AND EVALUATE TH Y INQUIRY OF THE PERSON(S) WHO MANAGES THE SYSTEM HERING THE INFORMATION, THE INFORMATION TO BE Y KNOWLEDGE AND BELIEF, TRUE, ACCURATE AND BISTANTIAL PENALTIES FOR SUBMITTING FALSE TY OF FINE AND IMPRISONMENT FOR KNOWING VIOLATIONS
DOCUMENTS WILL BE PREPARED UNDER SYSTEM DESIGNED TO ASSURE THAT QUINFORMATION SUBMITTED. BASED ON MY OR IS DIRECTLY RESPONSIBLE FOR GATH SUBMITTED WILL BE, TO THE BEST OF MY COMPLETE. I AM AWARE THERE ARE SUBMITFORMATION, INCLUDING THE POSSIBILITY COMPANY NAME STREET ADDRESS PRINT NAME AND TITLE	MY DIRECTION OR SUPERVISION IN ACCORDANCE WITH A ALIFIED PERSONNEL PROPERLY GATHER AND EVALUATE THE Y INQUIRY OF THE PERSON(S) WHO MANAGES THE SYSTEM HERING THE INFORMATION, THE INFORMATION TO BE Y KNOWLEDGE AND BELIEF, TRUE, ACCURATE AND BETANTIAL PENALTIES FOR SUBMITTING FALSE TY OF FINE AND IMPRISONMENT FOR KNOWING VIOLATIONS PHONE NO.
DOCUMENTS WILL BE PREPARED UNDER SYSTEM DESIGNED TO ASSURE THAT QUINFORMATION SUBMITTED. BASED ON MYOR IS DIRECTLY RESPONSIBLE FOR GATH SUBMITTED WILL BE, TO THE BEST OF MY COMPLETE. I AM AWARE THERE ARE SUBINFORMATION, INCLUDING THE POSSIBILI COMPANY NAME STREET ADDRESS PRINT NAME AND TITLE	MY DIRECTION OR SUPERVISION IN ACCORDANCE WITH A ALIFIED PERSONNEL PROPERLY GATHER AND EVALUATE THE Y INQUIRY OF THE PERSON(S) WHO MANAGES THE SYSTEM HERING THE INFORMATION, THE INFORMATION TO BE Y KNOWLEDGE AND BELIEF, TRUE, ACCURATE AND BETANTIAL PENALTIES FOR SUBMITTING FALSE TY OF FINE AND IMPRISONMENT FOR KNOWING VIOLATIONS PHONE NO.

PROJECT NAME:	
PROJECT ADDRESS:	
UNDERSTAND THE TERMS AND CONDIT (SWP3) FOR THE DESIGNATED PROJECT SUBCONTRACTOR, I AM REQUIRED TO PROJECT. IT IS MY RESPONSIBILITY TO TO ADVISE MY EMPLOYEES WORKING OF ARE SUBSTANTIAL PENALTIES OR LOSS	FY UNDER THE PENALTY OF LAW THAT I HAVE READ AND TIONS OF THE STORM WATER POLLUTION PREVENTION PLAN T AND AGREE TO FOLLOW THE PRACTICES DESCRIBED. AS A COMPLY WITH THE SWP3 FOR ANY WORK I PERFORM AT THE OBTAIN A COPY OF THE SWP3 FROM THE CONTRACTOR AND ON THIS PROJECT OF THE REQUIREMENTS. I AM AWARE THER OF CONTRACT FOR VIOLATING ANY CONDITION OF THE SWP3 ND IMPRISONMENT FOR KNOWING VIOLATIONS.
COMPANY NAME	PHONE NO.
STREET ADDRESS	
PRINT NAME AND TITLE	
SIGNATURE	DATE
DESCRIPTION OF CONSTRUCTION SER	VICE(S) I AM TO PROVIDE:
DESCRIPTION OF CONSTRUCTION SER	VICE(S) I AM TO PROVIDE:
DESCRIPTION OF CONSTRUCTION SER	VICE(S) I AM TO PROVIDE:
DESCRIPTION OF CONSTRUCTION SER	VICE(S) I AM TO PROVIDE:
DESCRIPTION OF CONSTRUCTION SER	VICE(S) I AM TO PROVIDE:

PROJECT NAME:	
PROJECT ADDRESS:	
UNDER MY DIRECTION OR SUPERVIS THAT QUALIFIED PERSONNEL PROPE FOR THE DESIGNATED PROJECT. BA SYSTEM OR DIRECTLY RESPONSIBLE SUBMITTED IS, TO THE BEST OF MY RESPONSIBLE	THAT THIS DOCUMENT AND ALL ATTACHMENTS WERE PREPAREIGION IN ACCORDANCE WITH A SYSTEM DESIGNED TO ASSURE ERLY GATHERED AND EVALUATED THE INFORMATION SUBMITTED ASED ON MY INQUIRY OF THE PERSON(S) WHO MANAGED THE FOR GATHERING THE INFORMATION, THE INFORMATION KNOWLEDGE AND BELIEF, TRUE, ACCURATE AND COMPLETE. I AS ENALTIES FOR SUBMITTING FALSE INFORMATION, INCLUDING THE MENT FOR KNOWING VIOLATIONS.
COMPANY NAME	PHONE NO.
STREET ADDRESS	
PRINT NAME AND TITLE	
SIGNATURE	DATE

	GRADING AND	STABILI	ZATIO	N ACTI	VITY LOG
ROJECT NA	ME:				SHEET NO.:
ROJECT AD	DRESS:				
DATE GRADING ACTIVITY		DATE GRADING ACTIVITY		IZATION INITIATED	DESCRIPTION OF STABILIZATION MEASURE AND LOCATION
INITIATED	DESCRIPTION OF GRADING ACTIVITY	CEASED	DATE	TYPE	(ATTACH SKETCH IF NECESSARY)
				☐ TEMP. ☐ PERM.	
				☐ TEMP. ☐ PERM.	
				☐ TEMP. ☐ PERM.	
				☐ TEMP. ☐ PERM.	
				☐ TEMP. ☐ PERM.	
				☐ TEMP. ☐ PERM.	
				☐ TEMP. ☐ PERM.	
				☐ TEMP. ☐ PERM.	

	EROSI	ON AND SEDIMENT CONT	ROL AMENDMENT LOG
ROJECT NAME	:		SHEET NO.:
OJECT ADDR	ESS:		
AMENDMENT NO.	DATE OF AMENDMENT	DESCRIPTION OF AMENDMENT	DESCRIPTION OF STABILIZATION MEASURE AND LOCATION (ATTACH SKETCH IF NECESSARY)



dantas

CITY OF WILLOUGHBY
AKESHORE EAST EQ BA
PHASE II

PROJECT NO.

230264


DISCIPLINE

EROSION


SHEET NAME


30C-04

SHEET OF **48**

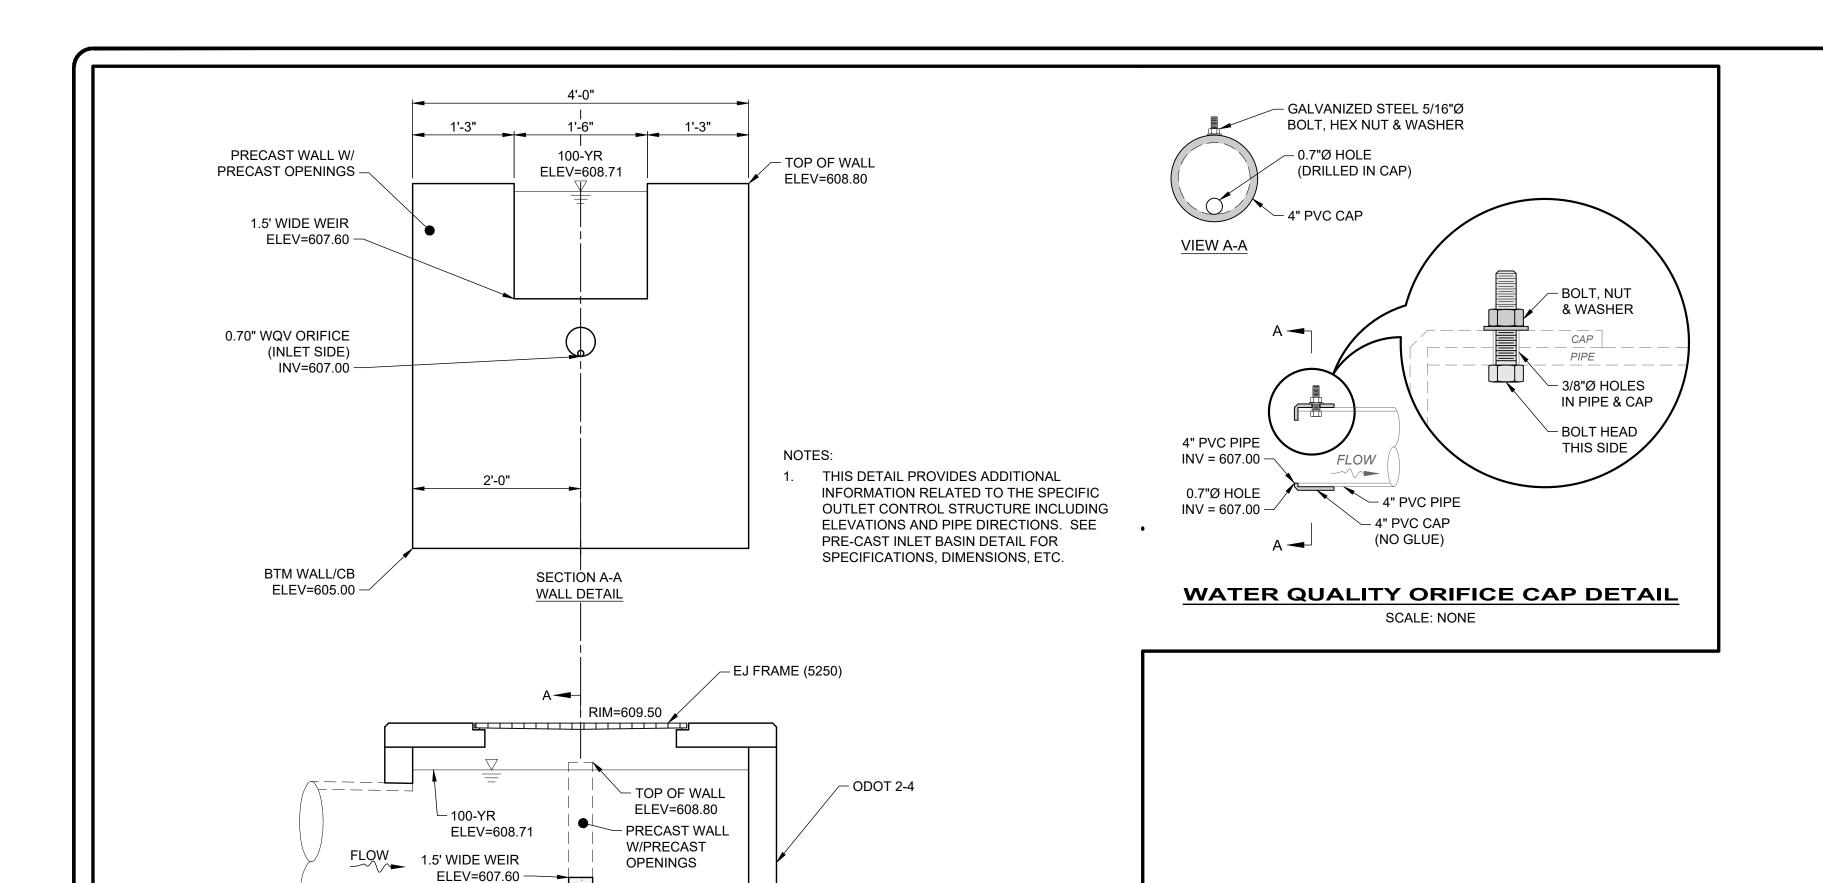

12" INV=606.50

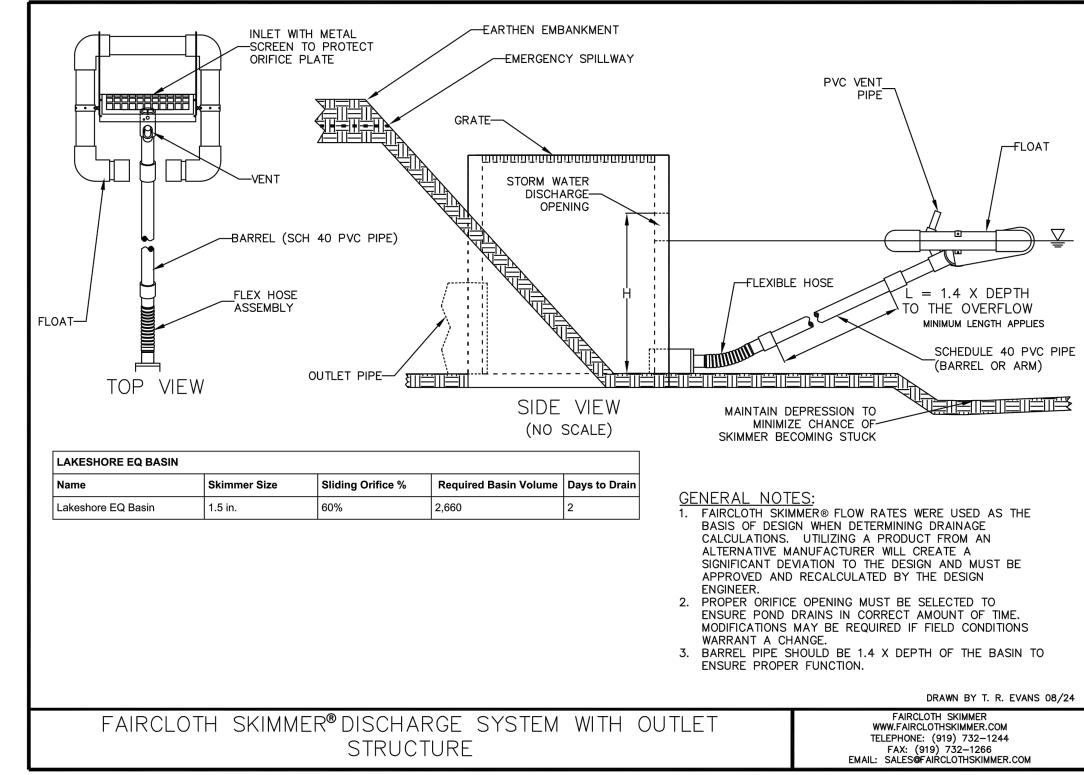

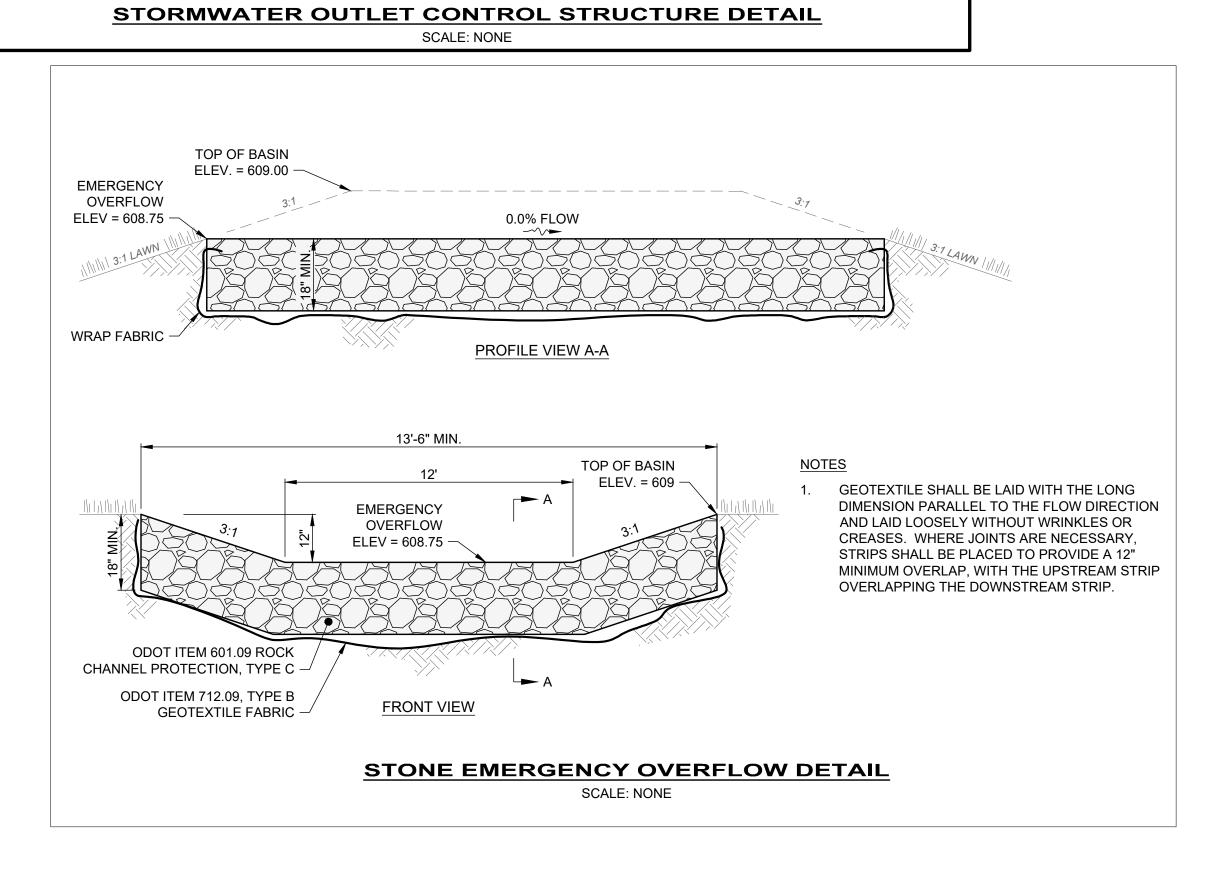

- 4" PVC W/ CAP INV=607.00


FLOW

0.70" WQV ORIFICE

INV=607.00 -

18" INV=607.00 -

BTM SUMP ELEV=605.00 -

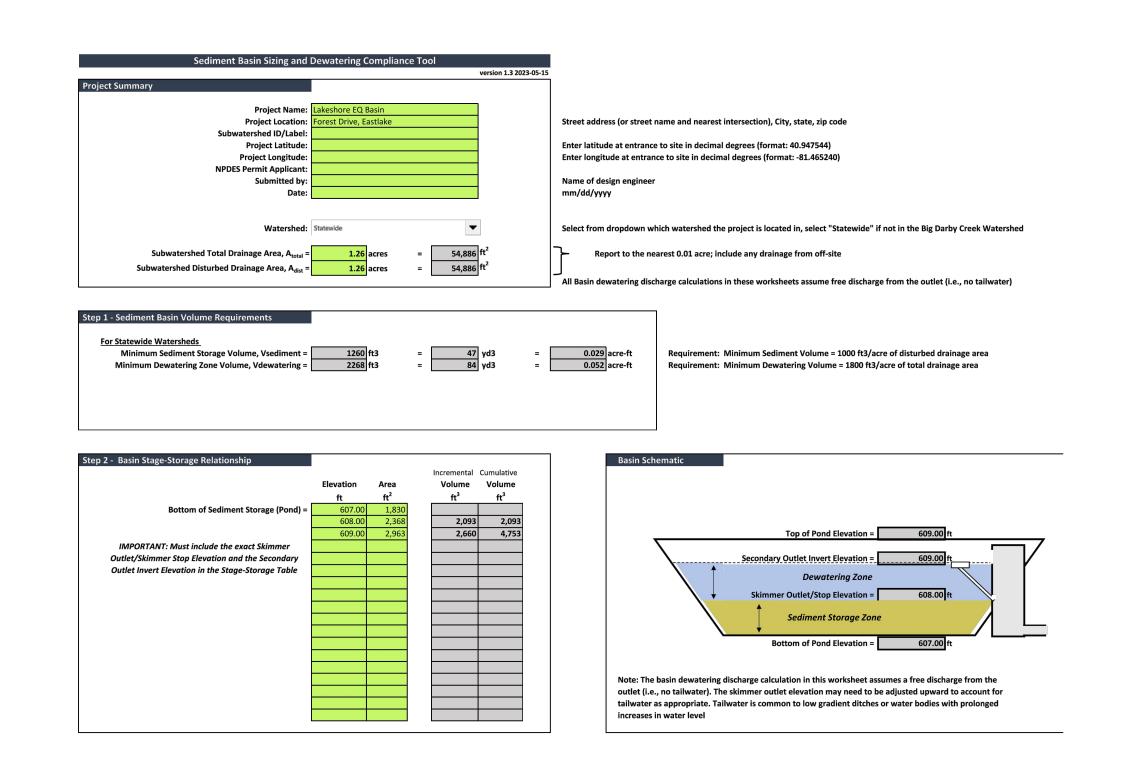

SEDIMENT TRAP SIZING
SCALE: NONE

PROFESSION	LENE C. HILL E-66017 G/STERE ONAL	WEER * O'STILL

KESHORE EAST EO BASIN	ISSUE DATE: 1	0/3/2025	
	SCALE: AS	NOTED	D
JNTY WILLOUGHBY, OHIO	DESIGNED BY:	VTA	
STANDARD DETAILS - SD SERIES	DRAWN BY:	VTA	MENTOR
SWPPP DETAILS	CHECKED BY:	RSS	(440) 951

PROJECT NO.


230264


DISCIPLINE

EROSION


SHEET NAME

30C-05

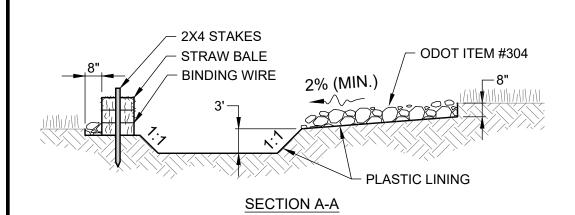

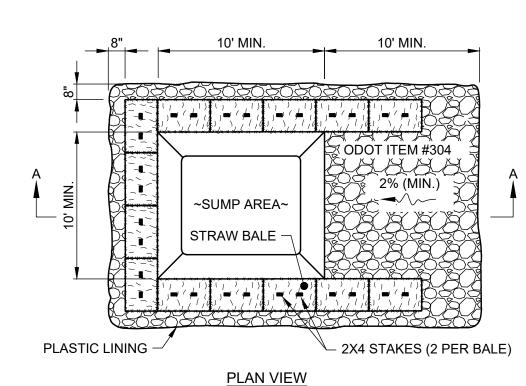

SINGLE LOCATION FOR SMALL PROJECT

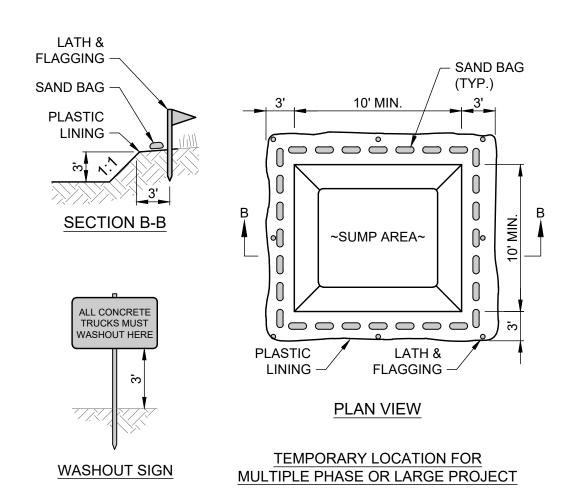

- 1. CONCRETE WASHOUT AREA SHALL BE LOCATED A MINIMUM OF 100' FROM STORM SEWER INLETS, STREAMS, WETLANDS OR ANY OTHER SURFACE WATERS OF THE STATE.
- IF CONCRETE WASHOUT AREA IS LOCATED AWAY FROM A PAVED SURFACE, CONSTRUCT A GRAVEL ACCESS ROUTE EQUAL IN COMPOSITION TO A CONSTRUCTION ENTRANCE.
- CONCRETE WASHOUT AREA SHALL BE SUFFICIENT SIZE TO CONTAIN CONCRETE WASTE GENERATED. LARGE SITES MAY REQUIRE MULTIPLE CONCRETE WASHOUT AREAS.
- PLASTIC LINING SHALL BE DOUBLE-LINED, CONTINUOUS 10-ML POLYETHYLENE SHEETING FREE OF HOLES, TEARS OR OTHER DEFECTS INSTALLED ON A SMOOTH, LEVEL SURFACE, FREE OF LARGE ROCKS AND DEBRIS.
- CONCRETE WASHOUT SIGNAGE SHALL BE CLEARLY VISIBLE AND LOCATED WITHIN 30 FEET OF EACH WASHOUT AREA.
- CONCRETE WASHOUT AREA SHALL BE COVERED DURING INCLEMENT WEATHER TO PREVENT OVERFLOW.
- PREFABRICATED, PORTABLE AND RE-USABLE CONCRETE WASHOUT CONTAINERS ARE ACCEPTABLE.
- CONCRETE WASHOUT AREA SHALL BE INSPECTED DAILY TO CHECK FOR DAMAGE AND DETERMINE IF IT NEEDS CLEANED OR REPLACED. ANY DAMAGE TO THE SIDEWALLS OR PLASTIC LINING SHALL BE REPAIRED IMMEDIATELY. REPLACE THE ENTIRE CONCRETE WASHOUT AREA WHEN IT IS 75% FULL.


CONCRETE WASHOUT DETAIL


SCALE: NONE

- THE SEED BED SHALL BE PULVERIZED AND LOOSE TO ENSURE THE SUCCESS OF ESTABLISHING VEGETATION.
- SOIL AMENDMENTS MAY BE REQUIRED TO ESTABLISH VEGETATION. PERFORM SOIL TESTS TO PREDICT THE NEED FOR LIME OR FERTILIZER. IN LIEU OF A SOIL TEST, APPLY LIME AT 2 TONS/AC. OR FERTILIZER AT 500 LB/AC. OF 10-10-10 OR 12-12-12 ANALYSIS
- APPLY SEED UNIFORMLY. COVER BROADCASTED SEED BY RAKING OR DRAGGING, AND LIGHTLY TAMPING INTO PLACE.
- MULCH SHALL BE APPLIED IMMEDIATELY AFTER SEEDING.
- INSPECT FOR SOIL EROSION OR VEGETATION LOSS AND REPAIR BARE OR SPARSE AREAS, FILL GULLIES, RE-FERTILIZE, RE-SEED AND RE-MULCH AS NEEDED.

TEMPORARY SEEDING SPECIES SELECTION				
DATES	SPECIES	LB/1,000 SF	LB/AC.	
MARCH 1 - AUGUST 15	OATS TALL FESCUE PERENNIAL RYEGRASS	3 1 1	128 40 40	
	PERENNIAL RYEGRASS TALL FESCUE	2 1	40 40	
AUGUST 16 - OCTOBER 31	RYE TALL FESCUE PERENNIAL RYEGRASS	3 1 1	112 40 40	
	WHEAT TALL FESCUE PERENNIAL RYEGRASS	3 1 1	120 40 40	
	PERENNIAL RYEGRASS TALL FESCUE	2 1	40 40	
NOVEMBER 1 - FEBRUARY 28	ONLY MULCH OR DORMANT SEEDING.			

TEMPORARY SEEDING NOTES

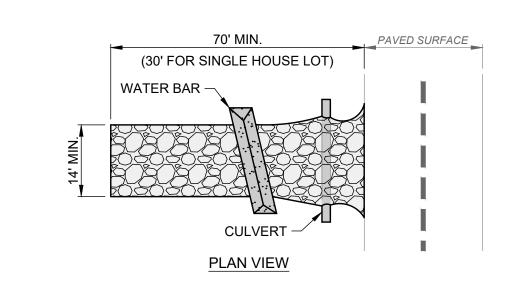


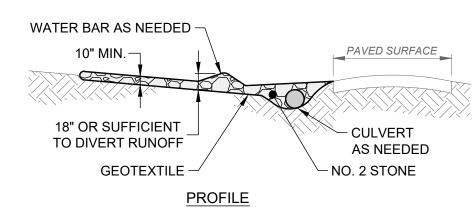


- 1. GEOTEXTILE SHALL BE COMPOSED OF STRONG ROT-PROOF POLYMERIC FIBERS MEETING THE FOLLOWING:
- INSTALL WATER BAR, AS NEEDED, TO PREVENT SURFACE RUNOFF FROM FLOWING OUT ONTO PAVEMENT.
- APPLY ADDITIONAL STONE AS CONDITIONS DEMAND, REPLENISH STONE WHEN THE DEPTH IS LESS THAN 6", AND REPLACE IF STONES BECOMES MUD-LADEN.
- IMMEDIATELY REMOVE MUD DROPPED, WASHED OR TRACKED ONTO ROADS OR ANY SURFACE WHERE RUNOFF IS NOT CHECKED BY SEDIMENT CONTROLS BY SCRAPING OR SWEEPING.
- CONSTRUCTION ENTRANCE SHALL NOT BE RELIED UPON TO REMOVE MUD FROM VEHICLES OR PREVENT OFF-SITE TRACKING. VEHICLES THAT ENTER AND LEAVE THE SITE SHALL BE RESTRICTED FROM MUDDY
- CONSTRUCTION ENTRANCE SHALL REMAIN UNTIL THE DISTURBED AREA IS STABILIZED OR REPLACED WITH A PERMANENT ROADWAY.

CONSTRUCTION ENTRANCE DETAIL

SCALE: NONE

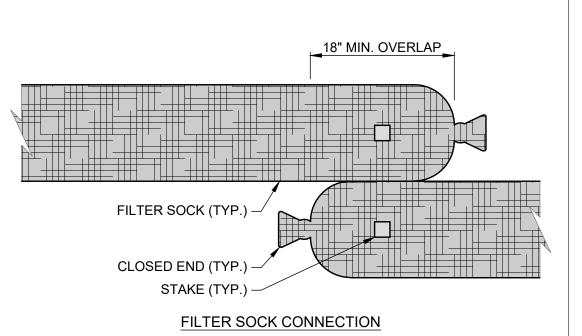

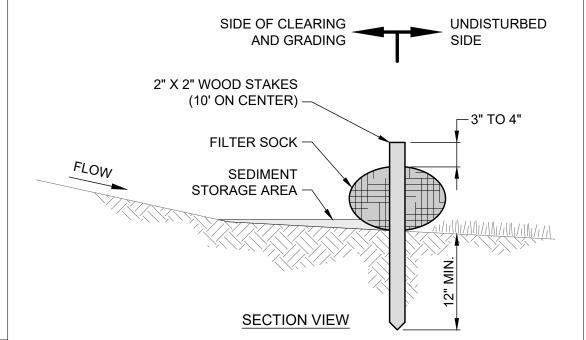

- FILTER SOCKS SHALL BE CONTINUOUS, TUBULAR, HDPE KNITTED MESH NETTING MATERIAL, FILLED WITH COMPOST.
- COMPOST SHALL BE WEED, PATHOGEN AND INSECT FREE, FREE OF REFUSE, CONTAMINANTS OR MATERIALS TOXIC TO PLANT GROWTH, BE DERIVED FROM A WELL-DECOMPOSED SOURCE OF ORGANIC MATTER, AND CONSIST OF PARTICLES RANGING FROM 3/8" TO 2".
- FILTER SOCKS SHALL BE PLACED ON A LEVEL LINE ACROSS SLOPES PARALLEL TO THE BASE OF THE SLOPE. ON SLOPES APPROACHING 2:1, ADDITIONAL SOCKS SHALL BE PROVIDED AT THE TOP AND MID-SLOPE.
- THE FLAT DIMENSION OF THE SOCK SHALL BE AT LEAST 1.5 TIMES THE NOMINAL DIAMETER.
- FILTER SOCKS SHALL BE PLACED AT LEAST 5' FROM THE TOE OF SLOPE FOR SEDIMENT DEPOSIT.
- TRAFFIC SHALL NOT BE PERMITTED TO CROSS FILTER SOCKS.
- BUILT UP SEDIMENT SHALL BE REMOVED WHEN IT HAS REACHED 1/3 THE FILTER SOCK HEIGHT.
- BIODEGRADABLE FILTER SOCKS SHALL BE REPLACED AFTER 6 MONTHS; PHOTODEGRADABLE SOCKS AFTER 1 YEAR. POLYPROPYLENE SOCKS SHALL BE REPLACED ACCORDING TO MANUFACTURER'S RECOMMENDATIONS.
- WHEN A FILTER SOCK IS NO LONGER REQUIRED, IT SHALL BE DISPERSED ON-SITE.
- 10. THE MAXIMUM DRAINAGE AREA PER 100 FEET OF FILTER SOCK IS 1/2

ACRE AND IS DEPENDENT ON THE SLOPE PER THE CHARTS BELOW:


MAX. DRAINAGE AREA (AC.) PER 100-FT OF FILTER SOCK (*)	RANGE OF SLOPE PER INDIVIDUAL DRAINAGE AREA
0.50 AC.	<2% (50H:1V)
0.25 AC.	≥2% (50H:1V) BUT <20% (5H:1V)
0.125 AC.	≥20% (5H:1V) BUT <50% (2H:1V)


(*) FILTER SOCK CANNOT BE USED FOR SLOPES >50% (2H:1V).


MAX. SLOPE LENGTH ABOVE FILTER SOCK				
SLOPE (%) RATIO (H:V) 12"		12"	18"	24"
0% TO <2% 0 TO <50:1 250' 300' 3		350'		
<u>></u> 2% TO <10% <u>></u> 50:1 TO <10:1 125'		125'	200'	25'
≥10% TO <20% ≥10:1 TO <5:1		100'	150'	200'
≥20% TO <50% ≥5:1 TO ≥2:1 50' 75' 100'				


FILTER SOCK DETAIL


SCALE: NONE

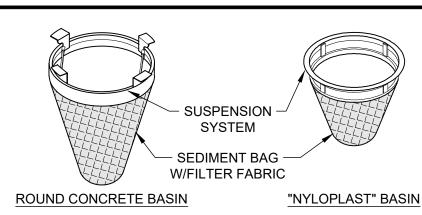

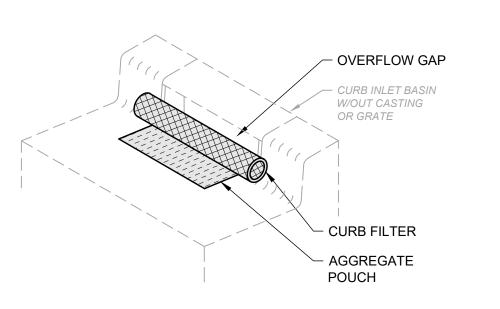

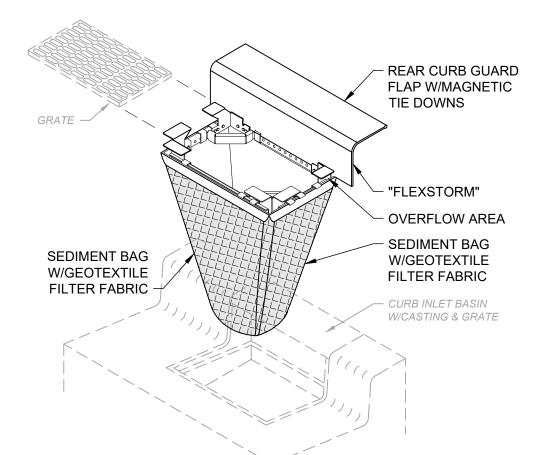

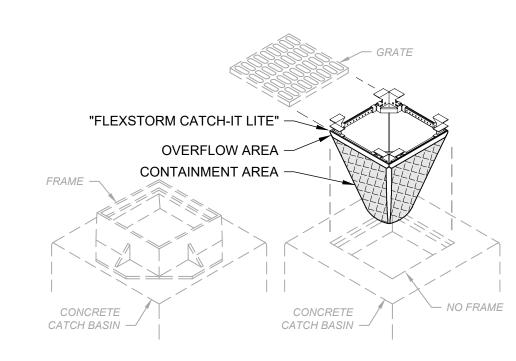

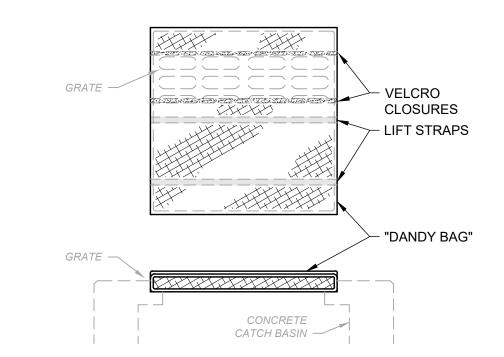

- ALL NEW AND EXISTING STORM INLET BASINS WITHIN THE WORK LIMITS SHALL HAVE INLET PROTECTION INSTALLED.
- INLET PROTECTION SHALL BE INSTALLED AS EACH STORM INLET IS CONSTRUCTED.
- NOT ALL ITEMS SHOWN MAY APPLY OR DIFFERENT TYPES OR CONFIGURATIONS MAY BE REQUIRED. THE CONTRACTOR SHALL MEASURE EACH INLET TO CONFIGURE AND ASSEMBLE CUSTOMIZED INLET FILTERS.

INLET PROTECTION DETAIL

SCALE: NONE

- MULCH SHALL CONSIST OF ONE OF THE FOLLOWING:
- UNROTTED SMALL GRAIN STRAW SPREAD UNIFORMLY AT 2 TONS/AC. (2 TO 3 BALES).
- WOOD-CELLULOSE FIBER (I.E. HYDROSEEDING) APPLIED AT 1 TON/AC.
- ROLLED EROSION CONTROL PRODUCT OR MULCH MATTING
- APPLIED PER MANUFACTURER RECOMMENDATION. WOOD MULCH OR CHIPS APPLIED AT 6 TONS/AC.
- MULCH SHALL BE ANCHORED IMMEDIATELY BY ONE OF THE FOLLOWING METHODS:
- PUNCH OR ANCHOR THE MULCH MATERIAL INTO THE SOIL USING A DISK, CRIMPER OR SIMILAR TOOL.
- NETTING PER MANUFACTURER RECOMMENDATION IN CONCENTRATED RUNOFF AREAS OR CRITICAL SLOPES.
- SYNTHETIC BINDERS AT MANUFACTURER RATE.
- WOOD-CELLULOSE FIBER BINDER AT A NET DRY WEIGHT OF 750 LB/AC., MIXED WITH WATER, AND CONTAIN 50 LB/100 GAL. MAX. OF WOOD CELLULOSE FIBER.

MULCHING NOTES

- SUBSOILING SHALL OCCUR WHEN SOIL MOISTURE IS LOW ENOUGH TO ALLOW THE SOIL TO CRACK OR FRACTURE. SUBSOILING IS NOT PERMITTED ON SLIP-PRONE AREAS.
- THE SEED BED SHALL BE PREPARED BY APPLYING AGRICULTURAL GROUND LIMESTONE OR FERTILIZER AS RECOMMENDED BY A SOIL TEST. IN LIEU OF A SOIL TEST. APPLY LIME AT 2 TONS/AC. OR FERTILIZER AT 500 LB/AC. OF 10-10-10 OR 12-12-12 ANALYSIS. LIME AND FERTILIZER SHALL BE WORKED INTO THE SOIL TO A DEPTH OF 3".
- APPLY SEED UNIFORMLY ON FIRM, MOIST SEED BED BETWEEN MARCH 1 AND MAY 31 OR AUGUST 1 AND SEPTEMBER 30. TILLAGE FOR SEEDBED PREPARATION SHALL OCCUR WHEN THE SOIL IS DRY ENOUGH TO CRUMBLE AND NOT FORM RIBBONS WHEN COMPRESSED BY HAND. SEEDING SHOULD NOT BE APPLIED BETWEEN OCTOBER 1 AND NOVEMBER 20 BECAUSE SEEDS MAY GERMINATE, BUT WILL NOT SURVIVE THE WINTER. IF SEEDING MUST OCCUR, INCREASE THE SEEDING RATE BY 50% AND ANCHOR. APPLY ADDITIONAL MULCH AND IRRIGATION AS REQUIRED TO ENSURE GERMINATION.
- 4. MULCH SHALL BE APPLIED IMMEDIATELY AFTER SEEDING.
- SEEDING SHALL INCLUDE IRRIGATION TO ESTABLISH VEGETATION DURING DRY OR HOT WEATHER OR ON ADVERSE SITE CONDITIONS.
- SEEDING SHALL NOT BE CONSIDERED ESTABLISHED FOR AT LEAST 1 FULL YEAR FROM THE TIME OF SEEDING. DURING THIS PERIOD INSPECT FOR SOIL EROSION OR VEGETATION LOSS AND REPAIR BARE OR SPARSE AREAS, FILL GULLIES, RE-FERTILIZE, RE-SEED AND RE-MULCH AS NEEDED.
- ADEQUATE PERMANENT VEGETATION SHALL BE GROUND COVER DENSE ENOUGH TO COVER 80% OF THE SOIL SURFACE BASED ON VISUAL INSPECTION.

PERMANENT SEEDING	G FERTILIZATIO	ON AND	MOWING CHART	
MIXTURE	FORMULA	LB/ AC.	TIME	MOW
CREEPING RED FESCUE DOMESTIC RYEGRASS KENTUCKY BLUEGRASS	10-10-10	500	FALL, YEARLY, OR AS NEEDED	<u>></u> 3"
TALL FESCUE	10-10-10	500		. 411
TURF-TYPE FESCUE	10-10-10	500		<u>></u> 4"
CROWN VETCH FESCUE	0-20-20	400	SPRING, AND	DO NOT
FLAT PEA FESCUE	0-20-20	400	YEARLY AFTER ESTABLISHED	MOW

		2017 (52101125				
PERMANENT SEEDING SPECIES SELECTION						
SEED MIX	SEED RATE LB/AC.	NOTES:				
GENERAL USE						
CREEPING RED FESCUE DOMESTIC RYEGRASS KENTUCKY BLUEGRASS	20 - 40 10 - 20 20 - 40	FOR CLOSE MOWING AND WATERWAYS WITH <2.0 FT./SEC. VELOCITY				
TALL FESCUE	40 - 50					
TURF-TYPE FESCUE	90					
STEEP E	BANKS OR CUT	SLOPES				
TALL FESCUE 40 - 50						
CROWN VETCH TALL FESCUE	10 - 20 20 - 30	DO NOT SEED LATER THAN AUGUST				
FLAT PEA TALL FESCUE	20 - 25 20 - 30	DO NOT SEED LATER THAN AUGUST				
ROAD DITCHES AND SWALES						
TALL FESCUE	40 - 50					
TURF-TYPE FESCUE KENTUCKY BLUEGRASS	90 5					
LAWN						
KENTUCKY BLUEGRASS PERENNIAL RYEGRASS	100 - 120 100 - 120					
KENTUCKY BLUEGRASS CREEPING RED FESCUE	100 - 120 100 - 120	FOR SHADED AREAS				

PERMANENT SEEDING NOTES



PROJECT NO.

230264


DISCIPLINE


EROSION

SHEET NAME 30C-06

48

SHEET

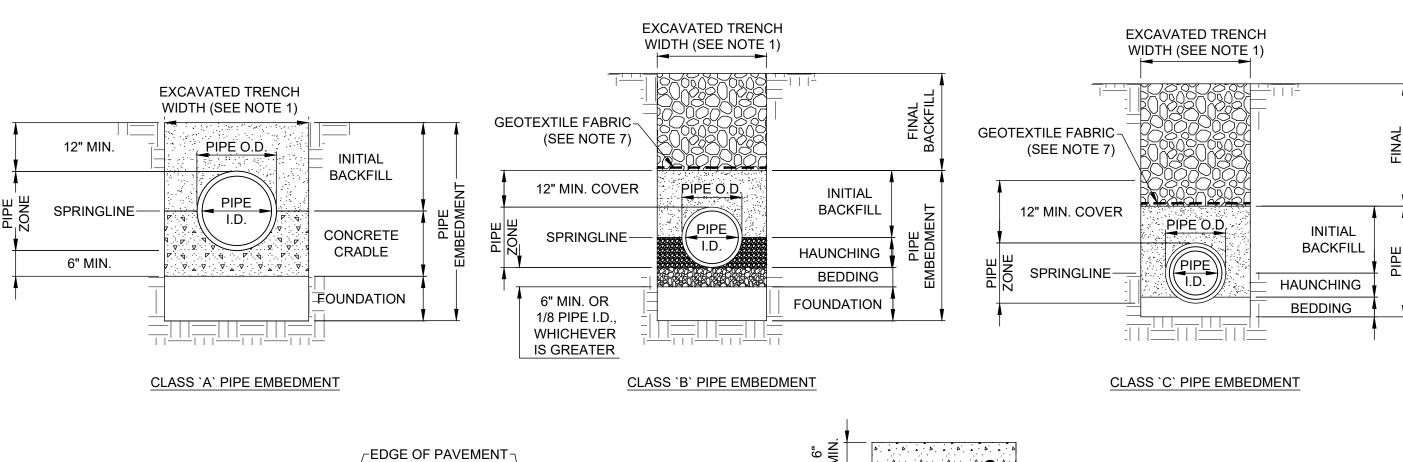

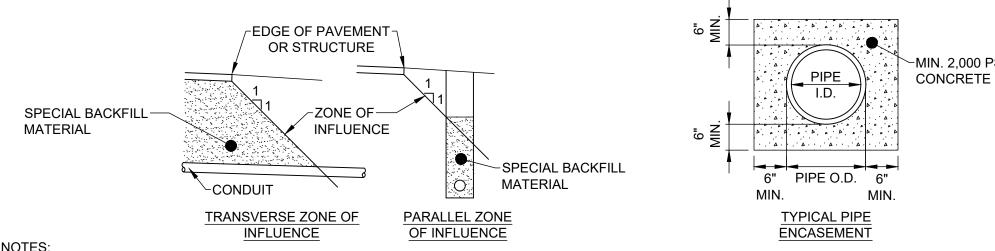



- MAXIMUM EXCAVATED TRENCH WIDTH: THE MAXIMUM EXCAVATED TRENCH WIDTH FROM THE BOTTOM OF THE TRENCH TO 12" OVER THE TOP OF THE PIPE (WITHIN PIPE EMBEDMENT) SHALL BE O.D. + 24" FOR ALL PIPES UP TO AND INCLUDING 24" I.D. + 30" FOR PIPE FROM 24" I.D. TO 54" I.D. AND O.D. + 48" FOR PIPES SIZES 60" I.D. AND OVER.
- 2. FOUNDATION: REQUIRED FOR THIS PROJECT. AS PER THE GEOTECHNICAL REPORT, THE CONTRACTOR SHALL EXCAVATE AND REMOVE AN ADDITIONAL 12" OF MATERIAL AND REPLACE WITH A LAYER OF 6" OF AASHTO NO. 1 AND NO. 2 CRUSHED LIMESTONE, FOLLOWED BY A LAYER OF 6" OF AASHTO NO. 57 GRANULAR LIMESTONE.
- PIPE EMBEDMENT:

CLASS A: CLASS A PIPE EMBEDMENT SHALL BE USED FOR ALL PIPING UNDER PAVEMENT OR STRUCTURES WITH LESS THAN 12 INCHES OF PIPE COVER TO THE SUBGRADE. THE CONCRETE CRADLE SHALL BE IN ACCORDANCE WITH ODOT ITEM 499, CLASS "C". THE INITIAL BACKFILL SHALL BE AASHTO NO. 57 LIMESTONE GRANULAR PIPE EMBEDMENT.

- CLASS B: CLASS B PIPE EMBEDMENT SHALL BE USED FOR ALL PIPING UNLESS OTHERWISE NOTED ON THE PLANS OR AUTHORIZED BY THE ENGINEER. THE HAUNCHING SHALL BE AASHTO NO. 57 LIMESTONE GRANULAR PIPE EMBEDMENT. IN ALL AREAS UNDER PAVEMENT, STRUCTURES OR WITHIN THE ZONE OF INFLUENCE, THE INITIAL BACKFILL SHALL BE AASHTO NO. 57 LIMESTONE GRANULAR PIPE EMBEDMENT. IN ALL AREAS OUTSIDE OF PAVEMENT, STRUCTURES OR THE ZONE OF INFLUENCE, THE INITIAL BACKFILL SHALL BE SUITABLE ON-SITE MATERIAL APPROVED BY THE ENGINEER FOR ONLY REINFORCED CONCRETE PIPE AND DUCTILE IRON PIPE. THE INITIAL BACKFILL FOR ALL OTHER PIPES SHALL BE AASHTO NO. 57 LIMESTONE GRANULAR PIPE EMBEDMENT.
- CLASS C: CLASS C PIPE EMBEDMENT SHALL ONLY BE USED FOR DUCTILE IRON WATER MAIN, DUCTILE IRON FORCE MAINS OR AS AUTHORIZED BY THE ENGINEER. THE PIPE EMBEDMENT SHALL BE AASHTO NO. 57 LIMESTONE GRANULAR PIPE EMBEDMENT IN ALL AREAS UNDER PAVEMENT, STRUCTURES OR WITHIN THE ZONE OF INFLUENCE. THE PIPE EMBEDMENT SHALL BE SUITABLE ON-SITE MATERIAL APPROVED BY THE ENGINEER IN ALL AREAS OUTSIDE OF PAVEMENT, STRUCTURES OR THE ZONE OF INFLUENCE. WHERE ROCK OR SHALE IS ENCOUNTERED, A MINIMUM 6-INCHES OF AASHTO NO. 57 LIMESTONE GRANULAR PIPE BEDDING OR SAND BEDDING SHALL BE PLACED AS DIRECTED BY THE
- 4. FINAL BACKFILL: IN ALL AREAS UNDER PAVEMENT, STRUCTURES OR WITHIN THE ZONE OF INFLUENCE THE FINAL BACKFILL SHALL BE SPECIAL BACKFILL MATERIAL. IN ALL AREAS OUTSIDE OF PAVEMENT, STRUCTURES OR THE ZONE OF INFLUENCE, THE FINAL BACKFILL SHALL BE SUITABLE ON-SITE MATERIAL APPROVED BY THE ENGINEER. LSM SHALL BE USED IN PLACE OF SPECIAL BACKFILL MATERIAL WHEN TOP OF PIPE IS WITHIN 5' OF PAVEMENT OR WITHIN CITY RIGHT-OF-WAY OR UNLESS INDICATED ON DRAWINGS
- 5. SPECIFICATIONS: ALL TRENCHING, PIPE EMBEDMENT AND BACKFILL MATERIALS SHALL BE IN ACCORDANCE WITH SPECIFICATION 310000 EARTHWORK.
- 6. CLAY TRENCH DAMS: CLAY TRENCH DAMS SHALL BE REQUIRED FOR EACH LATERAL, UPSTREAM OF EVERY MANHOLE, AS SHOWN ON THE DRAWINGS, AND AS DIRECTED BY THE ENGINEER.
- 7. GEOTEXTILE FABRIC: INSTALL A GEOTEXTILE FABRIC IN ACCORDANCE WITH ODOT 712.09, TYPE A, AFTER ALL INITIAL BACKFILL CONSISTING OF AASHTO NO. 57 LIMESTONE GRANULAR PIPE
- 8. TYPICAL PIPE ENCASEMENT, AS PER PLAN OR AS DIRECTED BY THE ENGINEER.

TRENCHING, BEDDING, AND BACKFILL DETAIL NOT TO SCALE

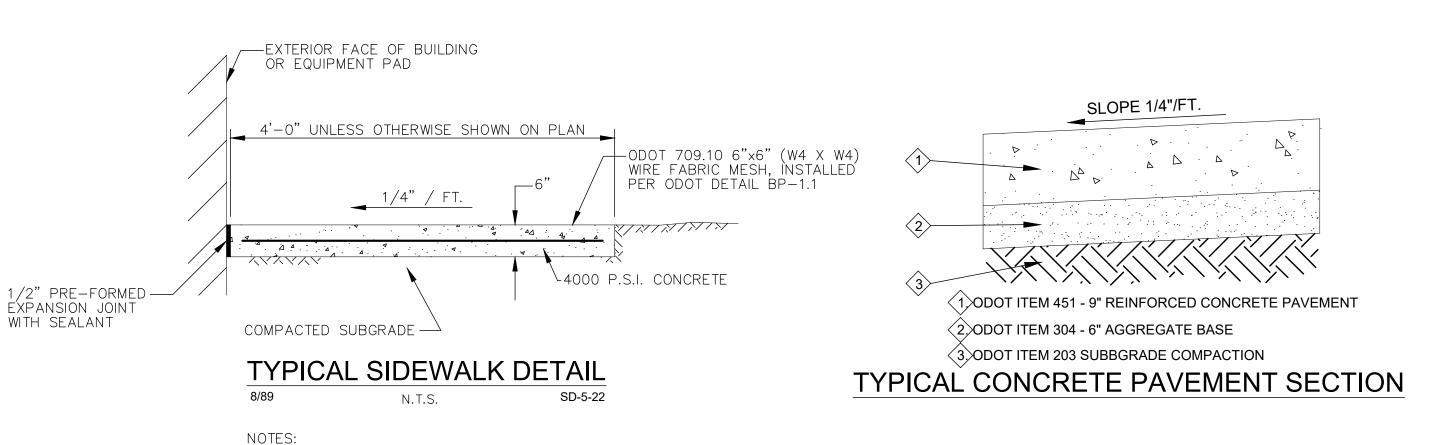

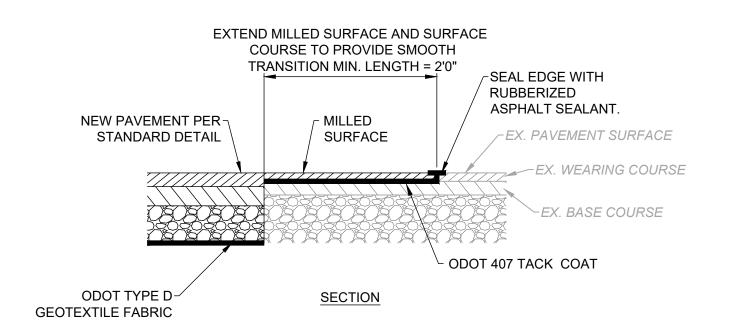

11/88

BUTT JOINT DETAIL NOT TO SCALE


SIZI	NG SC	HEDUL	- —	ARING FAC		
PIPE SIZE	1	BEND EARING CA			15° BENI EARING CA	
	1000 P.S.F.	3000 P.S.F.	5000 P.S.F.	1000 P.S.F.	3000 P.S.F.	5000 P.S.
4	1.40 0.14	0.46	0.26 0.06	2.70 0.12	0.90 0.06	0.54
6	2.80 1.15	0.93 0.10	0.56 0.07	5.50 0.15	1.83 0.10	1.10
8	4.80	1.60	0.96	9.60	3.20	1.92
	0.20	0.13	0.09	0.23	0.15	0.09
10	7.90	2.63	1.96	15.70	5.23	3.14
	0.53	0.34	0.22	0.34	0.20	0.13
12	11.30 0.62	3.76 0.40	2.26 0.26	22.30 0.75	7.43	4.46
14	15.30 0.74	5.10 0.48	3.06 0.31	30.20 0.98	10.06 0.64	6.04
16	19.80	6.60	3.96	39.10	13.03	7.82
	1.17	0.76	0.49	1.21	0.79	0.51
	SOIL B	0° BENI Earing ca	PACITY	SOIL B	OR DEAD	PACITY
	1000 P.S.F.	3000 P.S.F.	5000 P.S.F.	1000 P.S.F.	3000 P.S.F.	5000 P.S.
4	4.90	1.63	0.96	3.50	1.16	0.70
	0.14	0.09	0.06	0.12	0.06	0.06
6	10.20	3.40	2.04	7.20	<u>2.40</u>	1.44
	0.22	0.14	0.09	0.17	0.11	0.07
8	17.70	5.54	3.54	12.50	<u>4.16</u>	2.50
	0.35	0.23	0.15	0.25	0.16	0.14
10	28.90	9.60	5.76	20.40	6.80	4.06
	0.54	0.35	0.23	0.38	0.25	0.16
12	<u>41.10</u>	13.70	8.22	29.10	9.70	5.82
	1.31	0.85	0.55	0.97	0.63	0.42
14	55.80	18.60	11.16	39.50	13.16	7.90
	1.70	1.11	0.72	1.22	0.79	0.51
16	72.20	24.06	14.44	51.10	17.03	10.22
	2.14	1.39	0.90	1.54	1.00	0.65


T.		
-	PLAN FOR BENDS	PLAN FOR TEE AND DEAD END
- - S.F.	— 4 — — — — — — — — — —	
_	SECTION 1 - 1	SECTION 2 - 2

ALL CONCRETE BLOCKING MUST HAVE ITS ENTIRE FACE (X & Y) BEARING SURFACE AGAINST UNDISTURBED SOIL AND ALL VERTICAL NON-BEARING SURFACES SHALL BE FORMED SO AS TO KEEP CONCRETE FROM JOINTS. BLOCKING DESIGN BASED ON COMBINED WORKING PRESSURE PLUS WATER HAMMER OF 240 PSI AND FOR BEARING CAPACITY FOR SAND - 1000 PSF, SAND AND GRAVEL - 3000 PSF, SHALE - 5000 PSF.

THRUST BLOCKING DETAIL

SD-4-6

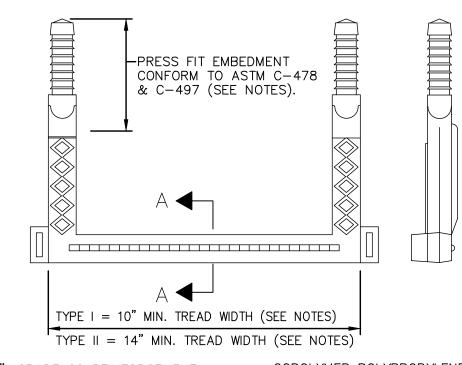

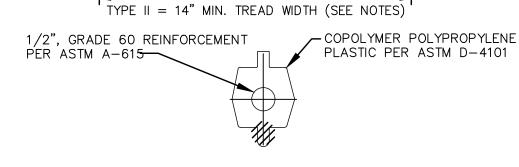

SECTION A - A NOTES:

- 1.) USE TYPE I STEP FOR MANHOLES OR CIRCULAR STRUCTURES OF 5'-0" DIA. OR LESS - USE 16" C/C SPACING.
- 2.) USE TYPE II STEP FOR FLAT WALL STRUCTURES SUCH AS VAULTS, WELLS, ETC. OR CIRCULAR STRUCTURES OVER 5'-0" DIA. USE 12" C/C SPACING.
- 3.) MOUNTING REQUIREMENTS SHALL BE IN ACCORDANCE WITH MFR'S RECOMMENDATIONS.

TYPICAL MANHOLE STEP DETAIL

PROJECT NO. 230264 DISCIPLINE CIVIL SHEET NAME **SD-C-01** 48


H:\2023\230264\DWG\SHEETS\PHASE II\SD 230264 - PROCESS PHASE II.DWG - 37 STANDARD DETAILS - 9/30/2025 1:39:40 PM - CORY SCOTT


SIDEWALK SHALL BE SLOPED 1/4" /FT. SLOPE SHALL BE SLOPED AWAY FROM BUILDINGS AND EQUIPMENT PADS.


RYAN S.

SCHUSTER

72755

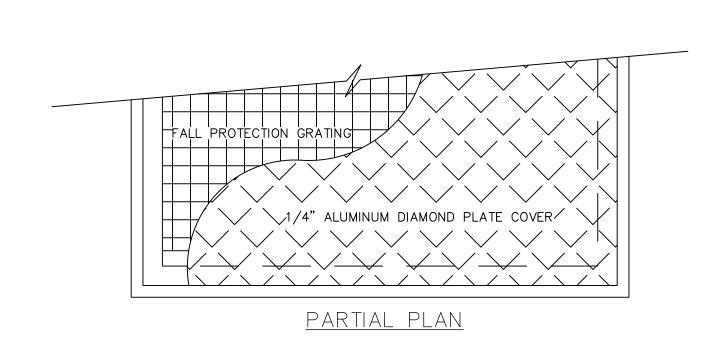

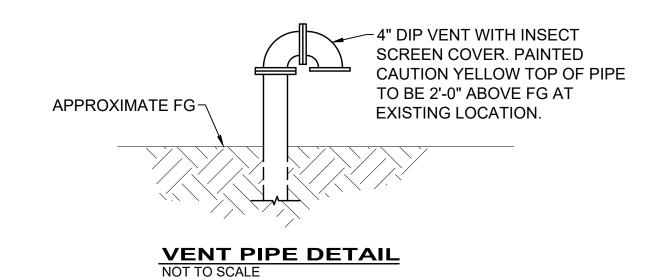

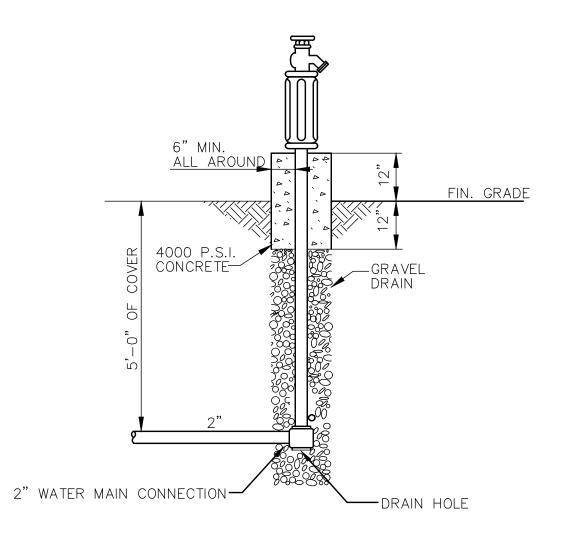

POST HYDRANT DETAIL


NOTES


 HYDRANT TO BE KUPFERLE "ECLIPSE #2" POST HYDRANT, OR APPROVED EQUAL, SELF-DRAINING AND NON-FREEZING. HYDRANT TO HAVE COATED CAST IRON CASING, EPOXY COATED STEEL PIPE, WITH HANDWHEEL OPERATOR, SINGLE OUTLET, 2-INCH INLET & OUTLET. PROVIDE WITH VANDAL-PROOF TOP SCREW AND SIDE CAP.

PROVIDE SAFETY CHAIN OR OTHER FALL PROTECTION SYSTEM W/ ALL


ACCESS HATCHES

2. POST HYDRANT SHALL BE STENCILED WITH THE WORDS "UNSAFE WATER - DO NOT DRINK". STENCILED LETTERS SHALL BE 1-INCH, LOCATED ON THE TOP STOCK SECTION.

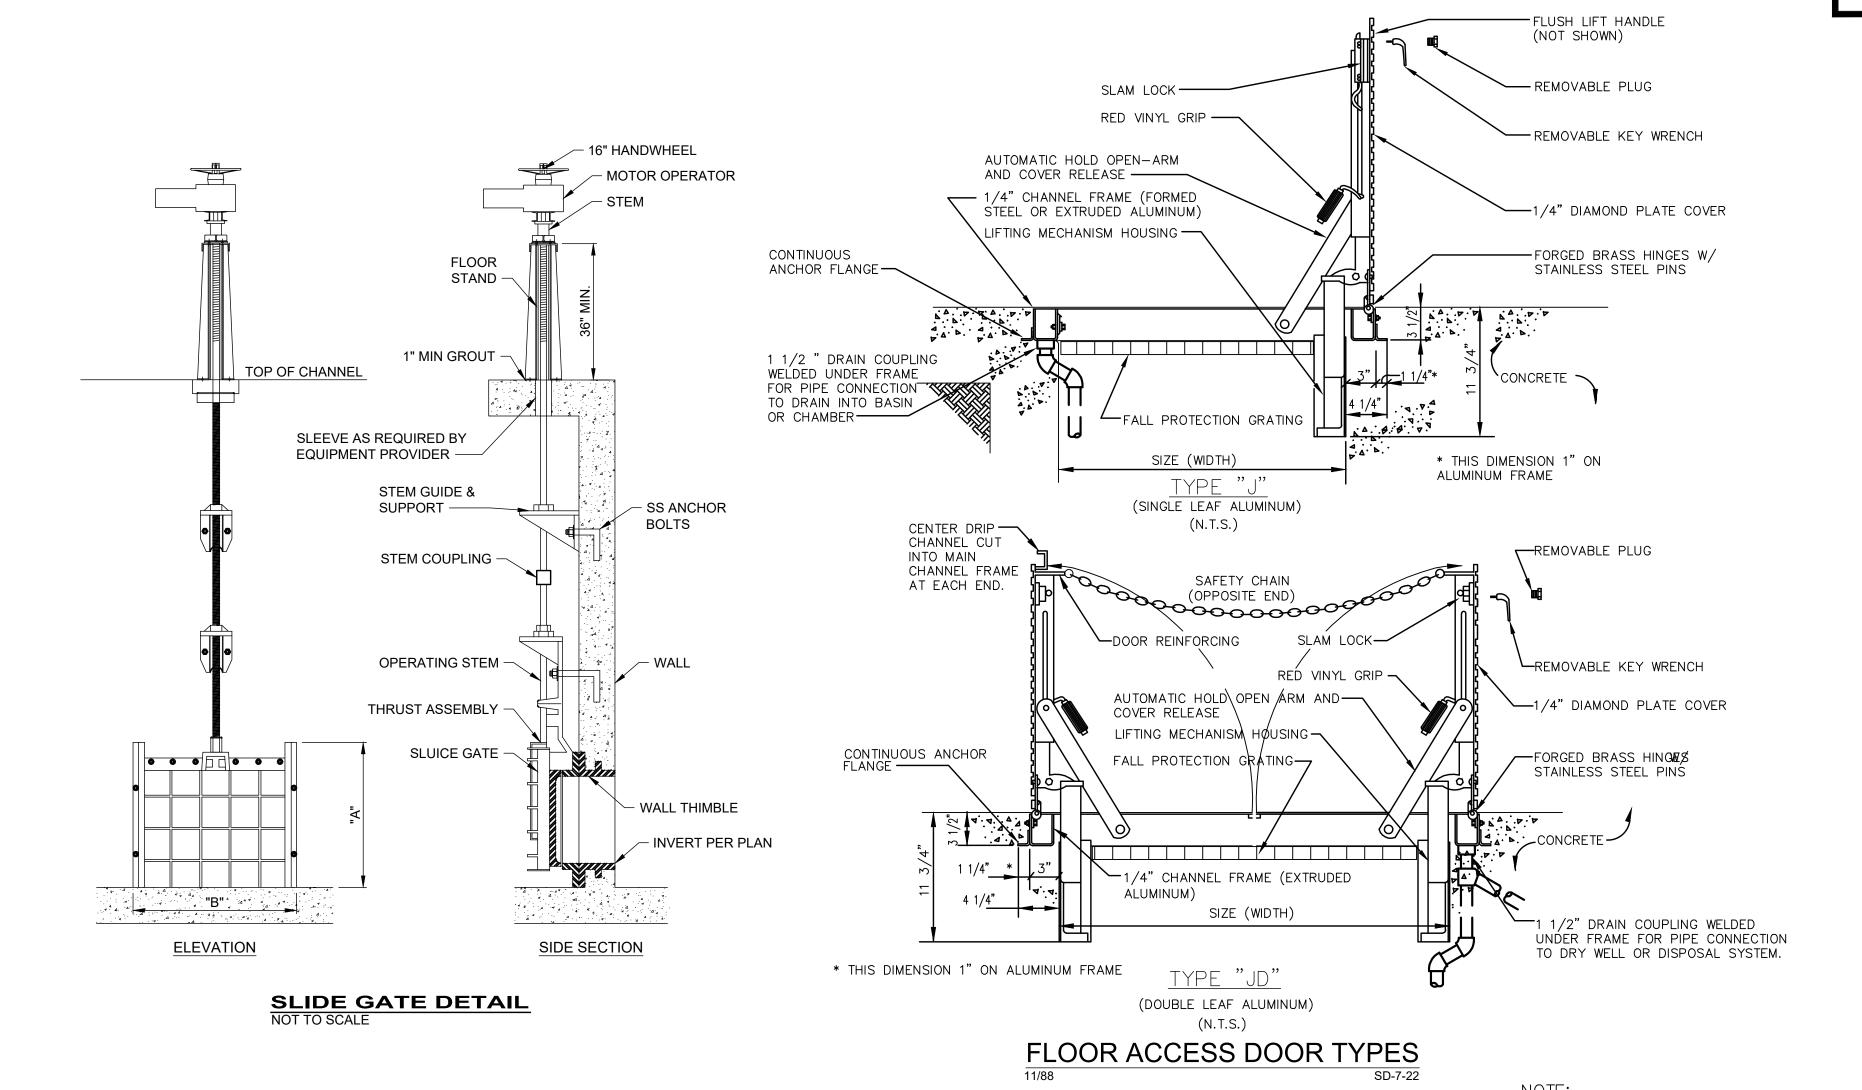

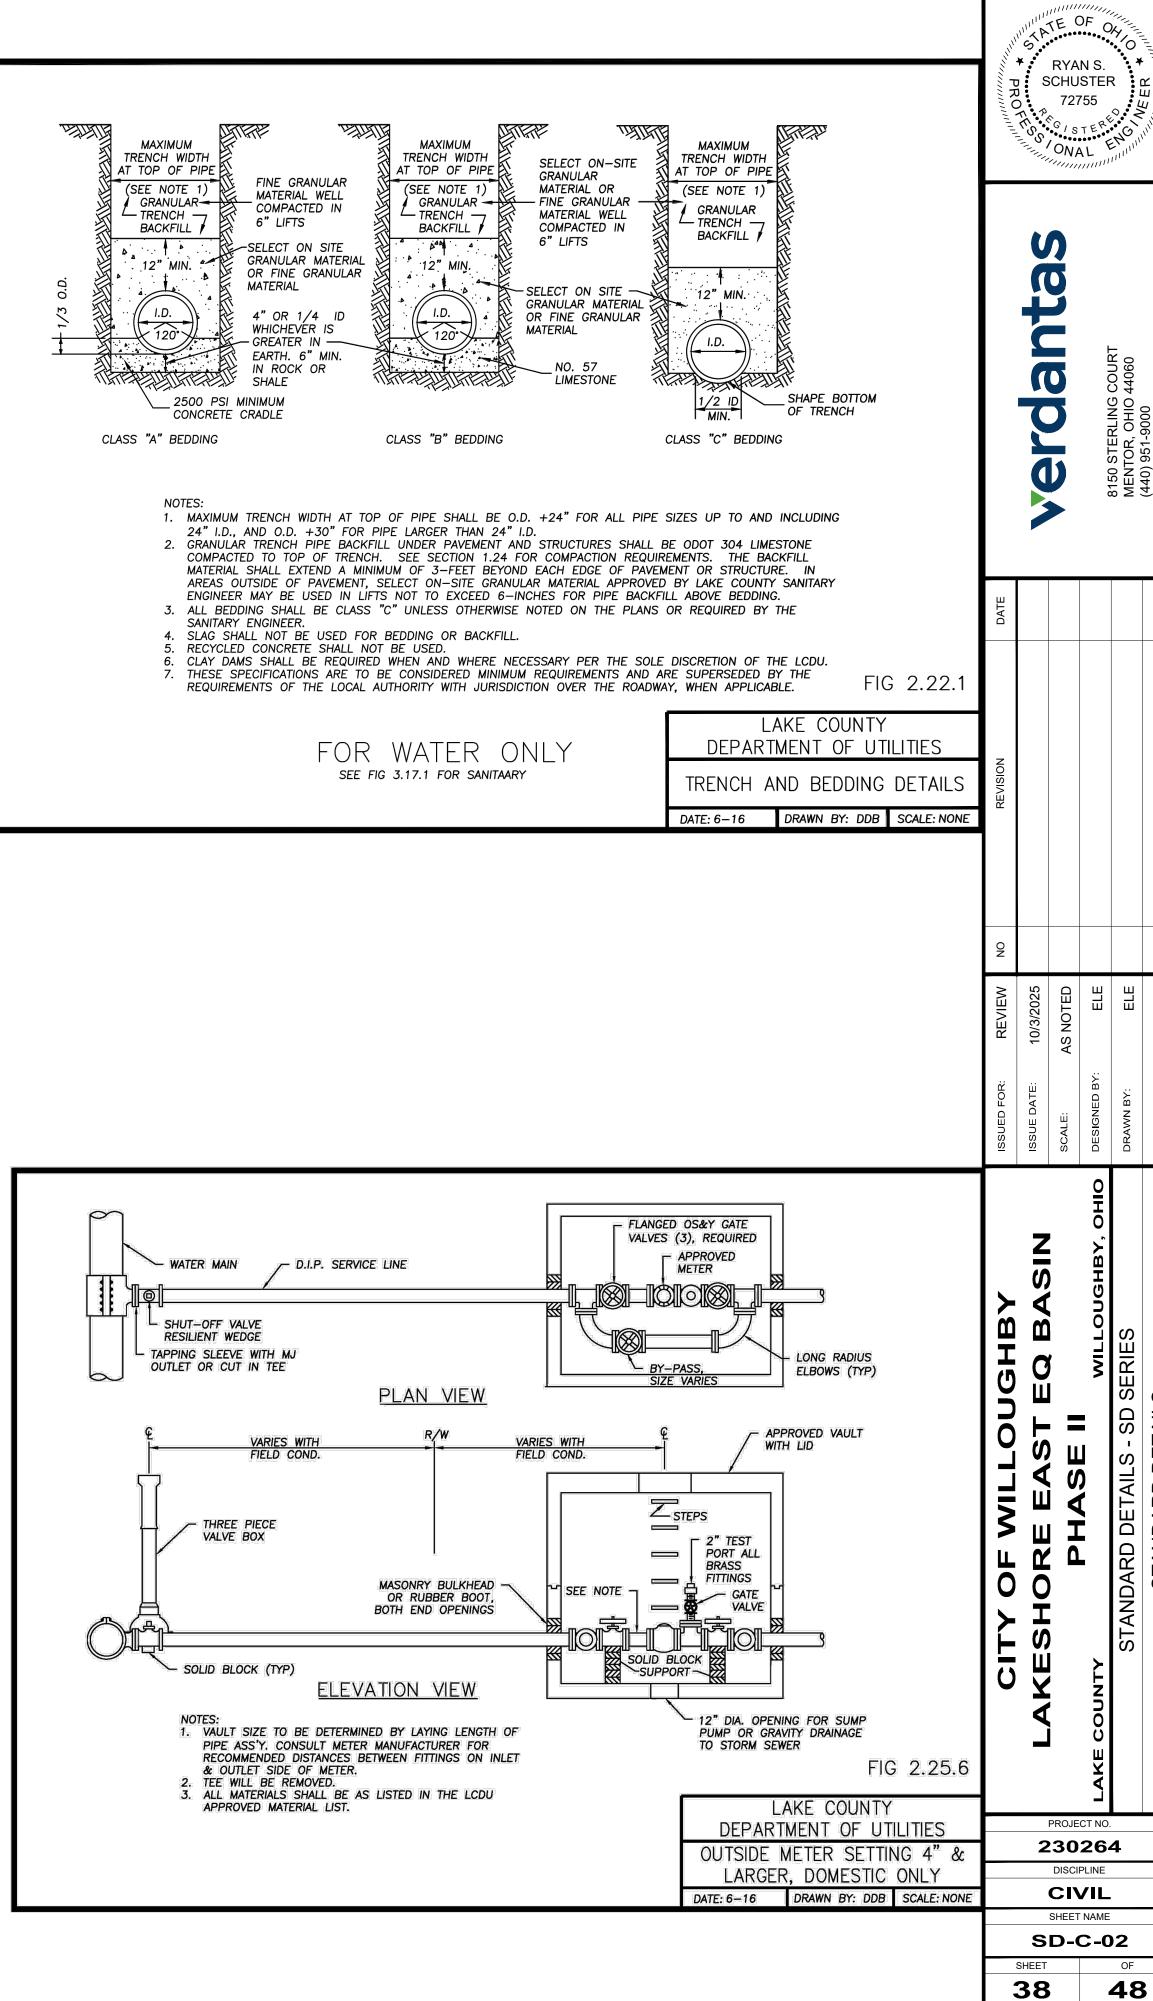



H:\2023\230264\DWG\SHEETS\PHASE II\SD 230264 - PROCESS PHASE II.DWG - 38 STANDARD DETAILS - 9/30/2025 1:39:40 PM - CORY SCOTT

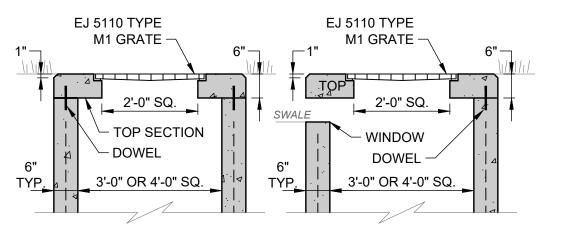

GRASS AREA

GRASS AREA W/ WINDOW

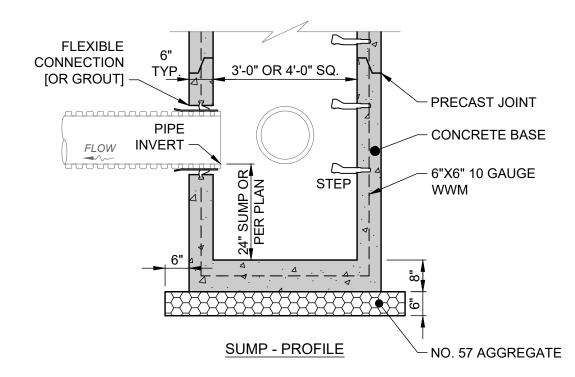

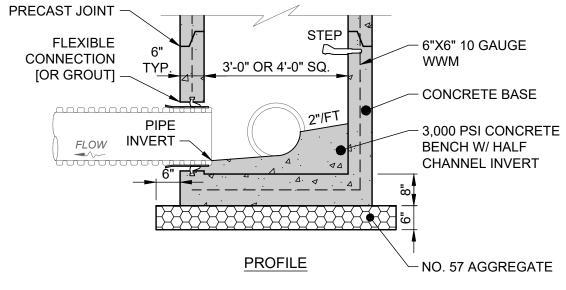

NOTES

- CONCRETE SHALL BE ODOT ITEM 499, CLASS QC-1.
- 2. STRUCTURE SHALL MEET H-20 LOADING.
- 3. INSTALL STEPS IF STRUCTURE IS MORE THAN 4' DEEP. USE REINFORCED PLASTIC MANHOLE STEPS. FIRST STEP SHALL NOT BE MORE THAN 2'-0" BELOW TOP OF FRAME.
- 4. PRECAST KNOCKOUT SIDES FOR CURB DRAIN AND PIPE CONNECTION HOLES, AS REQUIRED. PIPE OPENINGS SHALL BE O.D. OF PIPE PLUS 2", AND ALL PIPE OPENINGS MUST BE PRECAST WITH FLEXIBLE CONNECTIONS (Z-LOK OR A-LOK) PER ASTM C-923.]
- 5. IF TOP SECTION IS A SEPARATE CAST PIECE, 1/2"Ø X 6" L DOWELS SHALL BE USED AT EACH CORNER TO ATTACH THE TOP TO THE BOTTOM SECTIONS OF BASIN.
- 6. GRATE MUST INCLUDE LETTERING "DUMP NO WASTE" AND FISH IMAGE.
- 7. THIS DETAIL IS FOR REFERENCE AND DIMENSION CONTROL ONLY; SEE UTILITY PLAN FOR ACTUAL PIPE SIZES AND ELEVATIONS.


PRECAST CONCRETE
ODOT 2-3 & 2-4
INLET BASIN DETAIL
SCALE: NONE

PRECAST CONCRETE SANITARY STRUCTURE WALL —PIPE BEDDING CONCRETE FILLET-EXTERNAL S.S. FERNCO BAND CLAMP TOP OF TROUGH-**BOTTOM OF** TROUGH SLOPE--SANITARY SEWER PIPE TROUGH--ASTM C-923 SEAL/SLEEVE CAST INTO CLASS B CONCRETE SANITARY STRUCTURE WALL TO FLOW LINE-(Z-LOK OR A-LOK) (Z-LOK SHOWN)

PIPE CONNECTION TO NEW STRUCTURE DETAIL

NOT TO SCALE

CONTRACTOR SHALL REFER TO MANUFACTURER DETAILS AND SPECIFICATIONS FOR SPECIFIC REQUIREMENTS NOT EXPLICITLY NOTED ON THESE DETAILS FOR INSTALLING NEW PIPE INTO AN EXISTING OR NEW PRE-CAST CONCRETE STRUCTURE.

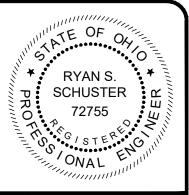

erdantas

 SINA
 ISSUED FOR:
 REVIEW
 NO
 REVISION
 DATE

 SINALE
 AS NOTED
 AS NOTED

LAKESHORE EAST EQ BASIN
PHASE II

PROJECT NO.

230264

DISCIPLINE

CIVIL

SHEET NAME

SD-C-03

SHEET OF **48**

			MECHANICAL EQUIPMENT SCHEDU	LE	
SYMBOL	QUANT.	AREA SERVED	DESCRIPTION	ACCESSORIES	ELECTRICAL REQUIREMENTS
ACU-1	1	CONTROL BUILDING	MITSUBISHI AIR CONDITIONING UNIT HEAT PUMP, DUCTLESS SPLIT SYSTEM, R-454B REFRIGERANT, HIGH WALL EVAPORATOR, POLYSTYRENE CABINET, 22 SEER, VARIABLE SPEED INVERTER-DRIVEN COMPRESSOR, NOM. 1.5 TONS COOLING (5.2 MBH MIN., 22 MBH MAX.), 477 CFM; 18.0 MBH RATED CAPACITY, 14.2 MBH SHC, 0.79 SENSIBLE HEAT FACTOR #MSZ-GX18NL INDOOR UNIT, 208V/230/1 (1.0A, WIRED FROM OUTDOOR UNIT), #MUZ-GX18NL CONDENSING UNIT, 208V/230/1, 23 MCA, 25A CB	WIRED LOW VOLTAGE WALL THERMOSTAT REFRIGERANT LINE SETS CONDENSER WALL MOUNTING BRACKETS: STAINLESS STEEL CONDENSER BASEPAN HEATER	208/230/1/60 23 MCA, 25A CB
UH-1	1	CONTROL BUILDING	MARKEL #P3P5105CA1N UNIT HEATER ELECTRIC, HEAVY DUTY, HORIZONTAL DISCHARGE, FAN FORCED, 5,000 WATTS, 17,100 BTH	24V WALL THERMOSTAT DISCONNECT SWITCH MOUNTING BRACKETS	480/3/60 5.0 KW

1. QUANTITIES ARE SHOWN FOR GENERAL REFERENCE ONLY. CONTRACTOR IS RESPONSIBLE TO PROVIDE ALL EQUIPMENT SHOWN ON PLANS AND DETAILS.

2. CHARACTERISTICS (RPM, HP, IMPELLERØ, PRESSURE DROP) SHALL NOT VARY BY MORE THAN 10% OF SPEC'D UNITS. SOUND VALUES SHALL NOT EXCEED THE VALUES INDICATED.

SEQUENCE OF OPERATION

- ACU-1 AIR CONDITIONING UNIT (CONTROL BUILDING): UNIT SHALL BE A HEAT-PUMP TYPE. UNIT SHALL BE PROVIDED WITH A WIRED WALL THERMOSTAT, 24V LOW VOLTAGE, TO ENERGIZE THE FAN AND COMPRESSOR UPON A CALL FOR COOLING. FAN AND HEAT MODE SHALL BE ENERGIZED UPON A CALL FOR HEATING.
- 2. <u>UH-1</u> UNIT HEATER (CONTROL BUILDING): HEATER SHALL BE CONTROLLED VIA A 24V WALL HEATING THERMOSTAT TO ENERGIZE THE FAN AND HEATING ELEMENTS UPON A CALL FOR HEATING. HEATER CAN BE USED AS "PRIMARY" HEAT, OR AS "BACKUP" HEAT FOR ACU-1 HEAT PUMP DESCRIBED ABOVE, AS DESIRED.


	DRAIN SCHEDULE
SYMBOL	DESCRIPTION
FD-1	J.R. SMITH #2310-Y-L FLOOR DRAIN MEDIUM DUTY, WITH CAST IRON BODY, 8.5"Ø ROUND ADJUSTABLE TOP, CAST IRON SLOTTED GRATE, FLASHING COLLAR, SPEED-SET. WITH #2692 "QUAD CLOSE" ELASTOMERIC TRAP SEAL DEVICE.

NOTES:

1. EQUALS BY: JOSAM CO., WATTS IND., ZURN IND..

MECHANICAL GENERAL NOTES:

- 1. BUILDING IS PRE-CAST CONCRETE. COORDINATE ALL PRE-CAST OPENINGS (PIPING, FLOOR DRAIN, ETC.) WITH GENERAL TRADES CONTRACTOR AND BUILDING MANUFACTURER.
- 2. COORDINATE EXACT LOCATIONS OF ALL PIPES, DUCTS AND EQUIPMENT, SO AS TO NOT INTERFERE WITH DOORS, LIGHTS, ELECTRICAL EQUIPMENT, PROCESS EQUIPMENT, PROCESS PIPING, ETC.
- 3. ALL INTERIOR AND EXTERIOR HANGERS, RODS, SUPPORTS, CLAMPS, ETC. TO BE CORROSION RESISTANT. INTERIOR HANGERS, RODS, ETC. TO BE GALVANIZED STEEL. EXTERIOR HANGERS, RODS, ETC. TO BE TYPE #304 OR #316 STAINLESS STEEL.
- 4. MAKE FINAL GAS CONNECTIONS WITH GAS VALVE, UNION, AND DIRT LEG.
- 5. INSTALL PERMANENT SIGN OF CORROSION RESISTANT MATERIALS, WITH PICTOGRAPH AT ALL HOSE BIBS THAT READS AS FOLLOWS: "CAUTION: NONPOTABLE WATER - DO NOT DRINK."
- 6. ALL MOUNTING HEIGHTS ARE REFERENCED TO THE BOTTOM OF EQUIPMENT, UNLESS NOTED OTHERWISE.
- 7. SEE ELECTRICAL DRAWINGS FOR POWER WIRING SYSTEMS FOR MECHANICAL EQUIPMENT.
- 8. PROVIDE TEMPERATURE CONTROL WIRING IN CONDUITS IN ACCORDANCE WITH DIV. 26 SPECIFICATIONS.

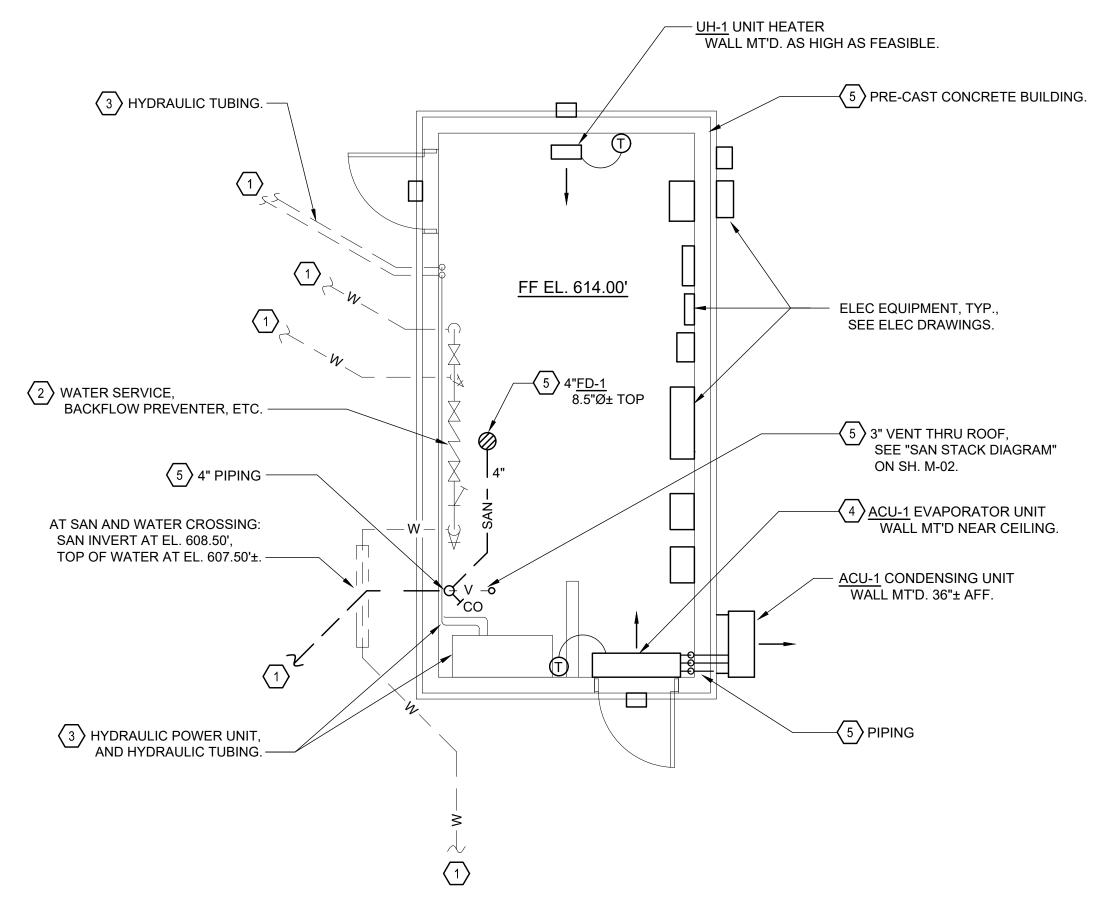



CONTROL BUILDING MECHANICAL PLAN

SCALE: 1/4" = 1'-0"

CODED NOTES:

- 1. SEE SITE SITE PLANS FOR CONTINUATION.
- 2. WATER SERVICE, BACKFLOW PREVENTER, ETC. SEE PROCESS PLANS & DETAILS.
- 3. HYDRAULIC POWER UNIT & HYDRAULIC TUBING ALONG WALL. SEE PROCESS PLANS & DETAILS.
- 4. ROUTE PIPING DOWN ALONG INSIDE OF WALL, WITH REFRIGERANT LINES TO CONDENSING UNIT, AND CONDENSATE OUT WALL 12" AFF, OPEN END.
- 5. BUILDING IS PRE-CAST CONCRETE. COORDINATE ALL PRE-CAST OPENINGS (PIPING, FLOOR DRAIN, ETC.) WITH GENERAL TRADES CONTRACTOR AND BUILDING MANUFACTURER.


NAHTANC MEOLA E-60604

'Y OF WILLOUGHBY	ISSUED FOR:	REVIEW	ON	REVISION	DATE
SHORE EAST EO BASIN	ISSUE DATE:	10/3/2025			
	SCALE:	AS NOTED			
WILLOUGHBY, OHIO	DESIGNED BY:	JRM			
MECHANICAL - M SERIES	DRAWN BY:	JRM			
OL BLG MECH PLANS & SCHEDULES	СНЕСКЕD ВУ:	JRM			


PROJECT NO. 230264

DISCIPLINE

MECHANICAL SHEET NAME M-01

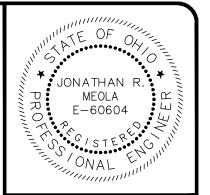



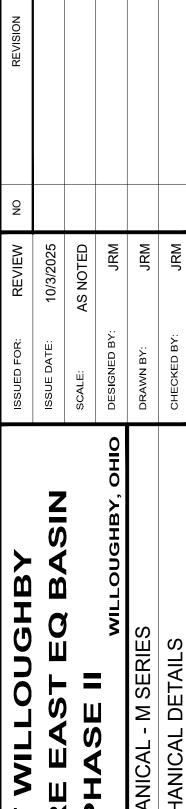



— SEE NOTE 4

FLEX. CONN., SUPPLIED WITH GENERATOR.

TYP.

AT GENERATOR

GENERATOR REGULATOR, -

UNION, TYP.

SEE NOTE 3.

PROJECT NO.

230264 DISCIPLINE


MECHANICAL SHEET NAME M-02


41

48

| 3" VTR INV. EL. 608.50'-SEE SITE PLANS FOR CONTINUATION. SANITARY STACK DIAGRAM

NOT TO SCALE

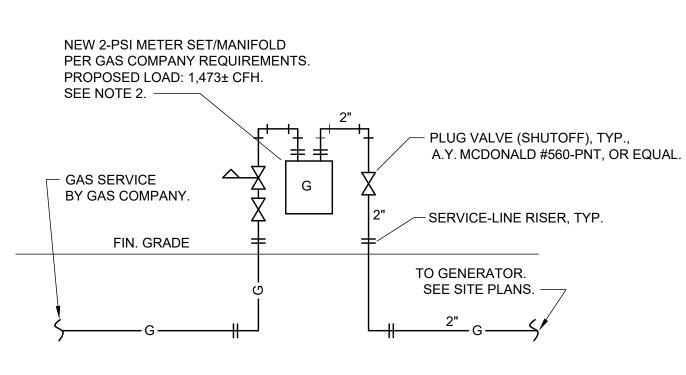

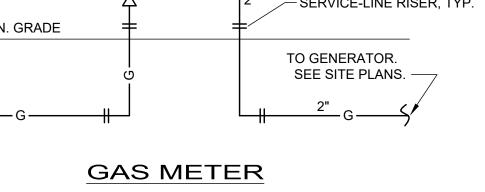

GAS SERVICE DETAIL NOT TO SCALE

NOTES:

- 1. SEE SPECIFICATION #335100 NATURAL GAS DISTRIBUTION FOR ADDITIONAL INFORMATION.
- 2. THE CONTRACTOR SHALL COORDINATE INSTALLATION OF NEW METER MANIFOLD WITH GAS COMPANY. VERIFY ALL CHARACTERISTICS PRIOR TO STARTING ANY WORK. PROVIDE PIPE INCREASERS/DECREASERS AS REQUIRED. TOTAL CONNECTED LOAD: 1,437± CFH. OPERATING PRESSURE: 2-PSI.

STEEL,


ABOVE-GROUND, TYP.

30"-36"

PLASTIC,
BELOW-GROUND,TYP.

CONTACT: DOMINION EAST OHIO GAS

- AKRON, OH PHONE: 330-664-2409 3. GENERATOR REGULATOR TO BE ROOTS(ITRON) B34-R (OR EQUAL), COMMERCIAL GRADE, WITH INTERNAL RELIEF. PIPE/BODY SIZE, SPRING, AND ORIFICE SELECTIONS BY MANUFACTURER/REP
- WITH 2-PSI INLET PRESSURE, AND 9-INCH± OUTLET PRESSURE. CONNECTED LOAD: 1,473 CFH±. NOTE: TYPICAL OPERATING PRESSURE 7-11 INCHES. CONFIRM WITH GENERATOR MANUFACTURER. 4. PROVIDE CAPPED 1/2" TEE FITTING, TO ALLOW CONNECTION OF PRESSURE MEASURING INSTRUMENT,
- UPSTREAM AND DOWNSTREAM OF REGULATOR, PER INTERNATIONAL FUEL GAS CODE. DOWNSTREAM TEE FITTING TO BE A MINIMUM OF 10 PIPEØ FROM REGULATOR.
- 5. LOCATE VALVES, PIPING, ETC. SO AS NOT TO INTERFERE WITH GENERATOR ACCESS. FIELD LOCATE RISER LOCATION AT GENERATOR TO BEST SUIT ACTUAL GENERATOR INSTALLED, CONSIDERING GENERATOR LOCATION, CONFIGURATION, CONCRETE PAD, ETC.

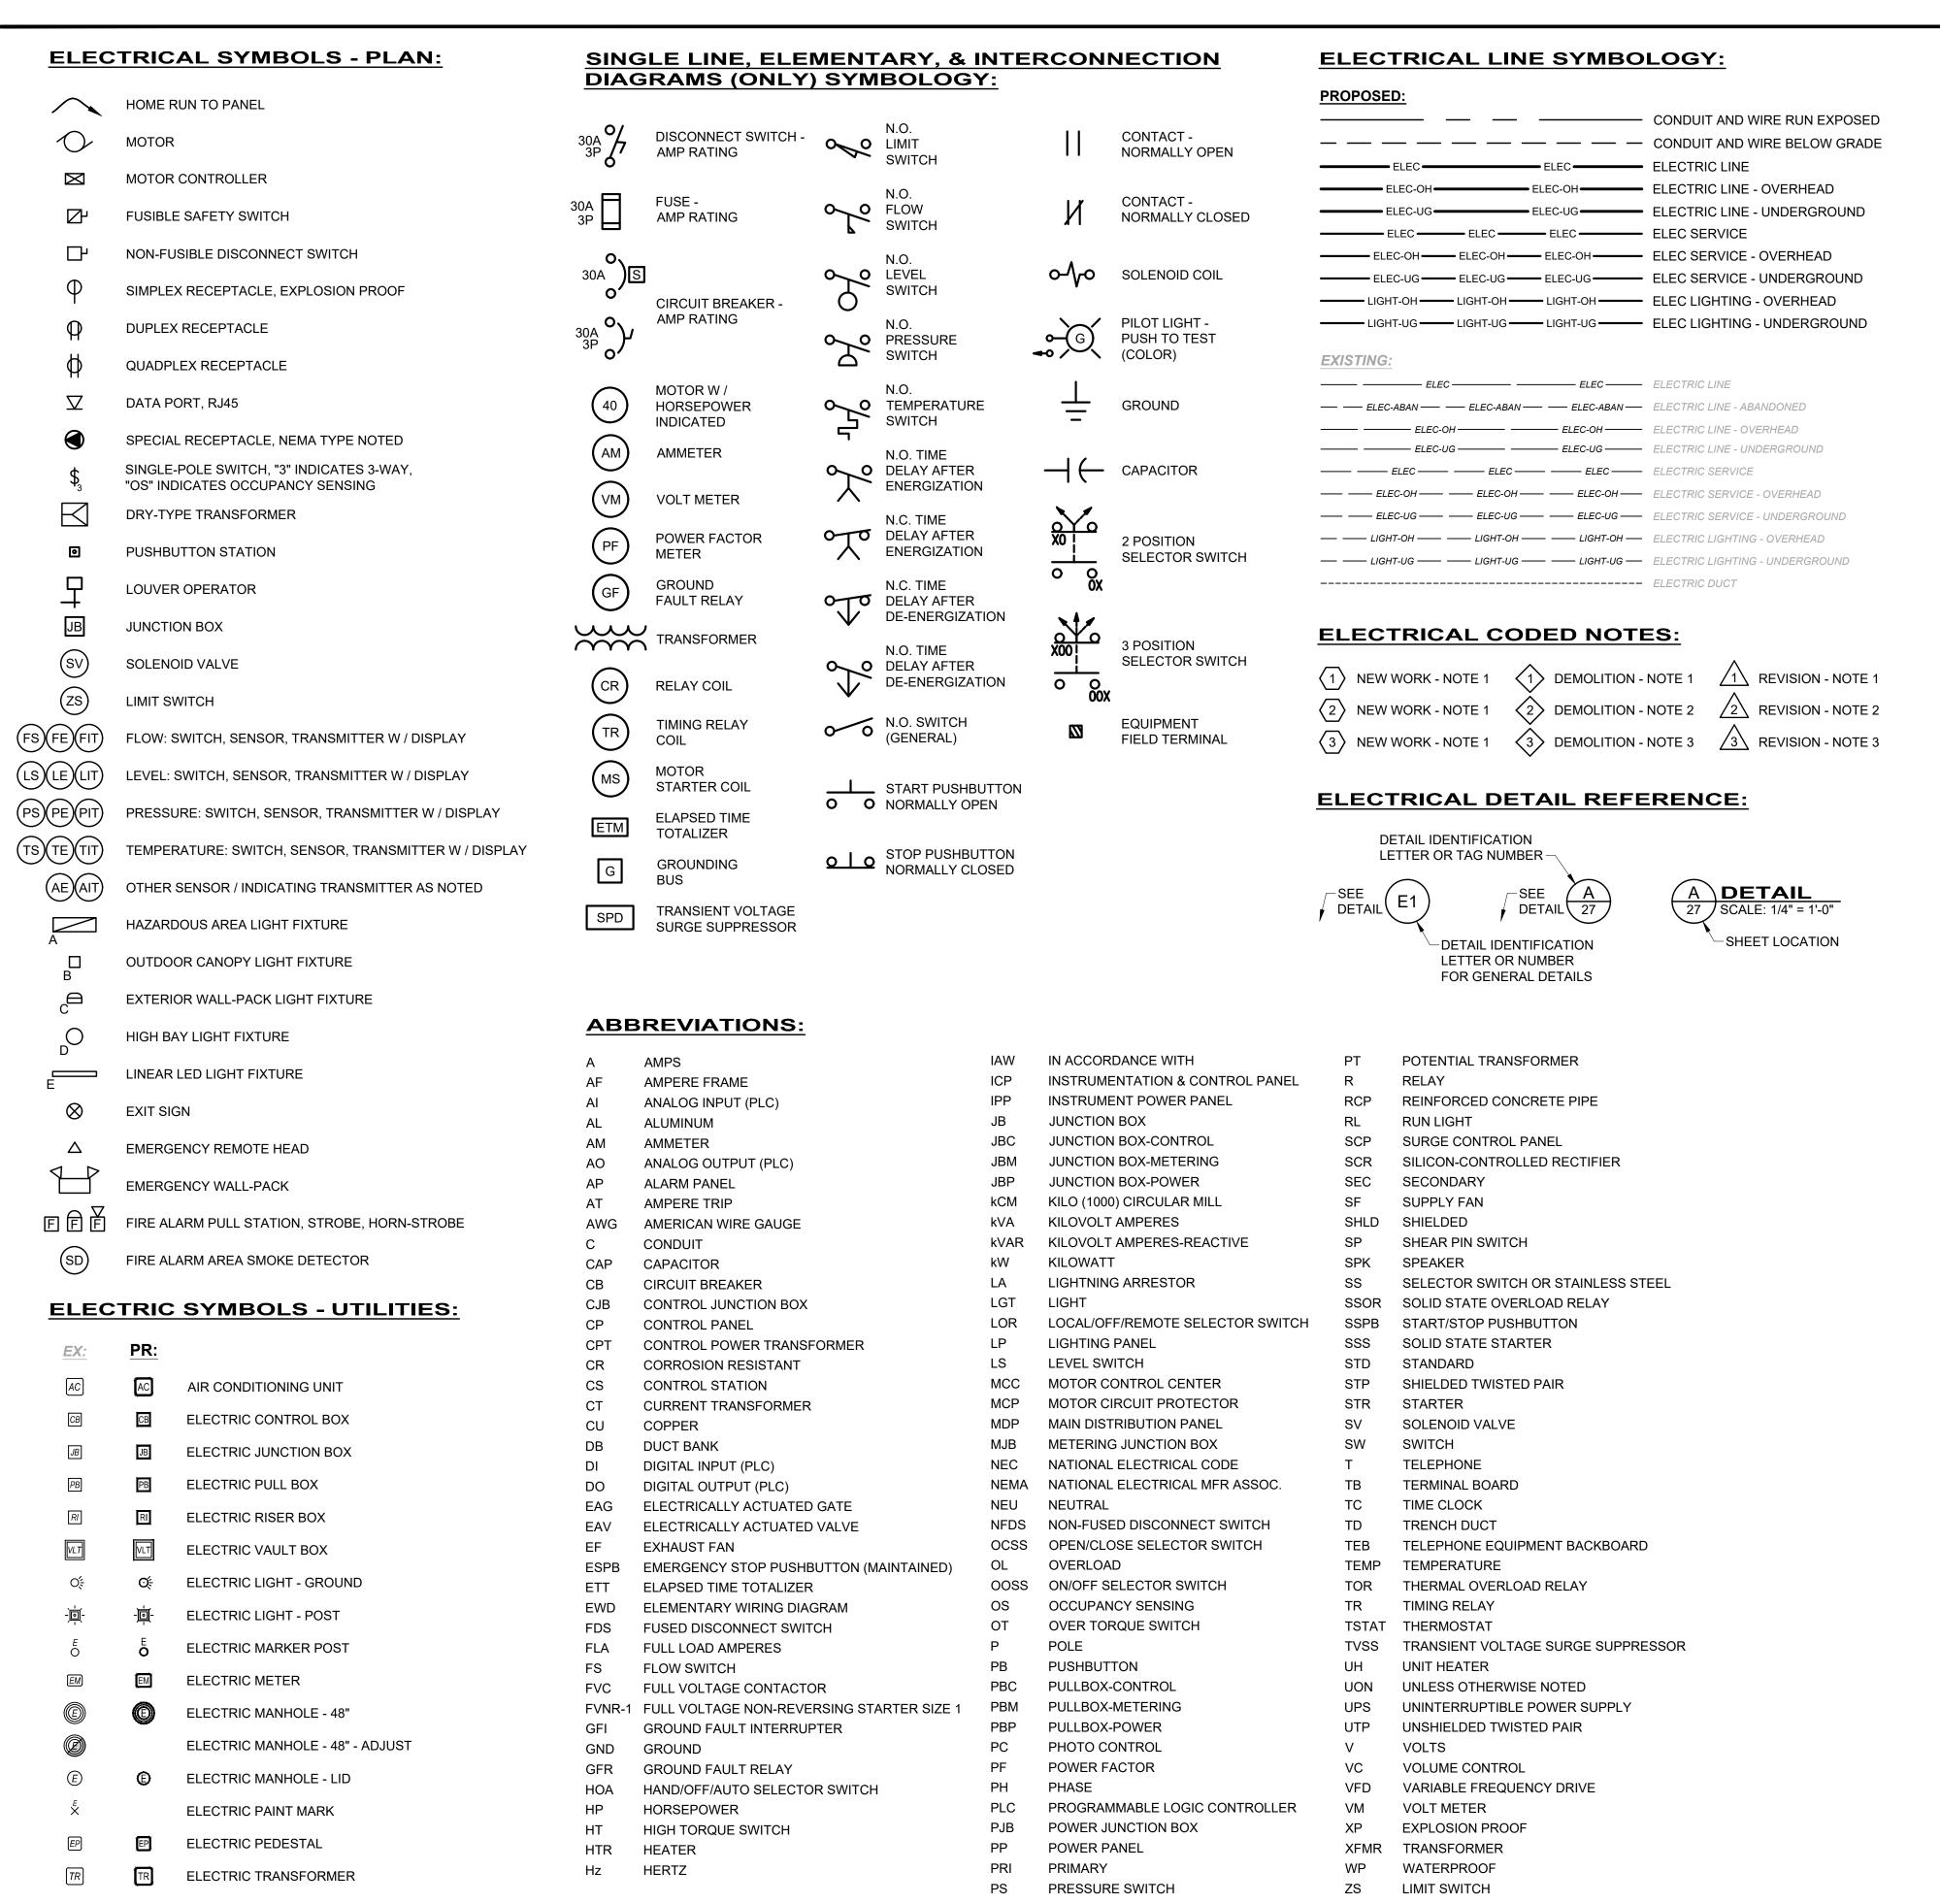

ELECTRICAL GENERAL NOTES:

- ALL ELECTRICAL EQUIPMENT AND MATERIALS WILL BE SELECTED AND INSTALLED IN COMPLIANCE WITH ALL APPLICABLE NATIONAL, STATE, AND LOCAL FIRE CODES, INCLUDING BUT NOT LIMITED TO ALL PERTINENT NFPA REGULATIONS. IT IS THE ELECTRICAL CONTRACTOR'S RESPONSIBILITY TO ENSURE COMPLIANCE WITH THESE CODES.
- 2. DO NOT INSTALL DEVICES SCALED FROM THESE DRAWINGS. ALL DEVICES SHALL BE INSTALLED AT LOCATIONS SHOWN IN THE APPROVED CONDUIT/DEVICE LAYOUT DRAWINGS AND WITH DIMENSIONS TAKEN IN THE FIELD.
- 3. ELECTRICIAN TO VISIT SITE AND VERIFY ALL EXISTING CONDITIONS PRIOR TO BID.
- 4. NO DUCTWORK OR PIPING TO BE RUN ABOVE ELECTRICAL PANELS OR THROUGH ELECTRICAL EQUIPMENT ROOMS. ELECTRICIAN SHALL COORDINATE WITH ALL TRADES FOR EQUIPMENT LAYOUTS PRIOR TO ROUGH-IN OF ALL SYSTEMS.
- . MANUFACTURERS AND CATALOG NUMBERS SHOWN IN THE LIGHT FIXTURE SCHEDULE ARE PROVIDED TO INDICATE DESIRED LIGHT FIXTURE CHARACTERISTICS. IT IS THE INTENT OF THE DOCUMENTS TO ALLOW ALTERNATE MANUFACTURERS TO PROVIDE LIGHTING PRODUCTS FOR THE PROJECT, AS LONG AS PROPOSED ALTERNATES PROVIDE THE SAME GENERAL DESIGN AND LIGHTING CHARACTERISTICS AS NOTED IN THE LIGHT FIXTURE DESCRIPTION.
- 6. ELECTRICIAN TO CONFIRM LOCATIONS OF ALL ELECTRICAL EQUIPMENT AND ELECTRICAL CHARACTERISTICS OF PROCESS EQUIPMENT PROVIDED BY OTHER TRADES PRIOR TO INSTALLING ROUGH-INS AS SHOWN ON THE ELECTRICAL PLANS. ALL SHOP DRAWING REQUIREMENTS WILL BE CONSIDERED AS THE MEANS AND METHODS OF INSTALLATION.
- 7. THIS PROJECT INVOLVES WORK AT AN INDUSTRIAL FACILITY AND THE CONTRACTOR IS EXPECTED TO PROVIDE CRAFTSMANSHIP REFLECTING THE NATURE OF THE FACILITY. CONDUITS IN PROCESS AREAS ARE TO BE SURFACE MOUNTED RIGID GALVANIZED STEEL (RGS). IN CLASSIFIED AREAS SEAL ALL CONDUITS TO RESTRICT THE PASSAGE OF GASSES AND VAPORS, AND ARRANGE SEALING FITTING DRAINS IN CONDUIT SYSTEMS TO PREVENT ACCUMULATION OF CONDENSATE ABOVE SEALS. ALL CONDUITS ENTERING OR LEAVING A MOTOR CONTROL CENTER, CONTROL PANEL, VALVE ACTUATOR, INSTRUMENT, A BUILDING, OR A PANELBOARD SHALL BE MADE WATERTIGHT USING AN INFLATABLE SEALED BLADDER DUCT SEALING SYSTEM, RAYCHEM 'RAYFLATE' DUCT SEALING SYSTEM RDSS OR APPROVED EQUAL. ALL HARDWARE IS TO BE STAINLESS STEEL UNLESS OTHERWISE DIRECTED.

ALL ENCLOSURES ARE TO BE RATED AS FOLLOWS (UON):

- OUTDOORS: NEMA 4X (STAINLESS STEEL)
- CLASSIFIED AREAS: NEMA 7
- INDOORS (CORROSIVE AREAS): NEMA 4X (STAINLESS STEEL)
- INDOORS (CONTROLLED ENVIRONMENT) NEMA 12
- 8. ELECTRICIAN SHALL REVIEW ALL OTHER TRADES' CONSTRUCTION DOCUMENTS AND/OR COORDINATE WITH OTHER TRADES AND VERIFY IF THERE ARE ANY ADDITIONAL ELECTRICAL REQUIREMENTS NOT SHOWN ON ELECTRICAL DRAWINGS. COST FOR WORK SHOWN ON OTHER TRADES' DRAWINGS SHALL BE INCLUDED IN BASE BID. ALL FIELD WIRING AND TERMINATIONS OF PROCESS EQUIPMENT AND INSTRUMENTATION AND CONTROLS SHALL BE THE RESPONSIBILITY OF THE ELECTRICIAN. ALL CABLES AND WIRES PROVIDED BY VENDORS SHALL BE INSTALLED AND TERMINATED BY THE ELECTRICIAN. WIRE ALL MISCELLANEOUS POWER AND CONTROLS AS REQUIRED TO PROVIDE A COMPLETE FUNCTIONING SYSTEM
- 9. A 4-20mA SIGNAL IS AN ANALOG SIGNAL USED TO TRANSMIT DATA (LEVEL, FLOW, ETC.) FOR PROCESS CONTROLS. THE ELECTRICIAN SHALL PROVIDE, INSTALL, AND TERMINATE SHIELDED TWISTED PAIRS (STP) WIRING IN RIGID GALVANIZED STEEL CONDUIT (RGS). RGS IS USED IN AN ATTEMPT TO REDUCE THE DISTORTION AFFECT FROM EMI AND RFI. BELOW GRADE CONDUITS SHALL BE PVC SCHED-40. PARALLEL RUNS OF DATA CONDUITS AND POWER CONDUITS SHALL BE SEPARATED BY 2 FEET. THE STP SHIELD SHALL BE GROUNDED AT THE CONTROL PANEL ONLY (DO NOT GROUND AT BOTH ENDS).
- 10. THE ELECTRICIAN SHALL BE RESPONSIBLE FOR LAYOUT AND COORDINATION OF OPENINGS AND CHASES AND SHALL PERFORM ALL CUTTING AND PATCHING AS REQUIRED TO INSTALL THEIR WORK. ALL CONCRETE HOUSE KEEPING PADS SHALL BE FRAMED AND POURED BY THE ELECTRICIAN. PADS SHALL HAVE A 45 DEGREE, 1" CHAMFER AROUND UPPER EDGE.
- 11. THE ELECTRICIAN SHALL INSTALL & DISTRIBUTE TEMPORARY POWER SERVICE FOR THE DURATION OF THIS PROJECT AS DEFINED IN DIVISION 1 SPECIFICATIONS. ALL COSTS ASSOCIATED WITH THE INSTALLATION, DISTRIBUTION AND MAINTENANCE OF THE TEMPORARY POWER IS THE RESPONSIBILITY OF THE ELECTRICIAN. THERE SHALL BE 480/277V,3PH,4W; 208/120V,3PH,4W; AND 120/240V,1PH,3W POWER AVAILABLE AT ALL LOCATIONS OF CONSTRUCTION AS DIRECTED IN FIELD AND AS SPECIFIED. ALL TEMPORARY EQUIPMENT, CONDUITS & CONDUCTORS SHALL BE COMPLETELY REMOVED AT COMPLETION OF PROJECT.
- 12. ALL ELECTRICAL EQUIPMENT, DEVICES, LIGHTING FIXTURES, CONDUIT, AND WIRING SHOWN ON THE ELECTRICAL DRAWINGS IS NEW UNLESS CLEARLY CALLED OUT AS EXISTING. ALL EXISTING ELECTRICAL EQUIPMENT THAT IS CALLED OUT TO BE REUSED SHALL BE INSPECTED IN THE FIELD BY THE ELECTRICIAN AND THE CONSTRUCTION MANAGER TO DETERMINE ITS CONDITION PRIOR TO STARTING ANY WORK. PROVIDE DOCUMENTATION TO OWNER INDICATING CONDITION OF THE EXISTING EQUIPMENT, AND REUSE EXISTING EQUIPMENT ONLY IF ALL PARTIES AGREE THE CONDITION IS ACCEPTABLE. ALL EXISTING EQUIPMENT DETERMINED TO BE UNUSABLE SHALL BE REPLACED WITH LIKE KIND AS DIRECTED BY THE OWNER. ANY OF THE OWNERS EQUIPMENT DETERMINED TO BE REUSED THAT IS DAMAGED BY ANY CONTRACTOR DURING SWITCHOVER SHALL BE REPLACED BY THAT CONTRACTOR. ALL EXISTING EQUIPMENT IS THE PROPERTY OF THE OWNER (NOT THE CONTRACTOR) AND SHALL BE TREATED ACCORDINGLY.
- 13. THE ELECTRICIAN SHALL BE HELD RESPONSIBLE TO ENSURE ALL CONTROLLERS TO BE INSTALLED ARE CAPABLE OF LOCKOUT / TAGOUT PRIOR TO INSTALLATION.
- 14. CONFORM TO THE NEC, OSHA, FIRE MARSHAL, BUILDING DEPARTMENT AND OTHER APPLICABLE CODES AND REGULATIONS. OBTAIN PERMITS, PAY ALL FEES, AND ARRANGE FOR REQUIRED INSPECTIONS.
- 15. ALL LIGHTING AND RECEPTACLE WIRING TO BE #12 XHHW WITH EQUIPMENT GROUND IN 3/4" C UNLESS OTHERWISE NOTED.
- 16. DO NOT MOUNT ANY LIGHT FIXTURE DIRECTLY OVER PIPING OR EQUIPMENT THAT WILL INTERFERE WITH NORMAL LIGHTING DISTRIBUTION.
- 17. SIZE JUNCTION BOXES AS REQUIRED PER NEC. PROVIDE BARRIER TYPE TERMINAL STRIPS, AND ALL WIRING TO BE IN CONDUIT.
- 18. SIZE PULL BOXES (PB) AS REQUIRED PER NEC.
- 19. PROVIDE SEPARATE PB'S FOR CONTROL AND POWER.
- MOTOR OVERLOAD SETTING SHALL BE FIELD SELECTED PER MOTOR NAME PLATE CURRENT AND INSTALLED ACCORDINGLY.
- 21. MOUNT LOCAL CONTROLS AND SERVICE DISCONNECTS ON WALL NEAREST EQUIPMENT WHERE POSSIBLE. (MAXIMUM 60" ABOVE FINISHED FLOOR OR FINAL GRADE, MAXIMUM LATERAL DISTANCE FROM WALL TO EQUIPMENT 10 FEET).
- 22. ALL FEEDERS RUN BELOW GRADE SHALL BE RUN IN PVC CONDUIT AT MINIMUM 3'-0" BELOW FINISHED GRADE, TRANSITION TO ABOVE GRADE SHALL BE MADE USING FACTORY PVC COATED RIGID STEEL CONDUIT SWEEPS.

rdantas

ISSUED FOR:	REVIEW	ON	REVISION	DATE	
ISSUE DATE:	10/3/2025				
SCALE:	A/N				
DESIGNED BY:	ELE				
DRAWN BY:	ELE				
CHECKED BY:	IDB				

LAKESHORE EAST ECAST ECA

PROJECT NO.

230264

DISCIPLINE


E-01

SHEET OF

42 48

ELECTRICAL


SHEET NAME

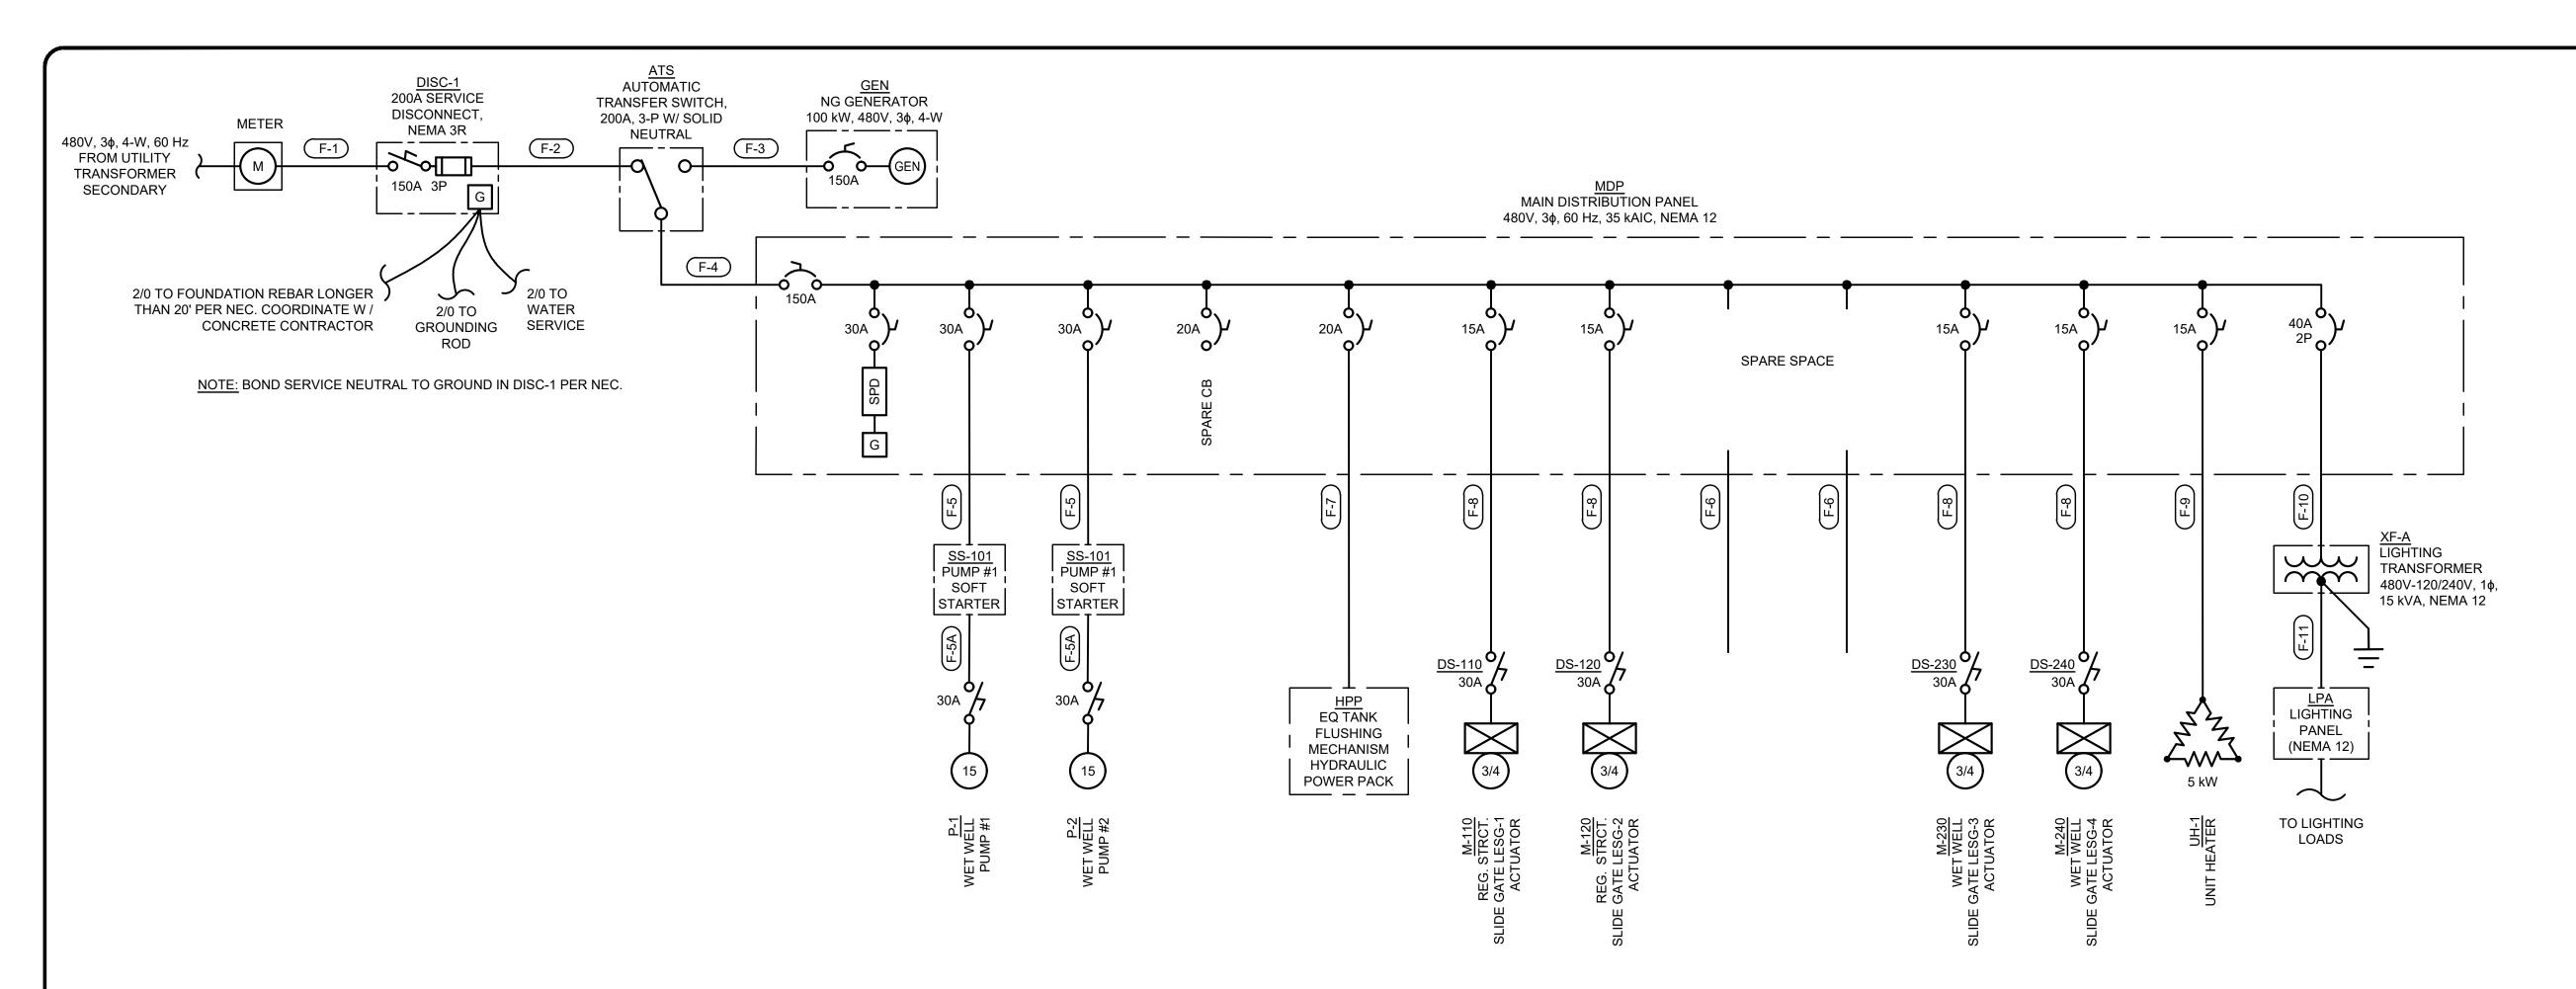

EQ BASIN ONE-LINE DIAGRAM

	POW	ER & CONT	ROL FEEDER SCHE	DULE	
TAG	EQUIPMENT	POWER SOURCE	CONDUCTOR SIZE + GND	CONTROL WIRE DESTINATION	CONTROL WIRES
F-1	SERVICE DISCONNECT SWITCH, DISC-1	UTILITY TRANSFORMER	(3) 3/0 + (1) 3/0 NEU IN 2-1/2"C	N/A	N/A
F-2	AUTOMATIC TRANSFER SWITCH, ATS	DISC-1	(3) 3/0 + (1) 3/0 NEU + (1) #4 GND IN 2-1/2"C	N/A	N/A
F-3	AUTOMATIC TRANSFER SWITCH, ATS	GEN	(3) 1/0 + (1) 1/0 NEU IN 4"C + (1) #4 GND IN 2-1/2"C	GEN	(2) 2-CS RS-485 CABLE [1 SP] IN 3/4"C
F-4	MAIN DISTRIBUTION PANEL, MDP	ATS	(3) 1/0 + (1) 1/0 NEU IN 4"C + (1) #4 GND IN 2-1/2"C	N/A	N/A
F-5 (TYP OF 2)	WET WELL PUMP SOFT STARTERS, SS-101 & SS-102	MDP	(3) #10 + (1) #12 GND IN 3/4"C	SCTP	(16) #14 IN 3/4"C
F-5A (TYP OF 2)	WET WELL PUMPS, P-1 & P-2	SS-101, SS-102	(3) #10 + (1) #12 GND IN 3/4"C	SS-101 & SS-102	(1) 2-CSC IN 3/4"C
F-6 (TYP OF 2)	SPARE PLUG VALVE ACTUATOR FEEDER	MDP	EMPTY 3/4"C	SCTP	EMPTY 3/4"C
F-7	EQ TANK HYDRAULIC POWER CENTER, HPP	MDP	(3) #12 + (1) #12 GND IN 3/4"C	N/A	N/A
F-8 (TYP OF 4)	SLIDE GATE ACTUATORS REGULATOR STRUCTURE: M-101 & M-102 WET WELL: M-201 & M-202	MDP	(3) #12 + (1) #12 GND IN 3/4"C	SCTP	(3) 2-CSC IN 3/4"C + (8) #14 IN 3/4"C
F-9	ELECTRICAL UNIT HEATER, <u>UH-1</u>	MDP	(3) #12 + (1) #12 GND IN 3/4"C	N/A	N/A
F-10	LIGHTING TRANSFORMER, XF-A	MDP	(2) #8 + (1) #8 GND IN 3/4"C	N/A	N/A
F-11	LIGHTING PANEL - <u>LPA</u>	XF-A	(2) #4 + (1) #4 NEU + (1) #8 GND IN 1"C	N/A	N/A

			FOLLOW CHAPTER	MENTOR, OHIO 44060	(440) 951-9000
DATE					
REVISION					
ON					
REVIEW	10/3/2025	AS NOTED	ELE	ELE	JPB
ISSUED FOR:	ISSUE DATE:	SCALE:	DESIGNED BY:	DRAWN BY:	CHECKED BY:
CITY OF WILLOUGHBY			LAKE COUNTY	ELECTRICAL - E SERIES	SINGLELINE DIAGRAM & SCHEDULES
			CT NO. 26 PLINE		
Е		SHEET		CA	L
	SHEET 43	E-	υ2	OF 4.9	•

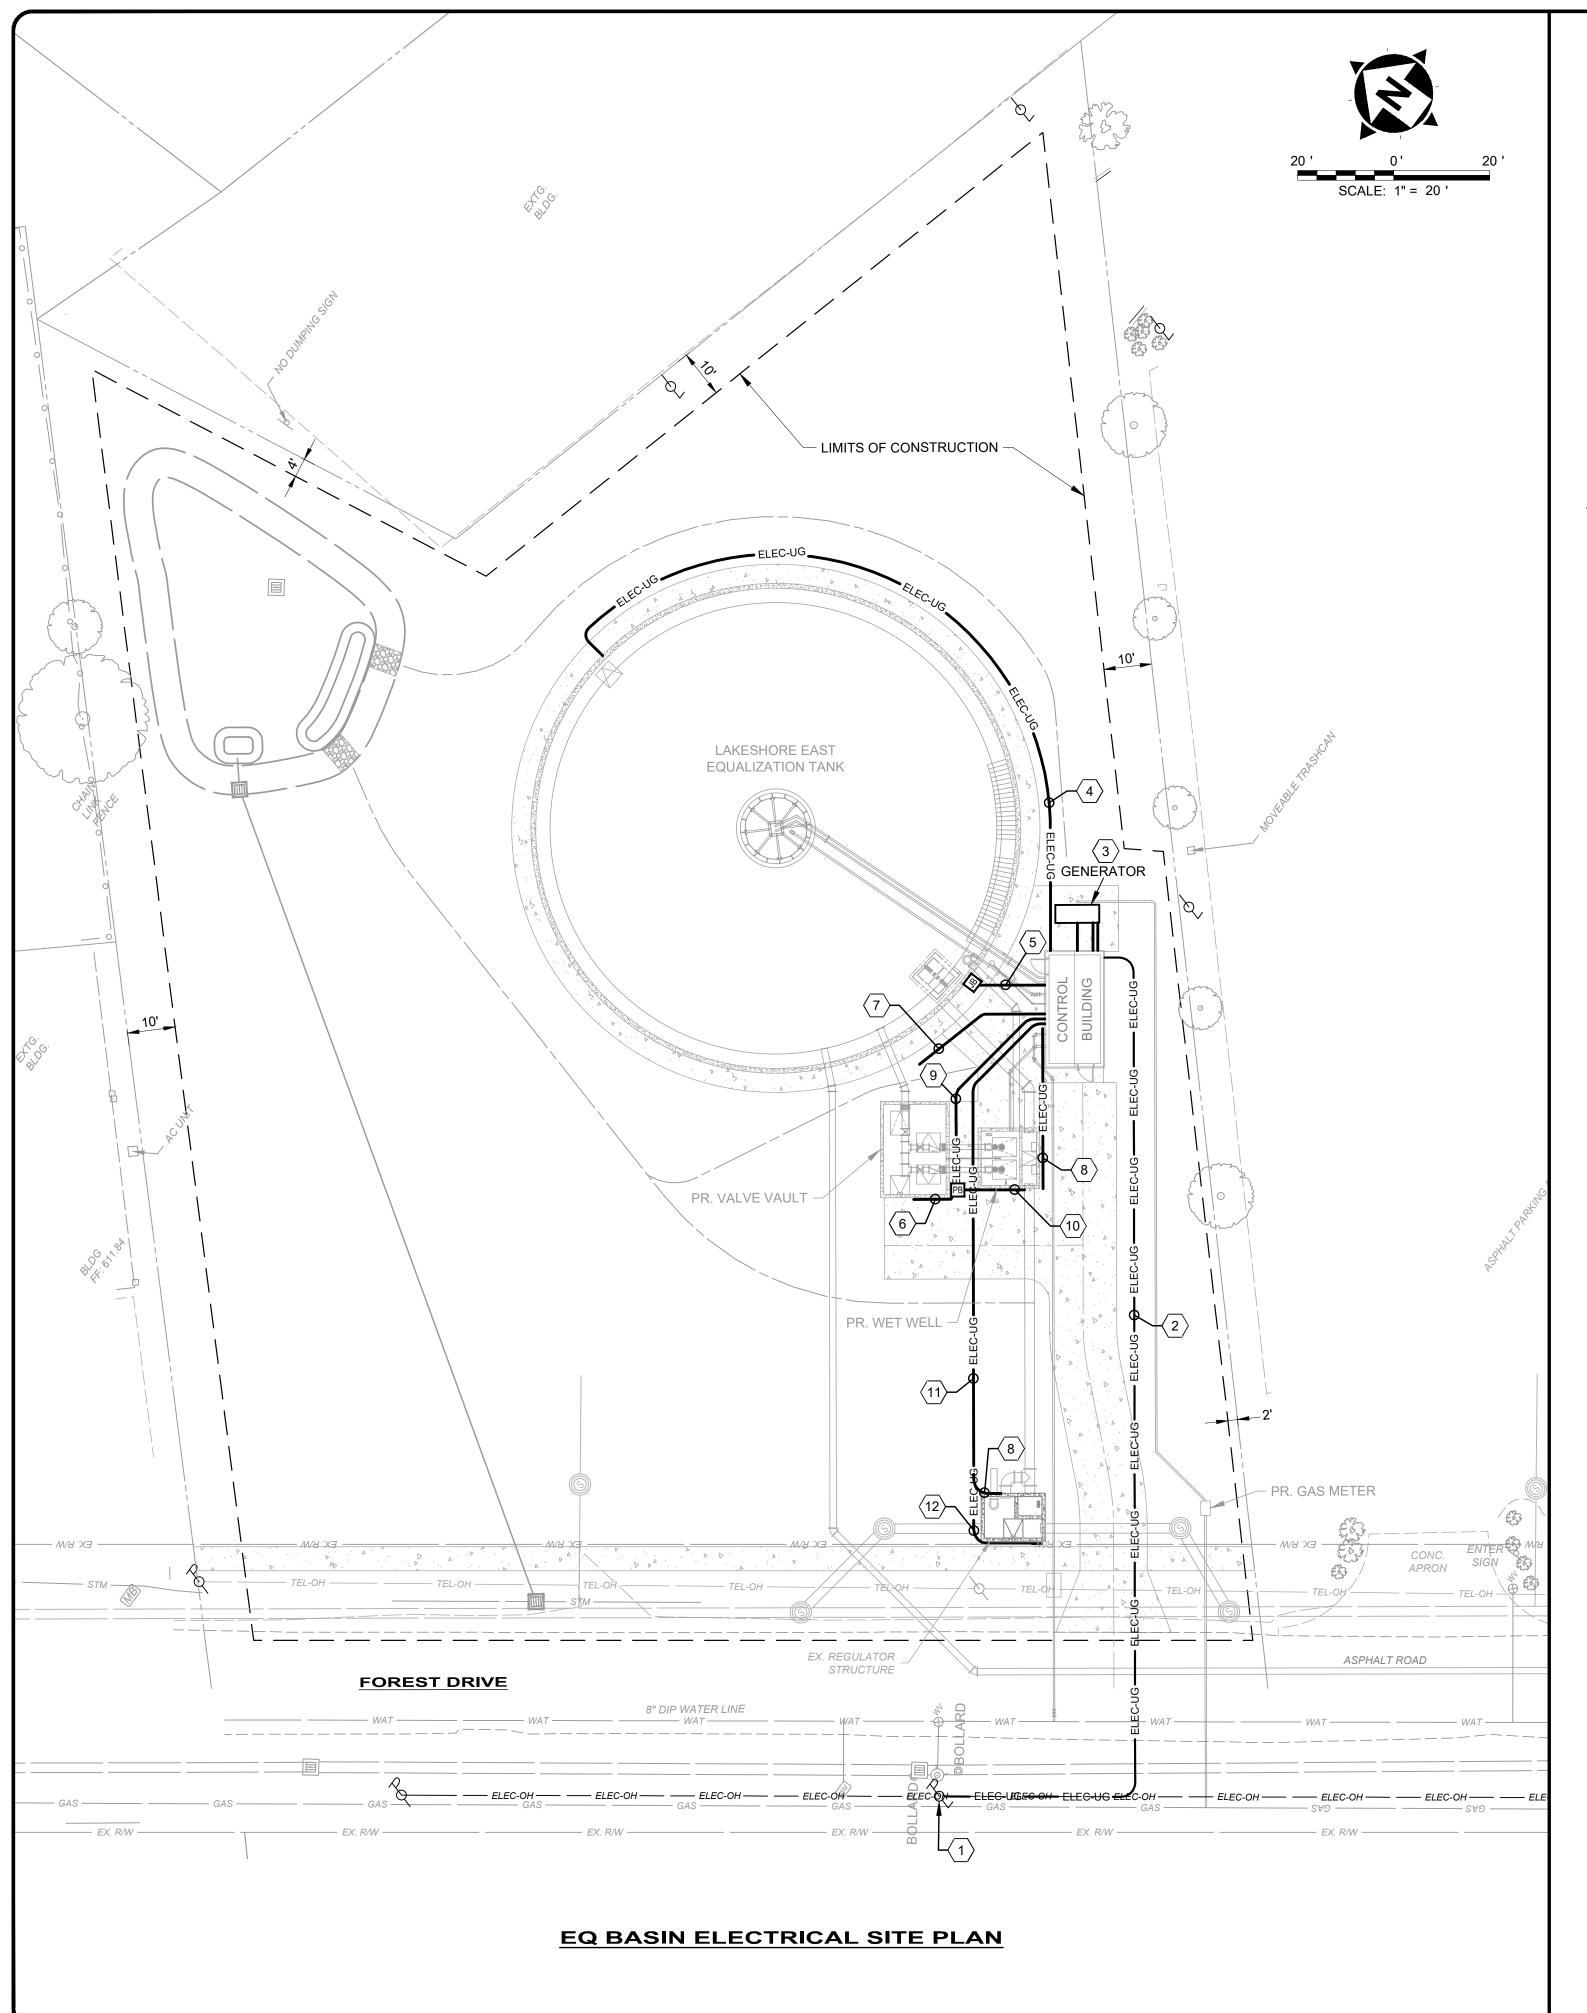

t:\2023\230264\DWG\SHEETS\PHASE II\E_230264 - ELECTRICAL SITE PLANS PHASE II.DWG - 44 ELECTRICAL SITE PLAN - 10/1/2025 8:26:56 PM - CORY SCOT

GENERAL NOTES:

- 1. ELECTRICAL UTILITY OF RECORD IS THE ILLUMINATING COMPANY, A FIRSTENERGY COMPANY. ALL SERVICE EQUIPMENT AND INSTALLATION MEANS & METHODS TO MEET THEIR REQUIREMENTS.
- 2. PROPOSED UNDERGROUND SERVICE DUCT BANKS TO UTILIZE 36" SWEEPS, MINIMUM; ALL OTHERS TO UTILIZE 24" SWEEPS, MINIMUM.
- 3. MINIMUM SIZE OF UNDERGROUND DUCT BANK CONDUIT IS 1-1/4". TRANSITION TO SMALLER CONDUIT ON FEEDER SCHEDULE ONCE ABOVEGROUND.
- 4. ALL DUCT BANKS SHOWN ARE DIAGRAMMATIC AND SHOULD NOT BE USED SOLELY FOR INSTALLATION. SEE DETAIL DRAWINGS FOR FULL ACCOUNTING OF DUCT BANK CONDUIT & CONDUCTORS.
- 5. COORDINATE CONDUIT PENETRATIONS INTO CONTROL BUILDING WITH PROCESS AND MECHANICAL CONTRACTORS TO AVOID INTERFERENCES WITH UNDERGROUND PIPING, ESPECIALLY BETWEEN BUILDING AND EQ TANK.
- 6. ALL CONDUIT ENTERING ROAD RIGHT-OF-WAY SHALL CONFORM TO ODOT STANDARDS.

X CODED NOTES:

- 1. EXISTING POWER POLE, UTILITY TO INSTALL TRANSFORMERS FOR 480V / 3φ / 4-W / 200A SERVICE. INSTALL 20' AERIAL CONDUIT WITH WEATHERCAP & SEAL, TRANSITION TO UNDERGROUND CONDUIT RUNNING PARALLEL TO FOREST DR. ROADWAY.
- 2. ELECTRICAL SERVICE FEEDER, CONTRACTOR TO INSTALL 2-1/2" SCH-40 PVC CONDUIT, UTILITY TO INSTALL (4) #3/0 CONDUCTORS. SECTION BENEATH FOREST DR. TO MEET ODOT STANDARDS, ALL OTHERS TO FOLLOW VERDANTAS SPECIFICATION DIVISION 26 REQUIREMENTS.
- 3. NATURAL GAS-FUELED BACKUP GENERATOR, 100 kW. SEE SHEET E-04 FOR DETAILS.
- 4. DUCT BANK FOR CONVENIENCE RECEPTACLE INSTALLED AT EQ TANK NORTH ACCESS HATCH. ROUTE AROUND OUTSIDE OF SIDEWALK SURROUNDING TANK. FASTEN VERTICAL TRANSITION TO CONCRETE TANK WALL PER SPECIFICATIONS BEFORE POURING SIDEWALK CONCRETE. INSTALL RECEPTACLE 18" ABOVE TOC.
- 5. EQ TANK LEVEL SENSORS OVERHEAD CONDUIT, ROUTE IN OVERHEAD RACK PER SPECIFICATION SECTION 260529 AT A HEIGHT TO FACILITATE CONDUIT ENTRY INTO TOP OF CONTROL BUILDING WALL. CONTAINS THE FOLLOWING INSTRUMENT FEEDERS, EACH ONE RUN IN 3/4"C:
- 5.1. FLUSHING CHAMBER HIGH WATER LEVEL SWITCH, (2) #14 TO HPP
- 5.2. TANK HIGH WATER OVERFLOW SWITCH, (2) #14 TO SCTP
- 5.3. TANK LEVEL TRANSMITTER, (1) 2-CSC TO SCTP
- 6. SPARE PLUG VALVE FEEDER "F-6" DUCT BANK, (2) 1-1/4"C. INSTALL CONDUIT PER DETAILS ON SHEET E-05 ABOVE TOC, CAP AND LEAVE IN PLACE.
- 7. SPARE PLUG VALVE FEEDER "F-6" DUCT BANK, (2) 1-1/4"C. INSTALL CONDUIT UNDERGROUND TO LOCATION SHOWN, CAP, AND LEAVE IN PLACE WITHOUT VERTICAL TRANSITION TO ABOVEGROUND. MARK CONDUIT END BY DRIVING 3'-LG #8 REBAR VERTICALLY TO SAME DEPTH OF CONDUIT.
- 8. SLIDE GATE ACTUATOR FEEDER "F-8" DUCT BANK, (3) 1-1/4"C. SEE FEEDER SCHEDULE ON SHEET E-02 FOR CONDUCTORS, TYPICAL OF (3).
- 9. COMBINED DUCT BANK FOR FEEDERS (2) "F-5A" & (1) "F-6" + WET WELL SENSORS JUNCTION BOX, (8) 1-1/4"C.SEE FEEDER SCHEDULE ON SHEET 01-E-02 FOR CONDUCTORS. SEE SHEET 01-E-05 FOR INSTALLATION DETAILS.
- 10. WET WELL SENSORS JUNCTION BOX DUCT BANK, (12) #14 IN 1-1/4"C + (2) 2-CSC IN 1-1/4"C. SEE SHEET E-05 FOR INSTALLATION DETAILS.
- 11. REGULATOR STRUCTURE DUCT BANK, (2) SLIDE GATE FEEDERS "F-8" + WATER LEVEL TRANSMITTER "LIT-100", (4) 1-1/4"C
- 12. COMBINED SLIDE GATE LESG-1 FEEDER "F-8" & LEVEL TRANSMITTER LIT-100 DUCT BANK, (3) #12 + (1) #12 GND & (4) 2-CSC, EACH IN (1) 1-1/4"C; (2) 1-1/4"C TOTAL.

danta

8150 STERL MENTOR, O (440) 951-90

UGHBY	ISSUED FOR:	REVIEW	ON	REVISION
r eo basin	ISSUE DATE:	10/3/2025		
	SCALE:	AS NOTED		
WILLOUGHBY, OHIO	DESIGNED BY:	JPB		
ERIES	DRAWN BY:	JPB		
NA IO	CHECKED BY:	V.		

LAKESHORE EAST EQ BASIN

PHASE II


MILLOUGHBY, OHI

ELECTRICAL - E SERIES

ELECTRICAL SITE PLAN


ELECTRICAL

E-03

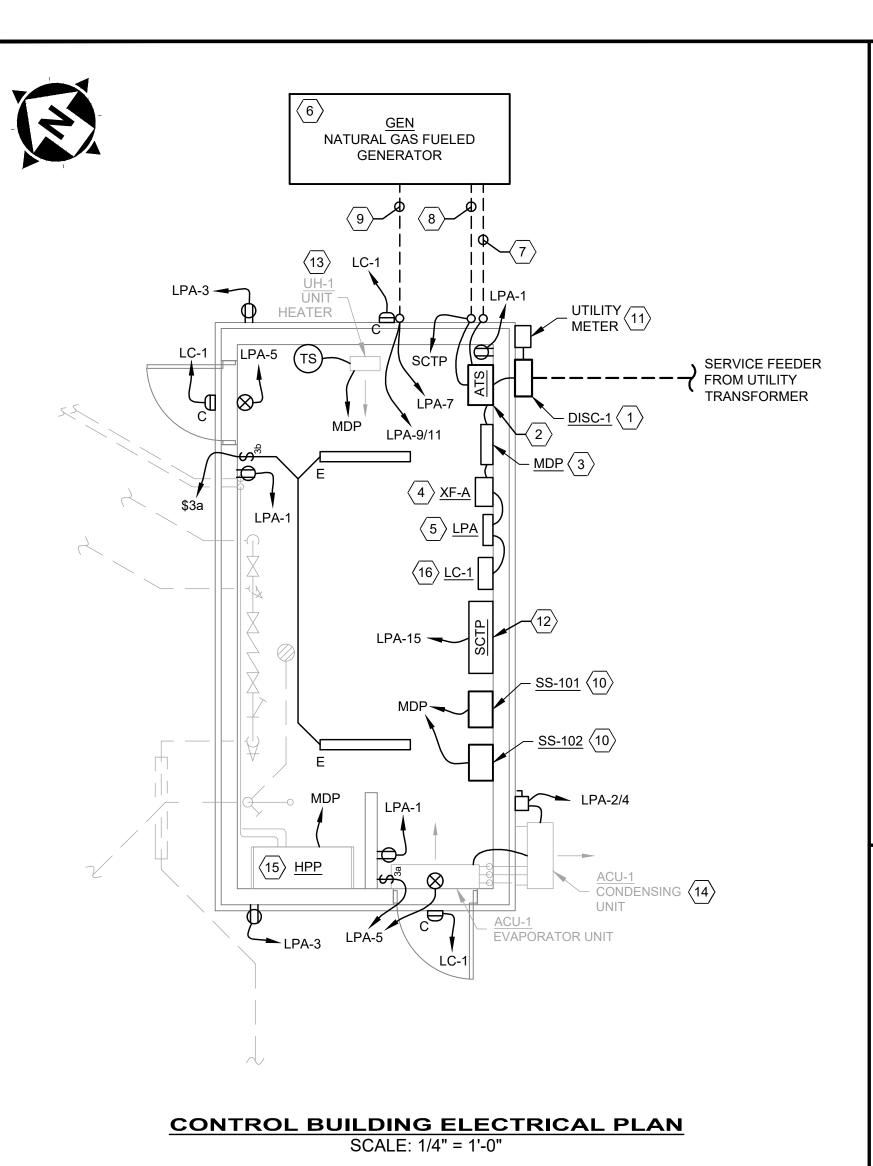

$\langle x \rangle$ CODED NOTES:

- 1. 480V, 3φ, 200A SERVICE DISCONNECT SWITCH <u>DISC-1</u>, FUSED AT 150A, NEMA 3R ENCLOSURE
- 2. 480V, 3φ, 200A AUTOMATIC TRANSFER SWITCH ATS, 3-POLE WITH SOLID NEUTRAL, NEMA 12 WALL-MOUNTED ENCLOSURE
- 3. 480V, 3φ, 200A MAIN DISTRIBUTION PANEL MDP, NEMA 12 FLOOR-MOUNTED ENCLOSURE
- 4. 480V 120/240V, 15 kVA TRANSFORMER <u>XF-A</u>, 1 ϕ , NEMA 12 FLOOR-MOUNTED ENCLOSURE
- 5. LIGHTING PANEL <u>LPA</u>, 120/240V, 1φ, 3-W, NEMA 12 WALL-MOUNTED ENCLOSURE. SEE SCHEDULE THIS SHEET FOR DETAILS.
- 6. NATURAL GAS FUELED BACKUP GENERATOR <u>GEN</u>, 100 kW, 480/277V, 3φ, 60 Hz, 150A LCB, W/SOUND ATTENUATING WEATHER PROOF ENCLOSURE. SEE SPECIFICATION SECTION 263213.16 FOR DETAILS.
- 7. UNDERGROUND FEEDER (F-3) FROM GENERATOR TO ATS. SEE SCHEDULE ON SHEET #43, E-02 FOR DETAILS.
- 8. UNDERGROUND GENERATOR CONTROL WIRING TO ATS & SCTP. SEE FEEDER (F-3) SCHEDULE ON SHEET 43, E-02 FOR DETAILS.
- 9. GENERATOR BLOCK HEATER & BATTERY CHARGER FEEDERS FROM LPA, (2) SETS OF (2) #12 + (1) #12 GND IN COMMON 1-1/4"C.
- 10. WET WELL PUMPS 1&2 SOFT STARTERS $\underline{\text{SS-101}}$ & $\underline{\text{SS-102}}$, WALL-MOUNTED NEMA 12 ENCLOSURE, 480V / 3ϕ / 60 Hz / 15 HP
- 11. 200A METER SOCKET PER UTILITY STANDARDS, NEMA 3R ENCLOSURE
- 12. SCADA/TELEMETRY PANEL <u>SCTP</u>, NEMA 12 WALL-MOUNTED ENCLOSURE, 10" TOUCHSCREEN HMI, 6-PORT (RJ45) ETHERNET SWITCH, AND RADIO COMMUNICATIONS DEVICES TO INTERFACE WITH DIVERSION STRUCTURE CONTROL PANEL FROM PHASE I (DETAILS THIS SHEET). SEE FEEDER SCHEDULE ON SHEET #43, E-02 FOR FIELD WIRING REQUIREMENTS.
- 13. UNIT HEATER <u>UH-1</u> WITH REMOTE TEMPERATURE SWITCH, 480V / 3φ / 60 Hz / 5 kW. SEE MECHANICAL PLAN & SCHEDULE SHEET #40, M-01 FOR DETAILS.
- 14. SPLIT AIR CONDITIONING UNIT <u>ACU-1</u>, 240V / 1φ / 60 Hz. INSTALL 30A, 2-P, NEMA 3R, LOCAL DISCONNECT ON EXTERIOR WALL NEAR CONDENSING UNIT & EXTEND (2) #12 + (1) #12 GND IN 3/4"C TO INDOOR EVAPORATOR UNIT. SEE MECHANICAL PLAN & SCHEDULE SHEET #40, M-01 FOR DETAILS.
- 15. EQ TANK HYDRAULIC POWER PACK <u>HPP</u>, VENDOR SUPPLIED, CONTRACTOR INSTALLED, 480V / 3φ / 60 Hz FEEDER (F-7). SEE SCHEDULE ON SHEET #43, E-02 FOR DETAILS. SEE CIRCULAR TANK FLUSHING SYSTEM SPEC SECTION 464614 FOR FIELD WIRING REQUIREMENTS. COORDINATE CONDUIT PENETRATIONS WITH GENERAL CONTRACTOR.
- 16. EXTERIOR LIGHTING CONTACTOR <u>LC-1</u> WITH REMOTE PHOTOEYE CONTROLS, H-O-A SWITCH, AND OVERRIDE TIMER IN WALL-MOUNTED NEMA 12 ENCLOSURE

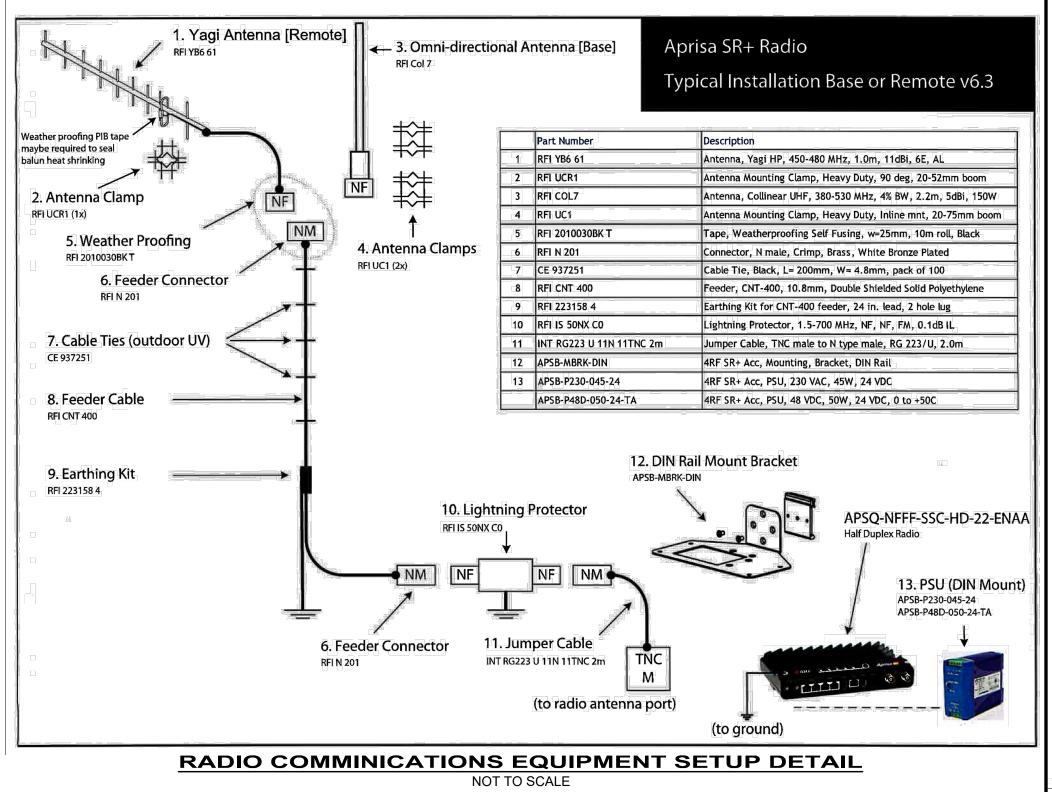

GENERAL NOTES:

- 1. ALL INTERIOR EQUIPMENT ENCLOSURES TO BE NEMA 12, WALL-MOUNTED, UON.
- 2. ALL LIGHTING PANEL CIRCUITS TO BE (2) #12 + (1) #12 GND IN 3/4"C, UON.
- 3. ALL EXTERIOR RECEPTACLES TO BE INSTALLED WITH WEATHERPROOF IN-USE COVERS.
- 4. MAINTAIN 42" OF CLEAR WORKING SPACE IN FRONT OF ALL 480V PANELS PER NEC.
- 5. ALL FLOOR-MOUNTED PANELS TO BE INSTALLED ON A 4" HOUSEKEEPING PAD PER NOTES ON SHEET# 42, E-01. EXTEND PADS 2" PAST THE OVERALL FOOTPRINT OF THE RESPECTIVE PANEL.

		LIGHT FIXTURE SCHEDULE	
DESIGNATION	DESCRIPTION	MANUFACTURER/MODEL	NOTES
С	EXTERIOR LED WALL-PACK W/ COLD WEATHER EMERGENCY BATTERY BACKUP	HOLOPHANE W4PLED-10C-700-40K-T3M-120-ELCW-BKSDP	4000K COLOR, 2200 LUMENS, VERII FINISH WITH ARCHITECT
E	LINEAR LED FIXTURE, GASKETED, VAPOR- TIGHT, LOW PROFILE, FROSTED LENSE W/ EMERGENCY BATTERY BACKUP	HOLOPHANE EMS-L48-6000LM-LPPFL-WD-MVOLT-40K-80CRI- E10WMCP	4000K COLOR, 6000 LUMENS
EXIT	EXIT SIGN, WHITE THERMOPLASTIC BODY W/ RED LETTERS, NICKEL-CADMIUM EMERGENCY BATTTERY BACKUP	LITHONIA LHQM-LED-R-SD	SELF-DIAGNOSTICS

LIGHTING FIXTURE SCHEDULE

NOTE: ALL FIXTURES WITH BATTERY BACKUP SHALL BE CAPABLE OF PROVIDING 100% OUTPUT FOR 90 MINUTES DURING POWER LOSS

PANELBOARD		LPA							
PANEL TYPE	NQC	DD OR EQ	UAL						
NEMA TYPE		NEMA 12							
/OLTAGE		240V/120V			PHASE				1
OCPD		80A			WIRE				3
MOUNTING		SURFACE			BUSS				100A
					•				
LOAD DE	ESCRIPTION	LOAD	BKR.	CCT. NO.	PHASE	CCT. NO.	BKR.	LOAD	LOAD DESCRIPTION
INTE	ERIOR RCPTS (GFCI)	540	20/1G	1	А	2	25/2	4560	ACLINIT ACLI 1
EXTE	ERIOR RCPTS (GFCI)	360	20/1G	3	В	4	23/2	4360	AC UNIT, ACU-1
	INTERIOR LIGHTS	85	15/1	5	А	6	15/1	300	SCADA PANEL, SCTP
GENERATOR	BATTERY CHARGER	360	15/1	7	В	8	20/1	180	EQ TANK NORTH RCPT
CENEDAT	TOR BLOCK HEATER	2000	20/2	9	Α	10	15/1	78	EXTERIOR LIGHTS VIA LC-1
GENERAI	IOR BLOCK HEATER	2000	20/2	11	В	12	20/1		SPARE
							8463 10143.75	VA VA	CONNECTED DEMAND
							42.27	A @ 240/	120V, 1P, 3W

LIGHTING PANEL "LPA" SCHEDULE

danta

REVISION DATE					
ON					
REVIEW	10/3/2025	AS NOTED	ELE	ELE	RSS
ISSUED FOR:	ISSUE DATE:	SCALE:	DESIGNED BY:	DRAWN BY:	СНЕСКЕD ВҮ:
<u>s</u>	<u> </u>	0)	OI+		

AKESHORE EAST EQ BASIN

PHASE II

WILLOUGHBY, OF

ELECTRICAL - E SERIES

CONTROL RILLI DING ELECTRICAL PLAN

PROJECT NO.

230264

DISCIPLINE


SHEET NAME


E-04

SHEET OF

45
48

ELECTRICAL

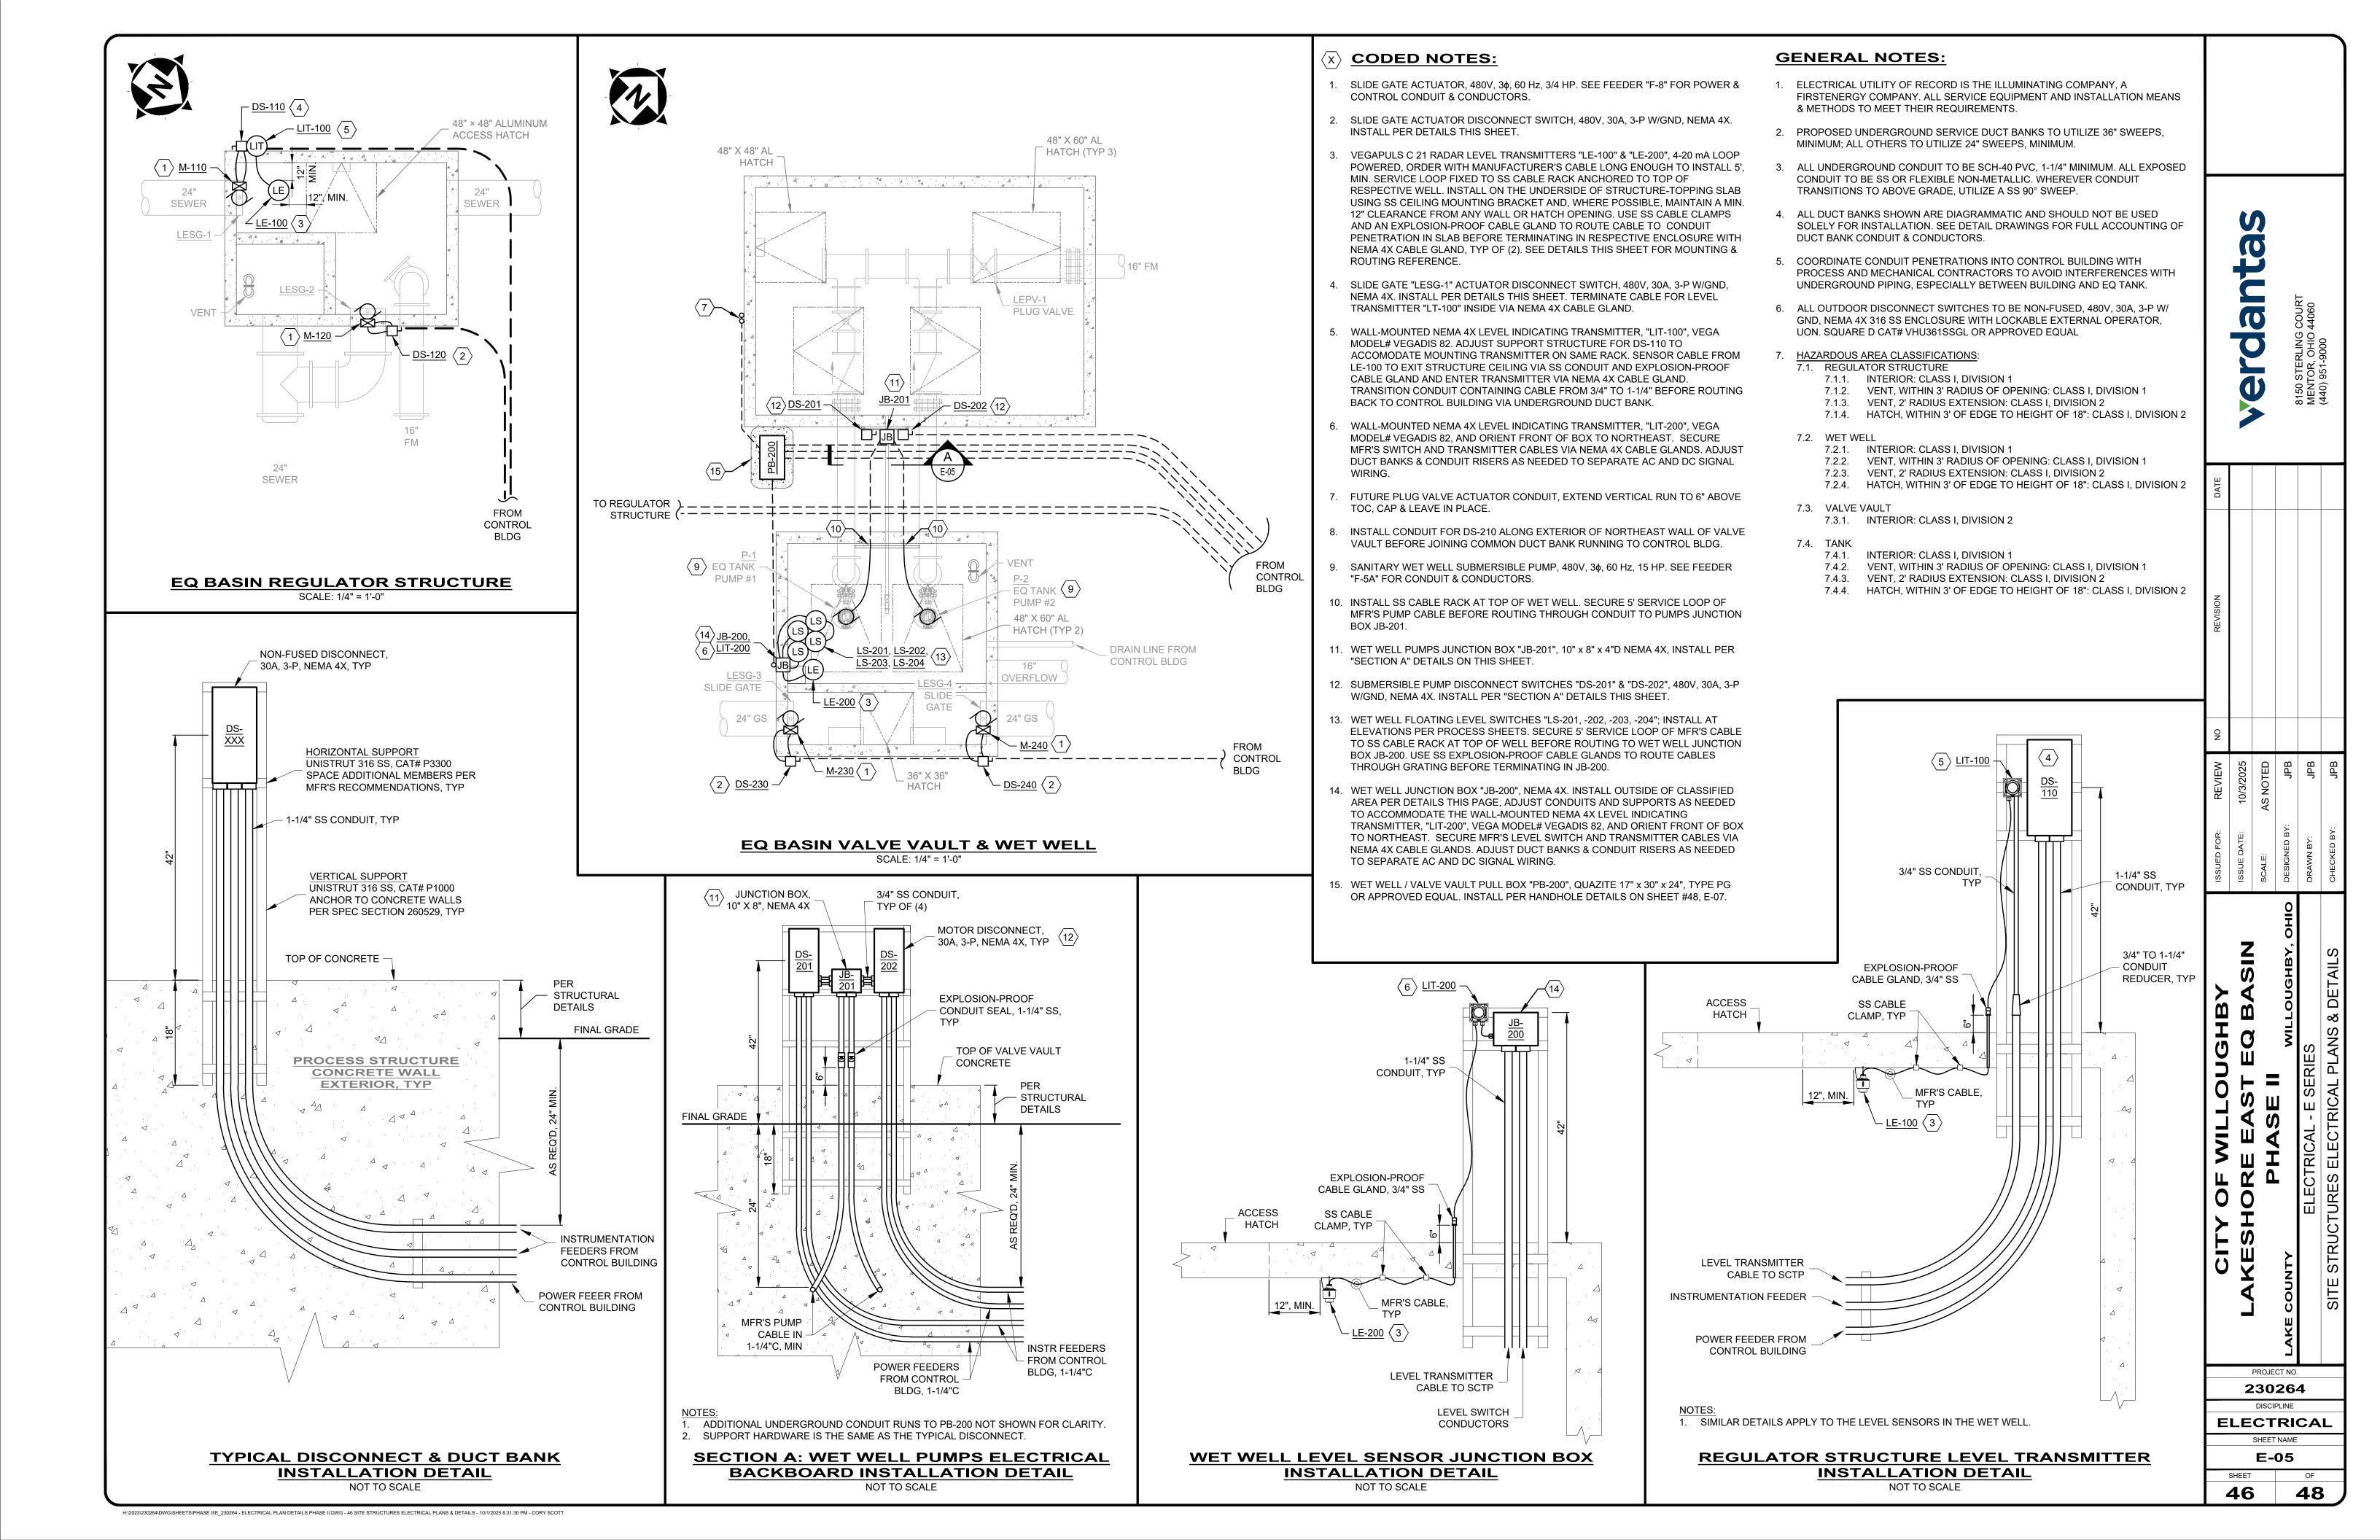

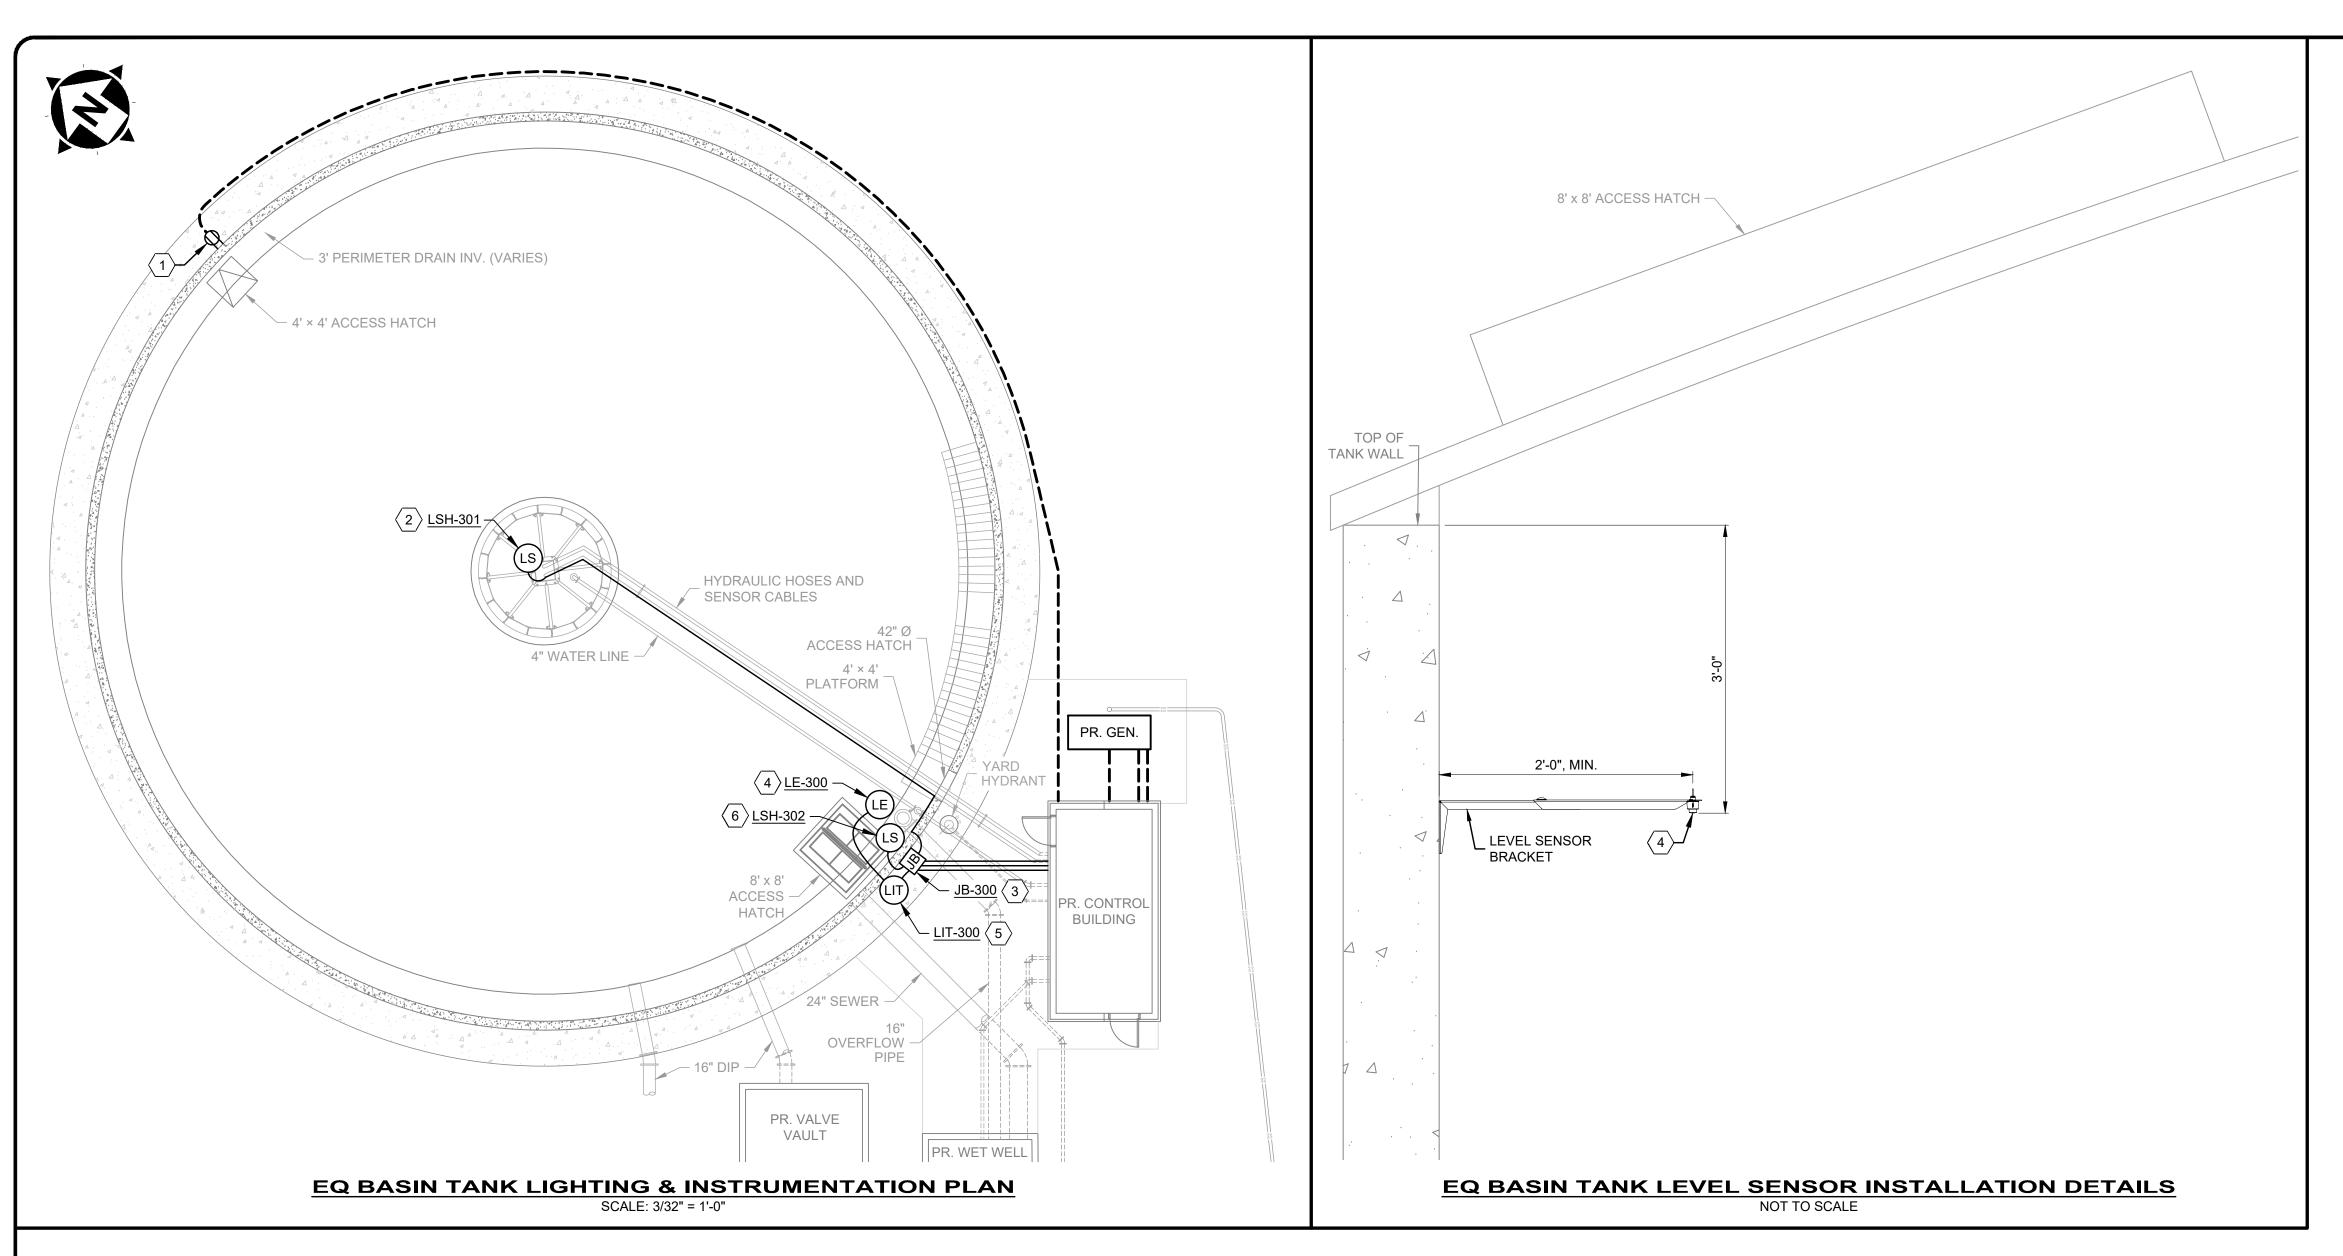

GENERAL NOTES:

- 1. ELECTRICAL UTILITY OF RECORD IS THE ILLUMINATING COMPANY, A FIRSTENERGY COMPANY. ALL SERVICE EQUIPMENT AND INSTALLATION MEANS & METHODS TO MEET THEIR REQUIREMENTS.
- 2. PROPOSED UNDERGROUND SERVICE DUCT BANKS TO UTILIZE 36" SWEEPS, MINIMUM; ALL OTHERS TO UTILIZE 24" SWEEPS, MINIMUM.
- 3. ALL UNDERGROUND CONDUIT TO BE SCH-40 PVC, 1-1/4" MINIMUM. ALL EXPOSED CONDUIT TO BE SS OR FLEXIBLE NON-METALLIC. WHEREVER CONDUIT TRANSITIONS TO ABOVE GRADE, UTILIZE A SS 90° SWEEP AND EXPANDERS/REDUCERS TO MATCH THE SIZE LISTED IN THE FEEDER SCHEDULE.
- 4. ALL DUCT BANKS SHOWN ARE DIAGRAMMATIC AND SHOULD NOT BE USED SOLELY FOR INSTALLATION. SEE DETAIL DRAWINGS FOR FULL ACCOUNTING OF DUCT BANK CONDUIT & CONDUCTORS.
- 5. COORDINATE CONDUIT PENETRATIONS INTO CONTROL BUILDING WITH PROCESS AND MECHANICAL CONTRACTORS TO AVOID INTERFERENCES WITH UNDERGROUND PIPING, ESPECIALLY BETWEEN BUILDING AND EQ TANK.
- **HAZARDOUS AREA CLASSIFICATIONS**:
- 6.4. TANK
 - 6.4.1. INTERIOR: CLASS I, DIVISION 1 6.4.2. VENT, WITHIN 3' RADIUS OF OPENING: CLASS I, DIVISION 1
 - 6.4.3. VENT, 2' RADIUS EXTENSION: CLASS I, DIVISION 2
- 6.4.4. HATCH, WITHIN 3' OF EDGE TO HEIGHT OF 18": CLASS I, DIVISION 2
- 6.5. VALVE VAULT 6.5.1. INTERIOR: CLASS I, DIVISION 2

CODED NOTES:


- 1. EQ BASIN CONVENIENCE RECEPTACLE, GFCI, INSTALL CONDUIT AND SUPPORTS PER DETAILS THIS SHEET TO MAINTAIN 6" CLEARANCE FROM BOTTOM OF RECEPTACLE TO FINISHED GRADE. INSTALL IN NEMA 4X GANG BOX WITH WEATHERPROOF IN-USE COVER. MAINTAIN 3' CLEARANCE FROM HATCH EDGES TO AVOID HAZARDOUS AREA.
- 2. EQ TANK FLUSHING RESERVOIR HIGH WATER LEVEL SWITCH "LSH-301", SUPPLIED BY VENDOR AND INSTALLED CONTRACTOR PER VENDOR'S REQUIREMENTS. RUN MFR'S CABLE THROUGH SS 3/4" CONDUIT WITH EXPLOSION-PROOF SEAL TO JUNCTION BOX MOUNTED ON EXTERIOR TANK WALL.
- 3. EQ TANK RESERVOIR LEVEL SENSOR JUNCTION BOX "JB-300", NEMA 4X, MOUNT AT A HEIGHT TO FACILITATE ROUTING CONDUIT OVERHEAD TO CONTROL BUILDING. MAINTAIN 3' CLEARANCE FROM HATCH EDGES TO AVOID HAZARDOUS AREA
- 4. RADAR LEVEL SENSOR "LE-300", VEGA MODEL# VEGAPULS C 21, 4-20 mA LOOP POWERED, MOUNTED TO TANK WALL 27' ABOVE BOTTOM OF TANK VIA SS ADJUSTABLE BRACKET CAT# MBD.AC TO EXTEND SENSOR 24" AWAY FROM WALL AND AT LEAST 12" FROM ROOF ACCESS HATCH EDGE. BE SURE TO AVOID ANY PROCESS PIPING OR OTHER OBSTRUCTIONS BETWEEN SENSOR FACE AND BOTTOM OF TANK. ORDER WITH MANUFACTURER'S CABLE LONG ENOUGH TO REACH LIT-300. USE SS EXPLOSION-PROOF CONDUIT BODIES & SEAL TO ROUTE CABLE THROUGH TANK WALL BEFORE TERMINATING IN LEVEL TRANSMITTER WITH NEMA 4X CABLE GLAND. SEE DETAIL THIS SHEET FOR INSTALLATION REFERENCE.
- 5. WALL-MOUNTED NEMA 4X LEVEL INDICATING TRANSMITTER, "LIT-300", VEGA MODEL# VEGADIS 82. INSTALL ON EXTERIOR TANK WALL SO THAT DISPLAY IS 62" ABOVE TOC. ROUTE 2-C SHIELDED SIGNAL CABLE TO JB-300.
- 6. EQ TANK HIGH WATER OVERFLOW LEVEL SWITCH "LSH-302", SEE PROCESS SERIES FOR DETAILS AND INSTALLATION ELEVATION. ROUTE CABLE THROUGH CONCRETE TANK WALL TO JB-300 VIA 3/4"C WITH EXPLOSION-PROOF CONDUIT BODIES/SEAL.


Y S

PROJECT NO. 230264 DISCIPLINE SHEET NAME E-06 SHEET

ELECTRICAL


48

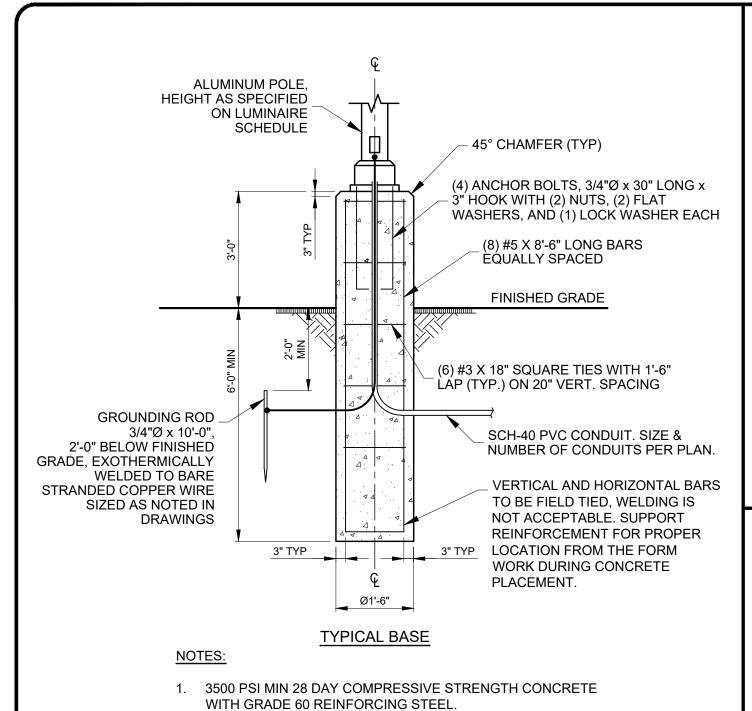

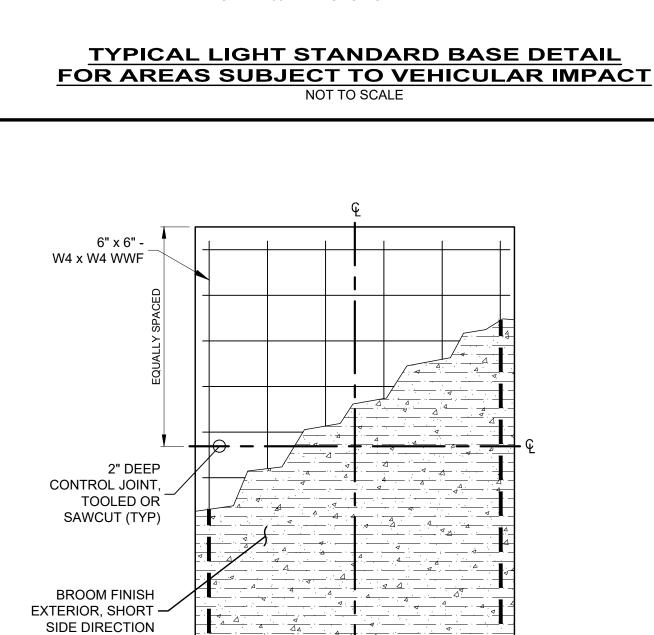


EQUALLY SPACED

PLAN VIEW

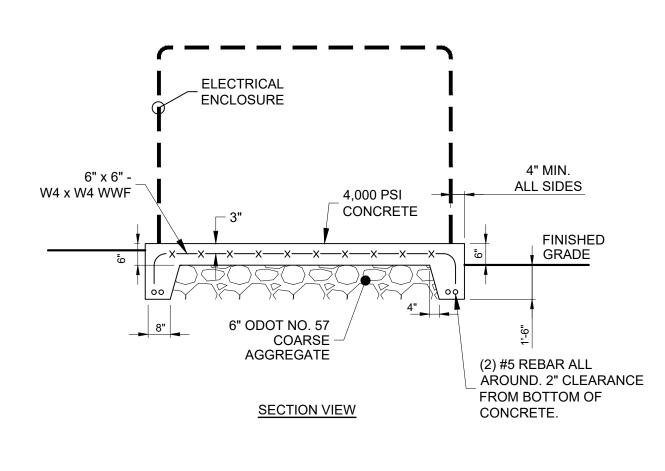


ENCLOSURE

GENERATOR PAD DETAIL NOT TO SCALE

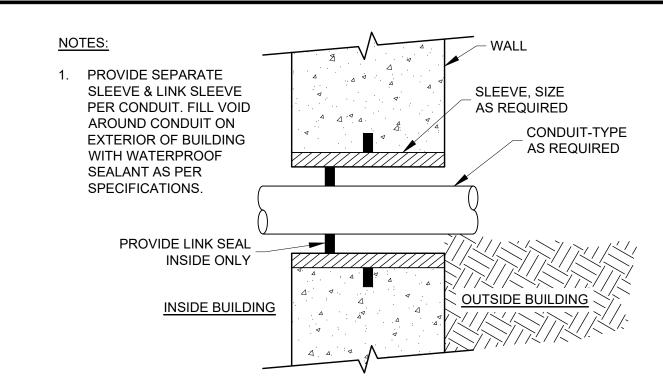


UNDERGROUND CONDUIT WALL PENETRATION BELOW GRADE TO INSIDE BUILDING/STRUCTURE

NOT TO SCALE

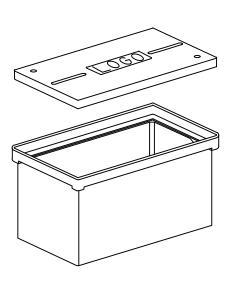



TYPICAL HANDHOLE NOT TO SCALE

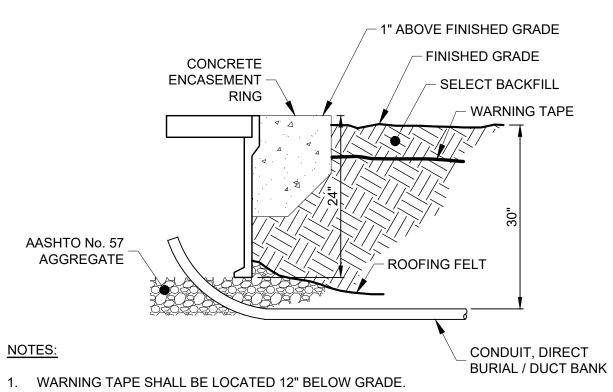

- AN AASHTO No. 57 AGGREGATE DRAINAGE BED IS REQUIRED UNDER ALL ELECTRICAL HANDHOLES. THE DRAINAGE BED SHALL BE EQUAL TO THE HANDHOLE BASE DIMENSIONS PLUS 12" DEPTH.
- THE ENCASEMENT RING SHALL BE 1" ABOVE FINISHED GRADE.
- 4. THE HANDHOLE RIC" OR OAD EQUAL OR "COMMUNICATIO **EXCEEDING 15,0**

NOT TO SCALE

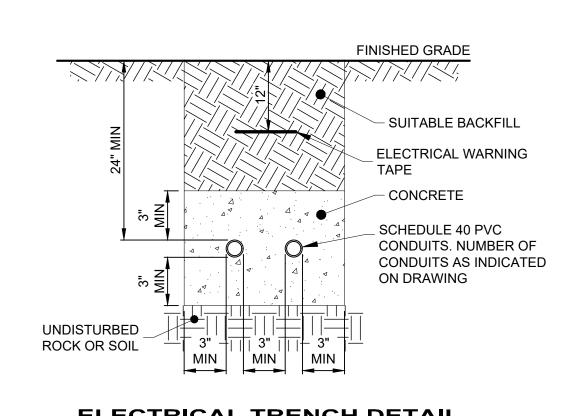

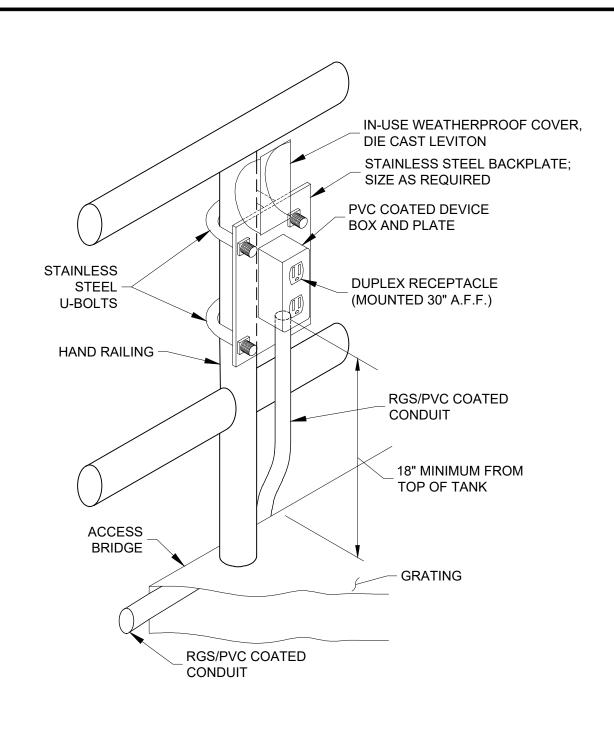

HANDRAIL RECEPTACLE MOUNTING DETAIL NOT TO SCALE

