08/28/2025


DATE


OHIO No. E-58308


VILLAGE OF BYESVILLE

S.R. 821 SANITARY SEWER IMPROVEMENT PHASE I - ROLLING HILLS WWTP ABANDONMENT GUERNSEY COUNTY, OHIO

SEPTEMBER 2025

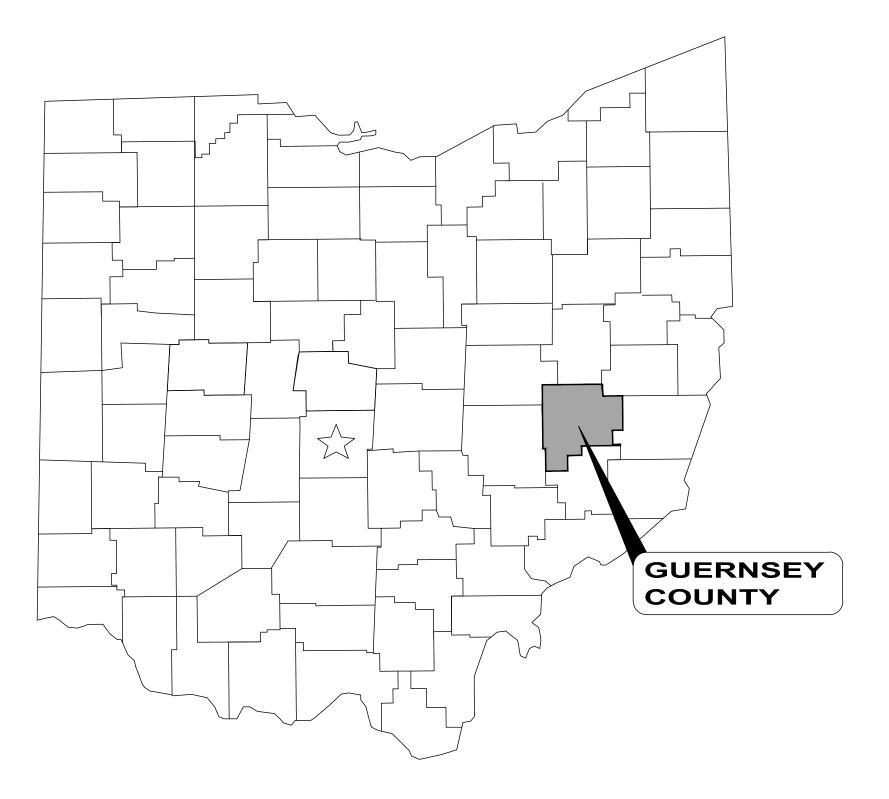

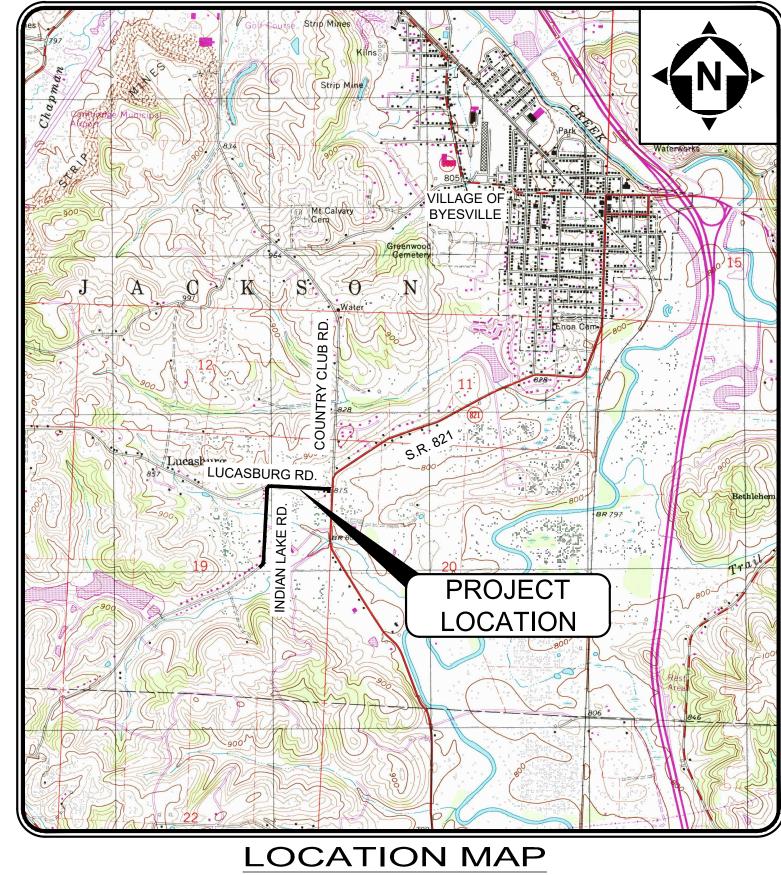

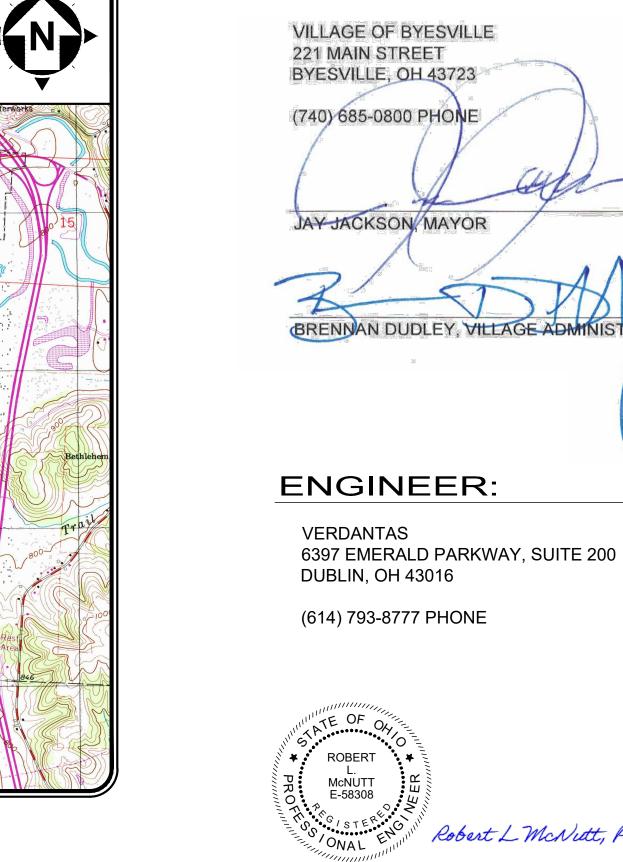

APPROVALS:





ENGINEER'S PROJECT No. 241455


verdantas

^{1.} UNDERGROUND BUILDING SERVICE UTILITY LINES ARE NOT SHOWN ON THE PLANS. THE CONTRACTOR SHALL BE RESPONSIBLE FOR LOCATING, MAINTAINING AND REPLACING AS NECESSARY TO ENSURE CONTINUAL SERVICE TO

^{2.} THE CONTRACTOR IS RESPONSIBLE TO CALL OHIO UTILITIES PROTECTION SERVICE @ 1-800-362-2764, THREE WORKING



Short		CHE
Sheet Number	Sheet Title	SHEE NAM
	GENERAL - 00 SERIES: GENERAL	
1	COVER SHEET	00G-01
2	SHEET INDEX	00G-02
3	GENERAL NOTES	00G-03
4	GENERAL NOTES	00G-04
5	SYMBOLS LEGEND	00G-05
6	SURVEY CONTROL 1	00G-06
7	SURVEY CONTROL 2	00G-07
	PLAN & PROFILES - 05 SERIES: CIVIL	
8	INDIAN LAKE RD.FM. STA. 0+00 TO 5+00	05C-01
9	INDIAN LAKE RD.FM. STA. 5+00 TO 12+50	05C-02
10	INDIAN LAKE RD.FM. STA. 12+50 TO END	05C-03
11	LUCASBURG RD. GRAVITY STA. 0+00 TO 5+00	05C-04
12	LUCASBURG RD. GRAVITY STA. 5+00 TO STA. 10+00	05C-05
	LIFT STATION - 10 SERIES: CIVIL	
13	PUMP STATION SITE PLAN	10C-01
	LIFT STATION - 10 SERIES: PROCESS	
14	PLAN & SECTIONS	10D-01
	LIFT STATION - 10 SERIES: ELECTRICAL	
15	SPECIFICATIONS	10E-01
16	SINGLE LINE	10E-02
17	SITE PLAN	10E-03
18	ELECTRICAL RACK DETAIL	10E-04
·	STANDARD DETAILS - SD SERIES: DETAILS	
19	CONSTRUCTION DETAILS - 1	SD-01
20	CONSTRUCTION DETAILS - 2	SD-02
21	CONSTRUCTION DETAILS - 3	SD-03
22	CONSTRUCTION DETAILS - 4	SD-04
	EROSION CONTROL - EC SERIES: CIVIL	
23	EROSION CONTROL - 1	EC-01
24	EROSION CONTROL - 2	EC-02

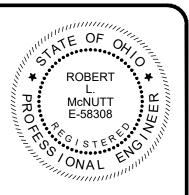

erdanta 8150 STERLING COURT

NO							
NEVIEW NO	8/29/25	AS NOTED	RLM	BLM		RLM	
ISSUED FOR:	ISSUE DATE:	SCALE:	DESIGNED BY:	DRAWN BY:		CHECKED BY:	
VILLAGE OF BYESVILLE	S.R. 821 SANITARY SEWER IMPROVEMEN	GUERNSEY COUNTY, OHIO	CT NO.	GENERAL - 00 SERIES		SHEET INDEX	
241455 DISCIPLINE GENERAL							
SHEET NAME 00G-02							

GENERAL:

- 1. THE CONTRACTOR SHOULD BE AWARE THAT THE INSTALLATION OF THE SANITARY SEWER MAY REQUIRE THE REMOVAL AND REPLACEMENT OF PAVEMENT, DRAINAGE PIPE, AND GRANULAR BACKFILL. THE LABOR AND MATERIAL COSTS ARE TO BE INCLUDED IN THE UNIT PRICES BID UNDER ITEM 901. SEE SPEC SECTIONS 901.03, 901.08 AND 901.09.
- CONTRACTOR SHALL RESTORE MAILBOXES, PAPERBOXES AND POST AFTER INSTALLATION OF SEWER IS COMPLETE.
- PRICES BID PER FOOT FOR ALL PIPE IS COMPLETE IN PLACE REGARDLESS OF SOIL OR ROCK CONDITIONS.
- 4. EXISTING UTILITIES SHOWN ARE FROM BEST AVAILABLE RECORDS AND FIELD INVESTIGATIONS, AND ARE NOT NECESSARILY COMPLETE OR EXACT. THE CONTRACTOR IS RESPONSIBLE FOR THE INVESTIGATION, LOCATION, SUPPORT, PROTECTION, AND RESTORATION OF ALL EXISTING UTILITIES AND APPURTENANCES WHETHER SHOWN ON THESE PLANS OR NOT. THE CONTRACTOR SHALL EXPOSE ALL UTILITIES OR STRUCTURES PRIOR TO CONSTRUCTION TO VERIFY THE VERTICAL AND HORIZONTAL EFFECT ON THE PROPOSED CONSTRUCTION AND SHALL MAKE ADJUSTMENTS IN ELEVATIONS TO PROVIDE SUFFICIENT CLEARANCE BETWEEN THE PROPOSED AND EXISTING UTILITIES FOR TRADITIONAL AND TRENCHLESS CONSTRUCTION METHODS. UTILITY SERVICES BROKEN OR DAMAGED SHALL BE REPAIRED AT ONCE TO AVOID INCONVENIENCE TO CUSTOMERS. STORM SEWERS SHALL NOT BE INTERRUPTED OVERNIGHT. THE CONTRACTOR SHALL CALL THE OHIO UTILITIES PROTECTION SERVICE (1-800-362-2764) THREE WORKING DAYS PRIOR TO WORK EXCLUDING SATURDAYS, SUNDAYS AND LEGAL HOLIDAYS.
- THE SPECIFICATIONS AND STANDARD CONSTRUCTION DRAWINGS OF THE BYESVILLE UTILITIES DEPARTMENT TOGETHER WITH THE SUPPLEMENTAL SPECIFICATIONS AND SPECIAL PROVISIONS CONTAINED HEREIN, IN FORCE AT THE TIME OF CONTRACT, SHALL GOVERN THIS PROJECT. SANITARY SEWER CONNECTIONS SHALL BE GOVERNED BY BYESVILLE UTILITIES RULES AND REGULATIONS AND MUST BE INSPECTED BY THE VILLAGE OF BYESVILLE OR AUTHORIZED REPRESENTATIVE. TWENTY-FOUR HOURS ADVANCE NOTICE OF WORK SHALL BE GIVEN FOR THE SCHEDULING OF AN INSPECTOR.
- THE CONTRACTOR SHALL BASE HIS PROJECTED WORK SCHEDULES UPON THE FOLLOWING CRITERIA:

A. CONSTRUCTION HOURS SHALL BE FROM 8:00 AM TO 4:00 PM, MONDAY THROUGH FRIDAY - ONLY! B. THE FOLLOWING GOVERNMENT HOLIDAYS SHALL BE OBSERVED BY THE CONTRACTOR:

- **NEW YEARS DAY**
- MARTIN LUTHER KING DAY
- PRESIDENT'S DAY
- MEMORIAL DAY
- JUNETEETH
- INDEPENDENCE DAY LABOR DAY
- COLUMBUS DAY
- VETERAN'S DAY
- THANKSGIVING DAY THANKSGIVING DAY AFTER
- 12. CHRISTMAS DAY

SOIL BORES:

NO SOIL BORINGS WERE TAKEN AS PART OF THESE PLANS AND SPECIFICATIONS. THE CONTRACTOR SHALL TAKE ALL SOIL BORINGS HE DEEMS NECESSARY. AT LEAST 48 HOUR NOTICE MUST BE GIVEN TO THE OWNER, AND THE LOCATION OF ALL SOIL BORINGS ARE SUBJECT TO THE APPROVAL OF THE OWNER. THE CONTRACTOR SHALL BE RESPONSIBLE FOR ALL DAMAGE RESULTING FROM DIGGING SOIL BORES AND HE SHALL RESTORE ALL PROPERTY TO A CERTAIN SIMILAR OR EQUAL TO THE CONDITION THAT EXISTING BEFORE SUCH DIGGING WAS DONE. THE CONTRACTOR SHALL NOTE ALL DEWATERING, SHEETING, ETC. WHICH SHALL BE REQUIRED FOR CONSTRUCTION DUE TO SOIL AND WATER CONDITIONS. COST FOR DEWATERING, SHEETING, ETC., SHALL BE INCLUDED IN PRICE BID PER LINEAR FOOT OF RESPECTIVE ITEMS. ANY FOUNDATION SLAG REQUIRED SHALL BE INCLUDED IN THE PRICE BID PER LINEAR FOOT OF RESPECTIVE ITEMS.

ROAD PERMITS:

APPLICABLE ROAD PERMITS HAVE BEEN INCLUDED IN THE SPECIAL CONSTRUCTION REQUIREMENTS AND SUPPLEMENTAL SPECIFICATIONS FOR THIS PROJECT. ANY COST FOR LABOR, EQUIPMENT, MATERIAL, ETC., TO COMPLY WITH THESE PERMITS SHALL BE INCLUDED IN THE PRICES BID. THE CONTRACTOR SHALL CONFINE HIS ACTIVITIES TO THE EXISTING RIGHT-OF-WAYS. CONSTRUCTION AND PERMANENT EASEMENTS AND SHALL NOT TRESPASS UPON OTHER PRIVATE PROPERTY WITHOUT THE WRITTEN CONSENT OF THE OWNER. THE CONTRACTOR SHALL BE SURE THAT ALL PERMITS REQUIRED TO OPEN CUT ROADS HAVE BEEN OBTAINED FROM THE GOVERNING LOCAL, COUNTY OR STATE DEPARTMENT PRIOR TO COMMENCEMENT OF WORK.

SANITARY SEWERS:

- THE COST OF PLUMBING, REROUTING AND DIVERTING ALL WATER AND SEWAGE DURING CONSTRUCTION SHALL BE INCLUDED FOR PAYMENT IN THE VARIOUS SEWER PAY ITEMS.
- GRAVITY SEWERS SHALL HAVE FLEXIBLE ADAPTERS AT CONNECTIONS OF DISSIMILAR PIPE-CONCRETE COLLARS ARE NOT
- ALL CONSTRUCTION SHALL CONFORM TO THE DEPT. OF LABOR, BUREAU OF LABOR STANDARDS SAFETY AND HEALTH REGULATIONS FOR THE CONSTRUCTION AND THE CONTRACT WORK HOURS AND SAFETY ACT. (CHAPTER XVII TITLE C&R, PART 1926 AND ALL ADDITIONS AND REVISIONS).
- ALL WATER AND SANITARY OR STORM SEWER CROSSINGS SHALL HAVE AN EIGHTEEN INCH (18") MINIMUM VERTICAL SEPARATION OUTSIDE DIAMETER (O.D.) TO (O.D.) ALL WATER AND SANITARY OR STORM SEWER SHALL HAVE A TEN FOOT (10') MINIMUM HORIZONTAL SEPARATION (O.D.) TO (O.D.). ALL WATER LINES CROSSING OTHER UTILITIES SHALL HAVE A TWELVE INCH (12") MINIMUM VERTICAL SEPARATION (O.D.) TO (O.D.) AND FOUR FOOT (4') MINIMUM HORIZONTAL CLEARANCE SEPARATION (O.D.) TO (O.D.).
- ROOF DRAINS, FOUNDATION DRAINS AND OTHER CLEAN WATER CONNECTIONS TO THE SANITARY SEWER SYSTEM ARE STRICTLY PROHIBITED.
- 6. NO BRICK MANHOLE CONSTRUCTION WILL BE PERMITTED. MANHOLE CASTING AND COVER TO BE INDENTED SOLID TOP DESIGN WITH HIDDEN PICKHOLES. ALL LIDS TO BE LABELED "PORTAGE COUNTY WATER RESOURCES SANITARY SEWER", CASTING SHALL BE NEENAH R-1783-A WITH EXTRA HEAVY DUTY TYPE "B" LID (TOTAL WEIGHT APPROX. 470#) OR EAST JORDAN IRON WORKS CASTING 1522 WITH TYPE "A" LID. WHERE LABELED "WATERTIGHT" ON PLANS, LIDS SHALL BE SEALED WITH A NEOPRENE GASKET AND FOUR (4) 5/16" DIA. STAINLESS STEEL BOLTS.
- 7. THE CONTRACTOR IS RESPONSIBLE FOR INSTALLING PVC MARKERS AT ALL MANHOLES, CLEAN-OUTS, AIR RELEASE VALVE PITS, LINE VALVES, ETC. ON CROSS-COUNTRY SEWER LINES. INCLUDE A GPS LAT/LONG READING ON ALL REFERENCED ITEMS ABOVE. AFTER LATERAL WYE BRANCH, RISER AND CONNECTION HAVE BEEN INSTALLED, THE END OF THE CONNECTION SHALL BE SEALED WITH AN AIR TIGHT SPIGOT CAP OR AIR TIGHT PLUG AND THE CAP OR PLUG PAINTED YELLOW. THE END OF THE SANITARY CONNECTION SHALL BE MARKED WITH A 2"X 2" HARDWOOD STAKE, EXTENDING VERTICALLY FROM THE END OF THE CONNECTION TO A POINT APPROX. 3' ABOVE THE SURFACE OF THE GROUND.
- LEAKAGE TEST FOR MANHOLES VACUUM TESTING OF CONCRETE SEWER MANHOLES SHALL BE TESTED (IAW) IN ACCORDANCE WITH ASTM C-1244-93. LEAKAGE TEST FOR SEWERS - EITHER WATER OR AIR TEST SHALL BE CONDUCTED TO SHOW EXFILTRATION OR INFILTRATION NOT TO EXCEED 100 GALLONS PER INCH DIAMETER PER MILE PER DAY, AND A MINIMUM POSITIVE HEAD OF 2 FEET. AIR TESTING SHALL CONFORM TO ASTM F-1417 FOR PLASTIC PIPE. DEFLECTION TESTS FOR FLEXIBLE PIPE - NO PIPE SHALL EXCEED A DEFLECTION OF 5 PERCENT. ALL INSPECTION AND TESTING SHALL BE DONE BY AN EXPERIENCED AND QUALIFIED FIRM ENGAGED IN THIS TYPE OF WORK, AS APPROVED BY PCWR. WRITTEN REPORTS FOR ALL INSPECTION AND TESTING SHALL BE SUBMITTED TO PCWR FOR APPROVAL. ALL SANITARY SEWERS MUST BE FLUSHED AND PASS THE LATEST PROPOSED LOW PRESSURE AIR TEST REQUIREMENTS AND DEFLECTION TEST REQUIREMENTS OF THE OEPA. ALL FINAL TESTING AND INSPECTIONS SHALL BE PERFORMED AFTER COMPLETION OF CONSTRUCTION AND SEEDING OF DISTURBED AREAS. IF THE INSTALLATION FAILS TO MEET THE REQUIREMENTS OF THESE TESTS AND INSPECTIONS, THE CONTRACTOR SHALL REPAIR ALL DEFECTS AND RETEST THE INSTALLATION WITH NO ADDITIONAL COST TO THE COUNTY.
- 9. EACH SECTION OF FORCE MAIN SHALL BE SUBJECTED TO A HYDROSTATIC TEST OF 50 PSI AT THE HIGH END OF THE PIPE OR TWICE THE WORKING PRESSURE WHICHEVER IS THE GREATER. ALL TESTING SHALL BE DONE IN THE PRESENCE OF THE ENGINEER OR HIS REPRESENTATIVE.

- 10. THE CONTRACTOR SHALL BE HELD RESPONSIBLE FOR ALL DAMAGE TO THE EXISTING SEWERAGE SYSTEM RESULTING FROM NON-CONFORMANCE WITH GCW STANDARDS OR GENERAL NEGLIGENCE. ALL REPAIRS OR REPLACEMENTS MUST CONFORM TO GCW STANDARDS.
- 11. TWELVE (12") INCH GRADE ADJUSTMENT OF MANHOLES PERMITTED WITH CONCRETE GRADE RINGS. MAXIMUM ADJUSTMENT NOT TO EXCEED 12 INCHES. MINIMUM OF ONE GRADE RING REQUIRED.
- 12. WHERE INLET AND OUTLET PIPES CONNECT TO MANHOLES A FLEXIBLE WATERTIGHT JOINT AS APPROVED BY GCW IS REQUIRED.
- 13. THE GRAVITY SEWER AND FORCE MAIN SEWER SHALL CONFORM TO THE MATERIAL TYPES AS NOTED IN THE PLANS AND PROJECT SPECIFICATIONS. ALL NONMETALLIC PIPE SHALL INCLUDE THE INSTALLATION OF A TRACE WIRE. WATER TRACE WIRE SHALL BE #12 AWG STEEL-COPPER COMPOSITE WIRE WITH 45 MIL HIGH DENSITY POLYETHYLENE EXTERIOR COATING, 21% IACS CONDUCTIVITY, BLUE IN COLOR, AND HAVE 1,030 POUND MINIMUM BREAK LOAD. SEWER TRACE WIRE SHALL BE #12 AWG STEEL-COPPER COMPOSITE WIRE WITH 45 MIL HIGH DENSITY POLYETHYLENE EXTERIOR COATING, 21% IACS CONDUCTIVITY, GREEN IN COLOR, AND HAVE 1,030 POUND MINIMUM BREAK LOAD.
- 14. THE PREFERRED MINIMUM COVER FOR SANITARY SEWERS CONSTRUCTED UNDER A ROAD IS FIVE FEET (5'). UNDER NO CIRCUMSTANCES SHALL THE COVER FOR ANY SANITARY SEWER BE LESS THAN FIVE FEET (5').
- 15. SANITARY SEWER LATERALS ARE TO BE SIX INCH (6") DIAMETER AT A GRADE OF 1.0% UNLESS OTHERWISE NOTED ON THE PLANS OR APPROVED BY THE GCW CONSTRUCTION ENGINEER. A MINIMUM OF FIVE FOOT (5') COVER IS TYPICAL. ALL LATERALS SHALL MAINTAIN AN EIGHTEEN INCH (18") VERTICAL AND TEN FOOT (10') HORIZONTAL SEPARATION FROM ALL WATER LINES AND STORM SEWER UNLESS THE LATERAL IS CONSTRUCTED USING (D.I.P) DUCTILE IRON PIPE CLASS 53. ALL NEW LATERALS SHALL ENTER THE NEW SEWER PIPE AT A 45° ANGLE. NO LATERAL SHALL DROP AT A 90° ANGLE INTO THE
- 16. PLACE PLUGS IN ENDS OF UNCOMPLETED CONDUIT AT THE END OF EACH DAY OR WHENEVER WORK STOPS. ALL NEWLY LAID SEWER SHALL BE FLUSHED AND ALL MANHOLES INSPECTED FOR CLEANLINESS UPON COMPLETION OF THE PROJECT

STORM SEWER:

- 1. THE CONTRACTOR SHALL REPLACE/REPAIR ALL EXISTING STORM SEWERS AND CATCH BASINS DISTURBED AS A RESULT OF THIS PROJECT. ANY STORM SEWERS UNDERNEATH ROADWAYS SHALL BE ODOT AND PORTAGE COUNTY ENGINEER APPROVED PIPE SECTIONS. STORM CULVERTS BENEATH DRIVE APRONS SHALL BE REPLACED IN KIND WITH THE SAME SIZE AND MATRIAL PIPE OR APPROVED EQUIVILANT MATERIAL. STORM SEWERS REPLACED WITHIN YARDS SHALL BE NON-PERFORATED HI-Q CORRUGATED EXTERIOR, SMOOTH INTERIOR, STORM DRAINAGE PIPE BY HANCOR OR PCWR APPROVED EQUAL. ALL WORK SHALL BE PER ODOT ITEM CMS 611 REQUIREMENTS. THIS WORK IF REQUIRED SHALL BE INCLUDED IN THE PRICE BID UNDER ITEM 901.
- 2. ALL STORM INLET STRUCTURES SHALL BE PROTECTED FROM SILT INFILTRATION. GRATE OPENINGS SHALL BE COVERED WITH ENGINEERING FABRIC AND STRAW BALES SHALL BE PLACED AROUND ALL STORM INLET STRUCTURES TO PREVENT SILT FROM ENTERING STORM SYSTEM.
- 3. ALL STORM SEWER INSTALLED BENEATH PAVEMENT SHALL BE REINFORCED CONCRETE OF SAME SIZE OF PIPE BEING REPLACED. CONTROL DENSITY BACKFILL SHALL BE UTILIZED FOR STORM SEWER BENEATH PAVEMENT.

TREE REMOVAL & PROTECTION:

ALL TREES, STUMPS, BRUSH, SHRUBS, AND BUSHES THAT ARE MARKED ON THE PLANS TO BE REMOVED SHALL BE CUT DOWN, REMOVED AND LEGALLY DISPOSED OF BY THE CONTRACTOR, REGARDLESS OF INSTALLATION METHODS; TO INCLUDE TRENCHLESS DRILLING CONSTRUCTION. TREE STUMPS OUTSIDE OF THE TRENCH EXCAVATION LIMITS AND WITHIN FIELD OR WOODED AREAS MAY REMAIN BUT SHALL BE CUT FLUSH WITH THE GROUND ELEVATION. TREE STUMPS WITHIN LAWN YARD AREAS SHALL BE GROUND AND REMOVED TO 6" BELOW THE GROUND ELEVATION. THE CONTRACTOR SHALL SAVE AND PROTECT ALL TREES OUTSIDE OF THE RIGHT OF WAY. WHEN PROTECTED TREES HAVE LIMBS PROTRUDING INTO THE RIGHT OF WAY AND IN CONFLICT WITH CONSTRUCTION EQUIPMENT, THE PROPERTY OWNER MAY GRANT PERMISSION TO PRUNE. THE CONTRACTOR SHALL GET APPROVAL FOR ALL TREE PRUNING FROM THE PCWR CONSTRUCTION ENGINEER. ANY TREES, STUMPS, BRUSH, SHRUBS. AND BUSHES NOT MARKED IN THE PLANS TO BE REMOVE THAT IS DEEMED BY THE CONTRACTOR AS NECESSARY FOR REMOVAL SHALL REQUIRE WRITTEN PERMISSION FROM THE PROPERTY OWNER AND PCWR BEFORE REMOVING. THE CONTRACTOR COSTS TO PERFORM ALL OF THIS DESCRIBED WORK WITHIN THE RIGHT OF WAY IS INCLUDED IN THE COST OF THE VARIOUS BID ITEMS.

EASEMENT

ALL TREES, STUMPS, BRUSH, SHRUBS, AND BUSHES WHOSE TRUNK IS LOCATED WITHIN THE PERMANENT EASEMENT SHALL BE CUT DOWN, REMOVED AND LEGALLY DISPOSED OF BY THE CONTRACTOR. TREE TRUNKS AND LIMBS OF 6" DIAMETER AND GREATER SHALL BE CUT TO 10' LENGTHS, SAVED AND OFFERED TO THE PROPERTY OWNER. IF THE PROPERTY OWNER DOES NOT WANT THE WOOD, THE CONTRACTOR SHALL BE REQUIRED TO REMOVE ALL AND DISPOSE OFF THE SITE. TREE STUMPS OUTSIDE OF THE TRENCH EXCAVATION LIMITS AND WITHIN FIELD OR WOODED AREAS MAY REMAIN BUT SHALL BE CUT FLUSH WITH THE GROUND ELEVATION. TREE STUMPS WITHIN LAWN YARD AREAS SHALL BE GROUND AND REMOVED TO 6" BELOW THE GROUND ELEVATION. TREES, STUMPS, BRUSH, SHRUBS, AND BUSHES SHALL BE REMOVED WITHIN THE PERMANENT EASEMENT REGARDLESS OF TRENCHLESS DRILLING CONSTRUCTION INSTALLATION METHODS USED BY HE CONTRACTOR. THE CONTRACTOR SHALL SAVE AND PROTECT ALL TREES OUTSIDE OF THE PERMANENT EASEMENT. WHEN PROTECTED TREES HAVE LIMBS PROTRUDING INTO THE PERMANENT EASEMENT AND IN CONFLICT WITH CONSTRUCTION EQUIPMENT, THE PROPERTY OWNER MAY GRANT PERMISSION TO PRUNE. THE CONTRACTOR SHALL GET APPROVAL FOR ALL TREE PRUNING FROM THE PCWR CONSTRUCTION OR DESIGN ENGINEER. THE CONTRACTOR COSTS TO PERFORM ALL OF THIS DESCRIBED WORK WITHIN THE PERMANENT EASEMENT IS INCLUDED IN THE COST OF THE VARIOUS BID ITEMS.

ROADWAYS & DUST CONTROL:

- 1. TRAFFIC CONTROL SHALL BE IN ACCORDANCE WITH THE OHIO AND FEDERAL MANUALS OF UNIFORM TRAFFIC CONTROL
- 2. THE CONTRACTOR SHALL THOROUGHLY CLEAN OFF ALL ROADS OF ANY DIRT OR DEBRIS DAILY AND SHALL UTILIZE DUST CONTROL AS NECESSARY OR AS REQUESTED BY THE PCWR ENGINEERING INSPECTOR.
- 3. ALL DISTURBED UTILITIES, SIGNS, GUARD RAIL, MAIL AND/OR PAPER BOXES, ROADWAYS AND DRIVEWAYS SHALL BE PUT TEMPORARILY IN SERVICE AT THE END OF EACH WORK DAY, UNTIL PERMANENT REPAIRS CAN BE COMPLETED. THE CONTRACTOR SHALL REPLACE ALL SIDEWALKS AND DECORATIVE ISLANDS WITHIN GRANTED WORK EASEMENTS.

PROHIBITED CONSTRUCTION ACTIVITIES:

- 1. NO USING ANY SUBSTANCE OTHER THAN WATER TO CONTROL DUST.
- 2. NO OPEN BURNING OF PROJECT DEBRIS WITHOUT A PERMIT. THE CONTRACTOR IS RESPONSIBLE FOR OBTAINING AN OEPA OPEN BUILDING AIR PERMIT OR DISPOSING OF THE TREES AND STUMPS.
- 3. NO PUMPING OF SEDIMENT-LADEN WATER FROM TRENCHES OR OTHER EXCAVATIONS INTO ANY SURFACE WATERS, ANY STREAM CORRIDORS, ANY WETLANDS, OR STORM SEWERS.
- 4. NO DISCHARGING POLLUTANTS SUCH AS CHEMICALS, FUELS, LUBRICANTS, BITUMINOUS MATERIALS, RAW SEWERAGE AND OTHER HARMFUL WASTE INTO OR ALONGSIDE RIVERS, STREAMS, IMPOUNDMENTS OR INTO NATURAL OR MAN-MADE CHANNELS LEADING THERETO.
- 5. STORING CONSTRUCTION EQUIPMENT AND VEHICLES AND/OR STOCKPILING CONSTRUCTION MATERIALS ON PROPERTY, PUBLIC OR PRIVATE, ASPHALT OR CONCRETE ROADWAY SURFACES (INCLUDING ANY EARTH EXCAVATION OR EMBANKMENT MATERIAL). NOT PREVIOUSLY SPECIFIED OR APPROVED BY THE ENGINEER FOR SAID PURPOSES.
- 6. NO DAMAGING VEGETATION OUTSIDE OF THE CONSTRUCTION AREA.
- 7. NO HEAVY MOTORIZED CONSTRUCTION EQUIPMENT ENTERING THE STREAM CHANNEL
- 8. NO DISPOSAL OF TREES, BRUSH AND OTHER DEBRIS IN ANY STREAM CORRIDORS, ANY WETLANDS, ANY SURFACE WATERS, OR AT UNSPECIFIED LOCATIONS.

UTILITY POLES:

 THE UTILITY POWER POLES ARE OWNED BY (OHIO EDISON). CONTRACTOR SHALL CONFIRM UTILITY POLE OWNERSHIP. CONTRACTOR SHALL COORDINATE AND PROVIDE UTILITY POLE OWNER (OHIO EDISON) TRUCK EQUIPMENT TO PROVIDE POLE HOLDS AND IF REQUIRED DURING SEWER CONSTRUCTION AT THE CONTRACTORS EXPENSE. THIS WORK IF REQUIRED IS INCLUDED WITH THE UNIT PRICE OF THE BID ITEMS 901.

EXISTING UTILITY LINES:

1. ANY GAS SERVICE / MAIN LINES, WATER SERVICE / MAIN LINES, COMMUNICATIONS CABLE SERVICE / MAINS, OTHER UTILITY LINES OR UTILITY POLE (SHOWN OR NOT SHOWN ON THESE DRAWINGS) CONFLICT THAT REQUIRES TEMPORARY OR PERMANENT RELOCATION SHALL BE THE RESPONSIBILITY OF THE CONTRACTOR, WHO SHALL COORDINATE ALL RELOCATIONS WITH THROUGH THE OWNER OF THE UTILITY IN QUESTION. COSTS OF RELOCATIONS WILL BE RESPONSIBILITY OF OWNER OF

LATERALS:

1. ALL LATERALS THAT CROSS THE ROADWAY WILL BE BORED. ANYWHERE WHERE THAT IS NOT FEASIBLE THE CONTRACTOR SHALL GET APPROVAL FROM ENGINEER BEFORE ANY WORK IS DONE IN THAT LOCATION.

	UTILITY COMPANIE	S
OTHERS) AND AVAILABLE RECOR	S SHOWN ON THIS PLAN ARE BASE RDS, AND AS SUCH, SHOULD BE FIE TRUCTION ACTIVITY - CALL BEFO	ELD VERIFIED PRIOR TO
SEWERS: VILLAGE OF BYESVILLE 221 MAIN STREET BYESVILLE, OHIO 43723 (740) 685-0800	WATER: VILLAGE OF BYESVILLE 221 MAIN STREET BYESVILLE, OHIO 43723 (740) 685-0800 GUERNSEY COUNTY	COUNTY: GUERNSEY COUNTY ENGINEER 62782 BENNETT AVE. CAMBRIDGE, OHIO 43725 (740) 432-2234
ELECTRIC: AMERICAN ELECTRIC POWER ATTN: BRENT GATES 700 MORRISON ROAD GAHANNA, OHIO 43230 (614) 883-6802	GAS: COLUMBIA GAS OF OHIO ATTN: ROB CALDWELL 3350 JOHNNY APPLESEED CT. COLUMBUS, OHIO 43231 (614) 818-2104	VILLAGE: VILLAGE OF BYESVILLE 221 MAIN STREET BYESVILLE, OHIO 43723 (740) 685-0800
COMMUNICATION: OPTIMUM (FKA) SUDDENLINK 110 E Market St, Warren, OHIO 44481 (866) 261-0725		

OUPS TICKET NUMBERS

A411404602 A411404620



PROJECT NO.

SHEET NAME 00G-03

GENERAL NOTES:

- 1. A PRE-CONSTRUCTION MEETING SHALL BE HELD AT THE VILLAGE ADMINISTRATION BUILDING (221 MAIN ST) AT LEAST 15 CALENDAR DAYS BEFORE THE START OF CONSTRUCTION. REPRESENTATIVES OF THE OWNER, DESIGN ENGINEER, GUERNSEY COUNTY ENGINEER'S OFFICE, AND THE CONTRACTOR SHALL BE IN ATTENDANCE. A SCHEDULE OF THE SEQUENCE OF EVENTS DURING CONSTRUCTION MUST BE SUBMITTED FOR REVIEW AT LEAST (7) SEVEN DAYS PRIOR TO THIS MEETING.
- 2. ALL WORK SHALL BE COMPLETELY ACCEPTABLE TO THE VILLAGE OF BYESVILLE OFFICIALS. NO WORK SHALL COMMENCE UNTIL ARRANGEMENTS HAVE BEEN MADE WITH THE VILLAGE OF BYESVILLE ENGINEER FOR INSPECTION. NECESSARY LINE AND GRADE STAKING TO BE PROVIDED BY THE CONTRACTOR.
- 3. THE CONTRACTOR SHALL PROVIDE WRITTEN NOTIFICATION TO THE VILLAGE OF BYESVILLE ENGINEER AT LEAST (7) SEVEN WORKING DAYS PRIOR TO THE START OF CONSTRUCTION.
- 4. THE CONTRACTOR SHALL PROVIDE A VIDEO RECORD OF THE SITE TO THE VILLAGE ENGINEER PRIOR TO THE START OF CONSTRUCTION. EMPHASIS OF THE VIDEO SHOULD BE ON EXISTING DEVELOPED AREAS CONTIGUOUS WITH THE PROJECT WORK AREAS.
- 5. CONTRACTOR IS RESPONSIBLE FOR MAINTAINING AN UP-TO-DATE COPY OF THE APPROVED PLANS. FOR ACCEPTANCE OF WORK, THE VILLAGE REQUIRES A SIGNED COMPLETE SET OF ALL APPROVED PLANS.
- 6. THE CONTRACTOR SHALL SECURE AND PAY FOR ALL PERMITS AND GOVERNMENT FEES, LICENSES, AND INSPECTIONS FOR THE PROPER EXECUTION OF THE IMPROVEMENTS SHOWN ON THE PLANS.
- 7. ALL PERTINENT STANDARD CONSTRUCTION DRAWINGS ARE AVAILABLE UPON REQUEST AT THE OFFICE OF THE VILLAGE ENGINEER.
- 8. APPROVAL OF THESE PLANS SHALL BE IN ACCORDANCE WITH THE VILLAGE OF BYESVILLE.
- 9. IT IS THE RESPONSIBILITY OF THE CONTRACTOR TO VISIT THE SITE AND VERIFY THE EXTENT OF WORK TO BE PERFORMED PRIOR TO MAKING THEIR BID. THIS IS ESPECIALLY TRUE WITH REGARD TO ANY REMOVAL ITEMS.
- 10. THE CONTRACTOR AND SUBCONTRACTOR SHALL ALSO ABIDE BY ALL ORDINANCES OF THE VILLAGE OF BYESVILLE.
- 11. THE CONTRACTOR IS SPECIFICALLY THAT THE LOCATION AND/OR ELEVATION OF EXISTING UTILITIES AS SHOWN ON THESE PLANS IS BASED ON RECORDS OF THE VARIOUS UTILITY COMPANIES AND, WHERE POSSIBLE, MEASUREMENTS TAKEN IN THE FIELD. THE INFORMATION IS NOT TO BE RELIED ON AS BEING EXACT OR COMPLETE.
- 12. ALL FIELD TILE BROKEN DURING EXCAVATION SHALL BE REPLACED TO ORIGINAL CONDITION OR CONNECTED TO THE CURB SUBDRAIN OR TO THE STORM SEWER SYSTEM AS DIRECTED BY THE ENGINEER.
- 13. INGRESS AND EGRESS SHALL BE MAINTAINED TO PUBLIC AND PRIVATE PROPERTY.
- 14. THE CONTRACTOR SHALL REPAIR OR REPLACE ANY AND ALL EXISTING WORK DAMAGED DURING OR DUE TO THE EXECUTION OF THIS CONTRACT AT THEIR OWN EXPENSE. SAID WORK TO BE REPAIRED OR REPLACED TO THE SATISFACTION OF THE OWNER'S ENGINEER AND THE VILLAGE OF BYESVILLE.
- 15. ALL SIGNS, FENCES, SHRUBS, DRAINAGE STRUCTURES, OR OTHER PHYSICAL FEATURES THAT ARE TO REMAIN INTACT WHICH ARE DISTURBED OR DAMAGED DURING WORK UNDER THE CONTRACT SHALL BE RESTORED TO THEIR ORIGINAL CONDITION BY THE CONTRACTOR UNLESS OTHERWISE PROVIDED IN THE CONTRACT. THE COST OF ALL SUCH WORK SHALL BE INCLUDED IN THE PRICE BID FOR THE VARIOUS SANITARY SEWER ITEMS.
- 16. THE CONTRACTOR SHALL RESTORE DISTURBED AREAS TO ORIGINAL CONDITION AS NEAR AS PRACTICABLE UPON COMPLETION OF THIS WORK. ANY DAMAGE TO OTHER UTILITIES DURING THIS WORK BY THE SUBCONTRACTOR SHALL BE REPAIRED BY THE APPROPRIATE UTILITY OWNER AT THE CONTRACTOR'S EXPENSE.
- 17. CARE SHALL BE EXERCISED WHEN WORKING THE AREA AROUND EXISTING TREES AND SHRUBS. TREES MAY BE REMOVED WITHIN THE PERMANENT AND TEMPORARY EASEMENTS ONLY. EFFORTS SHALL BE MADE TO PRESERVE TREES 24-INCHES CALIPER OR LARGER. NO TREES SHALL BE DAMAGED OR DISTURBED OUTSIDE OF THE EASEMENTS OR WHERE MARKED ON THE PLANS AS "DO NOT DISTURB".
- 18. THE COST OF DEWATERING OR ROCK EXCAVATION SHALL BE INCLUDED IN THE PRICE BID FOR SANITARY PIPE. THE BIDDER SHALL DETERMINE IF ANY DEWATERING OR ROCK EXCAVATION WILL BE REQUIRED AND ADJUST THEIR BIDS ACCORDINGLY.
- 19. THE FLOW IN ALL SEWERS, DRAINS, AND SANITARY SEWER COURSES ENCOUNTERED SHALL BE MAINTAINED BY THE CONTRACTOR AT THEIR OWN EXPENSE AND WHENEVER SUCH VILLAGE OF BYESVILLE.
- 20. ALL EARTHWORK OPERATIONS, ESPECIALLY PAVEMENT SUBGRADE CONSTRUCTION, SHALL BE INSPECTED BY A REGISTERED SOILS ENGINEER EMPLOYED AND PAID FOR BY THE OWNER. ADDITIONALLY ALL FINAL GRADES SHALL BE FIELD CHECKED BY THE CONSTRUCTION MANAGER UPON COMPLETION OF THE CONTRACTOR'S OPERATIONS TO DETERMINE IF THE SITE HAS BEEN CONSTRUCTED TO THE GRADES INDICATED.
- 21. ALL ITEMS CALLED FOR ON THE PLANS FOR WHICH NO SPECIFIC METHOD OF PAYMENT IS PROVIDED SHALL BE PERFORMED BY THE CONTRACTOR AND THE COST OF SAME AND SHALL BE INCLUDED IN THE PRICE BID FOR THE VARIOUS ITEMS.
- 22. EROSION CONTROL MEASURES ARE TO BE INSTALLED PER PLAN OR AS SUCH DIRECTED BY THE VILLAGE AND ARE TO BE MAINTAINED UNTIL SUCH TIME THAT THEY ARE NO LONGER REQUIRED.
- 23. ALL AREAS IN THE RIGHT-OF-WAY ARE TO BE GRADED AND SEEDED AS SOON AS WORK IN THAT AREA IS COMPLETE.
- 24. THE CONTRACTOR IS RESPONSIBLE FOR THE PROVISION AND MAINTENANCE OF A PORTABLE TOILET ON THE SITE DURING ALL PHASES OF CONSTRUCTION.
- 25. THE CONTRACTOR AND/OR DEVELOPER IS RESPONSIBLE FOR ALL COMPACTION AS WELL AS ASPHALT AND CONCRETE TESTING. TESTING IS TO BE PERFORMED BY A REGISTERED CONTRACTOR AS SPECIFIED BY THE VILLAGE ENGINEER.
- 26. THE VILLAGE ENGINEER RESERVES THE RIGHT TO DIRECT PROJECT SPECIFIC CHANGES TO ANY CITY CONSTRUCTION NOTE AND SPECIFICATION.
- 27. NO CONSTRUCTION TRAFFIC IS PERMITTED ON STREETS ACCESSING NEIGHBORHOOD SUBDIVISIONS. NO TRACKED EQUIPMENT IS PERMITTED ON EXISTING STREET PAVEMENT.
- 28. THE CONTRACTOR AND SUBCONTRACTORS SHALL BE RESPONSIBLE FOR COMPLYING WITH THE OCCUPATIONAL SAFETY AND HEALTH ACT OF 1970 AND ALL OTHER FEDERAL, STATE, AND LOCAL SAFETY REQUIREMENTS, TOGETHER WITH EXERCISING PRECAUTIONS AT ALL TIMES FOR THE PROTECTION OF PERSONS (INCLUDING EMPLOYEES) AND PROPERTY. THE CONTRACTOR AND SUBCONTRACTORS SHALL INITIATE, MAINTAIN, AND SUPERVISE ALL SAFETY REQUIREMENTS, PRECAUTIONS, AND PROGRAMS ASSOCIATED WITH THIS WORK.
- 29. THE CONTRACTOR SHALL BE RESPONSIBLE FOR SECURING ALL PERMITS NECESSARY TO PERFORM ALL WORK WITHIN AND/OR ADJACENT TO THE RIGHT-OF-WAY OF ALL ROADS AND HIGHWAYS. ALL FEES, BONDS, INSURANCE, AND OTHER COSTS REQUIRED BY THE OWNER OF SAID ROADS AND HIGHWAYS SHALL BE PROVIDED BY THE CONTRACTOR AND INCLUDED IN THE PRICE BID FOR THE WORK.
- 30. THE CONTRACTOR SHALL PROVIDE THE VILLAGE ENGINEER AND GUERNSEY COUNTY ENGINEER WITH A 24 HOUR TELEPHONE NUMBER TO READILY CONTACT A RESPONSIBLE PARTY IN THE CASE OF AN EMERGENCY. THE COST AND/OR DAMAGES INCURRED RELATED TO WORK PERFORMED BY THE CONTRACTOR IN SUCH EMERGENCIES ARE THE CONTRACTORS RESPONSIBILITY AND NOT THE AFFECTED ENTITY.
- 31. NO EXTRA COMPENSATION SHALL BE PAID TO THE CONTRACTOR BY REASON OF COMPLIANCE WITH ANY OF THE REQUIREMENTS INDICATED IN THE PLANS, BUT PAYMENT SHALL BE DEEMED TO BE INCLUDED AMONG THE SEVERAL ITEMS, AS BID UPON, UNLESS OTHERWISE SPECIFICALLY PROVIDED.
- 32. IN ADDITION TO THE DIRECT REQUIREMENTS OF THE CONTRACT SPECIFICATIONS, THE CONTRACTOR SHALL OBSERVE AND CONFORM TO THE SPECIFIC REQUIREMENTS OF ALL RIGHT-OF-WAYS INCLUDING EASEMENTS, COURT ENTRIES, RIGHTS OF ENTRY, OR ACTION FILED IN COURT IN ACCORDANCE WITH THE CODE OF THE APPLICABLE GOVERNING AGENCY. THE COST OF OPERATIONS NECESSARY TO FULFILL SUCH REQUIREMENTS SHALL BE INCLUDED IN THE TOTAL CONTRACT PRICE BID.

- 33. THE DESIGN SHOWN ON THESE DRAWINGS IS BASED UPON A FIELD SURVEY AND EXISTING RECORDS.
- 34. PRIOR TO THE BEGINNING OF CONSTRUCTION, THE CONTRACTOR SHALL TAKE PHOTOGRAPHS AND VIDEO OF THE PROJECT SITE PER THE SPECIFICATIONS. A DIGITAL COPY OF ALL MEDIA SHALL BE SUBMITTED TO THE VILLAGE ENGINEER FOR REVIEW AND APPROVAL. THE COST OF THIS WORK SHALL BE INCLUDED IN THE UNIT BID PRICE FOR PRE-CONSTRUCTION VIDEOTAPING.
- 35. ALL CONSTRUCTION STAKING SHALL BE PROVIDED BY THE CONTRACTOR. THIS WILL CONSIST OF ALIGNMENT AND GRADE STAKES SET AND MARKED IN THE FIELD. THE CONTRACTOR WILL BE HELD RESPONSIBLE FOR ANY REPLACEMENT STAKES NECESSARY, REMOVED OR DESTROYED BY THEIR PERSONNEL OR EQUIPMENT.
- 36. THE CONTRACTOR SHALL MAINTAIN AS-BUILT DRAWINGS THROUGHOUT THE PROJECT AND SHALL BRING THE CURRENT SET OF AS-BUILT DRAWINGS TO EACH PROGRESS MEETING FOR REVIEW.
- 37. THE WORK OF THIS CONTRACT SHALL NOT INTERFERE WITH MAINTAINING CONTINUOUS FLOW IN THE EXISTING SANITARY SEWER, STORM SEWER, WATERLINES, POWER, TELEPHONE, CABLE TV, GAS, OR ANY OTHER SYSTEM THAT MAY BE ENCOUNTERED DURING CONSTRUCTION. THE CONTRACTOR IS RESPONSIBLE TO MAINTAIN ALL UTILITY POLES AND RELOCATE ANY UTILITY THAT IMPEDES CONSTRUCTION. NOTHING SHALL BE DONE BY ANY OTHER CONTRACTOR FOR THIS PROJECT WHICH WILL IN ANY WAY REDUCE THE QUALITY OR QUANTITY LEVEL OF SUCH OPERATIONS. THE CONTRACTOR SHALL NOTIFY THE OWNER (1) ONE WEEK PRIOR TO MODIFYING ANY FACILITIES. NO PAYMENT WILL BE MADE FOR ANY UTILITY MAINTENANCE UNLESS SPECIFICALLY NOTED AS A BID ITEM IN THE PROPOSAL. FAILURE TO PROPERLY MAINTAIN UTILITIES WILL RESULT IN THE REDUCTION OF THE PROPOSAL ITEM FOR UTILITY MAINTENANCE.
- 38. AT ALL UTILITY CROSSINGS, THE BACKFILL SHALL CONSIST OF COMPACTED GRANULAR MATERIAL BETWEEN THE DEEPER AND SHALLOWER PIPE UNLESS CONTROLLED DENSITY FILL OR CONCRETE IS SPECIFIED OTHERWISE IN THE DRAWINGS.
- 39. MANHOLES SHALL BE INSTALLED WITH ADJUSTING RINGS SO THAT THE TOP OF THE CASTING IS AT EXISTING GRADE. THE CASTING SHALL NOT PROTRUDE SO AS TO INTERFERE WITH MOWING.
- 40. BACKFILL: EARTH WILL NOT BE MOUNDED OVER THE TRENCH IN ANTICIPATION OF SETTLEMENT. THE CONTRACTOR SHALL COMPACT THE TRENCH AND ESTABLISH THE ORIGINAL DITCH GRADE AS WORK PROGRESSES. DRAINAGE MUST BE RESTORED AS QUICKLY AS PRACTICAL. IF EROSION OF THE DITCH LINE CAUSES SILTING OF EXISTING DRAINAGE LINES, THE CONTRACTOR SHALL CLEAN AS NECESSARY. BACKFILL AND CLEANUP OPERATIONS SHALL BE KEPT WITHIN 300 FEET OF PIPE LAYING OPERATIONS DAILY. CARE SHALL BE TAKEN TO INSURE THAT NO DITCH LINE ELEVATIONS ARE RAISED DUE TO EXCESS BACKFILL. COMPACTION IS TO BE CARRIED OUT WITH THE NECESSARY EQUIPMENT TO ACHIEVE THE COMPACTION REQUIREMENT OF ODOT CMS ITEM 304.05. THE CONTRACTOR SHALL MAINTAIN DRIVEWAYS ACCESSIBLE AT ALL TIMES BY USING PLATES OR COMPACTED GRANULAR FILL.
- 41. ROAD MAINTENANCE AREA: UNLESS PREEXISTING BEFORE CONSTRUCTION OPERATIONS, THE SURFACE WITHIN A MINIMUM OF 5 FEET FROM THE EDGE OF PAVEMENT SHALL BE MAINTAINED OBSTACLE FREE, BY THE CONTRACTOR, FOR POSITIVE DRAINAGE AND/OR SNOW PLOW/MAINTENANCE OF ROAD PAVEMENT.
- 42. ROOF DRAINS, FOUNDATION DRAINS, AND OTHER CLEAN WATER CONNECTIONS TO THE SANITARY SEWER SYSTEM ARE
- 43. DISTURBANCE TO THIS SITE IS COVERED BY OEPA GENERAL PERMIT OHC000005 AND THE NPDES PERMIT.


PRESERVATION NOTES:

- 1. ALL DRAIN TILE, FIELD TILE, AND STORM SEWERS DAMAGED, DISTURBED, OR REMOVED AS A RESULT OF THE CONTRACTOR'S OPERATIONS SHALL BE REPLACED WITH THE SAME QUALITY OR BETTER, MAINTAINING THE SAME GRADIENT AS EXISTING. REPLACED DRAIN TILE SHALL BE LAID PER THE STORM SEWER DETAIL. COST TO BE INCLUDED IN THE PRICE BID FOR THE VARIOUS UNIT PRICE BID ITEMS. ALL NECESSARY REPLACEMENT OF EXISTING PIPES IS TO BE PERFORMED AS SOON AS POSSIBLE, PRIOR TO BACKFILLING THE TRENCH.
- 2. CULVERTS, END SECTIONS, AND HEADWALLS DISTURBED OR DESTROYED DURING THE PERFORMANCE OF THE WORK SHALL BE RESTORED BY THE CONTRACTOR TO THE LOCATIONS AND GRADES EXISTING PRIOR TO CONSTRUCTION. THE COST OF THIS RESTORATION SHALL BE INCLUDED IN THE UNIT BID PRICE FOR THE RELEVANT ITEMS OF THE WORK.
- 3. THE CONTRACTOR SHALL CAREFULLY PRESERVE BENCHMARKS, PROPERTY CORNERS, AND REFERENCE POINTS AND IN CASE OF WILLFUL OR CARELESS DESTRUCTION, THEY SHALL BE RESPONSIBLE FOR ANY MISTAKES THAT MAY BE CAUSED BY UNNECESSARY LOSS OR DISTURBANCE. THE CONTRACTOR SHALL ALSO RESTORE ALL DISTURBED AREAS, FENCES, AND DITCHES TO THEIR ORIGINAL CONDITION.
- 4. ANY PROPERTY CORNERS, PERMANENT SURVEY MARKERS, OR MONUMENTATION DISTURBED DURING CONSTRUCTION SHALL BE REESTABLISHED BY THE CONTRACTOR USING A SURVEYOR REGISTERED BY THE OHIO STATE BOARD OF REGISTRATION FOR PROFESSIONAL ENGINEERS AND SURVEYORS. THE CONTRACTOR SHALL COORDINATE THIS WORK WITH THROUGH GUERNSEY COUNTY ENGINEER'S OFFICE. COST TO BE INCLUDED IN THE PRICE BID FOR THE VARIOUS UNIT PRICE BID ITEMS. ALL CONSTRUCTION STAKING WILL BE PROVIDED BY THE CONTRACTOR. THIS WILL CONSIST OF ALIGNMENT AND GRADE STAKES SET AND MARKED IN THE FIELD. THE CONTRACTOR WILL BE HELD RESPONSIBLE FOR ANY REPLACEMENT STAKES NECESSARY, REMOVED, OR DESTROYED BY THEIR PERSONNEL OR EQUIPMENT.
- 5. ALL SIGNS, FENCES, SHRUBS, DRAINAGE STRUCTURES, OR OTHER PHYSICAL FEATURES DISTURBED OR DAMAGED DURING THE WORK UNDER THIS CONTRACT SHALL BE RESTORED TO THEIR ORIGINAL CONDITION BY THE CONTRACTOR, OR REPLACED IN LIKE KIND AND QUALITY UNLESS OTHERWISE NOTED ON THE PLANS. EXISTING GRATES SHALL BE SALVAGED AND EXISTING CATCH BASINS OR INLETS SHALL BE REBUILT IN KIND MATERIAL. ALL EXISTING DRAINAGE DITCHES SHALL BE RESTORED TO EXISTING CONDITIONS AND GRADE. IF GUARDRAIL IS DISTURBED, THE CONTRACTOR SHALL PROVIDE NEW POSTS IN ACCORDANCE WITH THE CURRENT ODOT CMS ITEM 606.02, UNLESS OTHERWISE PROVIDED IN THE CONTRACT. THE COST OF ALL SUCH WORK SHALL BE INCLUDED IN THE PRICE BID FOR THE VARIOUS UNIT PRICE BID ITEMS.
- 6. THE CONTRACTOR SHALL BE RESPONSIBLE FOR MAINTAINING MAIL SERVICE IN THE CONSTRUCTION AREA. PRIOR TO DISTURBING ANY MAILBOXES, THE CONTRACTOR SHALL CONTACT THE POSTAL AUTHORITIES AND SHALL TEMPORARILY RELOCATE MAILBOXES WITH THE REQUIREMENTS THEREOF. THE CONTRACTOR SHALL RESTORE MAILBOXES TO THEIR ORIGINAL CONDITION AND LOCATION SUBSEQUENT TO CONSTRUCTION.
- 7. THE CONTRACTOR SHALL RESTRICT CONSTRUCTION ACTIVITY TO PUBLIC RIGHT-OF-WAY AND THOSE AREAS DEFINED AS TEMPORARY CONSTRUCTION EASEMENTS, PERMANENT UTILITY EASEMENTS, AND ACCESS EASEMENTS, PER WORK AGREEMENT. FOLLOWING THE CONSTRUCTION ACTIVITIES IMPACTING ANY OF THE R/W, THE R/W SHALL BE RESTORED BACK TO MATCH THE ORIGINAL CONDITION.
- 8. THE LENGTH OF THE TRENCH OPENED, OR THE AREA OF THE SURFACE DISTURBED AT ANY TIME SHALL BE LIMITED WITH REGARD TO BOTH EXPEDITIOUS CONSTRUCTION AND CONVENIENCE OF THE PUBLIC. NEW TRENCHES SHALL NOT BE OPENED WHEN OPEN TRENCHES NEED BACKFILLING OR WHEN LABOR IS NEEDED TO RESTORE THE SURFACE OF THE STREETS TO A SAFE AND PROPER CONDITION. IN NO CASE SHALL MORE THAN 50 FEET OF TRENCH BE OPENED IN ADVANCE OF THE COMPLETED WORK. IF ATTRIBUTABLE TO THE CONTRACTOR AND THE TRENCH WILL REMAIN OPEN FOR AN UNREASONABLE LENGTH OF TIME IN ADVANCE OF INSTALLING THE POPE OR OTHER ITEMS AS DETERMINED BY THE OWNER, THEN THE CONTRACTOR SHALL REFILL THE EXCAVATION, OR ANY PART THEREOF, UNTIL THEY ARE READY TO PROCEED WITH THE CONSTRUCTION OF THE WORK. THIS SHALL BE DONE AT NO ADDITIONAL COST TO THE OWNER.
- 9. ALL EXCAVATED MATERIAL SHALL BE WORKED IN SUCH A MANNER THAT WILL NOT ENDANGER THE WORK NOR OBSTRUCT WALKS AND DRIVEWAYS, MANHOLE COVERS, INLETS, FIRE AND POLICE CALL BOXES. OTHER UTILITIES SHALL BE UNOBSTRUCTED AND ACCESSIBLE AT ALL TIMES. GUTTERS SHALL BE KEPT CLEAR OR OTHER SATISFACTORY PROVISIONS MUST BE MADE TO KEEP THEM UNOBSTRUCTED,
- 10. OPEN EXCAVATIONS: ALL EXCAVATIONS SHALL BE MAINTAINED AS SAFE AS POSSIBLE BY THE CONTRACTOR AT ALL TIMES AND BACKFILLED AS SOON AS PRACTICAL. OPEN EXCAVATIONS AFTER WORK HOURS REQUIRE TRAFFIC PLATES, TEMPORARY PAVEMENT, AND/OR LIGHTED BARRICADES AND CONSTRUCTION FENCE.
- 11. THE TRACKING OF MUD, DIRT, OR DEBRIS, OR SPILLAGE OF THE SAME, UPON STATE ROUTES, COUNTY ROADS, TOWNSHIP ROADS, RESIDENTIAL AND COMMERCIAL DRIVES, SIDEWALKS, OR BIKE PATHS IS PROHIBITED AND ANY SUCH OCCURRENCE SHALL BE CLEANED UP IMMEDIATELY BY THE CONTRACTOR. FAILURE TO REMOVE SAID MUD, DIRT, OR DEBRIS, OR SPILLAGE MAY RESULT IN THE OWNER PROVIDING THAT SERVICE OR WITHHOLDINGS FROM MONEYS WHICH MAY BECOME DUE TO THE CONTRACTOR.

- 12. INGRESS AND EGRESS SHALL BE MAINTAINED AT ALL TIMES TO PUBLIC AND PRIVATE PROPERTY.
- 13. ROADWAY STORM DRAINAGE: I.E. DITCHES, PIPES, CULVERTS SHALL NOT BE OBSTRUCTED DURING SEWER CONSTRUCTION. TEMPORARY EROSION AND SEDIMENTATION MEASURES PER ODOT CMS 670.02 ARE TO BE INSTALLED AND MAINTAINED BY THE CONTRACTOR TO PREVENT SILTATION OF DRAINAGE DITCHES, SEWERS, CULVERTS, ETC.
- 14. ALL TREES, WHETHER SHOWN OR NOT SHOWN ON THE PLANS, ARE TO BE PRESERVED UNLESS APPROVAL TO REMOVE IS GIVEN BY THE OWNER OR THEIR REMOVAL HAS BEEN DESIGNATED ON THE PLANS. THE CONTRACTOR SHALL USE SPECIAL PRECAUTIONS TO AVOID DAMAGE TO ALL OTHER TREES. WHEN REQUIRED, LIMBS SHALL BE CAREFULLY AND NEATLY PRUNED AND PAINTED WITH A SEALING COMPOUND.
- 15. THE CONTRACTOR IS SPECIFICALLY THAT THE LOCATION AND/OR ELEVATION OF EXISTING UTILITIES AS SHOWN ON THESE PLANS IS BASED ON RECORDS OF THE VARIOUS UTILITY COMPANIES AND, WHERE POSSIBLE, MEASUREMENTS TAKEN IN THE FIELD. THE INFORMATION IS NOT TO BE RELIED ON AS BEING EXACT OR COMPLETE.

SANITARY SEWER NOTES:

- 1. ALL SANITARY SEWER PIPE AND FITTINGS AND METHODS OF CONSTRUCTION AND WORKMANSHIP FOR SANITARY SEWER LINES AND APPURTENANCES SHOWN ON THESE PLANS SHALL CONFORM TO THE RULES AND REGULATIONS OF THE VILLAGE OF BYESVILLE, DIVISION OF WASTEWATER, CURRENT ON THE DATE OF THE CONTRACT, UNLESS THE REQUIREMENTS OF SUCH RULES AND REGULATIONS ARE UPGRADED BY THE FOLLOWING SPECIFICATIONS OR BY THE CONSTRUCTION DETAILS SET FORTH HEREIN.
- PRIOR TO THE BEGINNING OF CONSTRUCTION, THE CONTRACTOR SHALL MAKE ALL ARRANGEMENTS NECESSARY TO COORDINATE AND PROVIDE FULL-TIME INSPECTION SERVICE BY THE CITY FOR THE PROPOSED WORK.
- 3. THE DESIGN OF THE SANITARY SEWER COLLECTION SYSTEM SHALL BE SUCH THAT INFLOW AND INFILTRATION OF NON-POLLUTED WATERS IS MINIMIZED.
- 4. MAINTAIN A MINIMUM OF 10' HORIZONTAL AND 18" VERTICAL SEPARATION BETWEEN WATERLINES AS WELL AS SANITARY AND STORM SEWERS. PIPES SHALL BE CONCRETE ENCASED WHERE THE REQUIRED SEWER-WATERLINE SEPARATION CANNOT BE MAINTAINED.
- 5. ROOF DRAINS, FOUNDATION DRAINS, AND OTHER CLEAN WATER SANITARY SEWER CONNECTIONS TO THE SANITARY SEWER SYSTEM ARE PROHIBITED ON THIS PROJECT.
- 6. ALL SANITARY SEWER MANHOLES MUST BE PRECAST CONCRETE AND MEET THE VILLAGE OF BYESVILLE SPECIFICATIONS.
- 7. MANHOLES SHALL BE SET ON A FOUNDATION OF #57 STONE. BACKFILL SHALL CONSIST OF EXCAVATED EARTH MATERIAL, FINELY DIVIDED AND FREE OF STONES 2 INCHES OR GREATER IN DIMENSION TO AT LEAST 1 FOOT ABOVE PIPE TOP.
- 8. SANITARY SEWER LIDS ARE TO BE EAST JORDAN TYPE 1660 (OR APPROVED EQUAL) AND EMBOSSED "SANITARY SEWER".
- 9. MANHOLES SHALL BE BUILT OR ADJUSTED SO THAT THE TOPS CONFORM TO THE ELEVATIONS SHOWN ON THESE PLANS. PRIOR TO AND AFTER CONSTRUCTION, THE CONTRACTOR SHALL VERIFY MANHOLE CONSTRUCTION AND TOP OF CASTING ELEVATION. MANHOLE HEIGHT ADJUSTMENTS SHALL BE BY PRECAST CONCRETE ADJUSTMENT RINGS. PRECAST CONCRETE RISER RINGS ARE TO BE USED FOR ALL FINAL ADJUSTMENT OF MANHOLES.
- 10. SANITARY SEWER MANHOLE TOP OF CASTING SHALL BE SET AT $1\frac{1}{2}$ " ABOVE FINISHED GROUND GRADE, WHEN PLACED OUTSIDE OF PAVED AREAS.
- 11. DISTANCE FROM TOP OF CASTING TO THE FIRST MANHOLE STEP SHALL BE 22" TO 26", PER STANDARD DRAWING AA-S102.
- 12. THE CONTRACTOR'S SPECIFIC ATTENTION IS DIRECTED TO THE REQUIREMENTS OF EITHER INFILTRATION OR EXFILTRATION TEST AS SPECIFIED BY THE VILLAGE OF BYESVILLE. LEAKAGE THROUGH THE JOINTS OF THE SEWER SHALL NOT EXCEED THE FOLLOWING ALLOWABLE LIMITS: 100 GALLONS PER INCH OF TRIBUTARY SEWER DIAMETER PER 24 HOURS PER MILE OF LENGTH OR THE COMPUTED EQUIVALENT FOR SHORTER LENGTHS AND SHORTER PERIODS OF TIME. ALL SANITARY SEWER AND SERVICES SHALL BE TESTED. ALL SANITARY SEWERS SHALL BE SUBJECT TO AND PASS THE INFILTRATION OR EXFILTRATION TEST PRIOR TO ACCEPTANCE. AN AIR TEST IS ACCEPTABLE TO THE VILLAGE OF BYESVILLE. THIS AIR TEST SHALL FOLLOW STANDARD ITEM 901.20.
- 13. THE MINIMUM REQUIREMENTS FOR SANITARY SEWER PIPE SHALL BE SDR 25 OR ASTM D3034 POLYVINYL CHLORIDE (PVC) SEWER PIPE WITH AN ASTM D1784 CELL CLASSIFICATION OF 12454 B OR 12454 C, UNLESS OTHERWISE SHOWN ON THESE PLANS.
- 14. ALL PVC PIPE SHALL BE DEFLECTION TESTED 30 DAYS OR MORE AFTER THE TRENCH HAS BEEN BACKFILLED TO FINISHED GRADE. A RIGID MANDREL SHALL BE USED FOR THE TESTING. NO MECHANICAL PULLING DEVICES SHALL BE USED. PIPE DEFLECTION SHALL NOT EXCEED 5°. PIPE EXCEEDING THE ALLOWABLE DEFLECTION SHALL BE LOCATED, EXCAVATED, REPLACED AND RETESTED AT THE SOLE EXPENSE OF THE CONTRACTOR. VILLAGE ENGINEER OR HIS REPRESENTATIVE MUST WITNESS TEST.
- 15. PIPE BEDDING TO BE CRUSHED # 57 AGGREGATE. ALL PIPES SHALL BE LAID WITH STONE OR GRAVEL BACKING AS SHOWN IN THE DETAILS.
- 16. ALL SANITARY SEWER PIPE TRENCHES SHALL BE IN ACCORDANCE WITH STANDARD DRAWINGS (SEWER PIPE INSTALLATION).
- 17. WHERE THE SANITARY AND STORM SEWER CROSS, THE TRENCH SHALL BE BACKFILLED TO THE BOTTOM OF THE PROPOSED STORM SEWER AND SANITARY LINE WITH COMPACTED GRANULAR MATERIAL, ITEM 304, 10 LINEAR FEET CENTERED ON THE STORM SEWER OR SANITARY SEWER LINE. THE COST OF THIS WORK IS TO BE INCLUDED IN THE BID PRICE FOR THE VARIOUS SEWER ITEMS.
- 18. 6 FOOT LONG CLAY DAMS ARE TO BE INSTALLED ON SANITARY SEWER PIPES AT MAXIMUM INTERVALS OF 150 FEET AND WITH A MINIMUM ONE DAM BETWEEN EACH PAIR OF MANHOLES. COST TO BE INCLUDED WITH VARIOUS SEWER ITEMS.
- 19. SEWER TRENCHES ARE TO BE DEWATERED TO 2" BELOW THE BELL OF PIPE PRIOR TO INSTALLATION.
- 20. TEMPORARY MECHANICAL BULKHEADS SHALL BE PLACED AT THE DOWNSTREAM CONNECTION POINT, AND SHALL REMAIN IN PLACE UNTIL REMOVAL IS DIRECTED BY THE VILLAGE ENGINEER.
- 21. ALL SANITARY LINES SHALL BE CLEANED OF DEBRIS (LEAVES, DIRT, STONE, ECT.) PRIOR TO THE VILLAGE TAKING OWNERSHIP.
- 22. ALL SANITARY TRUNK LINES ARE TO BE CAMERA/VIDEO TAPED PRIOR TO THE VILLAGE OF BYESVILLE'S FINAL ACCEPTANCE. A DIGITAL COPY OF THE MEDIA, WITH A SUMMARY REPORT IS TO BE PROVIDED TO THE VILLAGE ENGINEER.

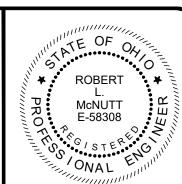


dantas

8150 STERLING COURT MENTOR, OHIO 44060

 $o \mid Z$ ш ≻ : **က** . PROJECT NO. 241455 DISCIPLINE **GENERAL** SHEET NAME

00G-04

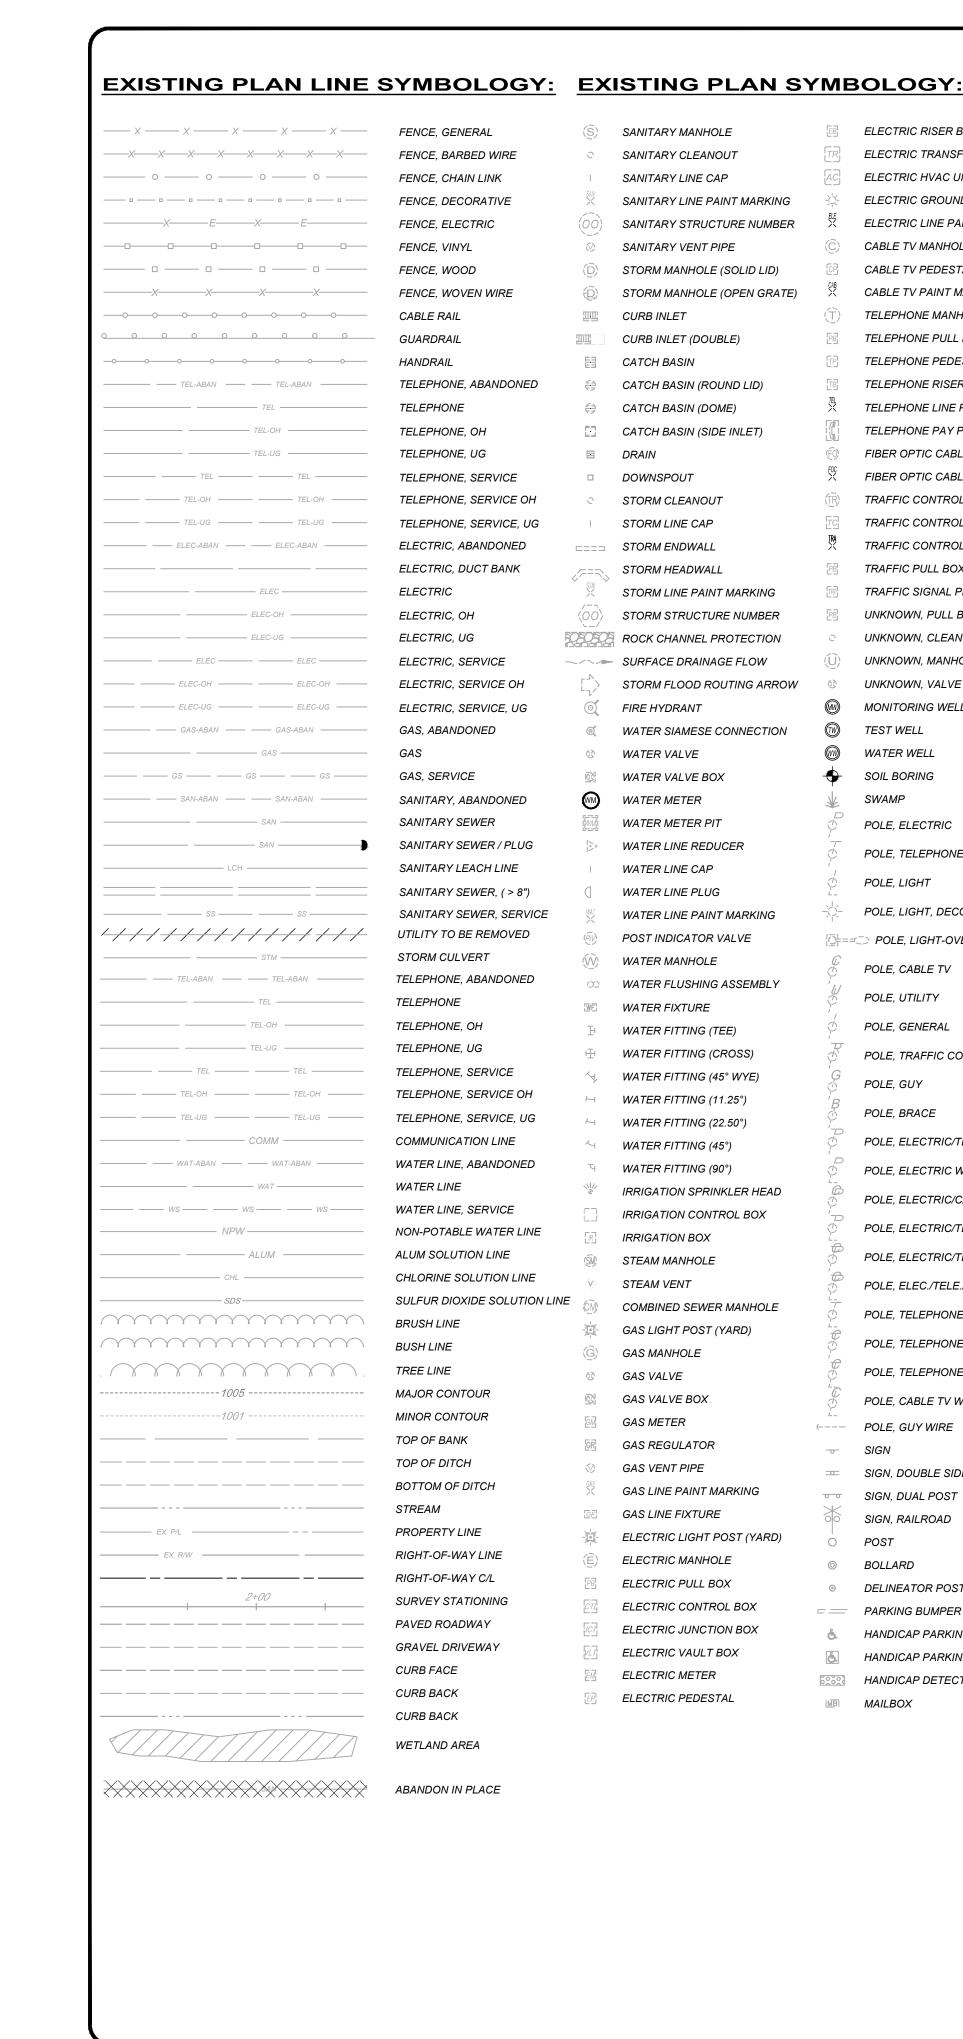

PAPERBOX PARKING METER GRAVE HEADSTONE EX. BARBEQUE GRILL FUEL PUMP ELECTRIC LINE PAINT MARKING FLAG POLE RAISED PAVEMENT MARKER

ELECTRIC RISER BOX

ELECTRIC HVAC UNIT

CABLE TV MANHOLE

CABLE TV PEDESTAL

CABLE TV PAINT MARKING

TELEPHONE MANHOLE

TELEPHONE PULL BOX

TELEPHONE PEDESTAL

TELEPHONE RISER BOX

TELEPHONE PAY PHONE

TRAFFIC CONTROL BOX

TRAFFIC SIGNAL PEDESTAL

TRAFFIC PULL BOX

UNKNOWN, PULL BOX

UNKNOWN, CLEANOUT

UNKNOWN, MANHOLE

UNKNOWN, VALVE

MONITORING WELL

TEST WELL

WATER WELL

SOIL BORING

POLE, ELECTRIC

POLE, LIGHT

POLE, TELEPHONE

POLE, LIGHT, DECORATIVE

POLE, LIGHT-OVERHEAD

POLE, CABLE TV

POLE, UTILITY

POLE, GENERAL

POLE, GUY

POLE, TRAFFIC CONTROL

SWAMP

FIBER OPTIC CABLE MANHOLE

TRAFFIC CONTROL MANHOLE

TELEPHONE LINE PAINT MARKING

FIBER OPTIC CABLE PAINT MARKING

TRAFFIC CONTROL PAINT MARKING

ELECTRIC TRANSFORMER

ELECTRIC GROUND LIGHT

GUARDRAIL, CENTER POST GUARDRAIL, TERMINAL POST GUARDRAIL, BOTTOM POST GUARDRAIL, TOP POST FENCE POST PICNIC TABLE **BENCH** DECIDUOUS TREE

EVERGREEN TREE STUMP IRON PIN FOUND SOLID IRON PIN FOUND IRON PIPE FOUND CHISELED "X" FOUND

MONUMENT BOX FOUND MONUMENT CONCRETE FOUND MONUMENT RIGHT-OF-WAY FOUND PK NAIL FOUND MAG NAIL FOUND SPIKE FOUND **HUB FOUND**

AXLE FOUND WOOD POST FOUND CORNER STONE FOUND AERIAL TARGET FOUND GPS CONTROL FOUND

BENCHMARK FOUND

POLE, BRACE POLE, ELECTRIC/TELEPHONE POLE. ELECTRIC W/LIGHT POLE, ELECTRIC/CABLE TV POLE, ELECTRIC/TELEPHONE/LIGHT POLE, ELECTRIC/TELEPHONE/CABLE TV POLE, ELEC./TELE./LIGHT/CABLE TV POLE, TELEPHONE/LIGHT POLE, TELEPHONE/CABLE TV POLE, TELEPHONE/LIGHT/CABLE TV POLE, CABLE TV W/LIGHT POLE, GUY WIRE SIGN


SIGN, DUAL POST SIGN, RAILROAD POST BOLLARD DELINEATOR POST = PARKING BUMPER BLOCK HANDICAP PARKING SYMBOL HANDICAP PARKING SYMBOL HANDICAP DETECTABLE WARNING MAILBOX

SERIES INFORMATION:

GENERAL - 00 SERIES PLAN & PROFILE - PP SERIES LIFT STATION - 10 SERIES STANDARD DETAILS - SD SERIES **EROSION CONTROL - EC SERIES**

GENERAL CIVIL **PROCESS**

INDEX EXPLAINATION:

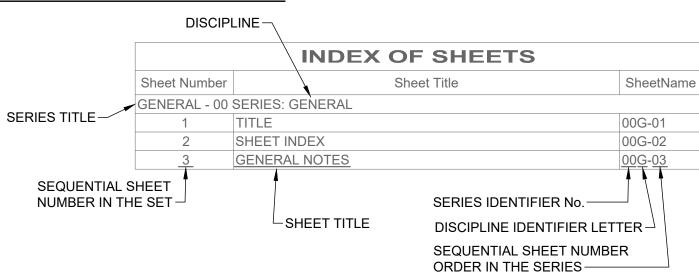

GENERAL SYMBOLOGY NOTES:

- THIS IS A STANDARD SHEET SHOWING COMMONLY USED SYMBOLOGY.
- 2. ALL SYMBOLS ARE NOT NECESSARILY USED ON THIS PROJECT.
- SCREENING OR SHADING OF WORK IS USED TO INDICATE EXISTING COMPONENTS OR TO DE-EMPHASIZE NEW IMPROVEMENTS SO AS TO HIGHLIGHT SPECIFIC TRADE WORK. REFER TO CONTEXT OF EACH SHEET FOR USAGE.
- 4. SYMBOLOGY OR DIAGRAMMATICAL LEGENDS MAY BE SHOWN ON INDIVIDUAL SHEETS FOR SCHEDULES, DIAGRAMS, DETAILS, SCHEMATICS OR EQUIPMENT.

PLAN REVISIONS: **DEMOLITION CODED NOTES:**


/A\ REVISION DESCRIPTION

1 DEMOLITION DESCRIPTION

/B\ REVISION DESCRIPTION

2 DEMOLITION DESCRIPTION

DETAIL REFERENCES:

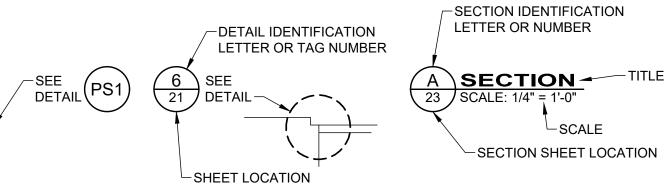

MAJOR SECTION CUT CONVENTIONS: -SECTION IDENTIFICATION LETTER OR NUMBER -SHEET WHERE SECTION IS FOUND SECTION PATH-

12'-4" (REF.) REFERENCE DIMENSIONS ARE GIVEN FOR INFORMATION ONLY. THEY ARE CALCULATED DIMENSIONS NOT INTENDED TO BE USED WITHOUT FIELD VERIFICATION AND ARE USEFUL IN SHOWING INTENDED DESIGN.

REFERENCE DIMENSION

DISCIPLINE INFORMATION:

IDENTIFIER: DISCIPLINE: **STRUCTURAL ARCHITECTURAL** MECHANICAL (PLUMBING & HVAC) ELECTRICAL INSTRUMENTATION

DRAWING CODED NOTE TYPES:

CT CONTRACTUAL NOTES ARE DEPICTED WITH A HEXAGON, SQUARE, CIRCLE OR TRIANGLE. ALL OTHER EXISTING WRITTEN CALLOUTS SHOWN ON THE REUSED SCANNED PLANS, SECTIONS & DETAILS ARE FOR EXISTING CONDITIONS AND REFERENCE ONLY, MANY OF THOSE NOTES FROM THE SCANNED DRAWINGS PERTAIN TO PREVIOUS WORK DONE.

VALVE OPERATOR ID:

CH = CHAIN EM = ELECTRIC MOTOR ES = EXTENSION STEM FB = FLOOR BOX

FS = FLOOR STAND GE = GEAR HC = HYDRAULIC CYLINDER HW = HANDWHEEL LE = LEVER

LW = "L" WRENCH ON = OPERATING NUT PC = PNEUMATIC CYLINDER PD = PNEUMATIC DIAPHRAGM TW = "T" WRENCH

VB = VALVE BOX

TH = THREADED

W = WELDED

PIPE END JOINT ID:

BE = BELL CM = COMPRESSION FL = FLANGED GR = GROOVED LU = LUG MJ = MECHANICAL JOINT NPT = NATIONAL PIPE THREAD RJ = RESTRAINED JOINT PE = PLAIN END = SOLDERED = SLIP JOINT (PUSH ON) SW = SOLVENT WELDED

GATE ABBREVIATIONS:

BG - BULKHEAD GATE SG - SLIDE GATE - STOP PLATE SL - STOP LOG **ALUM - ALUMINUM** SS - STAINLESS STEEL CI - CAST IRON POLY - POLYMER B/C - BOTTOM OF CHANNEL T/C - TOP OF CHANNEL A - HEIGHT - WIDTH В

ABBREVIATIONS

PIPE MATERIAL ID: BR = BRASS

BS = BLACK STEEL BZ = BRONZE ALUM. = GRAY CAST IRON BTWN CU = COPPER C/L CS = CAST IRON CLR = CARBON STEEL TUBING CONC DIP = DUCTILE IRON PIPE CONT DR = DIAMETER RATIO DWL FRP = FIBERGLASS REINFORCED PLASTIC

GS = GALVANIZED STEEL HDPE = HIGH-DENSITY POLYETHYLENE PIPE PVC = POLYVINYL CHLORIDE PIPE SS = STAINLESS STEEL STL = STEEL PIPE

SDR = STANDARD DIAMETER RATIO SCH = SCHEDULE

VALVE ID:

AN = ANGLE VALVE

BA = BALL VALVE

CV = CHECK VALVE

CO = CONE VALVE

GV = GATE VALVE

KN = KNIFE VALVE

PI = PINCH VALVE

PV = PLUG VALVE

MV = MUD VALVE

GL = GLOBE VALVE

KG = KNIFE GATE VALVE

PD = PLUG DRAIN VALVE

PF = PRESSURE RELIEF

SV = SOLENOID VALVE

TE = TELESCOPING VALVE

SU = SURGE VALVE

PG = PRESSURE REGULATOR

PRV= PRESSURE REDUCING VALVE

RF = RATE-OF-FLOW CONTROLLER

TM = TEMPERATURE CONTROL VALVE

AC = AIR CHECK VALVE

AR = AIR RELEASE VALVE

AV = AIR & VACUUM VALVE

B'FLY = BUTTERFLY VALVE

BK = BACKPRESSURE VALVE

BP = BACKFLOW PREVENTER

CI

OTHER:

ADD'L = ADDITIONAL AGG = AGGREGATE = ALUMINUM = BETWEEN = CWNTERLINE = CLEAR = CONCRETE = CONTINUOUS = DOWEL(S) = EACH FACE = ELEVATION EMBED = EMBEDMENT

= EACH WAY EW = FINISH FLOOR = FINISH GRADE FND = FOUNDATION HORIZ = HORIZONTAL = HIGH POINT = LOW POINT MAX = MAXIMUM

= MANUFACTURER = MINIMUM REF = REFERENCE REINF = REINFORCING STRC = STRUCTURE = TOP OF

TYP = TYPICAL UNO = UNLESS NOTED OTHERWISE VERT = VERTICAL

EQUIPMENT ID:

AER = AERATOR B = BLOWER BFP = BELT FILTER PRESS CLS = CLASSIFIER C = COMMUNITOR CMP = COMPACTOR CFD = CHEMICAL FEEDER CNV = CONVERYOR

CNT = CENTRIGUGE CC = CALIBRATION CYLINDER CFD = CHEMICAL FEEDER CP = CONTROL PANEL

CR = CRANE D = DECANTER DR = DRIVE DFL = DISC FILTER

FL = FILTER FM = FLOW METER GBT = GRAVITY BELT THICKENER

GR = GRINDER

HB = HOSE BIB M = MOTORMX = MIXER

P = PUMP PS = PUMP STATION SMP = SAMPLER SCR = SCREEN

AC = AIR COMPRESSOR

F = FAN

PT = PRESSURE TEMPERATURE RELIEF

GEN = GENERATOR

ATE OF ON

ROBERT McNUTT

E-58308


PROJECT NO. 241455 DISCIPLINE **GENERAL**


SHEET NAME 00G-05 24





 $H: \c 1.2024 \c 1.41455 \c 1.0000 \c 1.2024 \c 1.41455 \c 1.0000 \c 1.2000 \c 1.2000$




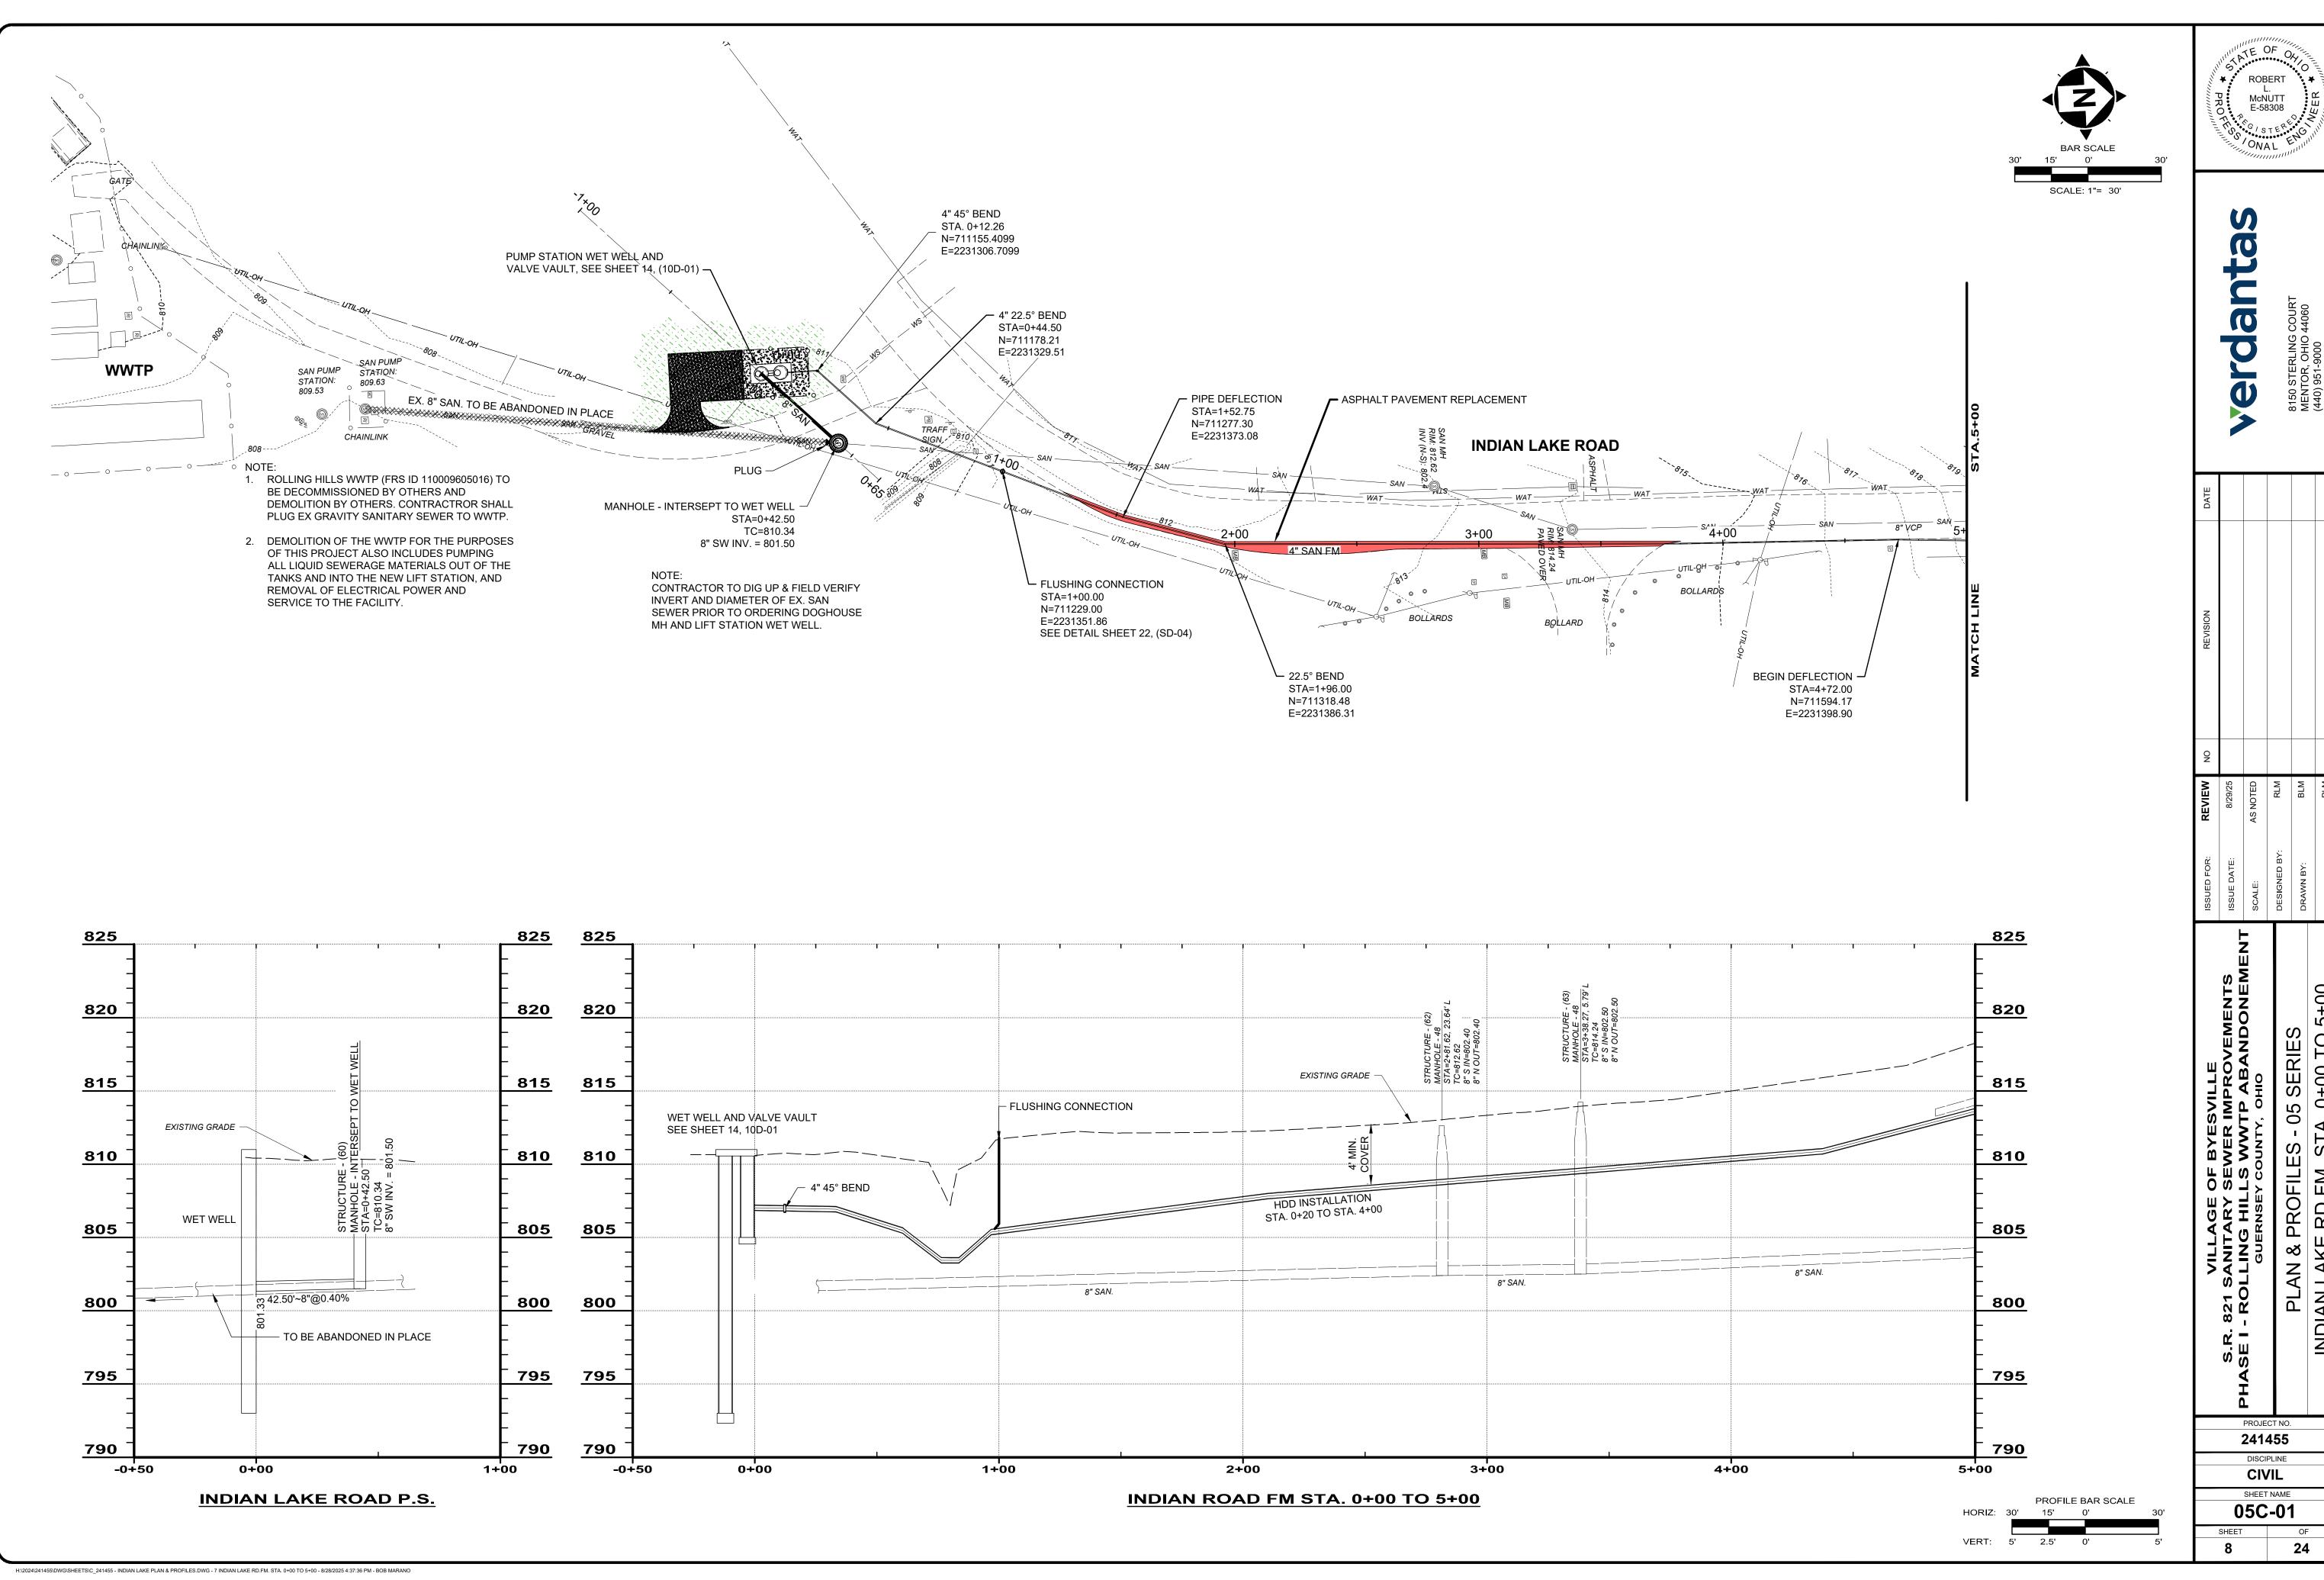

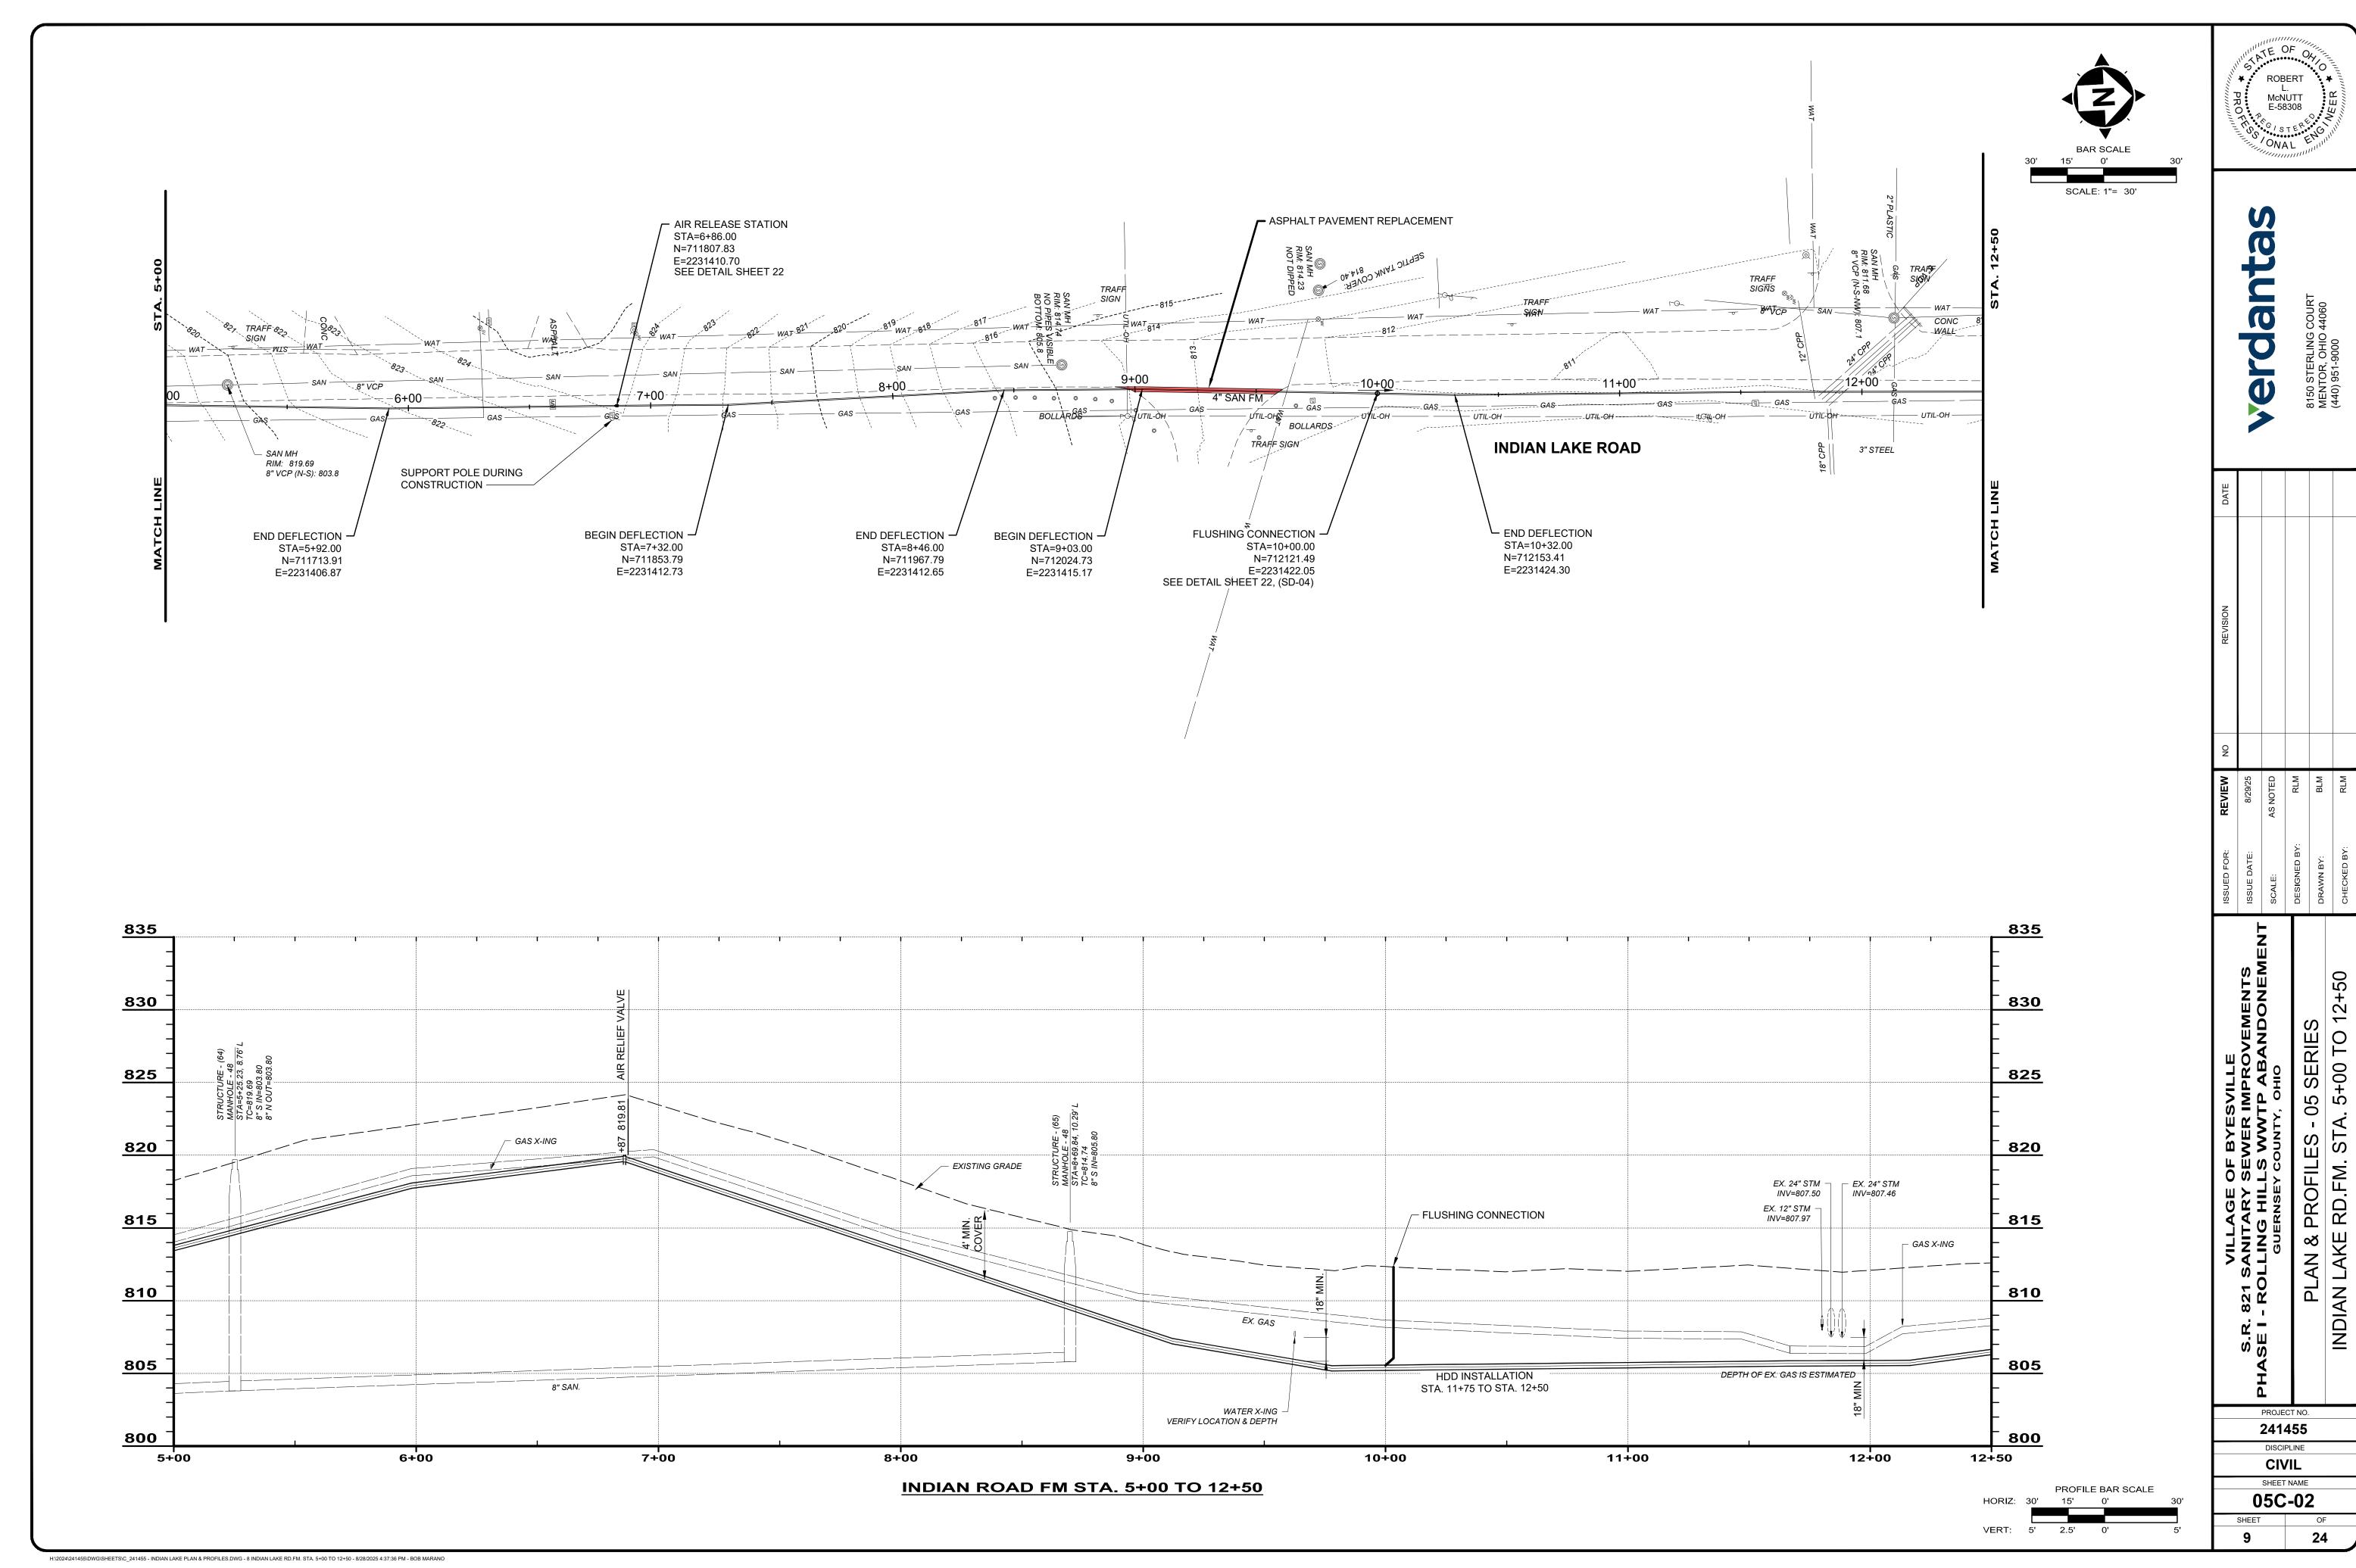

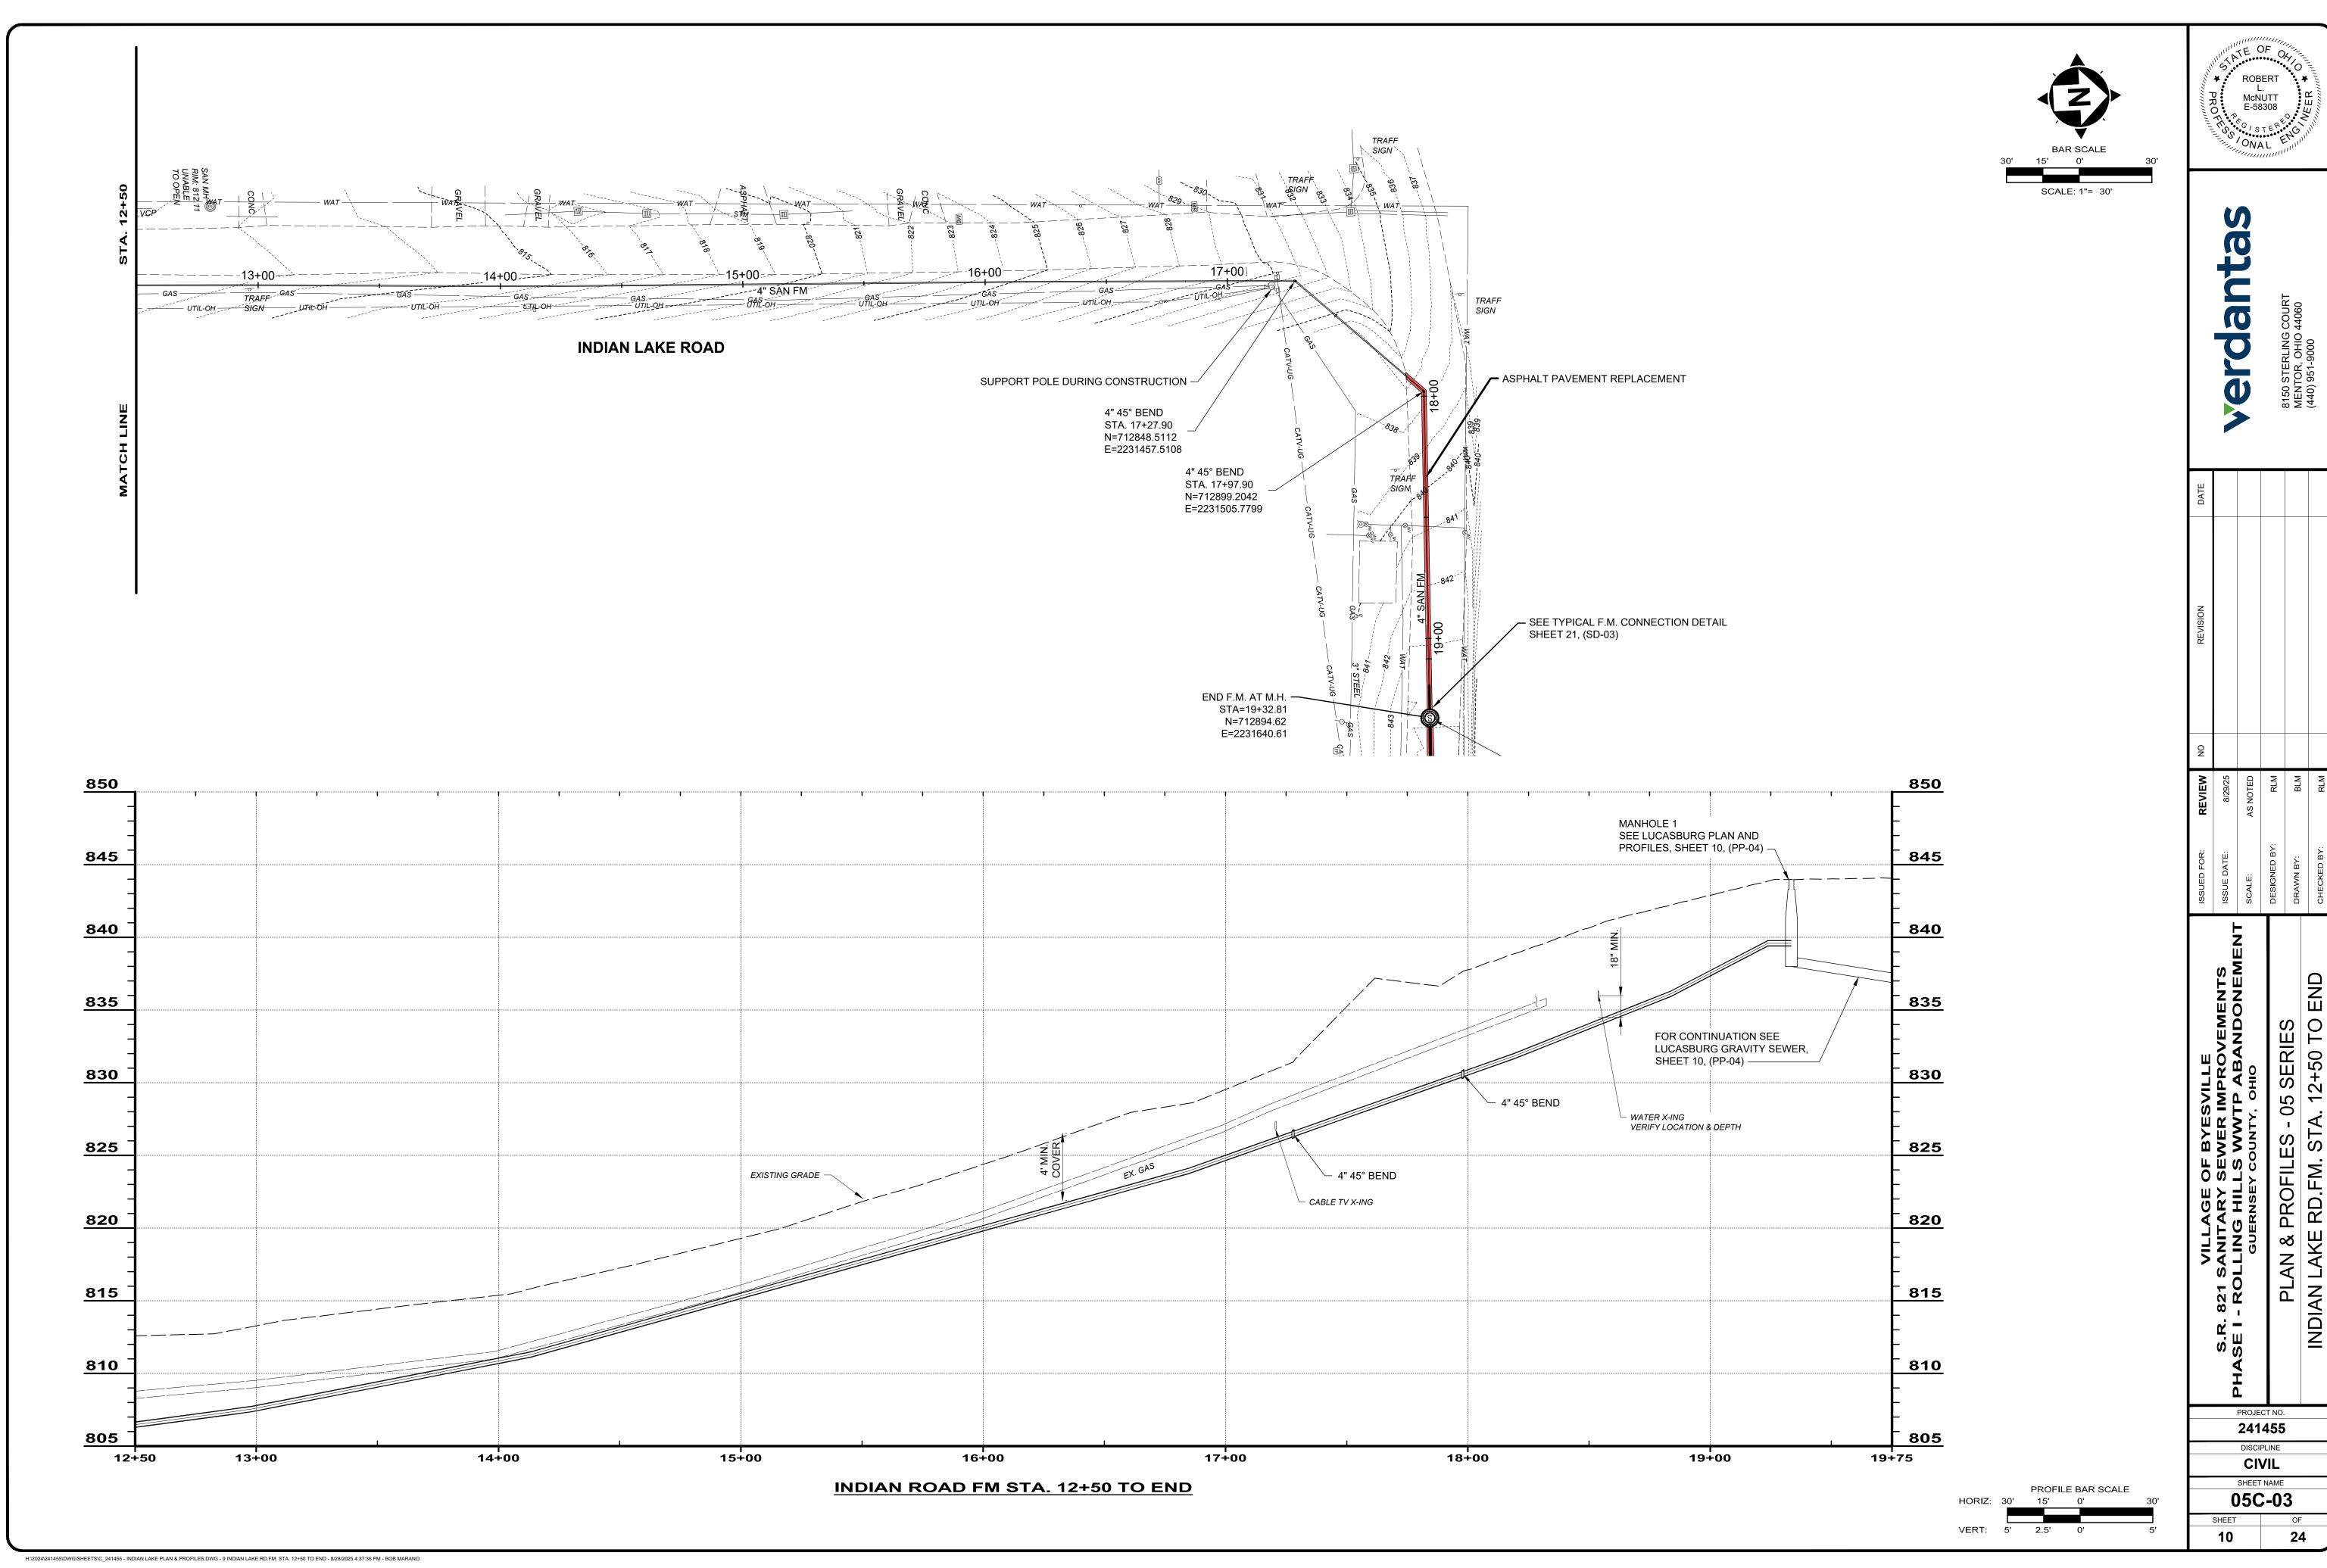

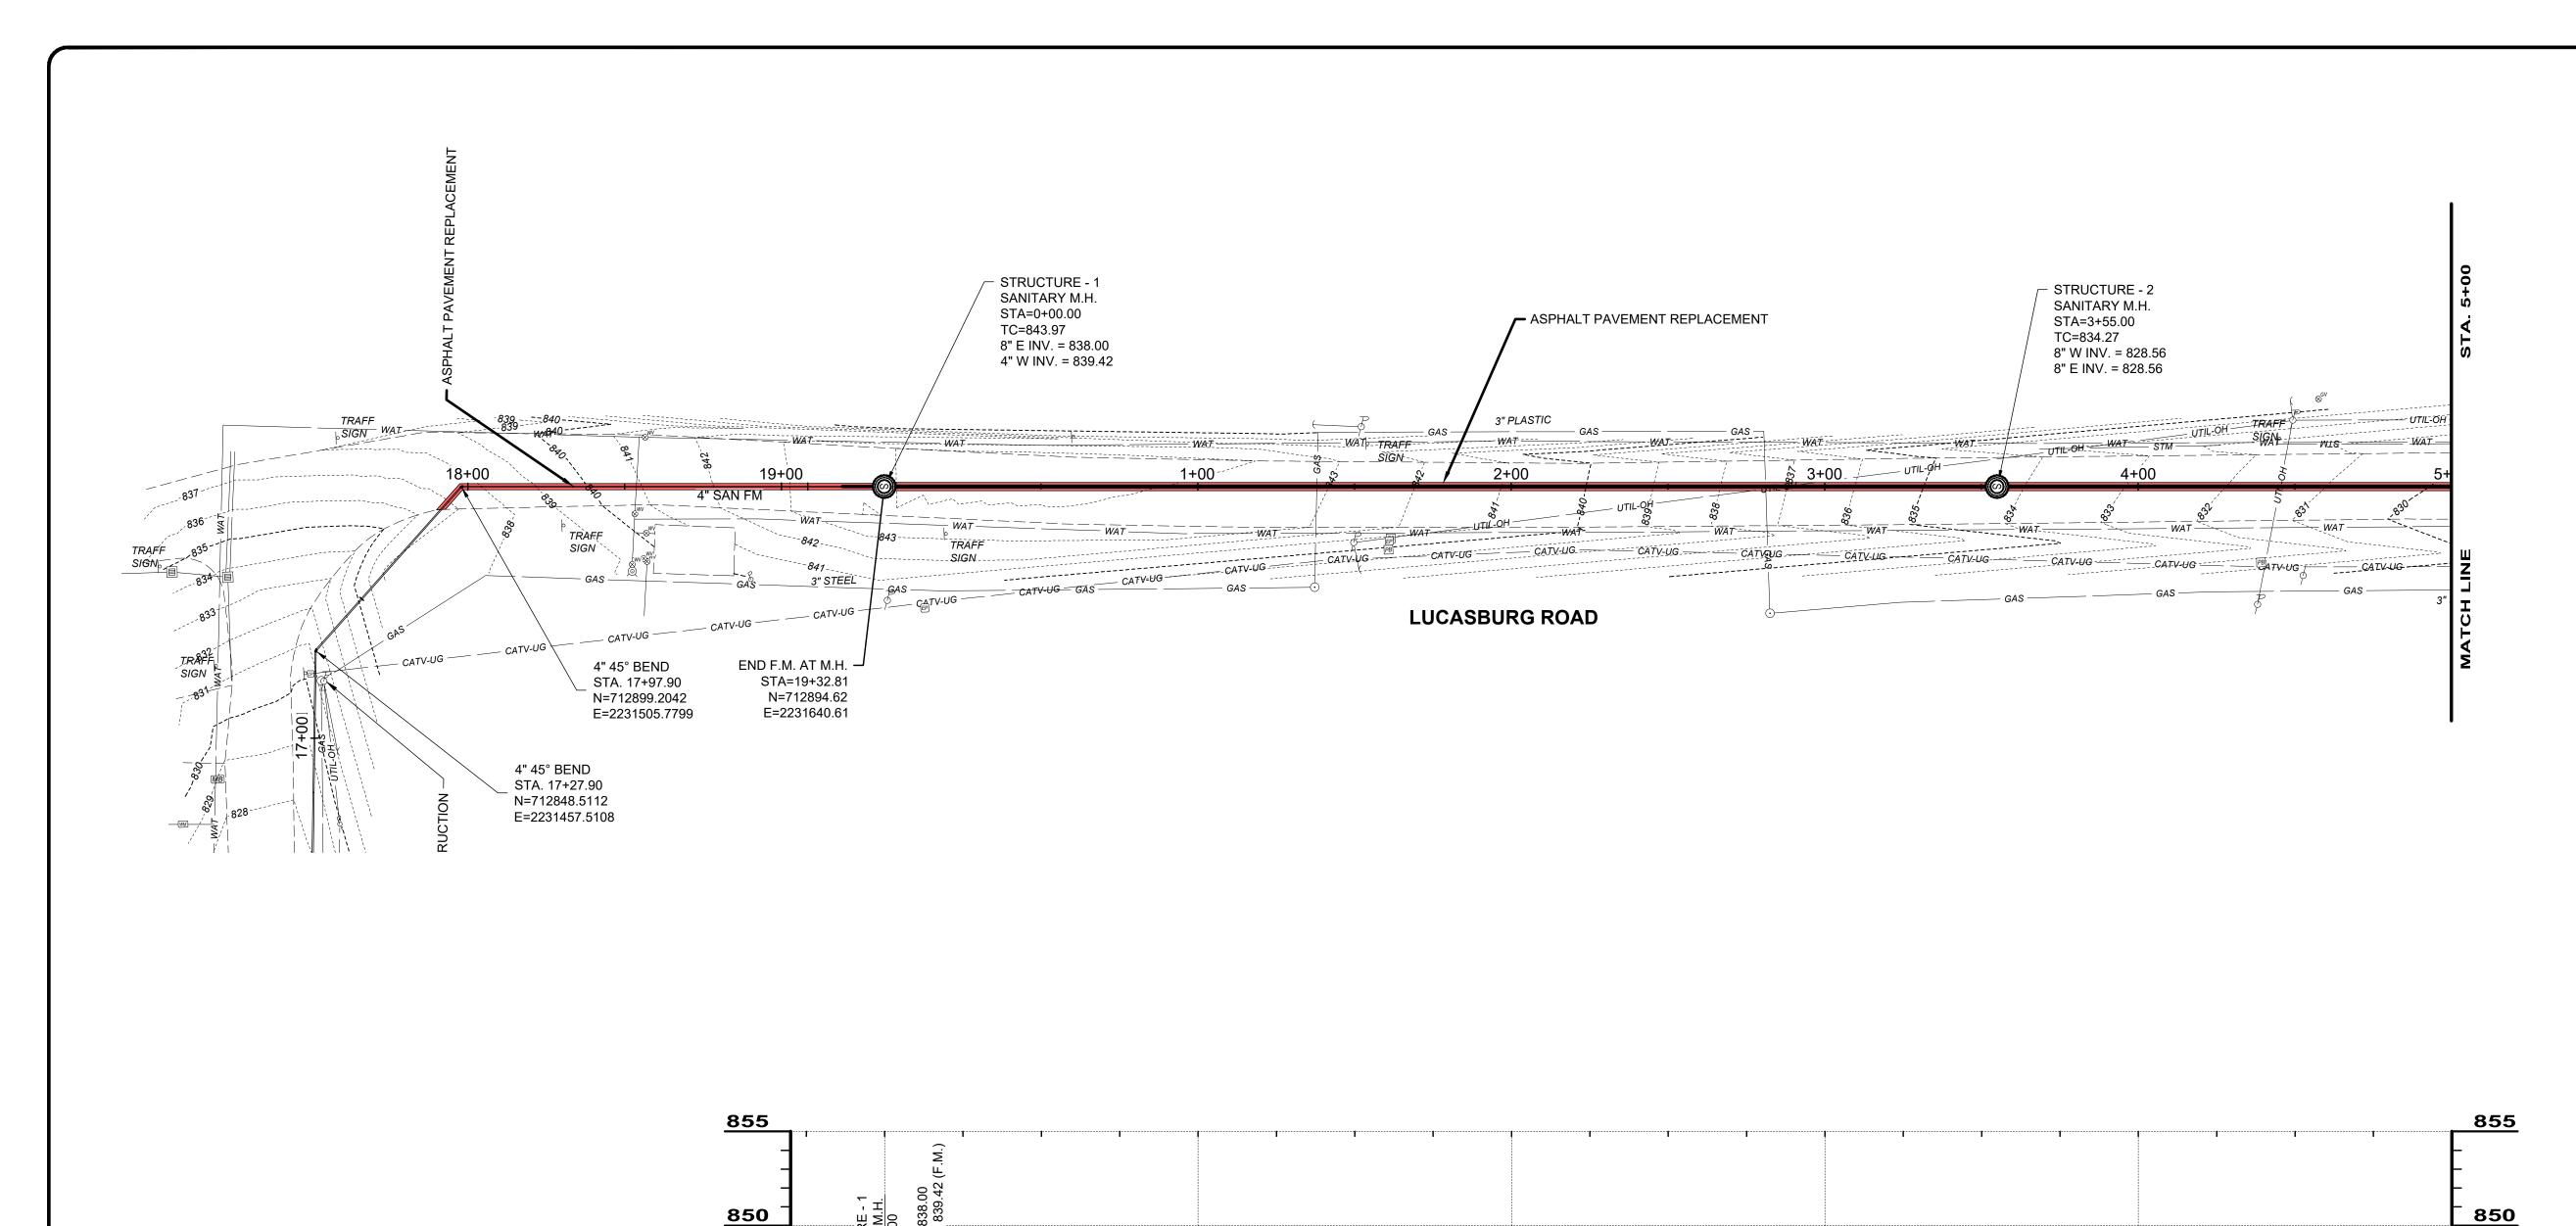

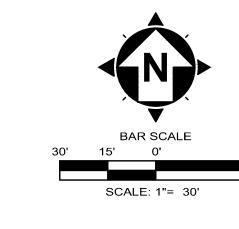

ROBERT McNUTT E-58308

ON					
REVIEW N	8/29/25	AS NOTED	RLM	ВГМ	RLM
ISSUED FOR:	ISSUE DATE:	SCALE:	DESIGNED BY:	DRAWN BY:	CHECKED BY:
VILLAGE OF BYESVILLE	S.R. 821 SANITARY SEWER IMPROVEMENTS	GUERNSEY COUNTY, OHIO		PLAN & PRUFILES - 05 SERIES	LUCASBURG RD. GRAVITY STA. 0+00 TO 5+00

PROJECT NO. 241455 DISCIPLINE


840


835

825


CIVIL SHEET NAME 05C-04

		EXISTING GRADE			
				RE - 2 M.H. 00 = 828.56 828.56	
840				RE	
- - -				STRUCTU SANITARY STA=3+55 TC=834.21 8" W. INV. 8" E INV. =	
835					
-	4" INDIAN LAKE ROAD F.M. SEE SHEET 9, (PP-03)	355.00'~8"@2.66%			
830					
-					
825					
-					
820				<u> </u>	
-0+	30 0+00 1+	00 2-	+00 3+	-00 4	+00
		LUCASBUR	G GRAVITY STA. 0+00 TO	<u>5+00</u>	

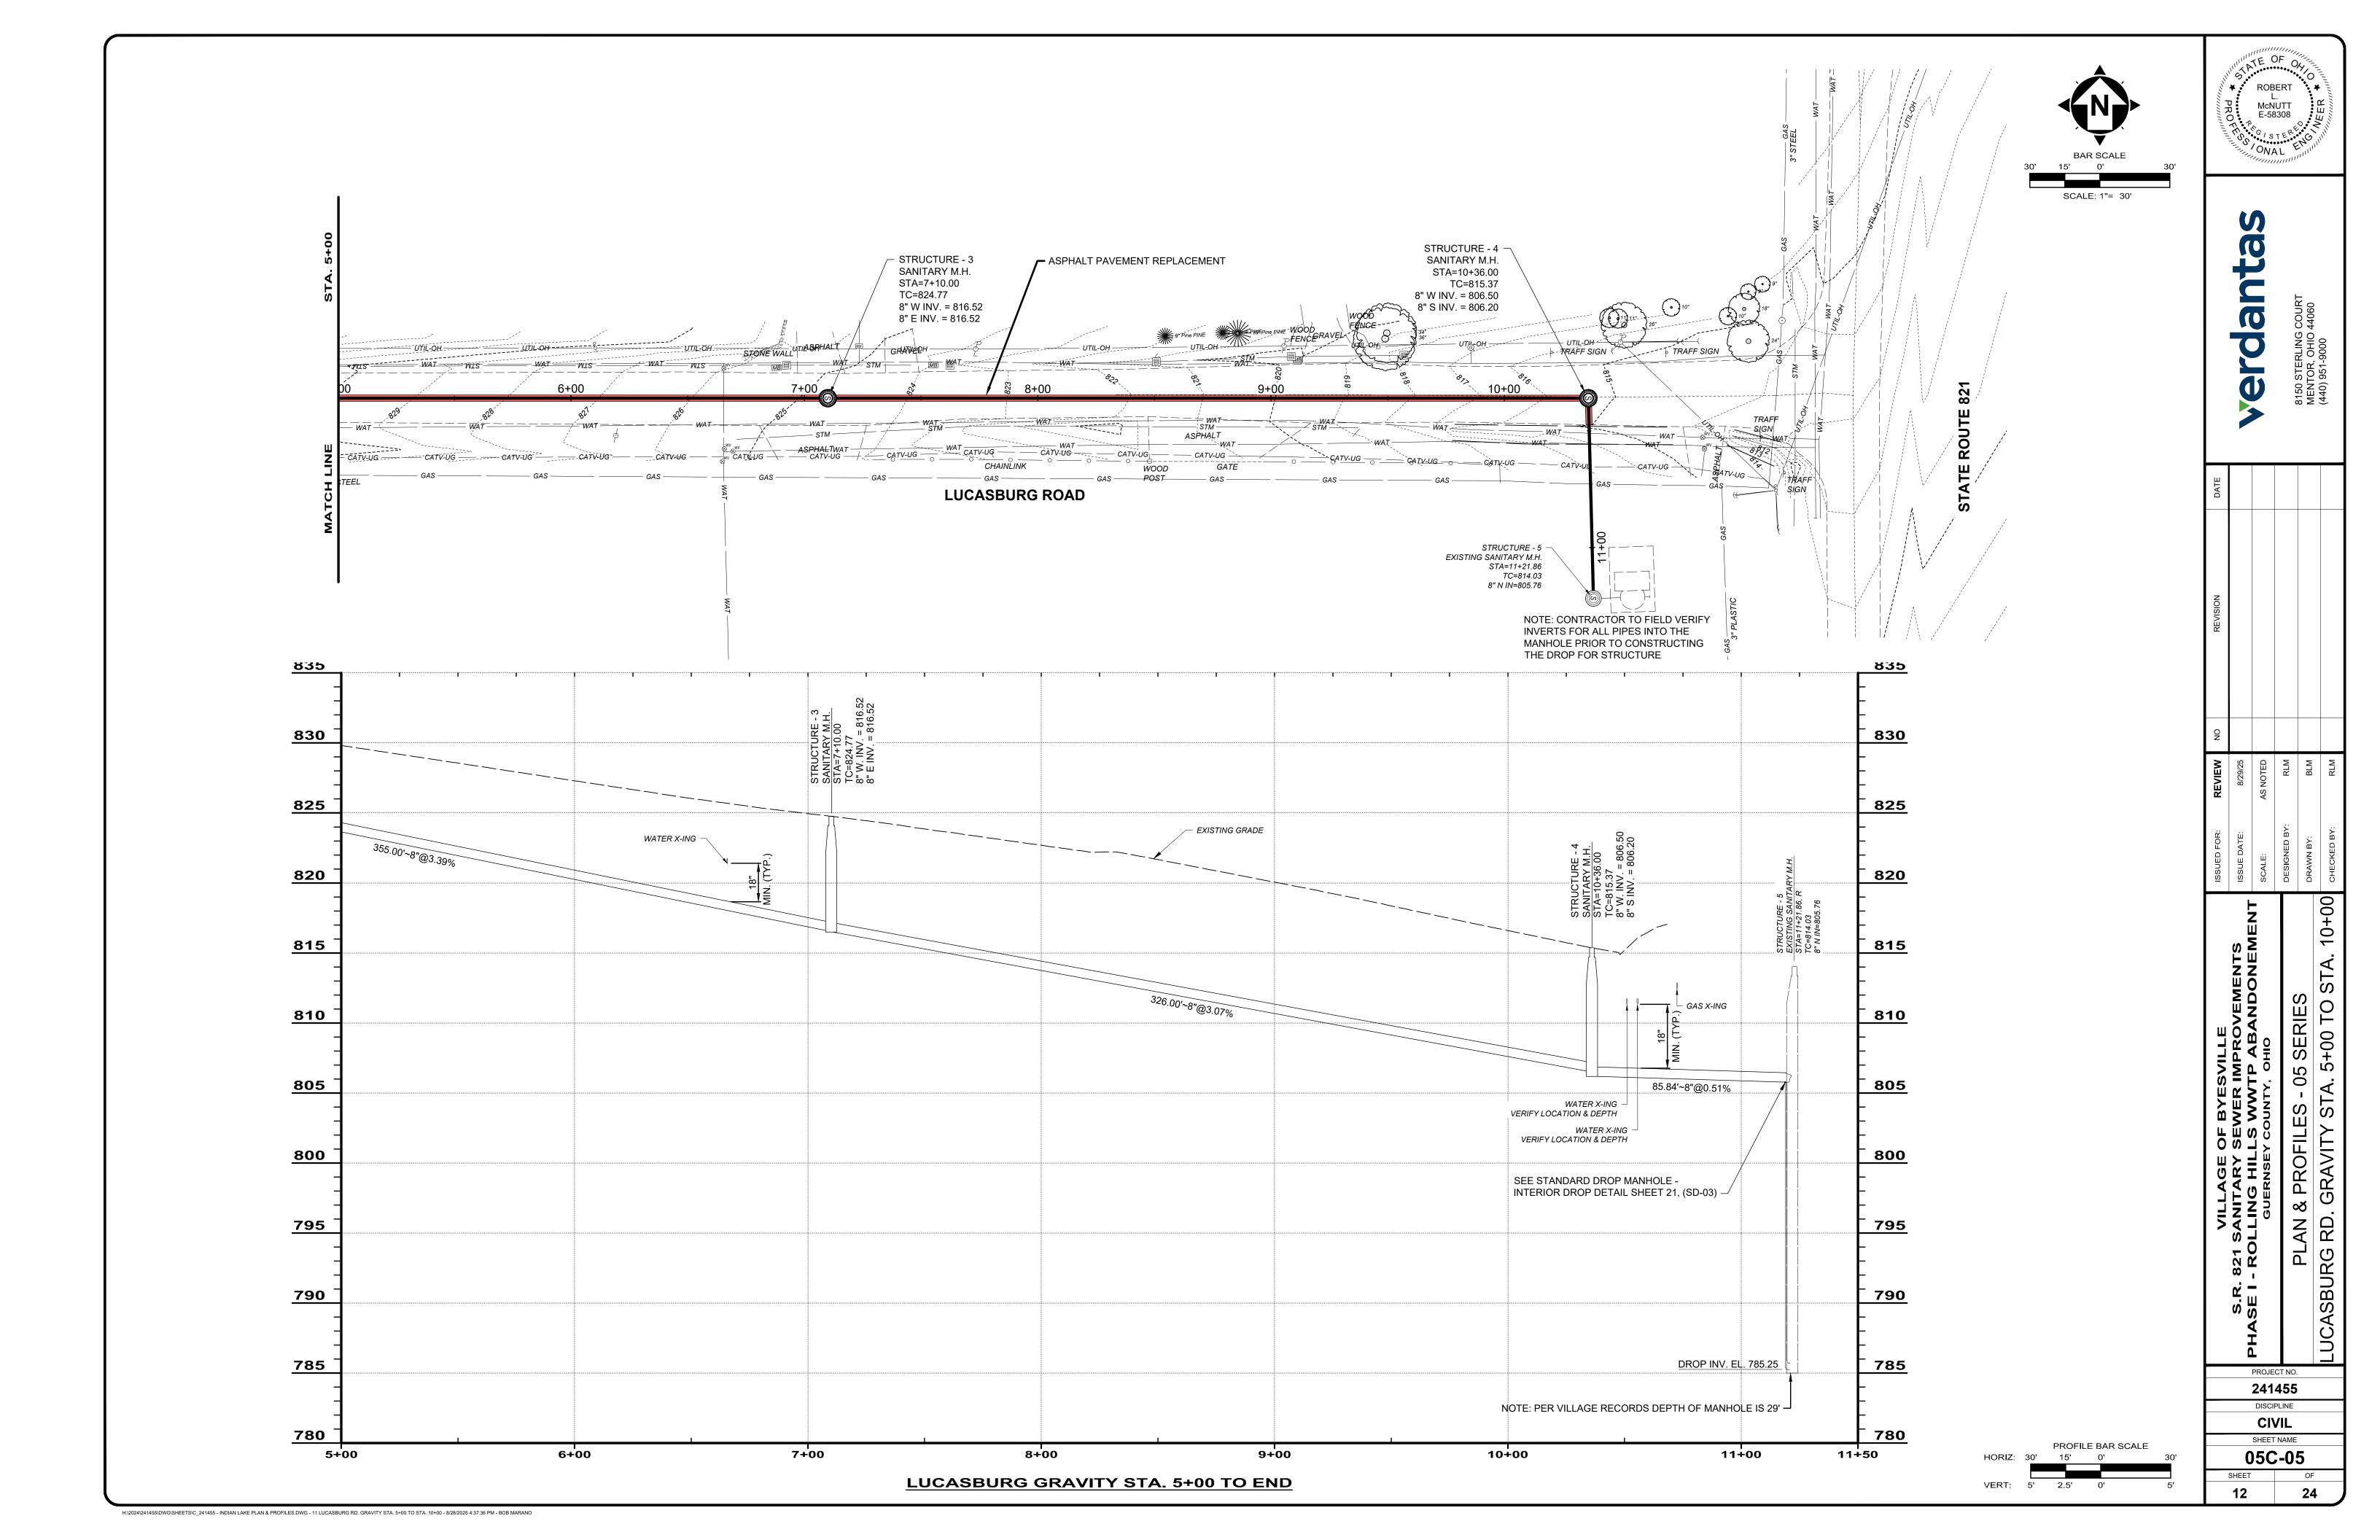

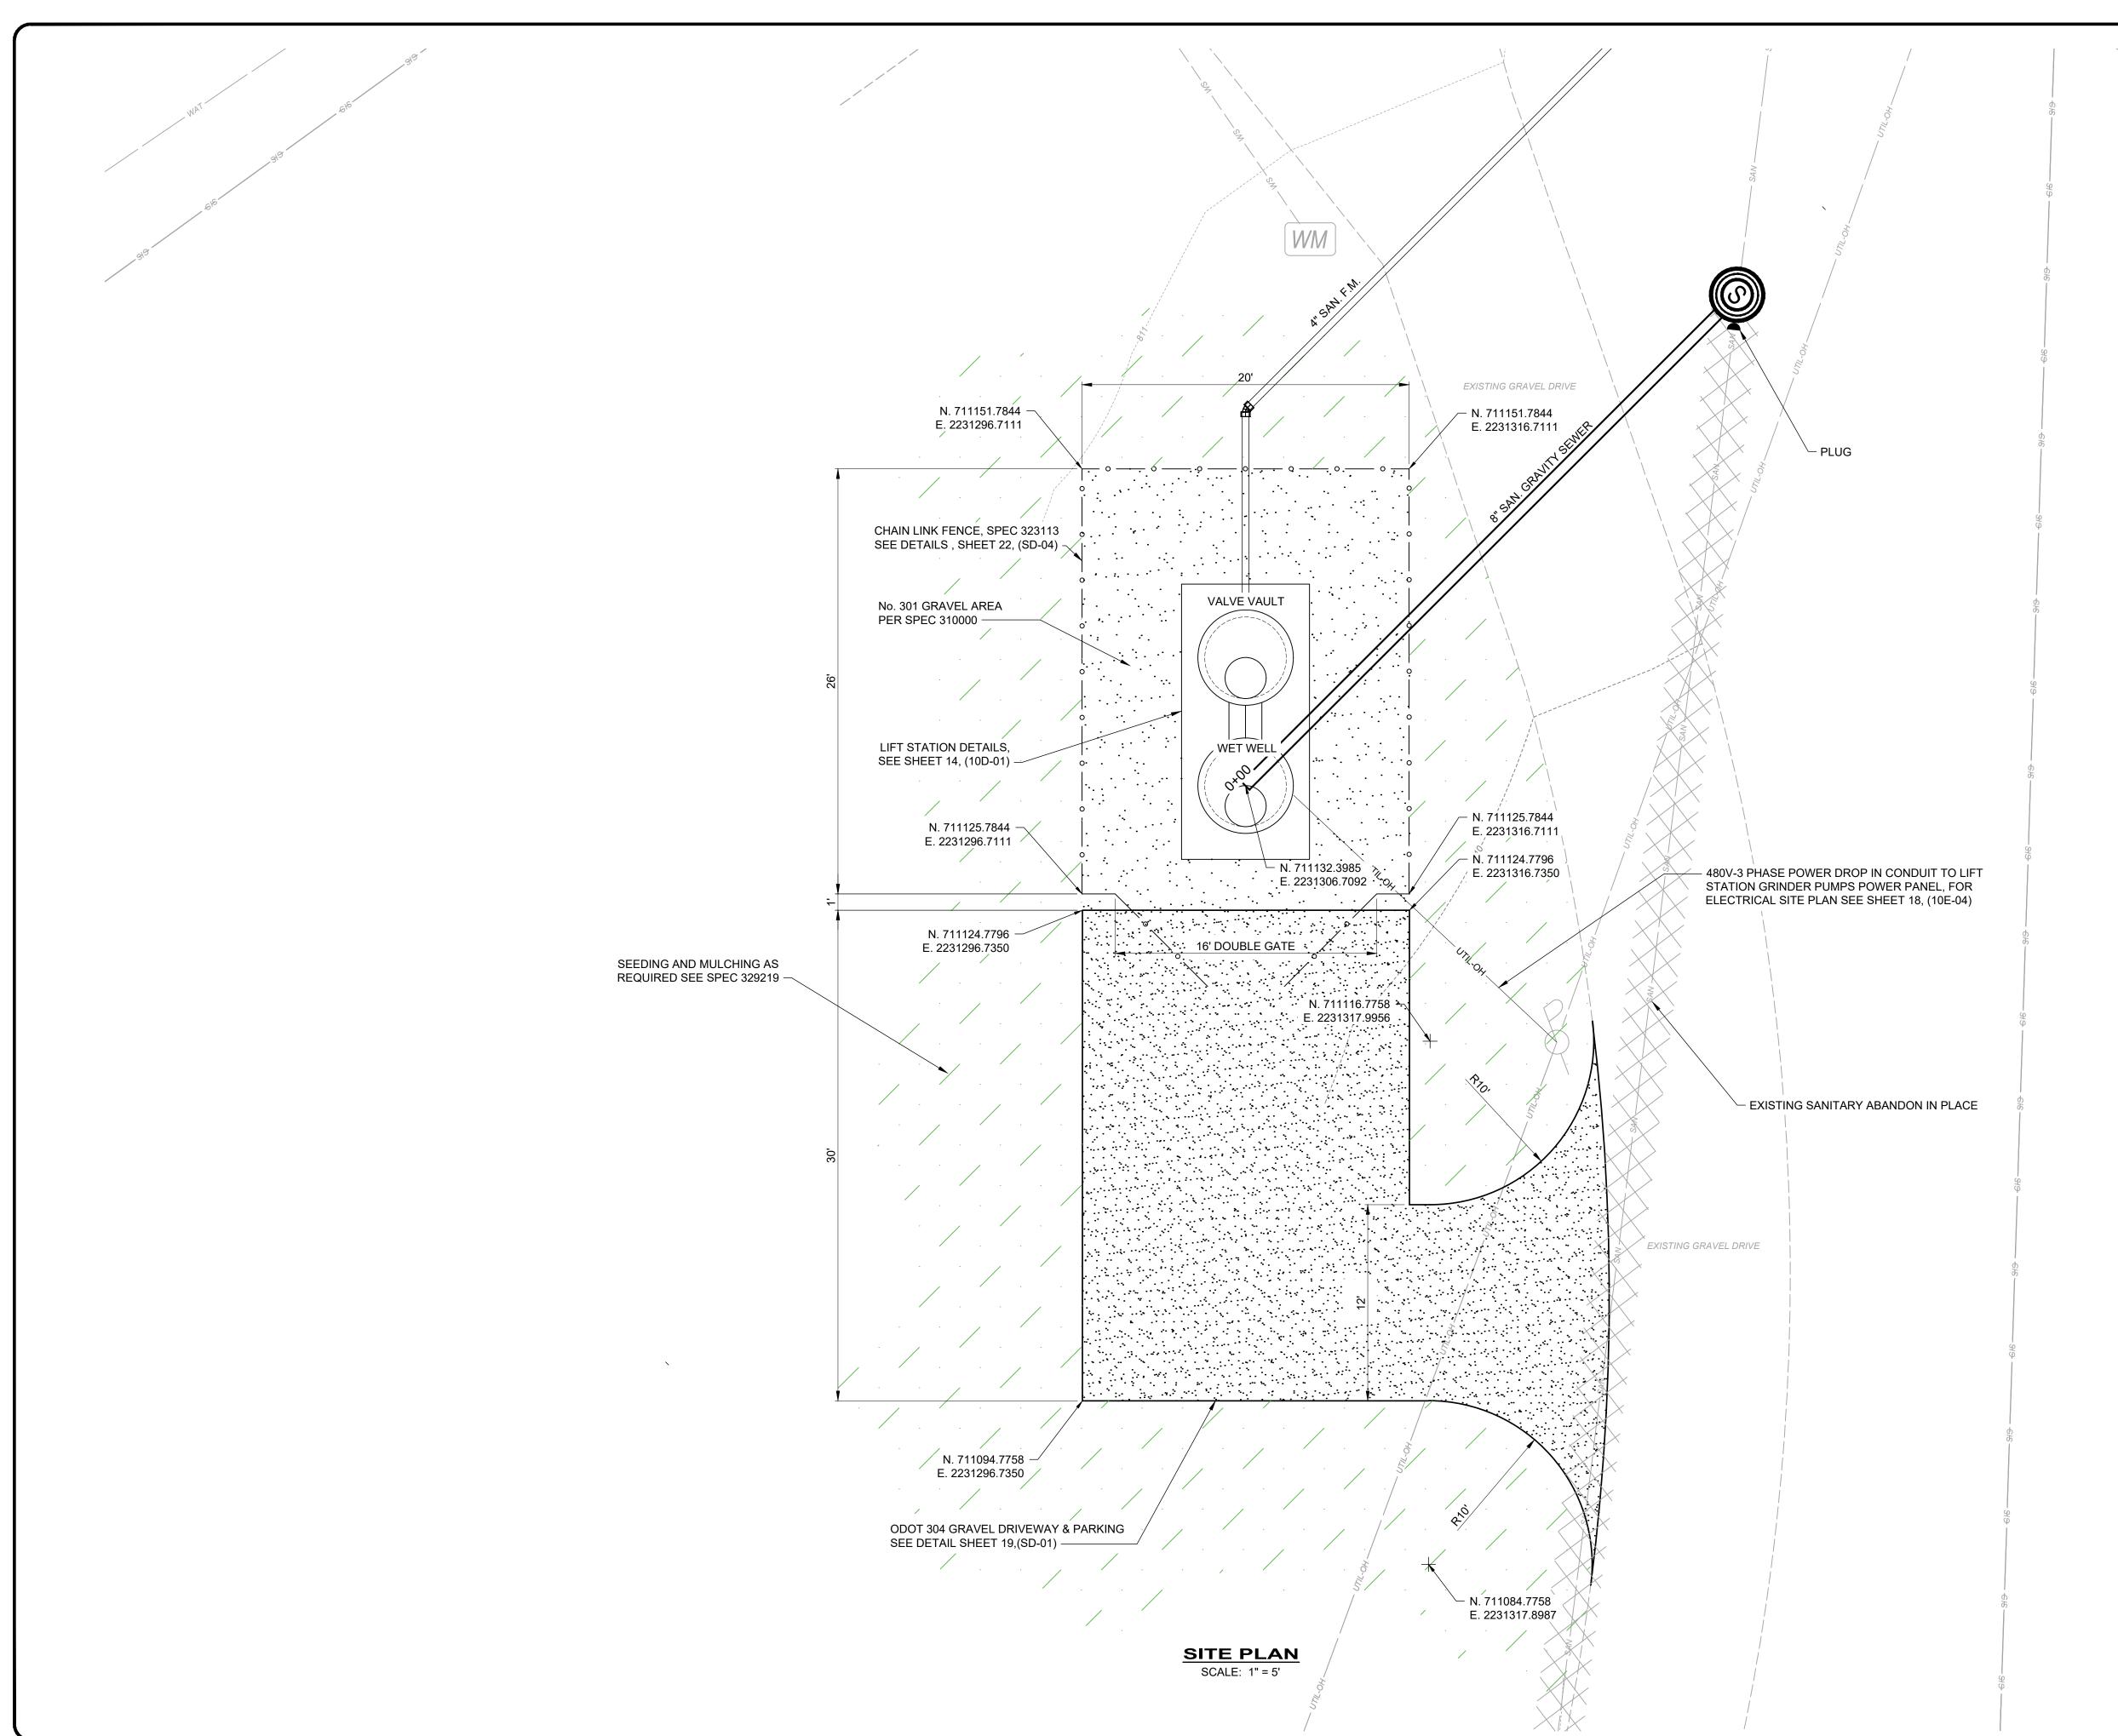



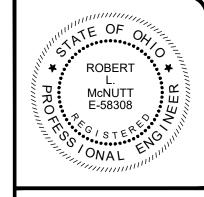



				8150 STERLING COURT MENTOR: OHIO 44060	(440) 951-9000	
DATE						
REVISION						
ON						
REVIEW	8/29/25	AS NOTED	RLM	RLM	RLM	
ISSUED FOR:	ISSUE DATE:	SCALE:	DESIGNED BY:	DRAWN BY:	CHECKED BY:	
VILLAGE OF BYESVILLE	S.R. 821 S			LIFI STATION - TO SERIES	PUMP STATION SITE PLAN	
		PROJE 241				

CIVIL

SHEET NAME

10C-01

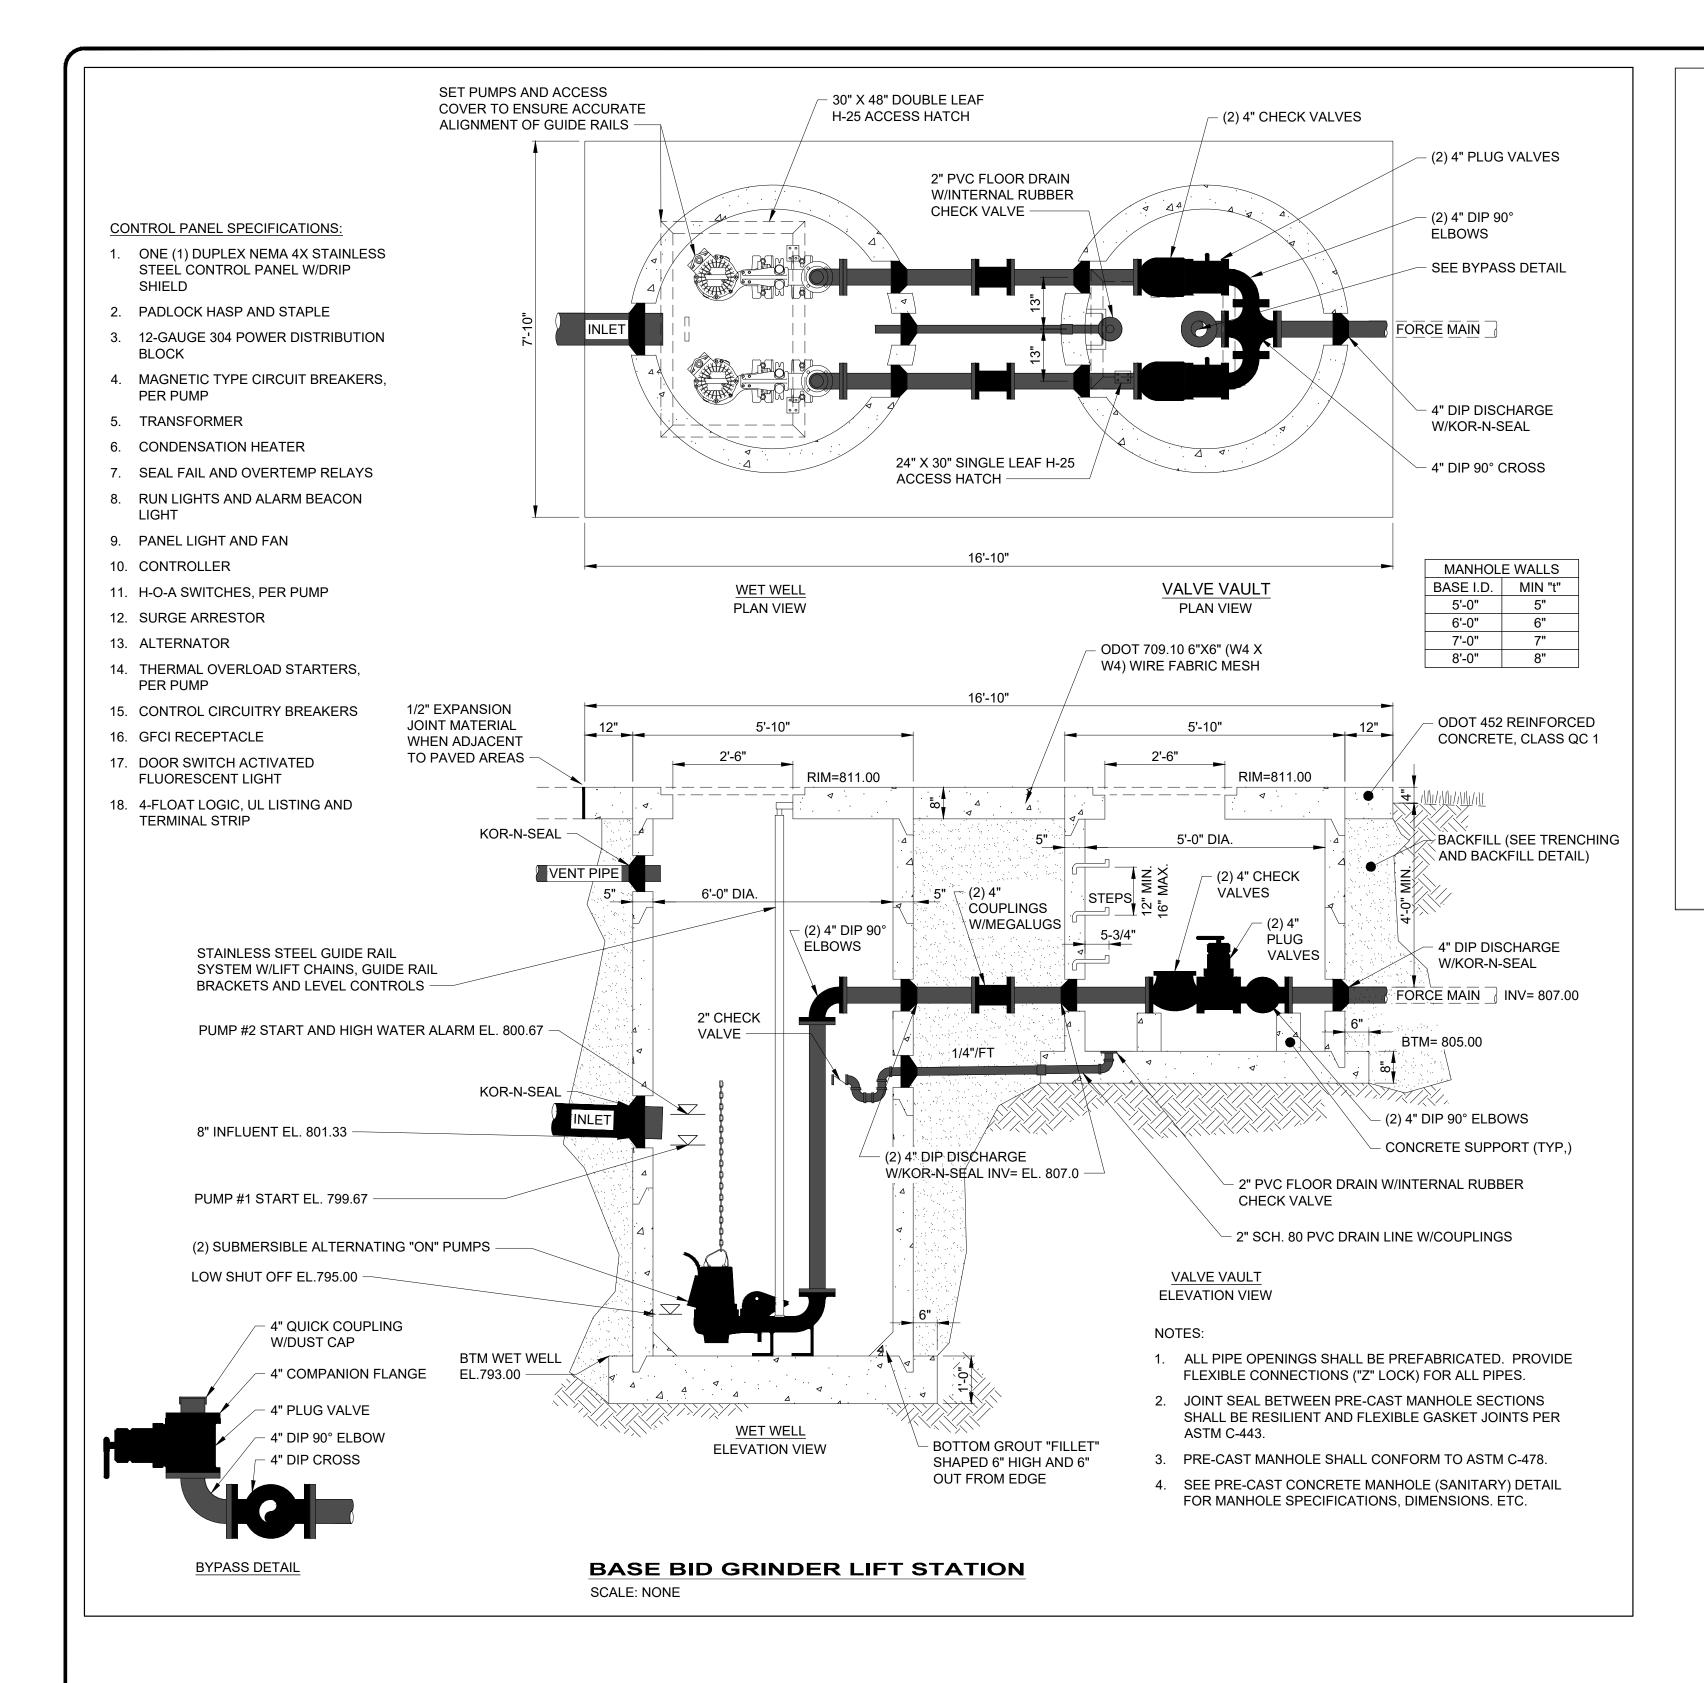

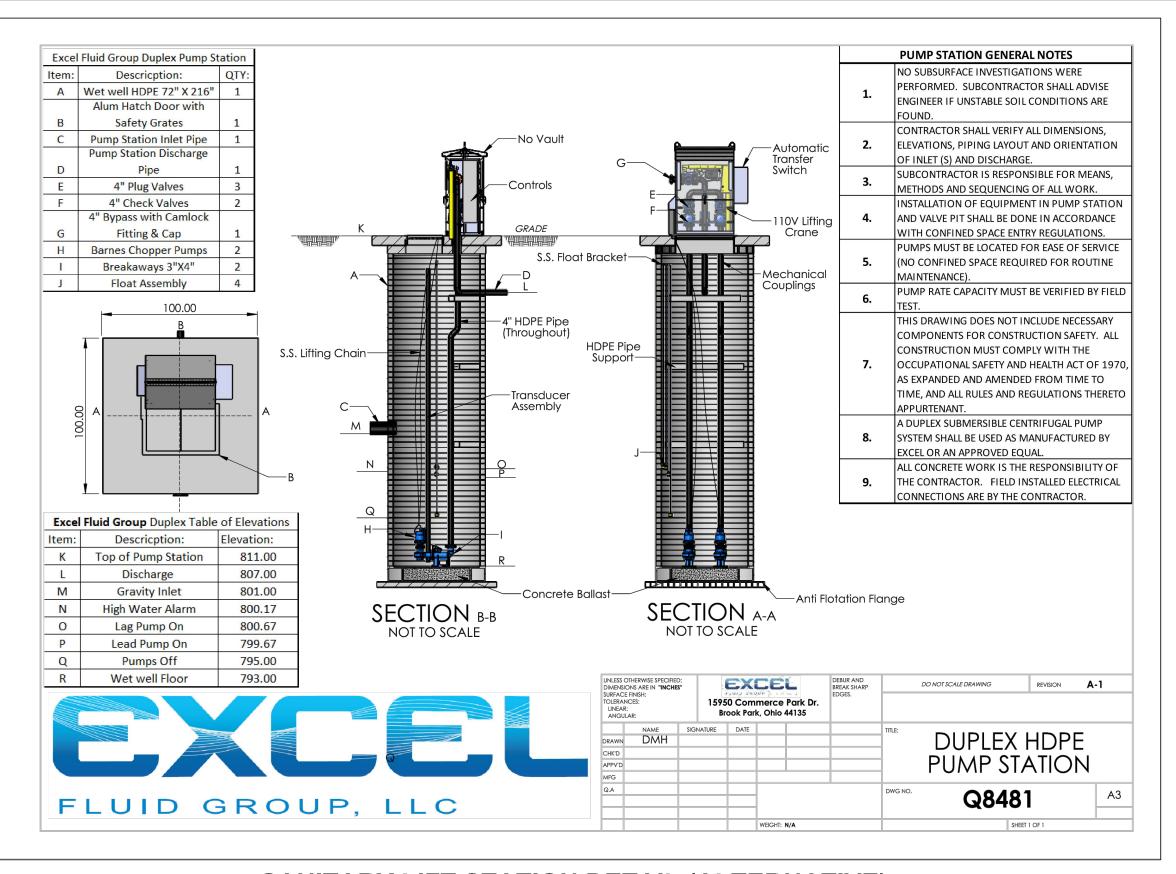

SANITARY LIFT STATION DETAIL (ALTERNATIVE)
SCALE: NONE

ROBERT L.

ROBERT L.

PRO McNUTT E-58308

ONAL

8150 STERLING COURT

		RLM	CHECKED BY:	PLAN & SECTIONS		
		RLM	DRAWN BY:	LIFI STATION - 10 SERIES		S
		RLM	DESIGNED BY:		155	
		AS NOTED	SCALE:	GUERNSEY COUNTY, OHIO	PROJECT 2414	ROC
		8/29/25	ISSUE DATE:	BUASE 1 BOLLING HILLS WANTE ABANDONEMENTS		P
REVISI	ON	REVIEW	ISSUED FOR:	VILLAGE OF BYESVILLE		

10D-01

SCOPE OF WORK

1.1 THE WORK SHALL BE CARRIED OUT IN ACCORDANCE WITH THESE GENERAL NOTES, CONSTRUCTION DRAWINGS AND CONTRACT DOCUMENTS. THE CONTRACTOR SHALL PROVIDE ALL MATERIALS, EQUIPMENT, TOOLS, LABOR, SUPERVISION AND ANY OTHER MISCELLANEOUS ITEMS REQUIRED TO INSTALL THE EQUIPMENT AND/OR DEVICES AS SPECIFIED HEREIN AND SHOWN ON THE DRAWINGS, UNLESS SPECIFICALLY EXCLUDED. THE EQUIPMENT OR DEVICES SHALL BE INSTALLED IN ACCORDANCE WITH THE NEC, THE MFR'S INSTRUCTIONS AND ACCORDING TO PLANS AND DRAWINGS PROVIDED. WRITTEN APPROVAL FROM THE AUTHORIZED COMPANY REPRESENTATIVE SHALL BE OBTAINED PRIOR TO MAKING ANY DEVIATION FROM THE DRAWINGS OR ANY SUBSTITUTION OF MATERIALS. IF SUCH PRIOR APPROVAL HAS NOT BEEN OBTAINED, IT WILL BE THE RESPONSIBILITY OF THE ELECTRICAL CONTRACTOR TO CHANGE, WITHOUT ADDITIONAL COMPENSATION, ANY ITEMS SUBSEQUENTLY DISCOVERED TO BE UNACCEPTABLE.

1.2 THE CONTRACTOR SHALL PROVIDE THE INSTALLATION, INTERCONNECTION AND TESTING OF COMPLETE AND OPERABLE SYSTEMS.

1.3 INCLUDED IN THIS WORK IS THE FURNISHING, BY THE CONTRACTOR, OF OFFICE MATERIAL, EQUIPMENT STORAGE AND SHOP FACILITIES FOR THE CONSTRUCTION WORK DURING THE ENTIRE CONSTRUCTION PERIOD. CAPACITY, ARRANGEMENTS AND LOCATION OF THESE FACILITIES ARE SUBJECT TO APPROVAL BY THE CONSTRUCTION MANAGER AND SHALL COMPLY WITH APPLICABLE CODES AND REGULATIONS.

1.4 TO ENABLE ORDERLY REVIEW DURING PROGRESS OF THE WORK, AND TO PROVIDE FOR SYSTEMATIC DISCUSSION OF PROBLEMS, THE CONSTRUCTION MANAGER WILL CONDUCT PROJECT MEETINGS THROUGHOUT THE CONSTRUCTION PERIOD. THE CONTRACTOR WILL BE EXPECTED TO ATTEND THESE MEETINGS.

1.5 THE CONTRACTOR SHALL BE RESPONSIBLE FOR ALL WORK ON THE PROJECT REQUIRED TO BE PERFORMED BY ELECTRICIANS, INCLUDING THAT DUE TO JURISDICTION AND/OR LOCAL PRACTICES.

1.6 THE CONTRACTOR SHALL EMPLOY QUALIFIED ELECTRICAL WORKERS, AND LABORERS TO PERFORM THE WORK TO BE DONE.

1.7 THE CONTRACTOR SHALL PROVIDE ALL TOOLS, CONSTRUCTION EQUIPMENT, TEST EQUIPMENT, AND TESTING FACILITIES AND SHALL MAKE TESTS AND KEEP RECORDS AS SPECIFIED HEREIN.

1.8 THE CONTRACTOR SHALL COORDINATE THEIR WORK WITH ALL OTHER TRADES, PERMANENT FACILITY PERSONNEL, AND THE CONSTRUCTION MANAGER. COORDINATION SHALL ALLOW WORK TO BE INSTALLED IN THE MOST DIRECT MANNER AND SO INTERFERENCE BETWEEN CONDUITS, PIPING, DUCTS, EQUIPMENT, AND STRUCTURAL FEATURES WILL BE AVOIDED.

1.9 CABLE TRAY AND RACEWAY ROUTING.

1.9.a EQUIPMENT, INSTRUMENTS, DEVICES, PANELS AND JUNCTION BOXES LOCATIONS ARE SHOWN ON THE ELECTRICAL LAYOUT DRAWINGS.

1.9.b ONLY THE GENERAL CABLE OR RACEWAY TRAY ROUTING PLANS ARE SHOWN ON THE ELECTRICAL LAYOUT DRAWINGS. THE ROUTING FROM INDIVIDUAL ITEMS IS NOT DEPICTED ON THE DRAWINGS.

1.9.c THE DIFFERENT WIRING CLASSES AND WIRE ASSIGNED TO THEM (MEDIUM VOLTAGE POWER, LOW VOLTAGE POWER, CONTROL, INSTRUMENTATION) ARE ALL INDICATED ON THE DRAWING OR IN THE CABLE, CONDUIT AND WIRE SCHEDULE.

1.9.d IT IS THE CONTRACTOR'S RESPONSIBILITY TO DETERMINE THE BEST CABLE TRAY OR RACEWAY ROUTING FOR ALL WIRES NOT SPECIFICALLY ROUTED, WHILE MAINTAINING THE WIRE CLASS SEGREGATION REQUIREMENTS OF THE NEC.

1.9.e THE CONTRACTOR SHALL PRESENT THE ROUTING PLAN TO THE CONSTRUCTION MANAGER FOR APPROVAL BEFORE PROCEEDING.

1.10 RUNS FROM OUTLETS REFERRED TO AS "HOME RUNS" MAY BE USED ON CONTRACTOR'S CONSTRUCTION DRAWINGS. THEY ARE INDICATED BY POINTING IN THE GENERAL DIRECTION OF PANELS. CONTRACTOR SHALL BE RESPONSIBLE TO CONTINUE SUCH CIRCUITS TO THE PANELS AS THOUGH THE ROUTES WERE COMPLETELY INDICATED. HOME RUNS SHALL BE INSTALLED FROM OUTLETS AS SHOWN ON CONTRACTOR'S DRAWINGS.

1.11 THE CONTRACTOR SHALL BECOME FAMILIAR WITH ALL DETAILS OF THE WORK AND VERIFY ALL DIMENSIONS IN THE FIELD SO THAT THE OUTLETS AND EQUIPMENT WILL BE PROPERLY LOCATED AND READILY ACCESSIBLE. LIGHTING FIXTURES, OUTLETS, AND OTHER EQUIPMENT AND MATERIALS SHALL BE LOCATED TO AVOID INTERFERENCE WITH CABINETS, MECHANICAL OR STRUCTURAL FEATURES. DEVIATIONS FROM DRAWINGS REQUIRED TO MAKE WORK OF THIS CONTRACT CONFORM TO BUILDING AS CONSTRUCTED, OR AS TO WORK OF OTHER CONTRACTORS, SHALL BE MADE BY THE CONTRACTOR AT HIS EXPENSE. THE ENGINEER RESERVES THE RIGHT TO MAKE MINOR CHANGES IN THE LOCATION OF EQUIPMENT AND OUTLETS PRIOR TO INSTALLATION WITHOUT ADDITIONAL CHARGES.

2. CONTRACT DOCUMENTS

2.1 THE CONTRACT DOCUMENTS SHALL CONSIST OF DRAWINGS, SPECIFICATIONS, AND OTHER DOCUMENTS ISSUED BY THE ENGINEER. EACH DOCUMENT IS COMPLEMENTARY, AND THE REQUIREMENTS SHOWN, WRITTEN OR REASONABLY INFERABLE THERE FROM ONE DOCUMENT IS CONSIDERED AS WRITTEN, SHOWN OR IMPLIED IN ALL.

2.2 THE CONTRACTOR SHALL FAMILIARIZE THEMSELVES WITH ALL OF THE PLANS INCLUDING ARCHITECTURAL, LAYOUT, PIPING AND MECHANICAL PLANS. HE SHALL PERFORM ALL WORK AND PROVIDE ALL MATERIAL REQUIRED BY THE ELECTRICAL CONTRACTOR SHOWN UNDER THESE AND ALL OTHER SECTIONS OF THE PLANS AND SPECIFICATIONS.

2.3 THE CONTRACTOR SHALL MAINTAIN AN UP TO DATE SET OF AS-BUILT DRAWINGS NEATLY MARKED WITH ALL CHANGES (RED LINED) FROM THE ORIGINAL DESIGN. THESE DRAWINGS SHALL BE DELIVERED TO THE CONSTRUCTION MANAGER AT THE COMPLETION OF THE PROJECT PRIOR TO RECEIVING FINAL PAYMENT.

3. CODES AND STANDARDS

3.1 THE ELECTRICAL EQUIPMENT, MATERIALS AND INSTALLATION PROVIDED FOR THIS PROJECT SHALL CONFORM IN DESIGN, FABRICATION, TESTING AND PERFORMANCE, TO THE LATEST EDITION OF STANDARDS AND GUIDELINES PUBLISHED BY THE FOLLOWING ORGANIZATIONS WHERE APPLICABLE. THE LATEST EDITION OF THE STANDARDS, DOCUMENTS, AND PUBLICATIONS, REFERENCED HEREIN BY BASIC DESIGNATION SHALL BECOME PART OF THESE SPECIFICATIONS TO THE EXTENT REFERENCED.

ANSI AMERICAN NATIONAL STANDARDS INSTITUTE

FM FACTORY MUTUAL FM STANDARDS

IEEE INSTITUTE OF ELECTRICAL AND ELECTRONICS ENGINEERS

NEC NATIONAL ELECTRICAL CODE

NFPA NATIONAL FIRE PROTECTION ASSOCIATION STANDARDS

NFPA 70 NATIONAL ELECTRIC CODE

NFPA 70E STANDARD FOR ELECTRICAL SAFETY IN THE WORKPLACE

NFPA 72 NATIONAL FIRE ALARM CODE

NEMA NATIONAL ELECTRICAL MFR'S ASSOCIATION

UL UNDERWRITERS' LABORATORIES, INC.

ICEA INSULATED CABLE ENGINEERS ASSOCIATION

IPCEA INSULATED POWER CABLE ENGINEERS ASSOCIATION STANDARDS

INSTRUMENT SOCIETY OF AMERICA STANDARDS

3.2 ALL LOCAL, STATE AND FEDERAL CODES, STANDARDS AND REGULATIONS IN EFFECT HAVING JURISDICTION IN THE AREA WHERE THE EQUIPMENT WILL BE INSTALLED. ANY CONFLICT BETWEEN THE ABOVE MENTIONED DOCUMENTS AND THIS SPECIFICATION SHALL BE REFERRED TO THE ENGINEER FOR CLARIFICATION BEFORE PROCEEDING WITH THE FABRICATION OF THE AFFECTED PARTS.

4. CODES AND PERMITS

4.1 THE INSTALLATION AND MATERIALS SHALL COMPLY WITH ALL LAWS APPLYING TO ELECTRICAL INSTALLATION IN EFFECT, WITH THE REGULATIONS OF THE NEC WHERE SUCH REGULATIONS DO NOT CONFLICT WITH LAWS IN EFFECT, AND WITH THE REGULATIONS OF THE PUBLIC UTILITY COMPANY FURNISHING THE SERVICE.

GUARANTEE

5.1 THE CONTRACTOR SHALL GUARANTEE ALL MATERIALS, WORKMANSHIP AND THE SUCCESSFUL OPERATION OF ALL EQUIPMENT AND APPARATUS UNDER THIS CONTRACT FOR A PERIOD OF (18) EIGHTEEN MONTHS FROM THE DATE OF FINAL ACCEPTANCE OF THE WHOLE WORK. CONTRACTOR SHALL GUARANTEE TO REPAIR OR REPLACE AT HIS OWN EXPENSE ANY PART OF THE APPARATUS WHICH MAY SHOW DEFECT DURING THAT TIME PROVIDED SUCH DEFECT IS DUE TO IMPROPER MATERIALS OR WORKMANSHIP AND NOT TO CARELESSNESS OR IMPROPER USE BY THE OWNER. BY DEFAULT, OWNER MAY HAVE SUCH WORK DONE AND CHARGED TO THE CONTRACTOR.

6. CONSTRUCTION, SHOP DRAWINGS AND MATERIALS

6.1 CONTRACTOR SHALL SUBMIT AN ELECTRONIC SET OF SHOP DRAWINGS TO THE ENGINEER FOR APPROVAL PRIOR TO COMMENCING ELECTRICAL CONSTRUCTION AND/OR PURCHASE OF EQUIPMENT INCLUDED THEREIN.

6.1.a THE FOLLOWING IS THE MINIMUM EXPECTATION OF SHOP DRAWINGS THAT WILL BE REQUIRED FOR THE PROJECT:

- A. TRANSFORMERS
- B. SWITCHGEAR, SWITCHBOARDS, PANELBOARDS, MOTOR CONTROLLERS
- C. DISCONNECT SWITCHES AND ASSOCIATED FUSES

WIRE, CABLE INCLUDING GROUND SYSTEM

- D. RACEWAYS: CONDUIT, CABLE TRAY AND WIREWAY
- F. LIGHTING FIXTURES
- G. CONTROL PANELS
- H. ALL PREFABRICATED CONCRETE: MANHOLES, VAULTS, POLE BASES

6.2 RECEIPT OR APPROVAL OF SHOP DRAWINGS BY THE ENGINEER DOES NOT RELIEVE THE CONTRACTOR OF THE RESPONSIBILITY OF COMPLYING WITH CONTRACT DOCUMENTS.

6.3 ALL MATERIAL SHALL BE UL LISTED UNLESS OTHERWISE REQUIRED.

6.4 CONTRACTOR SHALL MAKE PROVISIONS FOR TIMELY AND SAFE DELIVERY AND SAFE STORAGE OF MATERIALS.

6.5 MFRS' NAMES ARE LISTED TO ESTABLISH FUNCTION AND QUALITY OF MATERIAL OR EQUIPMENT. MATERIALS SO LISTED SHALL BE BID AS SPECIFIED UNLESS WRITTEN APPROVAL IS OBTAINED TO SUBSTITUTE MATERIALS OF EQUAL QUALITY BY OTHER MFRS. LETTERS REQUESTING APPROVAL AND INCLUDING COMPLETE ENGINEERING INFORMATION DESCRIBING PERFORMANCE AND SHOWING DIMENSIONS SHALL BE SUBMITTED TO THE ENGINEER AT LEAST 5 WORKING DAYS PRIOR TO BID OPENING.

7. FIELD DEVICES & WIRING:

7.1 ALL MOTORS AND INSTRUMENTS SHALL BE HAVE AN EQUIPMENT IDENTIFYING TAG AS INDICTED HEREIN, ON PLANS OR IN SPECIFICATIONS SECTION 26.

7.2 TERMINAL BLOCKS SHALL BE LABELED AS INDICTED HEREIN, ON PLANS OR IN SPECIFICATIONS SECTION 26.

7.3 POWER CABLES ARE TO BE COLOR CODED BY PHASE AS INDICATED HEREIN.

8. EXCAVATION AND BACKFILLING:

8.1 THE CONTRACTOR SHALL PERFORM ALL EXCAVATION, TRENCHING AND BACKFILLING WORK, AND REMOVE ALL DEBRIS IN CONNECTION WITH HIS WORK. BACKFILLING SHALL BE DONE WITH MATERIALS ACCEPTABLE TO THE CONSTRUCTION MANAGER AND THOROUGHLY COMPACTED. ALL DISTURBED SURFACES SHALL BE RESTORED TO THEIR ORIGINAL CONDITION AND PROPERLY INSTALLED TO ELIMINATE ANY SETTLEMENT.

9. WORKMANSHIP

9.1 THE CONTRACTOR SHALL BE HELD SOLELY RESPONSIBLE FOR THE PROPER INSTALLATION OF HIS WORK. HE SHALL ARRANGE WITH THE PROPER CONTRACTORS FOR THE BUILDING IN OF ANCHORS, ETC., AND FOR THE LEAVING OF REQUIRED CHASES, OPENINGS, ETC., AND SHALL DO ALL CUTTING AND PATCHING MADE NECESSARY BY HIS FAILURE OR NEGLECT TO MAKE SUCH ARRANGEMENTS WITH OTHERS. ANY CUTTING OR PATCHING DONE BY THIS CONTRACTOR SHALL BE SUBJECT TO THE DIRECTIONS OF THE CONSTRUCTION MANAGER AND SHALL NOT BE STARTED UNTIL APPROVAL HAS BEEN OBTAINED.

9.2 ALL CUTTING, WELDING OR DRILLING OF CONCRETE OR STRUCTURAL MEMBERS SHALL BE PROPERLY REINFORCED AND PATCHED TO MATCH AS NEARLY AS POSSIBLE THE SURROUNDING WORK. BEFORE CUTTING, WELDING OR DRILLING ANY CONCRETE OR STRUCTURAL MEMBER, THE CONTRACTOR SHALL SECURE THE APPROVAL OF THE CONSTRUCTION MANAGER.

9.3 THE CONTRACTOR SHALL ASSIGN PERSONS IN DIRECT CHARGE OF WORK WHO ARE THOROUGHLY EXPERIENCED IN THE CLASS OF CONSTRUCTION WORK SPECIFIED HEREIN. ALL LABOR SHALL BE PERFORMED IN A WORKMANLIKE MANNER BY SKILLED WORKMEN UNDER THE SUPERVISION OF COMPETENT SUPERVISORS.

9.4 THE CONTRACTOR SHALL PERIODICALLY REMOVE ALL DEBRIS AND WASTE IN ORDER TO MAINTAIN SAFE WORKING AND OPERATING CONDITIONS, AND SHALL DISPOSE OF THE SAME IN AN APPROVED MANNER. AT THE COMPLETION OF WORK, HE SHALL REMOVE ALL HIS RUBBISH, TOOLS, SCAFFOLDS AND SURPLUS MATERIALS FROM AND ABOUT THE SITE, LEAVING HIS WORK CLEAN AND THE AREAS READY FOR OCCUPANCY.

10. PERFORMANCE AND QUALITY ASSURANCE TESTING

10.1 UPON COMPLETION, THE COMPANY SHALL REVIEW AND APPROVE THE INSTALLATION TO ENSURE THAT THE WORK WAS DONE IN ACCORDANCE WITH THE DESIGN DRAWINGS AND CODE REQUIREMENTS, WITH ANY REQUIRED CORRECTIVE ACTIONS AT THE CONTRACTOR'S EXPENSE. THE CONTRACTOR SHALL BE RESPONSIBLE FOR ALL CERTIFICATES, PERMITS OR INSPECTIONS BY THE AUTHORITIES HAVING JURISDICTION.

10.2 THE INSTALLATION SHALL BE TESTED FREE FROM ALL GROUNDS AND SHORT CIRCUITS. ALL EQUIPMENT FURNISHED SHALL BE DEMONSTRATED TO OPERATE IN ACCORDANCE WITH THE REQUIREMENTS OF THESE SPECIFICATIONS AND PLANS. CONSULT WITH THE OWNER'S REPRESENTATIVE PRIOR TO TESTING AND ADJUSTING TO DETERMINE INTENDED FUNCTION. PERFORM SUCH TESTS AND MAKE NECESSARY ADJUSTMENTS TO ENSURE THAT DESIGN FUNCTION IS OBTAINED. THESE TESTS SHALL BE PERFORMED IN THE PRESENCE OF THE CONSTRUCTION MANAGER OR HIS AUTHORIZED REPRESENTATIVE. THE CONTRACTOR SHALL NOTIFY ALL THOSE WHO ARE REQUIRED TO BE PRESENT DURING THE TESTS (SUCH AS THE FIRE MARSHAL FOR THE TESTING OF THE FIRE ALARM SYSTEM AND EMERGENCY EXIT LIGHTING SYSTEM). NOTIFICATION OF A TEST SHALL BE MADE TO PERSONS THAT ARE TO ATTEND AS REQUIRED BY THEIR DEPARTMENT AT LEAST 7 DAYS IN ADVANCE.

10.3 NORMAL FEEDERS, CIRCUITS, AND SERVICE ENTRANCE CONDUCTORS WITH WIRE SIZE #2 AND LARGER SHALL BE TESTED FOR LEAKAGE PHASE-TO-GROUND AND PHASE-TO-PHASE PRIOR TO ENERGIZATION OF THE ELECTRICAL SYSTEM. THE CONTRACTOR SHALL SUBMIT A WRITTEN REPORT TO THE CONSTRUCTION MANAGER SHOWING METHODS AND READINGS TAKEN.

11. MATERIALS AND INSTALLATION

11.1 CONDUIT

11.1.a MATERIALS: <u>EXTERIOR</u> - ALL CONDUITS SHALL BE PVC (BELOW GRADE) AND RIGID ALUMINUM ABOVE GRADE (UON ON PLANS). TRANSITION FROM PVC TO ALUMINUM CONDUIT BELOW GRADE WITH PVC COATED RIGID SWEEPS. <u>INTERIOR</u> - ALL CONDUITS SHALL BE ALUMINUM PER PLANS. ANY INTERIOR AREAS SUBJECT TO POTENTIAL IMPACT WITH CONDUIT (IE STORAGE AREAS, FORKLIFT PATHWAYS) SHALL BE PROTECTED.

11.1.b CONDUITS MUST USE EXPANSION JOINTS AS PER NEC.

11.1.c BEFORE INSTALLATION, THE INTERIOR AND EXTERIOR OF ALL CONDUIT AND FITTINGS SHALL BE INSPECTED AND CLEANED OF ALL DIRT, CUTTINGS AND OTHER FOREIGN MATERIALS.

11.1.d WHEN CONDUIT IS INSTALLED WHERE NO LOCATION DIMENSIONS ARE GIVEN ON THE DRAWINGS, APPROVAL OF THE LOCATIONS OF THESE

CONDUITS SHALL BE OBTAINED FROM THE COMPANY REPRESENTATIVE PRIOR TO INSTALLATION.

11.1.e CONDUITS SHALL NOT BE FASTENED TO REMOVABLE MEMBERS SUCH AS PIPING. CONDUIT HANGERS SHALL BE SUPPORTED FROM

BUILDINGS AND STRUCTURES, NOT FROM EQUIPMENT.

11.1.f CONNECTIONS TO INTERIOR BOXES, PANELS, EQUIPMENT AND RELATED ITEMS SHALL BE MADE WITH DOUBLE LOCKNUTS, ONE INSIDE AND ONE OUTSIDE, WITH AN INSULATING BUSHING ON EACH END OF THE CONDUIT IN ADDITION TO LOCKNUTS. OUTDOOR CONNECTIONS SHALL BE MADE WITH "MYERS" HUBS OR APPROVED EQUAL.

11.1.g ALL CONDUITS SHALL HAVE THEIR ENDS PLUGGED BY CAPS, COUPLINGS W/ PLUGS OR OTHER APPROVED MEANS DURING CONSTRUCTION WORK

11.1.h ALL CONDUIT SUPPORTS SHALL BE ALUMINUM. THE USE OF PERFORATED STRAP OR PLUMBERS STRAP IS NOT PERMITTED.

11.1.i IN CROSSING OF PIPING, THE CONDUIT SHOULD CLEAR THE PIPE BY A MINIMUM OF 6 INCHES.

11.1.j EXPOSED CONDUITS IN BUILDINGS, UNLESS OTHERWISE SPECIFIED OR SHOWN ON THE DRAWINGS, SHALL BE SUBJECT TO THE FOLLOWING REQUIREMENTS:

- A. ALL CONDUITS SHOULD RUN PARALLEL OR PERPENDICULAR TO WALLS, CEILINGS, BEAMS AND COLUMNS.
- B. ALL CONDUIT RUNS SHALL CLEAR ALL CRANE SYSTEMS, DOORS, WINDOWS, ACCESS WALLS AND OPENINGS.
- C. PARALLEL RUNS SHOULD BE GROUPED IN NEATLY ALIGNED BANKS WHERE POSSIBLE WITH MINIMUM 1" CLEARANCE BETWEEN CONDUITS.
- D. CONDUITS TERMINATING AT CABLE TRAYS SHALL ATTACH TO TRAY AND SHALL BE ELECTRICALLY BONDED TO EDGE OF TRAY OR TO THE GND WIRE IN CABLE TRAY.

11.1.k CONDUITS SHALL BE INSTALLED, WHEREVER POSSIBLE, IN SUCH MANNER AS TO AVOID THE COLLECTION OF CONDENSED MOISTURE IN THE CONDUIT. DRAINS SHALL BE INSTALLED AT LOW POINTS IN EXPOSED CONDUIT RUNS.

11.1.I PULL POINTS SHALL BE PROVIDED IN EACH CONDUIT RUN TO CONFORM WITH THE REQUIREMENTS OF THE NEC OR CABLE MFR'S RECOMMENDATION.

11.1.m CONDUIT RUNS SHALL BE IDENTIFIED AT TERMINATIONS AND PULL POINTS WITH STAMPED ALUMINUM BANDS.

11.1.n EACH CONDUIT SHALL BE CLEANED OF ALL OBSTRUCTION BY PULLING A MANDREL THROUGH THE ENTIRE LENGTH OF RUN PRIOR TO PULLING WIRE OR CABLE IN CONDUIT.

11.1.0 CONDUIT SEALING AND DRAINING SHALL BE INSTALLED IN ACCORDANCE WITH THE NEC. SEALING METHODS SHALL BE IN ACCORDANCE WITH THE RECOMMENDATIONS OF THE SEAL MFR.

11.1.p CONDUIT UNIONS SHALL BE INSTALLED IN ALL CONDUITS CONNECTED TO TAPPED EQUIPMENT SO THAT THE EQUIPMENT CAN BE REMOVED WITHOUT DISTURBING THE CONDUIT (OR SEAL).

11.1.q ALL BOLTS, NUTS & WASHERS SHALL BE CADMIUM PLATED.

11.1.r ALL CONDUITS ROUTED TO EXTERIOR CABLE TRAYS SHALL ENTER THROUGH THE BOTTOM OF THE CABLE TRAY UON.

11.2 CONDUIT BENDS

11.2.a ALL BENDS SHALL HAVE RADIUS NOT LESS THAN SHOWN IN THE NEC OR SHALL BE MADE UP OF SCREW-JOINTED CONDUIT FITTINGS. NOT MORE THAN THE EQUIVALENT OF FOUR (4) 90° BENDS SHALL BE USED IN ANY RUN BETWEEN TERMINALS AND CABINETS, OR BETWEEN OUTLETS AND JUNCTION OR PULL BOXES.

11.2.6 A GROUP OF EXPOSED CONDUITS THAT CHANGE DIRECTION UTILIZING BENDS SHALL HAVE THE MINIMUM BENDING RADIUS OF THE LARGEST CONDUIT IN THE GROUP FOR VERTICAL CHANGES AND SHALL HAVE THE SAME BEND RADIUS POINT FOR A HORIZONTAL CHANGE.

11.2.c BENDS SHALL BE FREE FROM CRACKS, CRIMPS OR OTHER DAMAGE TO THE CONDUIT OR ITS COATING. THE CONDUIT AFTER BENDING SHALL BE TRUE AND ROUND WITH FULL INSIDE AREAS FOR THE LENGTH OF THE BEND. CONDUIT BENDS SHALL COMPLY WITH NEC.

11.3 CONDUIT JOINTS

11.3.a ALL JOINTS IN ALUMINUM SHALL BE THREADED OR ALUMINUM PUSH FITTINGS. ALL CUT THREADS AND ANY WRENCH MARKS SHALL BE COATED WITH COLD SEALING COMPOUND. ALL THREADED JOINTS SHALL BE MADE UP TIGHT WITH A MINIMUM OF FIVE (5) FULL THREADS.

11.4 CABLE TRA

11.4.a MATERIALS: TRAYS SHALL BE THE BRAND/MODEL INDICATED ON PLANS OR AS DESCRIBED IF NO SPECIFIC BRAND/MODEL IS GIVEN. SUBSTITUTIONS MUST BE APPROVED BY ENGINEER.

11.4.b CABLE TRAY AND TRAY SUPPORT MATERIALS, WHEN ASSEMBLED AND MOUNTED SHALL SUPPORT THE FULL CABLE LOAD WITH A MAXIMUM OF 2" DEFLECTION WITHOUT PERMANENT DEFORMATION.

11.4.c TRAY FITTINGS, SUCH AS BRANCHES, REDUCERS, FLAT ELBOWS, TEES AND CROSSES, SHALL BE USED FOR CHANGES IN DIRECTION. THE DIMENSIONS OF TRAY FITTINGS SHALL PROVIDE AMPLE BENDING RADIUS FOR THE CABLES CONTAINED IN THE TRAY. THE TERMINATION SHALL BE PROVIDED WITH A PROTECTOR GUARD TO PREVENT DAMAGE TO THE CABLES. AS REQUIRED, PROVIDE ADDITIONAL SUPPORTS FOR INDIVIDUAL CABLES WHERE THE CABLE LEAVES THE CABLE TRAY FOR FINAL TERMINATION.

11.4.d TRAYS SHALL BE CAREFULLY ALIGNED, LEVELED AND PLUMBED. TRAY SECTIONS AND FITTINGS SHALL BE ASSEMBLED ON THEIR SUPPORTS AND JOINTED TOGETHER, USING MFR'S STANDARD CONNECTOR UNITS.

11.4.e POWDER COATED STEEL ANGLES, TRAPEZE HANGERS, CHANNELS, BOLTING, AND MISCELLANEOUS MATERIALS REQUIRED FOR THE SUPPORT OF TRAYS FROM THE BUILDING STRUCTURE, SHALL BE ALUMINUM AND SUPPLIED AND INSTALLED BY THE CONTRACTOR.

11.4.f ALL EXTERIOR CABLE TRAYS TO BE SUPPLIED WITH COVERS, INSTALLED BY THE CONTRACTOR AFTER ALL CABLES ARE INSTALLED.

11.5 JUNCTION AND PULL BOXES

AND HAVE A DRAIN FITTING INSTALLED IN THE BOTTOM OF THE BOX.

11.5.a MATERIALS: BOXES SHALL BE THE BRAND/MODEL INDICATED ON PLANS OR AS DESCRIBED IF NO SPECIFIC BRAND/MODEL IS GIVEN. ALL BOXES SHALL BE UL/FM RATED FOR LOCATION. SUBSTITUTIONS MUST BE APPROVED BY ENGINEER.

11.5.b BOXES FOR INDOOR INSTALLATION SHALL CONFORM TO THE FOLLOWING:

A. BE HEAVY DUTY POWDER COATED METAL OR ALUMINUM, WITH ALUMINUM COVERS AND BRONZE OR CADMIUM PLATED SCREWS OR BOLTS UNLESS OTHERWISE PERMITTED OR SPECIFIED.

BLOCKS.

C. HAVE PIANO HINGED COVER AND INTERIOR MOUNTING PANEL WHERE USED FOR ENCLOSING TERMINAL BLOCKS AND CONTROL RELAYS.

B. BE NEMA 12 IN NON-HAZARDOUS AREAS OR AS SHOWN ON DRAWINGS AND HAVE GASKETED COVERS ON BOXES CONTAINING TERMINAL

11.5.c BOXES FOR OUTDOOR INSTALLATION SHALL CONFORM TO THE FOLLOWING:A. BE HEAVY DUTY STAINLESS STEEL WITH STAINLESS STEEL COVERS. SCREWS OR BOLTS UNLESS OTHERWISE NOTED.

B. HAVE THREADED CONDUIT ENTRANCES SUCH AS "MYERS" HUBS, OR APPROVED EQUAL ANDHAVE RUBBER OR NEOPRENE COVER GASKETS.

C. BE NEMA 4 WATERTIGHT IN OUTDOOR NON-HAZARDOUS AREAS AND HAVE A DRIP LIP ANDOTHER FEATURES REQUIRED FOR RAIN TIGHT CONSTRUCTION; UNLESS OTHERWISE NOTED.
 D. HAVE PIANO HINGED COVER AND INTERIOR MOUNTING PANELS WHEN USED FOR ENCLOSING TERMINAL BLOCKS, CONTROL RELAYS, ETC

11.5.d IDENTIFICATION: NAMEPLATES, WITH TITLE AND TAG NO., FABRICATED FROM PLASTIC WITH BLACK LETTERS ON WHITE BACKGROUND SHALL BE PERMANENTLY AFFIXED TO ALL JUNCTION BOXES.



lantas GCOURT

 ISSUED FOR:
 REVIEW
 NO
 REVISION
 DATE

 ISSUE DATE:
 8/29/25
 A
 A
 A

 SCALE:
 N/A
 A
 A
 A

 DESIGNED BY:
 RLM
 A
 A
 A

 CHECKED BY:
 RLM
 A
 A
 A
 A

OF BYESVILLE
SEWER IMPROVEMENTS
LS WWTP ABANDONEMENT
Y COUNTY, OHIO
ON - 10 SERIES
DEAWNE

S.R. 82 PHASE I - F

241455
DISCIPLINE
ELECTRICAL

10E-01

SHEET O

11.6 WIRE AND CABLE

11.6.a MATERIALS: ALL WIRE / CABLE SHALL BE COPPER (UON) AND ACCORDING TO THE CABLE SCHEDULES AND/OR CONSTRUCTION DRAWINGS. ANY DEVIATION MUST BE APPROVED BY ENGINEER & OWNER'S REPRESENTATIVE.

11.6.b ALL WIRE AND CABLE WILL BE EITHER INSTALLED IN RACEWAY OR CABLE TRAY PROVIDED.

11.6.c CABLE ON REELS AND WIRE IN COILS SHALL BE PROTECTED DURING SHIPMENT, STORAGE AND HANDLING. THE ENDS OF CABLES SHALL BE TAPED WHILE ON REELS AND AFTER INSTALLATION. TAPE WILL BE REMOVED ONLY WHEN READY TO TERMINATE WIRE.

11.6.d CONDUCTORS SHALL BE CONTINUOUS FROM TERMINATION TO TERMINATION. CABLES SHALL NOT BE SPLICED TO MAKE USE OF SHORT LENGTHS AND SHALL NOT BE CUT FOR CONVENIENCE OF PULLING. MFR'S INSTRUCTIONS OR RECOMMENDATIONS FOR INSTALLATION, WIRING ACCESSORIES OR OTHER WIRING MATERIALS SHALL BE FOLLOWED.

11.6.e WHERE MULTI-CONDUCTOR CABLES ENTER CONTROL PANELS AND CABINETS, THE OUTER JACKET SHALL NOT BE STRIPPED BEYOND THE POINT WHERE THE FIRST CONDUCTOR LEAVES THE CABLE TO CONNECT TO THE TERMINAL STRIP. IF JACKET IS STRIPPED IN EXCESS OF THE ABOVE FROM ANY CABLE, THE CABLE SHALL BE REPLACED AT THE

11.6.f THE PULLING OF WIRING INTO CONDUIT OR OTHER RACEWAYS SHALL BE DONE WITH ALL POSSIBLE CARE. THE CABLE REELS OR COILS SHALL BE SET UP IN SUCH A WAY THAT THE CONDUCTOR MAY BE TRAINED INTO THE RACEWAY AS DIRECTLY AS POSSIBLE WITH A MINIMUM NUMBER OF CHANGES OF DIRECTION AND BENDING. WHERE SEVERAL CABLES ARE CONTAINED IN ONE CONDUIT, ALL SUCH CABLES SHALL BE PULLED IN TOGETHER. PULLING COMPOUND OR POWDERED SOAPSTONE SHALL BE COMPATIBLE WITH THE CABLE INSULATION AND APPROVED FOR USE BY THE CABLE MFR. CABLE PULLING TENSIONS SHALL NOT EXCEED VALUES SPECIFIED BY THE CABLE MFR.

11.6.g ALL CONDUCTORS SHALL BE TERMINATED IN STRICT ACCORDANCE WITH THE MFRS' RECOMMENDED METHODS. PARTICULAR CARE AND COMPLIANCE WITH MFRS' INSTRUCTIONS SHALL BE UTILIZED IN CONNECTION WITH TERMINATING HIGH VOLTAGE CABLES. ALL CONDUCTORS SHALL BE CLEAN WHEN CONNECTIONS ARE MADE. WIRES, BUS BARS, AND POINTS OF CONTACT SHALL BE CLEANED WITH STEEL WOOL OR SAND PAPER TO REMOVE OXIDES AND

11.6.h ALL CONNECTIONS SHALL BE MADE WITH PRESSURE TYPE CONNECTORS INSTALLED WITH THE TOOL RECOMMENDED BY THE MFR. ALL CONNECTORS SHALL BE RING TYPE. THE RING SHALL NOT BE CUT TO FACILITATE INSTALLATION. TAPED CONNECTIONS SHALL HAVE LAYERS OF INSULATING TAPE BUILT UP TO A THICKNESS NOT LESS THAN THE THICKNESS OF THE INSULATION ON THE CABLES BEING CONNECTED.

11.6.i LUGS SHALL BE USED FOR THE CONNECTION OF CABLES TO EQUIPMENT AND BUSES. PRESSED LUGS SHALL BE USED ON WIRES SIZED #8 AWG AND SMALLER, CAST LUGS SHALL BE USED ON WIRES LARGER THAN #8 AWG.

11.6. POWER CABLE FOR ALL CIRCUITS 400 VOLTS AND ABOVE SHALL BE IDENTIFIED AT TERMINATIONS AND BOXES WITH HEAVY GAUGE STAMPED ALUMINUM BANDS. HEAT SHRINK WIRE MARKERS SHALL BE INSTALLED ON MOTOR, CONTROL AND INSTRUMENT LEADS AND THERMOCOUPLES AT ALL TERMINAL POINTS. IDENTIFICATION SHALL BE IN ACCORDANCE WITH THE DRAWINGS. COLORED WIRE MARKERS SHALL BE INSTALLED ON ALL FEEDERS AND INSULATED GROUNDLEADS AT ALL TERMINAL POINTS WHERE COLOR CODED WIRE IS NOT USED. COLOR CODE AS FOLLOWS:

	208/120VAC	480/277VAC	415/240VAC
PHASE A	BLACK	BROWN	BROWN
PHASE B	RED	ORANGE	ORANGE
PHASE C	BLUE	YELLOW	YELLOW
NEUTRAL	WHITE	GREY	GREY

11.6.k CONTROL WIRING COLOR CODES SHALL BE IN ACCORDANCE WITH SPECIFIC WIRING DRAWINGS

11.6.I CONTROL WIRING IDENTIFICATION SHALL BE IN ACCORDANCE WITH SPECIFIC WIRING DIAGRAMS AND

11.6.m AFTER INSTALLATION OF WIRING AND ASSOCIATED DEVICES HAS BEEN COMPLETED, ELECTRICAL CONDUCTORS SHALL BE TESTED TO ENSURE CONTINUITY, PROPER SPLICING AND FREEDOM FROM GROUND (EXCEPT "MADE GROUND" AND THOSE REQUIRED FOR PROTECTION). ALL 480VAC CIRCUITS AND ABOVE SHALL HAVE INSULATION RESISTANCE TEST COMPLETED IN ACCORDANCE WITH MANUFACTURER'S REQUIREMENTS AND UL REQUIREMENTS UTILIZING A MEGGER. DO NOT HI-POT THE CABLES AS THIS SHALL BE CONSIDERED DESTRUCTIVE.

11.7.a MATERIALS: EQUIPMENT/DEVICES SHALL BE THE BRAND/MODEL INDICATED ON PLANS OR AS DESCRIBED IF NO SPECIFIC BRAND/MODEL IS GIVEN. ALL EQUIPMENT/DEVICES SHALL BE UL/FM RATED FOR LOCATION. SUBSTITUTIONS MUST BE APPROVED BY ENGINEER.

11.7.b ALL EQUIPMENT SHALL BE COMPLETELY ASSEMBLED, INSTALLED AND CONNECTED AS SHOWN ON THE COMPANY OR MFR'S DRAWINGS AND SHALL BE FULLY PREPARED AND MADE READY FOR OPERATION AS NECESSARY BY THE CONTRACTOR. THE CONTRACTOR MAY HAVE THE USE OF ANY SPECIAL TOOLS FURNISHED WITH THE EQUIPMENT SPECIFICALLY FOR INSTALLATION PURPOSES. THE CONTRACTOR SHALL BECOME KNOWLEDGEABLE WITH AND FOLLOW SPECIAL INSTRUCTIONS OF THE MFR FOR THE HANDLING AND INSTALLATION OF THE EQUIPMENT.

11.7.c WHERE EQUIPMENT IS MOUNTED ON WALLS AND/OR COLUMNS CONTRACTOR SHALL PROVIDE STRUCTURAL STEEL SUPPORTS AND SUITABLE ANCHORS.

11.7.d AFTER INSTALLATION, ALL EQUIPMENT SHALL BE LEFT IN A CLEAN CONDITION. ALL INSULATORS, BUSHINGS, INSULATING MATERIALS AND OTHER PARTS WHICH ARE DEPENDED UPON FOR THEIR INSULATING QUALITIES SHALL BE THOROUGHLY CLEANED. NO OVERALL PAINTING OF EQUIPMENT WILL BE REQUIRED, BUT HOUSING SURFACES WHICH HAVE BEEN SOILED OR MARRED SHALL BE TOUCHED UP OR REFINISHED WITH PRIMER AND TOP COAT PAINT TO MATCH THE EQUIPMENT. DURING INSTALLATION, THE CONTRACTOR SHALL TAKE ALL POSSIBLE CARE TO KEEP THE DOORS OF SWITCHGEAR ASSEMBLIES, MOTOR CONTROL CENTERS AND PANELBOARDS CLOSED IN ORDER TO PREVENT THE ENTRANCE OF DUST AND OTHER FOREIGN MATTER.

11.7.e CONTRACTOR SHALL PROPERLY GROUND ALL EQUIPMENT, RACEWAYS, AND ANY SERVICE CONDUCTOR THAT IS TO BE GROUNDED IN ACCORDANCE WITH THE NEC AND ELECTRIC UTILITY COMPANY REQUIREMENTS

11.7.f ANY POWERHOUSE, MOTOR CONTROL CENTER OR SWITCHGEAR SHALL BE SET AND SECURED ON ITS SUPPORTS. THE NECESSARY CONNECTIONS BETWEEN SECTIONS TO FORM A COMPLETELY ASSEMBLED AND INTERCONNECTED GROUP SHALL BE MADE INCLUDING INSTALLATION OF REMOVABLE CIRCUIT BREAKERS, POTENTIAL TRANSFORMERS, AND COMPLETING ALL EXTERNAL CONNECTIONS, THE RAILS ADJUSTED TO ENSURE SMOOTH BREAKER TRAVEL AND CONTACTS ON THE HOUSING SHALL BE INSPECTED AND TIGHTENED IF FOUND LOOSE.

11.7.g ARC FLASH HAZARD WARNINGS SHALL BE ATTACHED TO ALL APPLICABLE EQUIPMENT PER NEC 2014, SECTION

11.7.h ALL ELECTRICAL MATERIALS, DEVICES, APPLIANCES, AND EQUIPMENT SHALL BE LABELED AND LISTED BY CERTIFIED TESTING LABORATORY OR AGENCY.

11.8.i ALL INTERIOR DISTRIBUTION EQUIPMENT WITH TERMINATIONS (IE PANELBOARDS, SWITCHBOARDS, DISCONNECT/STARTERS, CONTROL PANELS, TRANSFORMERS, VFDs, MCCs) SHALL BE NEMA TYPE 12 WITH RATING OF

11.8 CONDUIT CONCRETE DUCT BANKS

11.7 ELECTRICAL EQUIPMENT AND DEVICES

11.8.a MATERIALS: ALL CONDUITS SHALL BE SCHEDULE 80 PVC UNLESS OTHERWISE NOTED. ALL CONCRETE SHALL BE 3000PSi MINIMUM AND DIED RED THROUGHOUT.

11.8.b ALL UNDERGROUND UTILITY CONDUITS SHALL HAVE 3000PSI CONCRETE ENCASEMENT DIED RED THROUGHOUT. 6" MINIMUM CONCRETE COVER AND 24" BELOW FINISHED GRADE WITH EXCEPTIONS AS ALLOWED BY THE NEC. CONDUIT SHALL BE FIRMLY FIXED IN PLACE BY BEING WIRED TO REINFORCING STEEL OR BY OTHER APPROVED MEANS TO AVOID BEING DISTURBED DURING BACKFILLING OR POURING OF CONCRETE. SEE DETAILS ON PLANS.

11.8.c INSTALL #2/0 HMWPE GROUND CABLE IN CONCRETE.

11.8.d CONTRACTOR TO USE SPACERS EVERY 60" MAXIMUM. (CARLON SNAP-N-STAC OR EQUAL)

11.9 GROUNDING 11.9.a MATERIALS:

A. GROUND RODS: COPPER-CLAD STEEL

B. GROUND BUS: RECTANGULAR BARS OF ANNEALED COPPER, 1/4 X 2 INCHES IN CROSS SECTION WITH

C. GROUNDING ELECTRODE CONDUCTORS: BARE COPPER

BONDING JUMPERS: BARE COPPER

EQUIPMENT GROUNDING CONDUCTORS: COPPER WITH GREEN-COLORED INSULATION

UNDERGROUND GROUNDING CONDUCTORS: SOFT DRAWN BARE COPPER

G. GROUNDING CONNECTORS: BRONZE SUITABLE FOR GROUNDING AND BONDING APPLICATIONS, IN

CONFIGURATIONS REQUIRED FOR PARTICULAR INSTALLATION.

11.9.b GROUNDING SHALL BE IN ACCORDANCE WITH NFPA 70 AND DETAILS/NOTES HEREIN PLAN SET.

11.9.c. NON-CURRENT CARRYING PARTS OF ALL ELECTRICAL EQUIPMENT SHALL BE BONDED TO THE EQUIPMENT GROUND SERVING THIS EQUIPMENT. 11.9.d INSTALL SEPARATE EQUIPMENT GROUNDING CONDUCTOR IN CONDUITS WITH ALL BRANCH CIRCUITS AND

FEEDERS. SIZE EQUIPMENT GROUNDING CONDUCTORS IN ACCORDANCE WITH NFPA 70. TERMINATE EACH END ON SUITABLE LUG, BUS, OR BUSHING. 11.9.e INSTALL SOLID CONDUCTORS FOR NO. 10 AWG AND SMALLER, AND STRANDED FOR NO. 8 AND LARGER.

11.9.e BURY UNDERGROUND GROUNDING CONDUCTORS AT LEAST 30 INCHES BELOW GRADE

11.9.f ISOLATED GROUNDING CONDUCTORS: GREEN-COLORED WITH CONTINUOUS YELLOW STRIPE. ON FEEDERS WITH ISOLATED GROUND, IDENTIFY GROUNDING CONDUCTOR WHERE VISIBLE TO NORMAL INSPECTION, WITH ALTERNATING BANDS OF GREEN AND YELLOW TAPE, WITH AT LEAST THREE BANDS OF GREEN AND TWO BANDS OF YELLOW.

11.9.g ISOLATED GROUNDING RECEPTACLE CIRCUITS: INSTALL AN ISOLATED EQUIPMENT GROUNDING CONDUCTOR CONNECTED TO THE RECEPTACLE GROUNDING TERMINAL. ISOLATE CONDUCTOR FROM RACEWAY AND FROM PANELBOARD GROUNDING TERMINALS. TERMINATE AT EQUIPMENT GROUNDING TERMINAL OF THE APPLICABLE DERIVED SYSTEM OR SERVICE, UNLESS OTHERWISE INDICATED.

11.9.h PERFORM TESTS AND INSPECTIONS.

A. INSPECT PHYSICAL AND MECHANICAL CONDITION. VERIFY TIGHTNESS OF ALL BOLTED CONNECTIONS WITH

CALIBRATED TORQUE WRENCH ACCORDING TO MANUFACTURER'S WRITTEN INSTRUCTIONS. B. TEST GROUND RESISTANCE AT SERVICE DISCONNECT ENCLOSURE GROUNDING TERMINAL, AT GROUND TEST

WELLS, AND AT INDIVIDUAL GROUND RODS. MAXIMUM MEASURED GROUND RESISTANCE SHALL NOT EXCEED 5 OHMS. MEASURE GROUND RESISTANCE NO FEWER THAN TWO FULL DAYS AFTER LAST TRACE OF PRECIPITATION AND WITHOUT SOIL BEING MOISTENED BY ANY MEANS.

11.10 LIGHTNING PROTECTION

PREPARE AND SUBMIT TEST AND INSPECTION REPORTS. TURNOVER REPORTS TO COMMISSIONING AGENT.

11.10.a DESIGN & MATERIALS: THE DESIGN AND ALL MATERIALS SHALL CONFORM TO THE CODE REQUIREMENTS OF THE NFPA 780, LIGHTNING PROTECTION INSTITUTE 175 AND UL 96 AND 96A.

A. AIR TERMINALS SHALL BE UTILIZED.

B. COPPER MATERIALS SHALL BE USED FOR CONTACT WITH COPPER SURFACES, THE EARTH, ALKALINE-BASE PAINT, CONCRETE OR MASONRY, OR EXCESSIVE MOISTURE SUCH AS FLAT ROOFS; IN ACCORDANCE WITH NFPA 780 4.2,

ALUMINUM MATERIALS SHALL BE USED ON ALUMINUM, GALVANIZED STEEL, OR PAINTED METAL SURFACES; IN ACCORDANCE WITH NFPA 780 4.2, UL 96A 7, AND LPI 175 18--23.

D. ALL CONDUCTORS SHALL BE COPPER.

11.10.b. ONLY APPROVED ADHESIVE SHALL BE USED ON MEMBRANE ROOF AREAS TO SECURE THE CABLES AND BASES IN POSITION. NO MECHANICAL FASTENERS SHALL BE DRIVEN INTO THE MEMBRANE ROOFING.

11.10.c. CABLE FASTENERS SHALL BE SPACED NO MORE THAN 36" ON CENTER USING SOLD COPPER OR ALUMINUM CLIPS WITH STAINLESS STEEL PINS ON MASONRY SURFACES AND STAINLESS STEEL NAILS ON NAILING SURFACES. 11.10.d. AIR TERMINALS SHALL BE APPLIED TO ALL BUILDINGS WITH SHEET METAL ROOFS OR BUILDINGS NOT OF STEEL MEMBER CONSTRUCTION. EXCEPTIONS TO THIS REQUIREMENT SHALL BE GIVEN TO BUILDINGS ADEQUATELY PROTECTED BY HIGHER LOCATED SYSTEMS, PER NFPA 780.

11.10.e. METAL BODIES WITHIN 72" OF LPS CONDUCTORS SHALL BE BONDED AS REQUIRED BY NFPA 780 4.19, UL 96A 11, AND LPI 175 110.

12. IDENTIFICATION NAMEPLATES AND LABELS

12.1 IDENTIFICATION NAMEPLATES:

12.1.a MATERIALS:

A. INDOOR CLEAN, DRY LOCATIONS: USE PLASTIC NAMEPLATES.

B. OUTDOOR LOCATIONS: USE PLASTIC SUITABLE FOR EXTERIOR USE.

MOTORS AND INSTRUMENT CONNECTION - STAINLESS STEEL IDENTIFICATION TAG.

12.1.b PLASTIC NAMEPLATES: TWO-LAYER OR THREE-LAYER LAMINATED ACRYLIC OR

ELECTRICALLY NON-CONDUCTIVE PHENOLIC WITH BEVELED EDGES; MINIMUM THICKNESS OF 1/16 INCH (1.6 MM);

12.1.c MOUNTING HOLES FOR MECHANICAL FASTENERS: TWO, CENTERED ON SIDES FOR SIZES UP TO 1 INCH (25 MM) HIGH; FOUR, LOCATED AT CORNERS FOR LARGER SIZES.

12.2. IDENTIFICATION LABELS:

12.2.a MATERIALS: USE SELF-ADHESIVE LAMINATED PLASTIC LABELS; UV, CHEMICAL, WATER, HEAT, AND ABRASION RESISTANT.

A. USE ONLY FOR INDOOR LOCATIONS ON ALL NON-EQUIPMENT UNLESS OTHERWISE NOTED. 12.2.b TEXT: USE FACTORY PRE-PRINTED OR MACHINE-PRINTED TEXT. DO NOT USE HANDWRITTEN TEXT UNLESS OTHERWISE

12.3 FORMAT FOR EQUIPMENT IDENTIFICATION:

12.3.a MINIMUM SIZE: 1 INCH (25 MM) BY 2.5 INCHES (64 MM).

12.3.c TEXT: ALL CAPITALIZED UNLESS OTHERWISE INDICATED.

12.3.b. LEGEND:

A. EQUIPMENT DESIGNATION OR OTHER APPROVED DESCRIPTION.

B. OTHER INFORMATION AS INDICATED.

12.3.d MINIMUM TEXT HEIGHT:

A. SYSTEM DESIGNATION: 1 INCH (25 MM). B. EQUIPMENT DESIGNATION: 1/2 INCH (13 MM)

OTHER INFORMATION: 1/4 INCH (6 MM).

D. EXCEPTION: PROVIDE MINIMUM TEXT HEIGHT OF 1 INCH (25 MM) FOR EQUIPMENT

LOCATED MORE THAN 10 FEET (3.0 M) ABOVE FLOOR OR WORKING PLATFORM. 12.3.e COLOR:

A. NORMAL POWER SYSTEM: WHITE TEXT ON BLACK BACKGROUND.

12.4 FINAL CONNECTIONS TO ALL MOTORS AND INSTRUMENTS WILL BE SUPPLIED WITH A STAINLESS STEEL TAG IDENTIFYING THE EQUIPMENT (UON ON PLANS OR IN SPECIFICATIONS SECTION 26). THE IDENTIFICATION TAG WILL BE SUPPLIED ON THE CONNECTION POINT, NOT THE EQUIPMENT, TO FACILITATE FUTURE REPLACEMENT. 12.5 TERMINAL BLOCKS WILL BE CLEARLY LABELED AT EACH TERMINATION POINT. THE LABELING SYSTEM WILL BE

TYPED, NOT WRITTEN AND WILL PROTECT THE LETTERING. 13. WIRE AND CABLE MARKERS

13.1 MARKERS FOR CONDUCTORS AND CABLES: USE WRAP-AROUND SELF-ADHESIVE VINYL

CLOTH, WRAP-AROUND SELF-ADHESIVE VINYL SELF-LAMINATING, HEAT-SHRINK SLEEVE, OR PLASTIC SLEEVE. 13.2 MARKERS FOR CONDUCTOR AND CABLE BUNDLES: USE PLASTIC MARKER TAGS SECURED

BY NYLON CABLE TIES.

13.3 LEGEND: POWER SOURCE AND CIRCUIT NUMBER OR OTHER DESIGNATION INDICATED. 13.4. TEXT: USE FACTORY PRE-PRINTED OR MACHINE-PRINTED TEXT. ALL CAPITALIZED UNLESS

OTHERWISE INDICATED.

13.4.a DO NOT USE HANDWRITTEN TEXT.

13.5 MINIMUM TEXT HEIGHT: 1/8 INCH (3 MM)

13.6 COLOR: BLACK TEXT ON WHITE BACKGROUND UNLESS OTHERWISE INDICATED.

14. GENERAL MOUNTING HEIGHTS

14.1 MOUNT DEVICES AT HEIGHTS INDICATED BELOW UNLESS OTHERWISE NOTED ON PLANS. HEIGHTS ARE TO CENTER OF DEVICE (UON). WHERE A DEVICE NOT LISTED BELOW IS BEING INSTALLED, MOUNTING HEIGHT SHALL FOLLOW ANY REGULATION REQUIREMENTS, TYPICAL INDUSTRY STANDARDS AND/OR MANUFACTURERS REQUIREMENTS.

LIGHT SWITCHES RECEPTACLE, GENERAL

6" ABOVE COUNTERTOP RECEPTACLE, COUNTER

AS NOTED OR APPROPRIATE FOR USE SPECIAL PURPOSE OUTLET 18", 60" FOR STANDING LOCATIONS TELEPHONE/DATA

THERMOSTAT PUSHBUTTONS

INTERCOMS 54" INTERIOR, 48" EXTERIOR

CARD READERS

80"-96" WALL MOUNTED, 30' MAXIMUM CEILING MOUNTED FIRE ALARM HORN/STROBE

FIRE ALARM PULL STATION AS INDICATED ON SCHEDULE

LIGHTING FIXTURES PANELBOARDS TOP AT 78"

SAFETY SWITCHES 60" OR ADJACENT DEVICE SERVED AS ALLOWED PER CODE

HMI SCREENED DEVICE 60" AT SCREEN (WALL MOUNTED)

14.2 HEIGHTS ARE FOR REFERENCE AND ALL NATIONAL OR LOCAL CODES SHALL TAKE PRECEDENCE. IT IS THE

RESPONSIBILITY OF THE INSTALLING CONTRACTOR TO CONFIRM HEIGHTS PRIOR TO ROUGH-IN

GENERAL ABBREVIATIONS:

ABOVE FINISHED FLOOR AFG ABOVE FINISHED GRADE AHJ AUTHORITY HAVING JURISDICTION AWG AMERICAN WIRE GAUGE BELOW FINISHED FLOOR BFG BELOW FINISHED GRADE BOD BASIS OF DESIGN CIRCUIT BREAKER CDP CONTROLS DISTRIBUTION PANEL CONDUIT CLG CEILING CP CAPPED / PLUGGED CONDUIT (SPARE)

DS DISCONNECT SWITCH ELECTRICAL CONTRACTOR ETR EXISTING TO REMAIN

CU Cu COPPER

FD FIELD DETERMINE GC GENERAL CONTRACTOR GFCI GROUND FAULT CIRCUIT INTERRUPTING GROUND FAULT INTERRUPTING GFI GROUND

HVAC CONTRACTOR HORSE POWER HIGH PRESSURE SODIUM HOLLOW STRUCTURAL STEEL

3 - 1/C #10 Cu AWG

1 - 1/C #10 Cu GND

1" CONDUIT

TO PLC - 6 #14 Cu, 3/4" RGS:

RUN COMMAND,

RUNNING, AND FAULT

OEM

7.5HP, 480VAC, 11 FLA

POTTED CABLE

SIZE 1

DISCONNECT

OEM

PUMP 2

7.5HP, 480VAC, 11 FLA

POTTED CABLE

STARTER

TYPE 3R

KILOWATT KILO-VOLT AMPS

MECHANICAL CONTRACTOR MAIN CIRCUIT BREAKER MAIN DISTRIBUTION PANEL MANUFACTURER'S MAIN LUGS ONLY

SCHEDULE **TYPICAL**

UNLESS OTHERWISE NOTED UON

TRANSFORMER

KW kW

KVA

INPUT / OUTPUT JUNCTION BOX

MCB MDP MFR'S MLO PULL BOX QTY QUANTITY RIGID GALVANIZED STEEL RPR RESIDENT PROJECT REPRESENTATIVE

VOLT ALTERNATING CURRENT VCR VACUUM RECLOSER VFD VARIABLE FREQUENCY DRIVE

FOR SCCR OF THIS SERVICE EC TO RUN CONDUIT DOWN AEP POLE TO CT CABINET/METER 30" BELOW GRADE

ELECTRICAL

UTILITY SERVICE

100A, 480V, 3¢, 3W

COORDINATE WITH AEF

GENERATOR 25kW, 480VAC, 3 POLE ■ 40A MCB SOCKET 3- 1/C #6 Cu AWG 1 - 1/C #10 Cu GND

1" CONDUIT 3- 1/C #8 Cu AWG 1 - 1/C #8 Cu GND 60A MTS 480VAC, 3φ, HD NEMA 3R, 3 POLE **GENERATOR** CONNECTION 3- 1/C #6 Cu AWG

1 - 1/C #10 Cu GND

1" CONDUIT

60A-3P 3- 1/C #10 Cu AWG 3 - 1/C #10 Cu AWG 1 - 1/C #10 Cu GND 1 - 1/C #10 Cu GND 1" CONDUIT 1" CONDUIT TO PLC - 6 #14 Cu, 3/4" RGS: RUN COMMAND, RUNNING, AND FAULT 480V, 3φ, 4W NEMA 3R ENCLOSURE **TRANSFORMER** SIZE 1 COMBINATION COMBINATION **| 480-120/240 | 480-120/240 | 1** DISCONNECT 1φ (NEMA 3R) STARTER TYPE 3R LP1 120/240V, 1¢, 3W

> BASIC OF DESIGN IS A SQUARE D MINI POWER ZONE UNIT SUBSTATION. BOLT ON BRANCH, 1 o, 10kVA. 480V PRIMARY, 120/240v SECONDARY, TYPE 3R. (MPZB10S40F)

PROJECT NO. 241455 DISCIPLINE


ELECTRICAL


SHEET NAME

10E-02

23

H:\2024\241455\DWG\SHEETS\ELECTRICAL FROM Y DRIVE\E-002 ELECTRICAL SINGLE LINE.DWG - 15 SINGLE LINE - 8/28/2025 4:23:05 PM - BOB MARANO

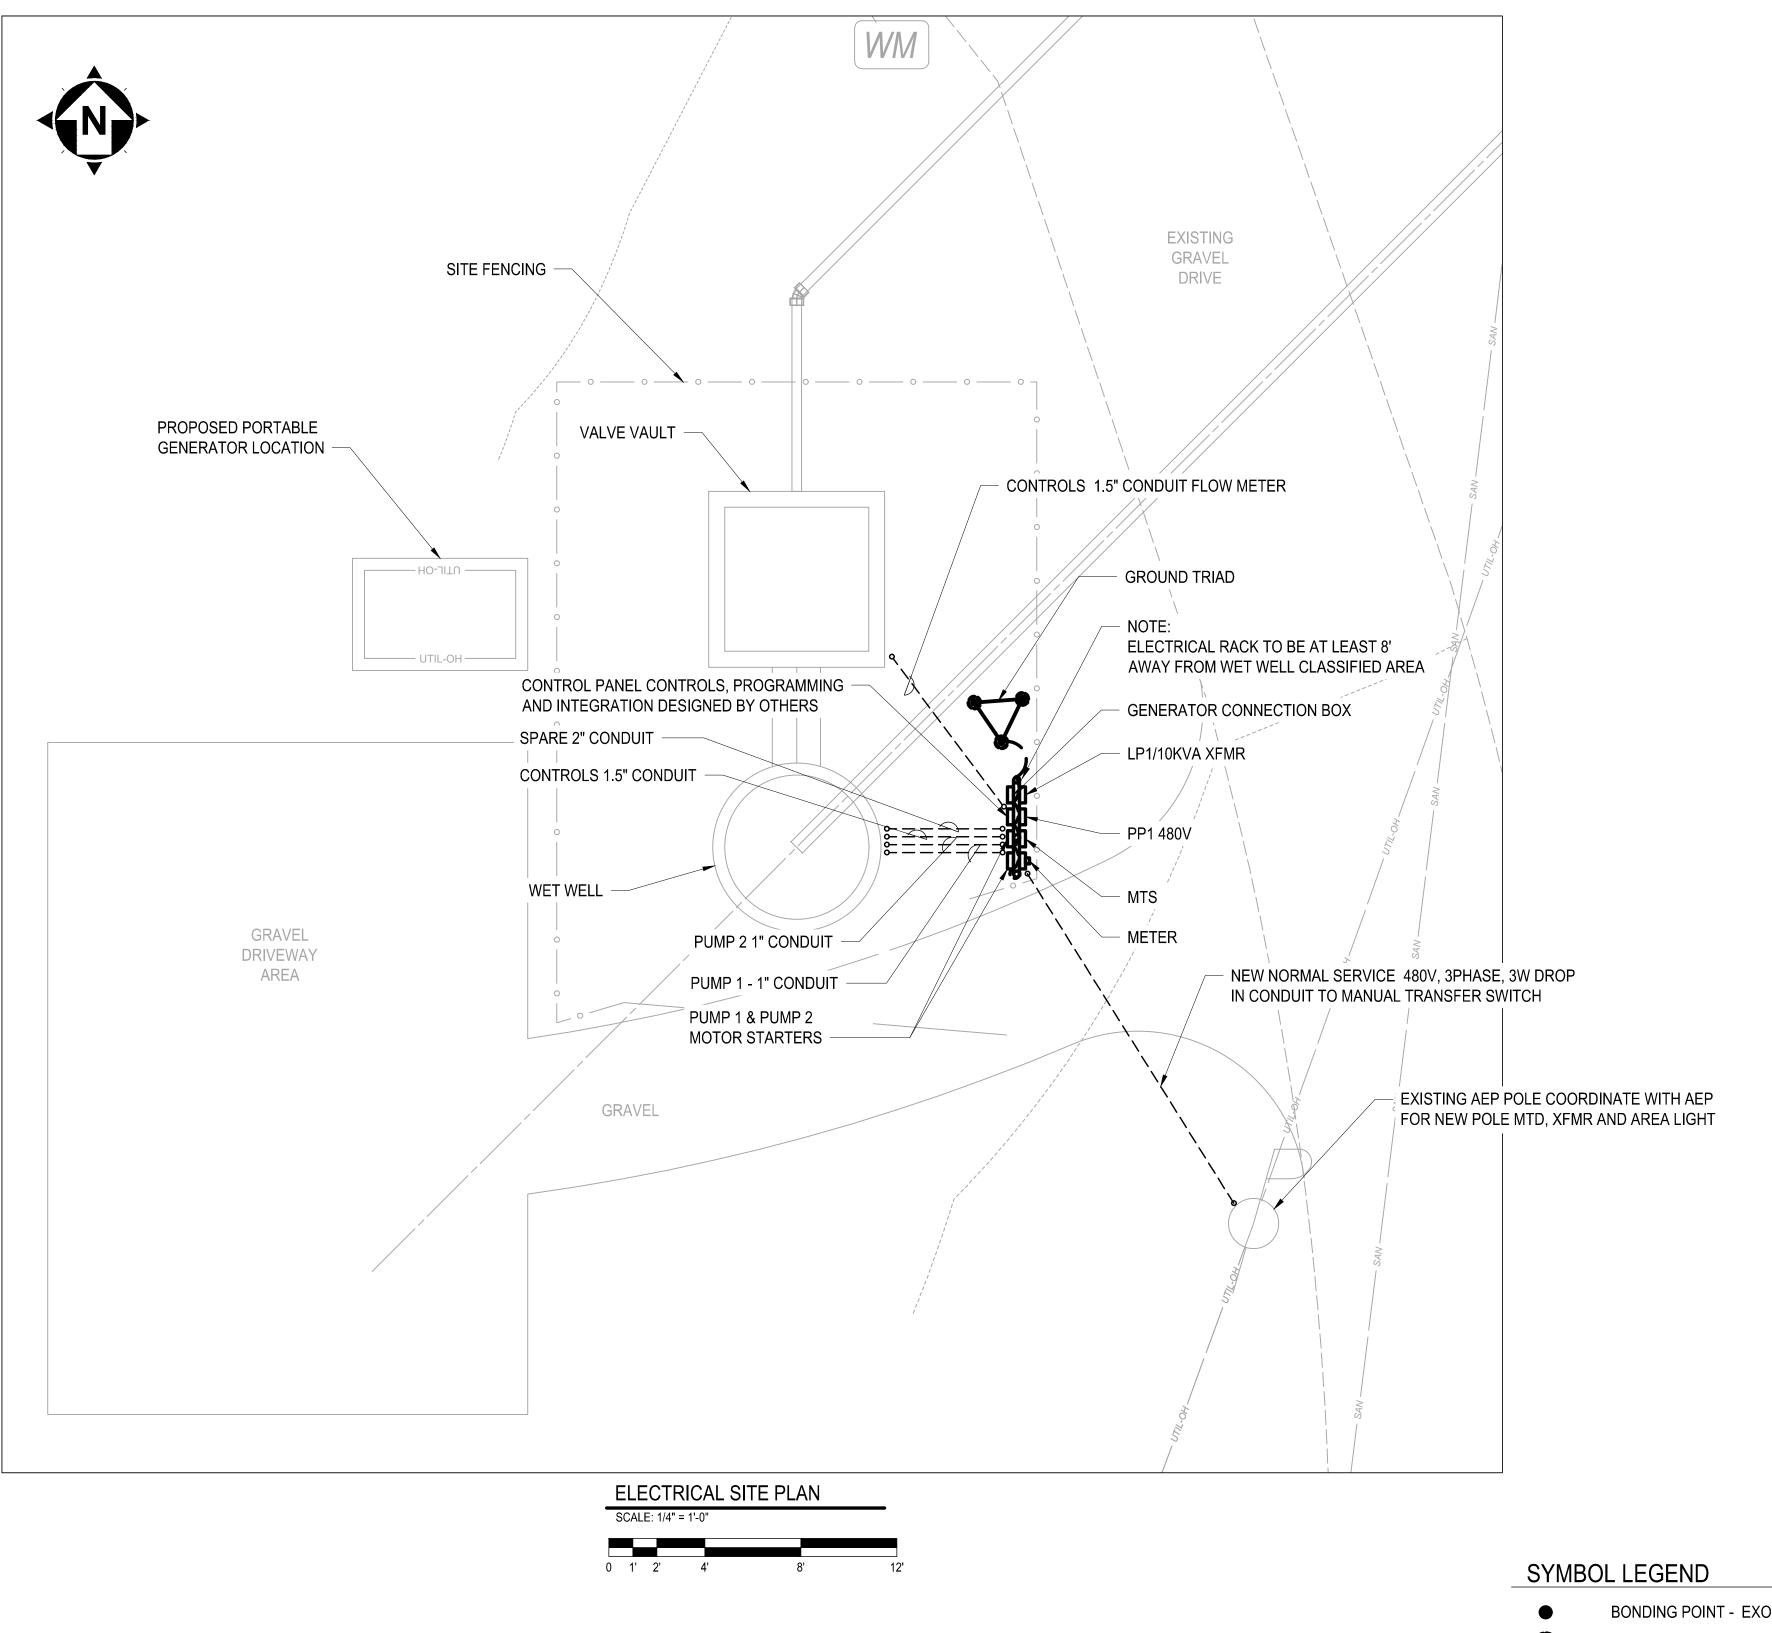

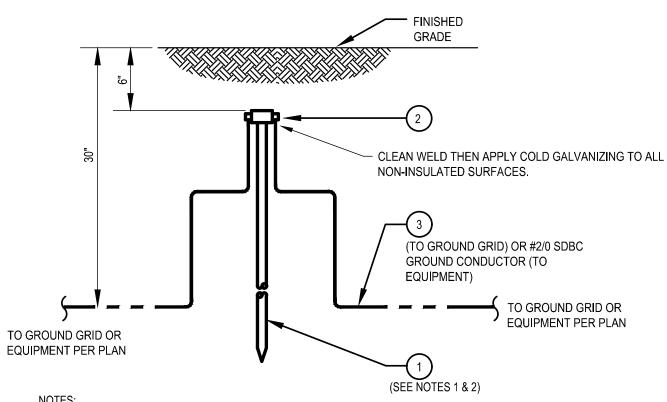


1. CADWELD GROUND ROD SPLICE CONNECTIONS ARE TO BE USED IN THE EVENT WHERE ADDITIONAL GROUND RODS ARE REQUIRED TO EXTEND ROD LENGTH BEYOND 10'. ELECTRICAL CONTRACTOR SHALL USE CADWELD CAT. NO. HDGBD-18 MOLD WITH CAT. NO. 2-200 WELD METAL (OR EQUAL).

2. REMOVE ROD GALVANIZING TO BARE STEEL BEFORE MAKING CONNECTIONS. THEN APPLY COATING OF COLD GALVANIZING TO ALL BARE METAL NON-GALVANIZED SURFACES.

		BILL OF MATERIAL
ITEM	QTY.	DESCRIPTION
1	1	GROUND ROD, 3/4" DIA. X 8' LONG HOT DIPPED GALV. STEEL, GALVAN GR7510 OR EQUAL
2	1	CONNECTOR, CABLE TO GND. ROD, CADWELL OR EQUAL
3	A/R	GROUND WIRE, MAIN GRID AS INDICATED ON PLANS


GROUND ROD INSTALLATION

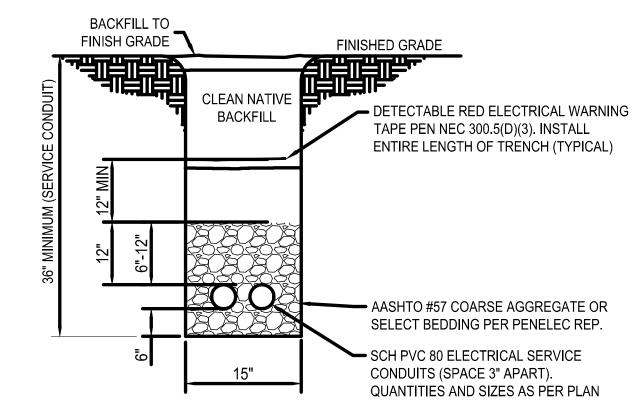

- NOTES:

 1. REFER TO PENELEC SPECIFICATIONS ON THIS SHEET FOR UTILITY EQUIPMENT SPECIFIC INFORMATION. COORDINATE TRENCHING WITH UTILITY COMPANY.
- 2. COMPACTION OF MATERIALS SHALL BE TO UTILITY REQUIREMENTS.

1. CONTRACTOR TO UTILIZE 25% OR 40% FILL SEAL-OFF FITTINGS WHERE SEAL-OFFS ARE NEEDED IN CLASSIFIED

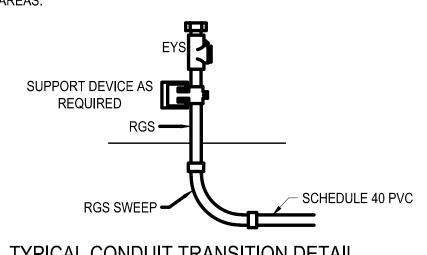

TYPICAL CONDUIT TRANSITION DETAIL SCALE: NONE"

- BONDING POINT EXOTHERMIC WELD UNLESS OTHERWISE NOTED
- 5/8" x 8' STEEL GROUND ROD WITH HOT-DIP ZINC GALVANIZATION
- GROUND ROD WITH ACCESS INSPECTION WELL AND MECHANICAL CABLE ROD CONNECTOR. SEE ACCESS WELL DETAIL ON SHEET E-104.

MAIN GROUNDING LOOP - 2/0 Cu INSULATED GROUND WIRE RATED FOR DIRECT BURY

BRANCH GROUNDING - #2 Cu INSULATED GROUND WIRE RATED FOR DIRECT BURY (UNLESS NOTED OTHERWISE)

A.F.F. ABOVE FINISHED FLOOR

ABOVE FINISHED GRADE

B.F.G. BELOW FINISHED GRADE

ISSUE DATE: 8/29/25	SCALE: AS NOTED	DESIGNED BY: CJZ	DRAWN BY: CJZ	CHECKED BY: TLD
SOVEMENTS	GUERNSEY COUNTY, OHIO		LIFT STATION - 10 SERIES	SITE PLAN

PROJECT NO.

241455

DISCIPLINE **ELECTRICAL**


SHEET NAME

10E-03

NOTES:

- 1) INSTALL APPROPRIATELY SIZED LIQUID TIGHT CABLE CONNECTORS, APPLETON CG (CORD GRIP) STYLE OR EQUAL. AT TERMINAL BOW ENTRY POINTS (ONE PER CABLE)
- 2) INSTALL APPROPRIATELY SIZED CONDUIT SEALING BUSHINGS, OZ GEDNEY
 CSBE SERIES OR EQUAL AT CONDUIT ENDS INSTALLED IN CORE-DRILLED HOLES
 (ONE PER CABLE)
- 3) STAINLESS STEEL COUPLING PLATE ANCHORED TO WET WELL WALL.
- 4) PROVIDE BUSHING NIPPLES, TERMINAL ADAPTERS AND FITTINGS AS REQUIRED TO SECURELY ATTACH EACH CONDUIT TO THE COUPLING PLATE.

AIR BREAK TERMINAL BOX / DISCONNECT WITH SUPPORT AND CABLE ASSEMBLY SCALE: NO SCALE

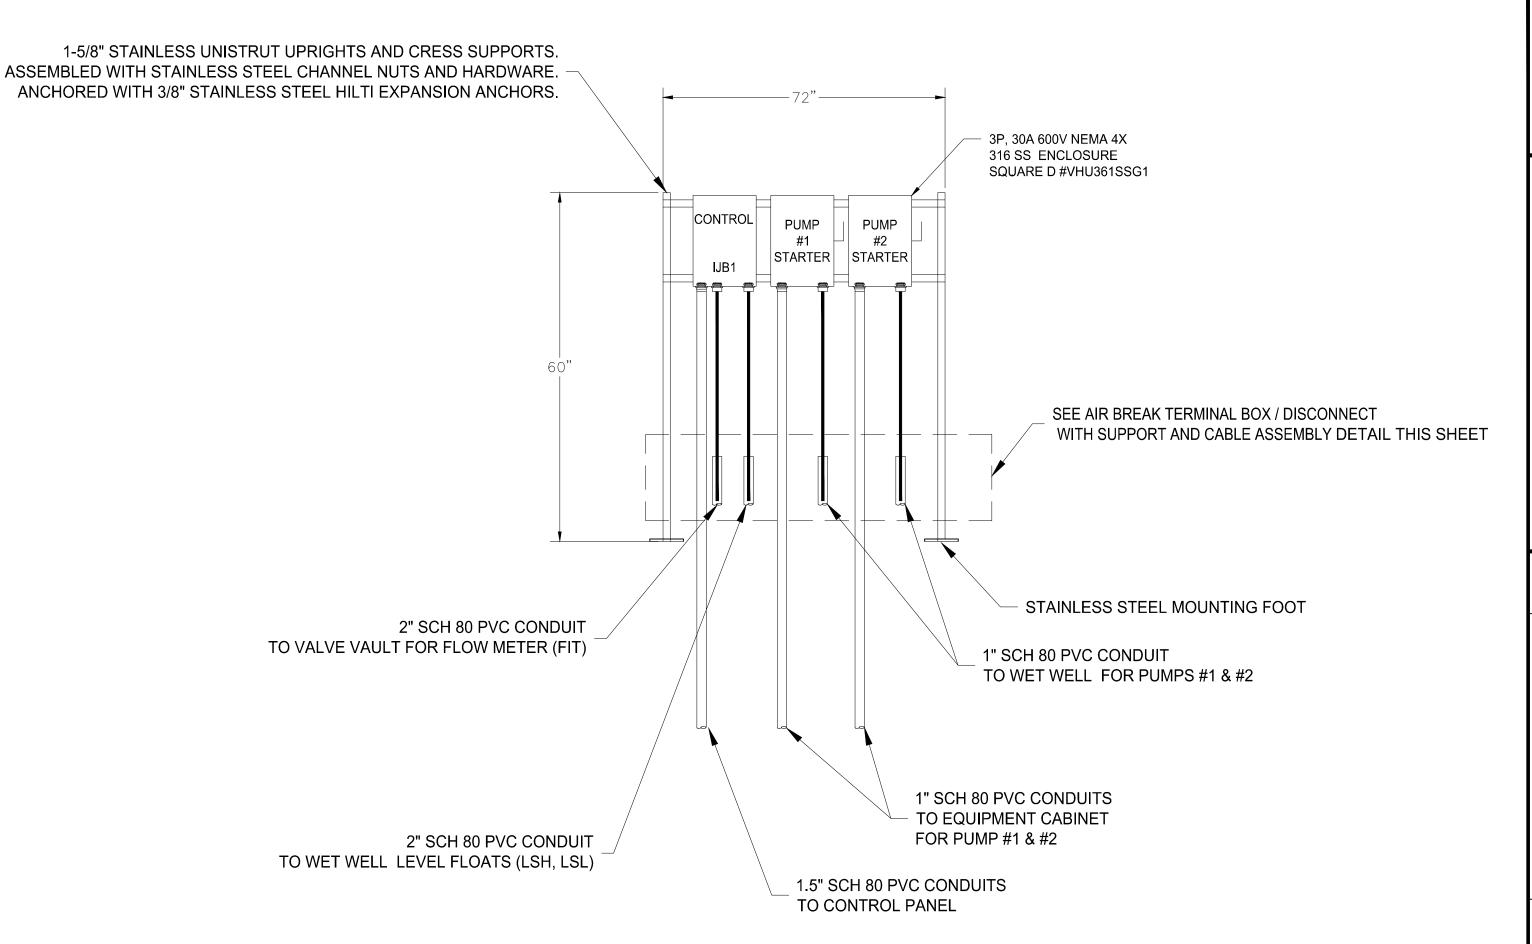

PUMP STATION JUNCTION BOX AND DISCONNECT RACK DETAIL SCALE: NO SCALE




9


NO REVISION					
REVIEW	8/29/25	AS NOTED	CJZ	CJZ	TLD
ISSUED FOR:	ISSUE DATE:	SCALE:	DESIGNED BY:	DRAWN BY:	CHECKED BY:
VILLAGE OF BYESVILLE	821 SANITARY SEWER IMPROVEMENTS	- ROLLING MILLS WWIP ABANDONEMEN I GUERNSEY COUNTY, OHIO		LIFI STATION - 10 SERIES	ELECTRICAL RACK DETAIL


PROJECT NO. **241455**


SHEET NAME

10E-04

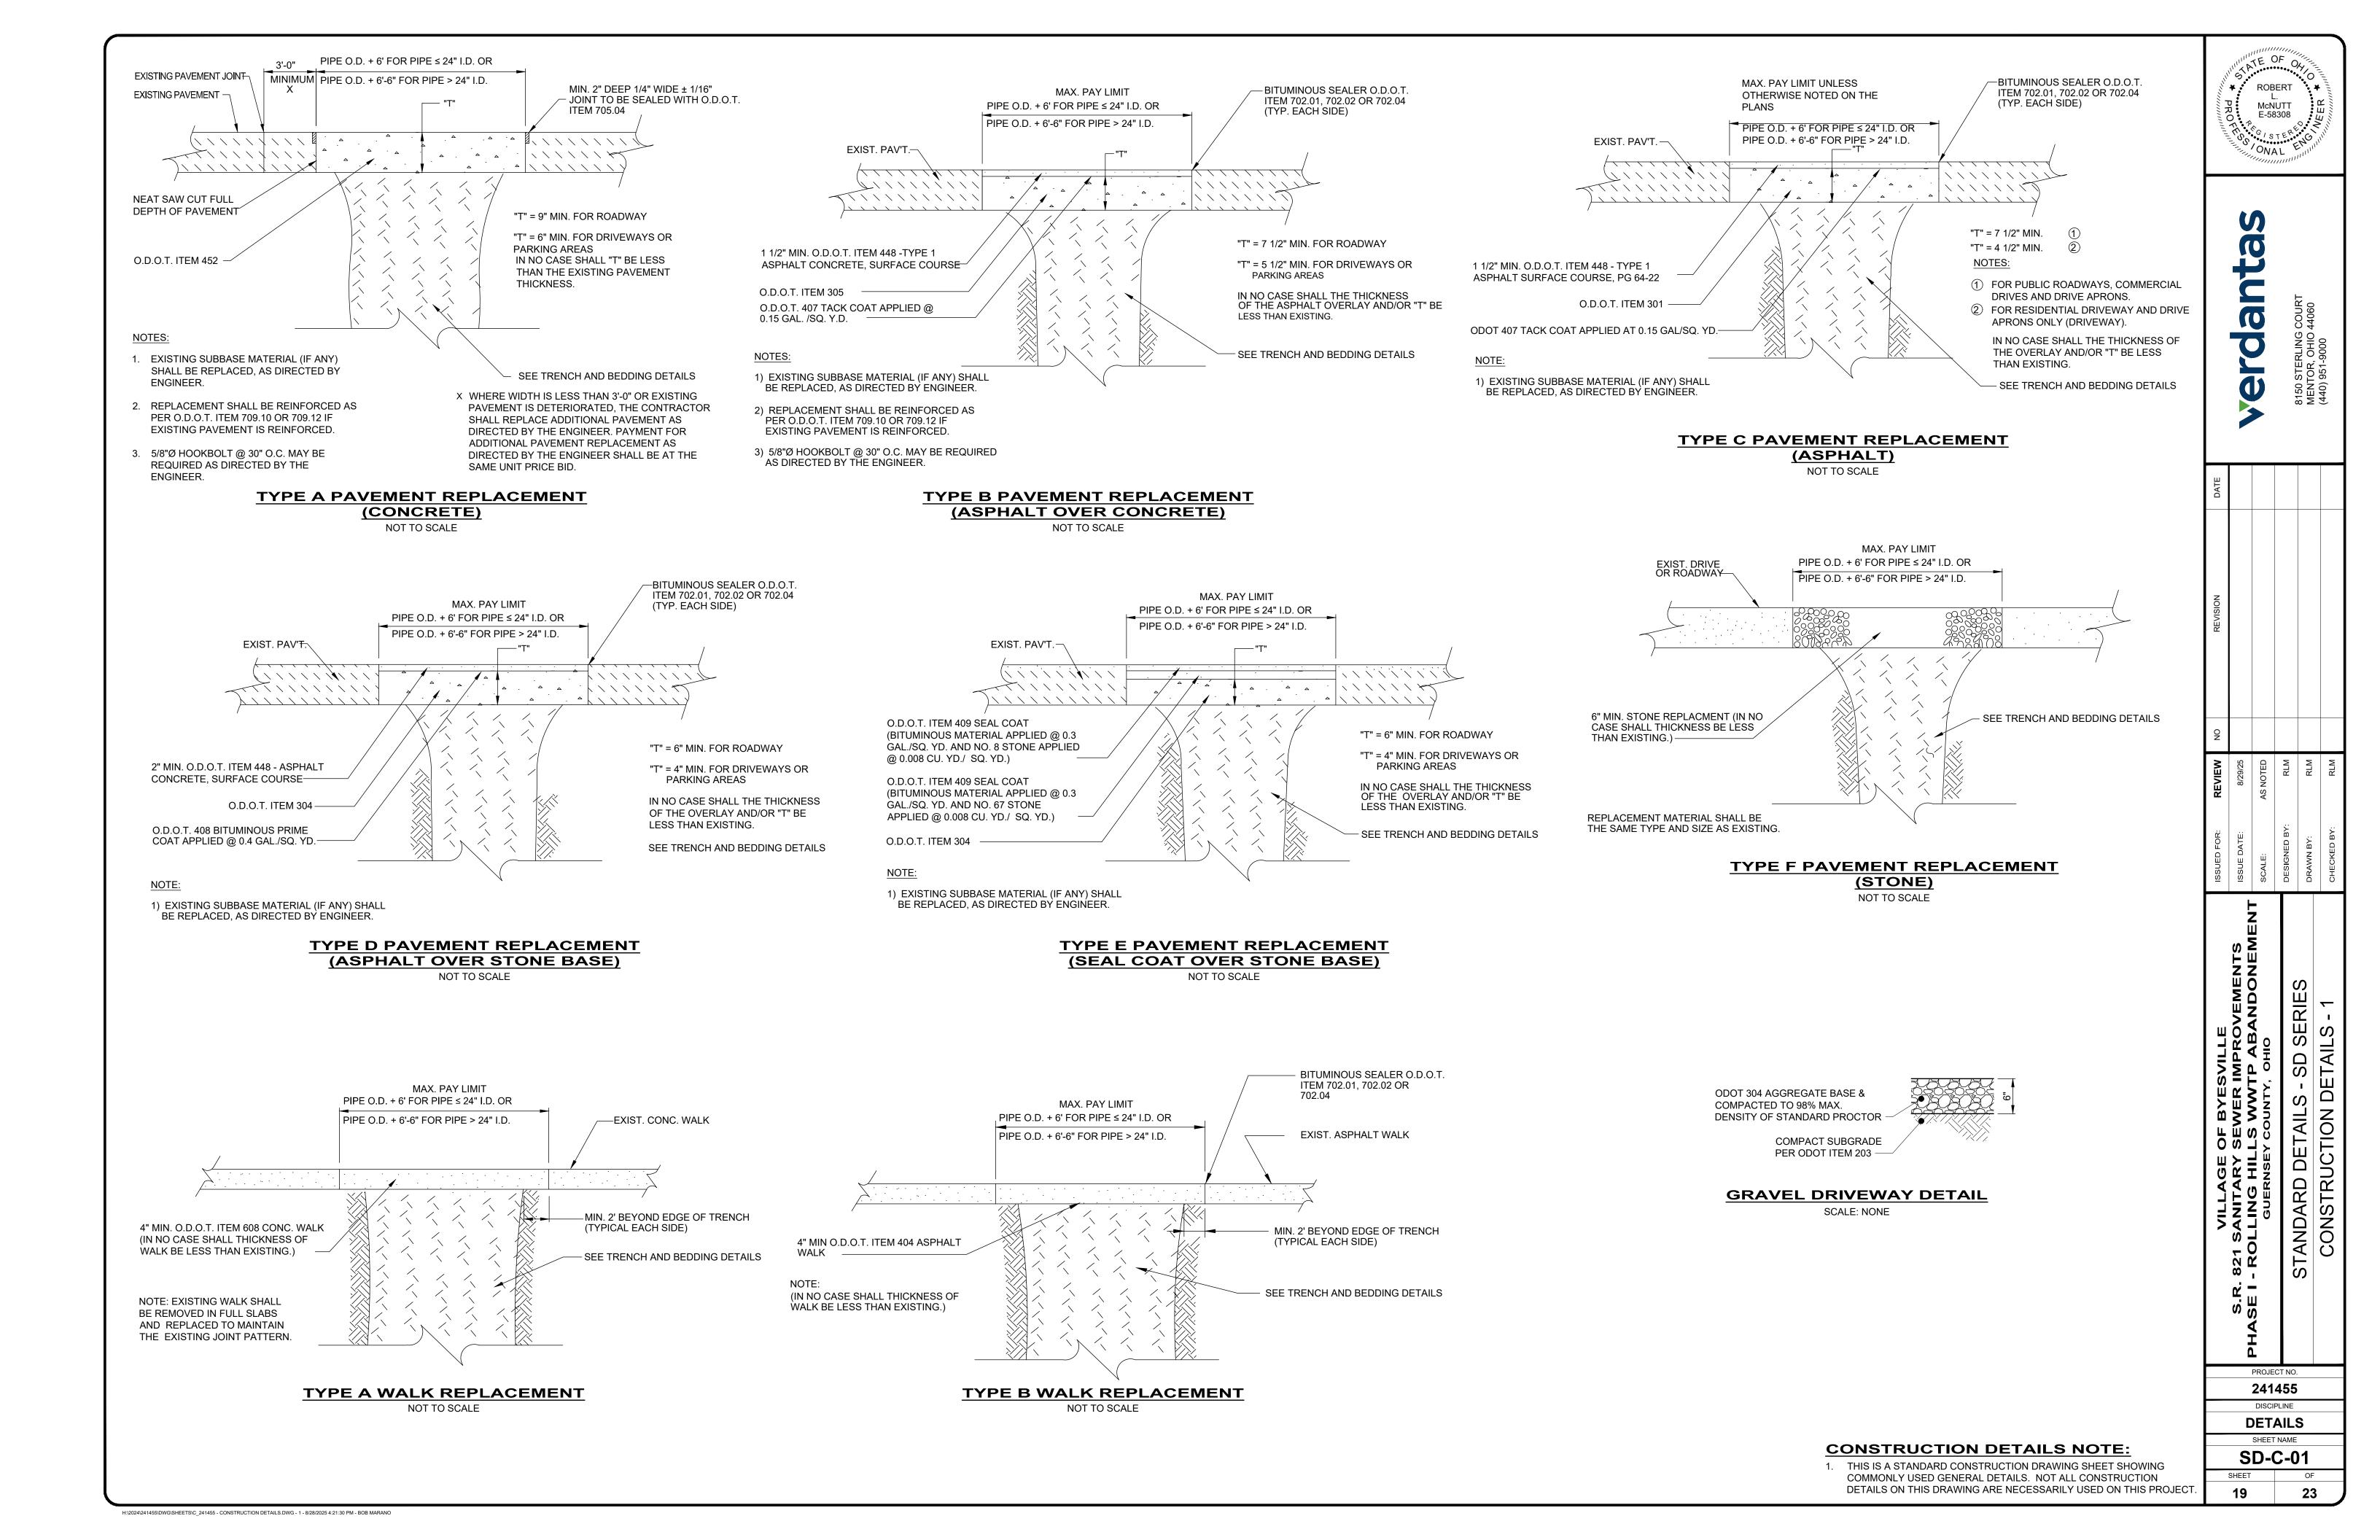

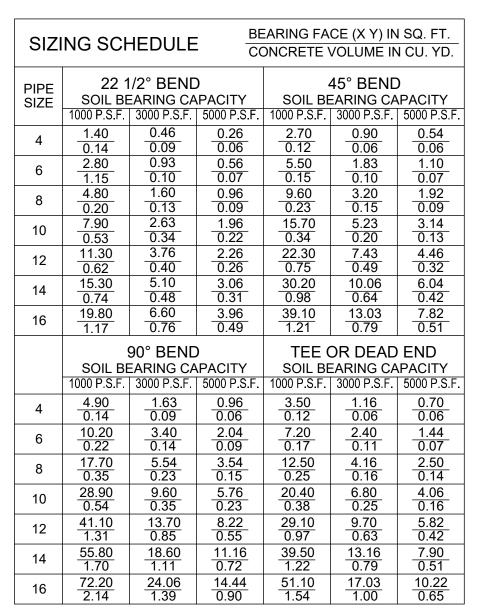

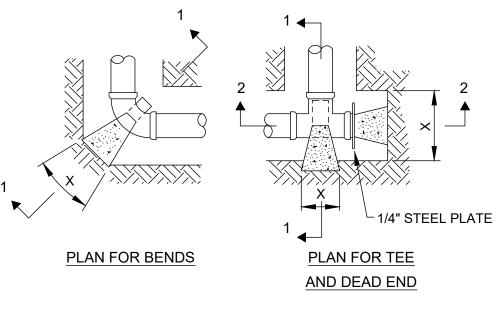

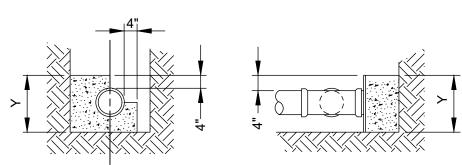


ALL CONCRETE BLOCKING MUST HAVE ITS ENTIRE FACE (X & Y) BEARING SURFACE AGAINST UNDISTURBED SOIL AND ALL VERTICAL NON-BEARING SURFACES SHALL BE FORMED SO AS TO KEEP CONCRETE FROM JOINTS. BLOCKING DESIGN BASED ON COMBINED WORKING PRESSURE PLUS WATER HAMMER OF 240 PSI AND FOR BEARING CAPACITY FOR SAND - 1000 PSF, SAND AND GRAVEL - 3000 PSF, SHALE - 5000 PSF.

SECTION 2-2

THRUST BLOCKING DETAIL

SECTION 1 - 1

NOT TO SCALE

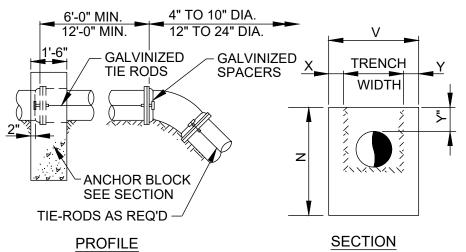

22 1/2° E	END-NO BLK'G. REQ'D. BEND-2 #4 EQ. SPC'D. 0-#4 @ 6" C/C	
A VIX	─ CONC	
PROFILE	SECTION	

TABEL OF DIMENSIONS - SAG BENDS

REIN'F. FOR SAG BENDS

TABLE OF DIMENSINS - OVER BENDS

1	11 1/4°, 22 1/2°, & 45° BENDS					TIE RODS	PIPE	22 1/2° BEND			45° BEND		
	Χ	V	Y	N	C.Y.	NO. & SIZE	SIZE	A	W	C.Y.	Α	W	C.Y.
1	1'-0"	4'-3"	1'-0"	2'-4"	.55	2-3/4" DIA.	4"	_			_		_
	1'-0"	4'-6"	1'-0"	2'-6"	.61	2-3/4" DIA.	6"			_	O'-8"	1'-8"	0.05
1	1'-0"	4'-8"	1'-0"	2'-8"	.67	2-3/4" DIA.	8"	0'-8"	1'-4"	0.04	0'-9"	2'-8"	0.10
1	1'-0"	4'-10"	1'-0"	2'-10"	.72	4-3/4" DIA.	10"	0'-8"	2'-0"	0.06	1'-2"	2'-10"	0.16
1	1'-0"	5'-0"	1'-0"	3'-0"	.78	4-3/4" DIA.	12"	0'-8"	2'-4"	0.08	1'-7"	3'-0"	0.24
	1'-0"	5'-2"	1'-0"	3'-3"	.87	6-3/4" DIA.	14"	0'-8"	2'-9"	0.09	1'-8"	3'-2"	0.28
	1'-0"	5'-4"	1'-0"	4'-4"	1.09	8-3/4" DIA.	16"	0'-9"	3'-4"	0.14	2'-3"	3'-4"	0.41
1	1'-0"	5'-6"	1'-0"	4'-7"	1.34	8-3/4" DIA.	18"	1'-0"	3'-6"	0.20	2'-9"	3'-6"	0.54

SIZE

8" 10" 12" 14"


16"


18"

- 1. TABLE PORTION FOR NO. AND SIZE OF TIE RODS IS APPLICABLE TO ALL TIE-IN PIPING REQUIRING SUCH REINFORCEMENT.
- 2. USE OF ANCHOR BLOCKS AND OR THRUST BLOCKS NEEDED ONLY IF A TIE-RODDED EXTENSION PIECE EQUALS OR EXCEEDS A STANDARD PIPE LENGTH.
- 3. BLOCKING DESIGN BASED ON COMBINED WORKING PRESSURE OF WATER HAMMER AND SOIL BEARING
- AT 3000 P.S.I.


OVER & SAG BEND THRUST BLOCKING DETAILS


NOT TO SCALE

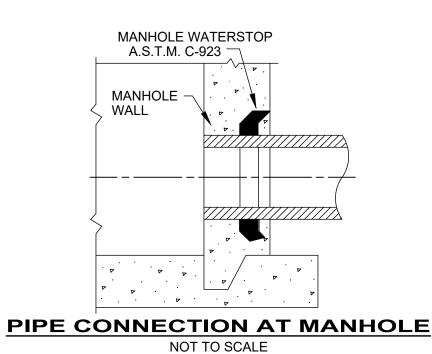


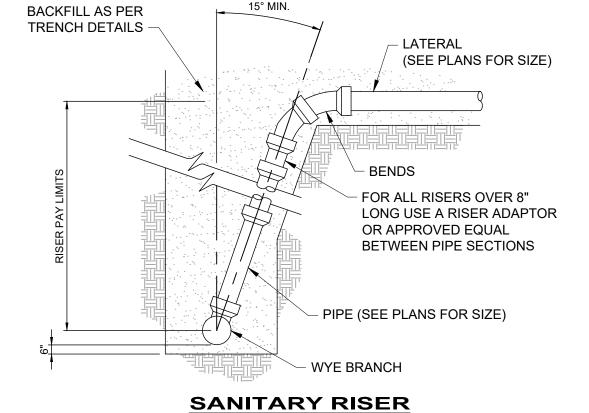

NOT TO SCALE

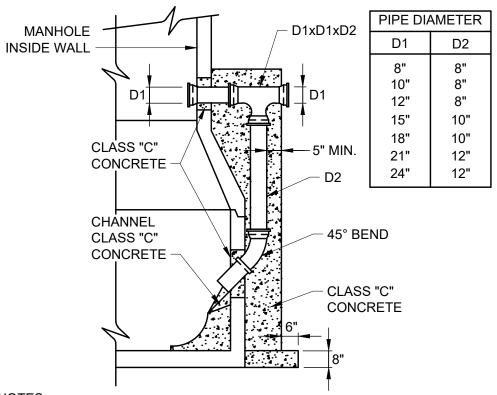

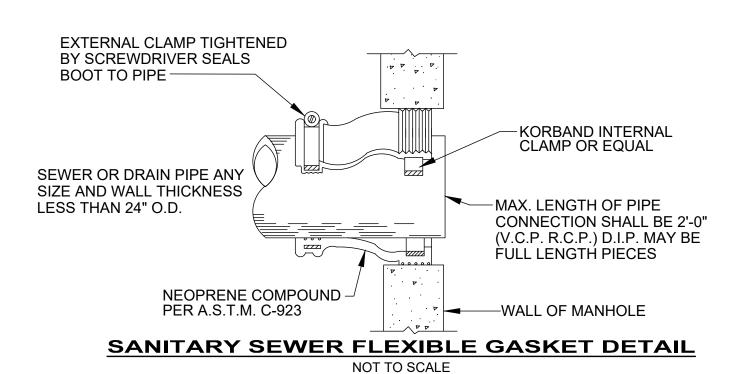

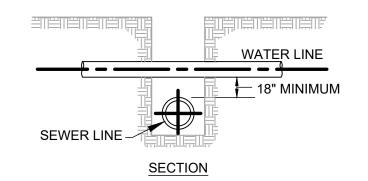

1. IF JOINT ON WATER MAIN IS WITHIN LIMITS OF SEWER TRENCH,

- INSTALL MECHANICAL BELL JOINT CLAMP
- 2. IF CLEARANCE IS LESS THAN 18", ENCASE SEWER PIPE 6 FT. EACH SIDE OF WATER MAIN. COST SHALL BE INCLUDED IN THE UNIT
- 3. IN NO CASE SHALL THE SEWER PIPE CONTACT ANY WATER MAIN, SERVICE LINE OR APPURTENANCE.

VERTICAL WATER MAIN CLEARANCE

PRICES BID FOR ALL ITEMS IN THE PROPOSAL.


NOT TO SCALE

1. DROP IS REQUIRED WHEN INVERT DIFFERENTIAL IS 24 INCHES

- OR GREATER. 2. HEIGHT OF DROP PIPE IS TO BE AS SHOWN ON THE DRAWINGS
- OR WILL BE DETERMINED AT THE TIME OF CONSTRUCTION. 3. ALL WORK AND MATERIALS REQUIRED TO CONSTRUCT THE DROP SHOULD BE INCLUDED FOR PAYMENT UNDER THE PAY ITEMS ESTABLISHED FOR MANHOLES, AND/OR PIPE SEWERS
- COMPLETE IN PLACE. 4. MATERIALS FOR THE TEE, DROP PIPE AND BEND SHALL BE C.I., DIP, OR PVC.
- 5. PIPE REQUIRE A 5" THICK (MINIMUM) CLASS "C" CONCRETE ENCASEMENT ON THREE SIDES OF PIPE AND TIED TO MANHOLE WALL WITH 5/8"-"U" RODS X 6" LONG @ 12".

OUTSIDE DROP PIPE FOR MANHOLES

SCALE: NONE

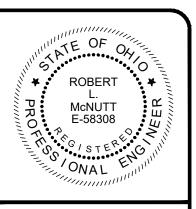



NO						
REVIEW	10,00,0	8/29/25	AS NOTED	RLM	RLM	RLM
ISSUED FOR:		ISSUE DATE:	SCALE:	DESIGNED BY:	DRAWN BY:	CHECKED BY:
	VILLAGE OF BYESVILLE S R 821 SANITARY SEWFR IMPROVEMENTS	LINEMENDALINA OTAMA O LIIL ONI LICO I ESCULO	GUERNSEY COUNTY, OHIO		STANDARD DETAILS - SD SERIES	N DETAILS - 2
	VILLAGE S R 821 SANITARY			CT NO.		CONSTRUCTION DETAILS - 2


SHEET NAME **SD-C-02**


23

SHEET

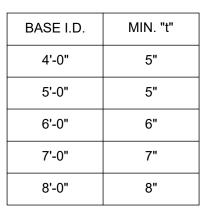

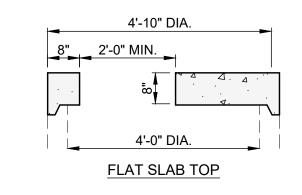

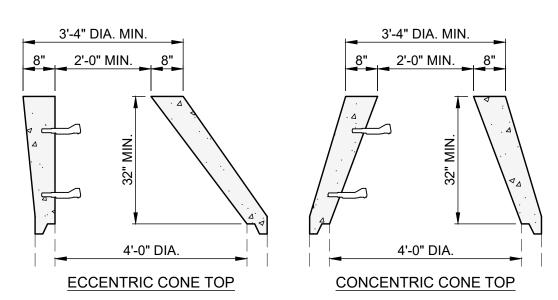

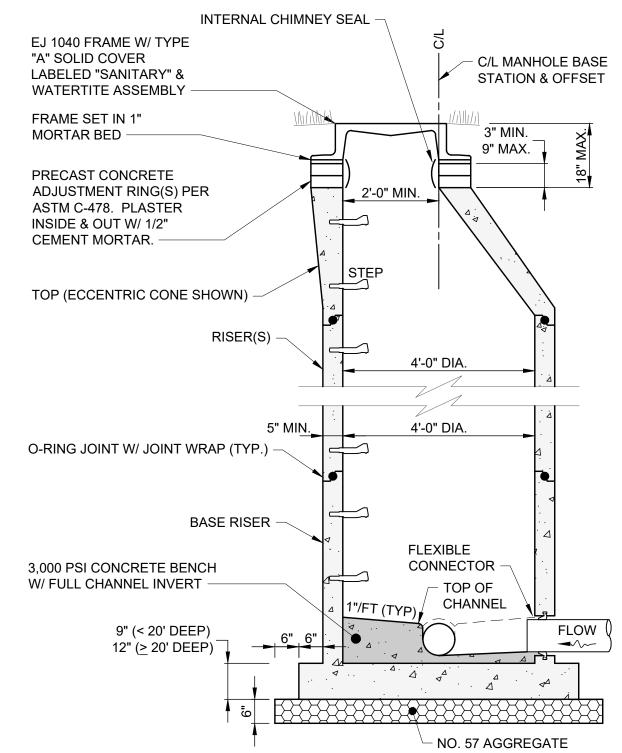


NOTES:

- TOP SECTION SHALL BE AN ECCENTRIC CONE. ROTATE CONE TO OFFSET MANHOLE CASTING TO AVOID SIDEWALKS, UNDERDRAINS AND CURBS. [ADDITIONAL OPTION: THIS DETAIL SHOWS AN ECCENTRIC CONE TOP FOR REFERENCE, BUT TOP SECTION SHALL BE A CONCENTRIC CONE.] USE FLAT SLAB TOP IF MANHOLE IS LESS THAN 6'-3" DEEP.
- O-RING JOINT BETWEEN PRECAST MANHOLE SECTIONS SHALL BE RESILIENT WATERTIGHT GASKET PER ASTM C-443.
- PRECAST MANHOLE AND REINFORCEMENT SHALL CONFORM TO ASTM
- C-478. 4. STRUCTURE SHALL MEET H-20 LOADING.
- BASE MUST BE PRECAST MONOLITHIC WITH BASE RISER.
- ALL PIPE OPENINGS MUST BE PRECAST WITH FLEXIBLE CONNECTIONS (Z-LOK OR A-LOK) PER ASTM C-923.
- WRAP ALL INSIDE AND OUTSIDE MANHOLE JOINTS WITH 24" WIDE EXTERIOR JOINT WRAP PER ASTM C-877 TYPE III, CONSEAL CS-212.
- CONCRETE CHANNEL TOP SHALL EXTEND TO FULL HEIGHT OF PIPE(S).
- CONCRETE BENCH AND CHANNEL(S) SHALL BE PRECAST AS ONE PIECE IN THE BASE SECTION. ALL PIPES SHALL HAVE POURED INVERTS.
- 10. ALL PRECAST CONCRETE SECTIONS SHALL BE MANUFACTURED AND FURNISHED AS SOLID SECTIONS WITHOUT LIFT HOLES OF ANY KIND.
- 11. USE REINFORCED PLASTIC MANHOLE STEPS.
- FIRST STEP SHALL NOT BE MORE THAN 2'-0" BELOW TOP OF FRAME. MAKE PROJECTION 3-1/2" IF IN 24" DIA. SECTION.
- 13. MANHOLE MUST PASS A VACUUM TEST PER ASTM C-1244.
- ANY PRECAST CONCRETE SECTION DAMAGED IN TRANSIT OR ON-SITE AND WHERE THE WATER TIGHTNESS OF THE SECTION HAS BEEN ADVERSELY AFFECTED SHALL BE REPLACED AND NOT UTILIZED IN THE CONSTRUCTION OF THE MANHOLE.

PRECAST CONCRETE **MANHOLE (SANITARY) DETAIL**

SCALE: NONE

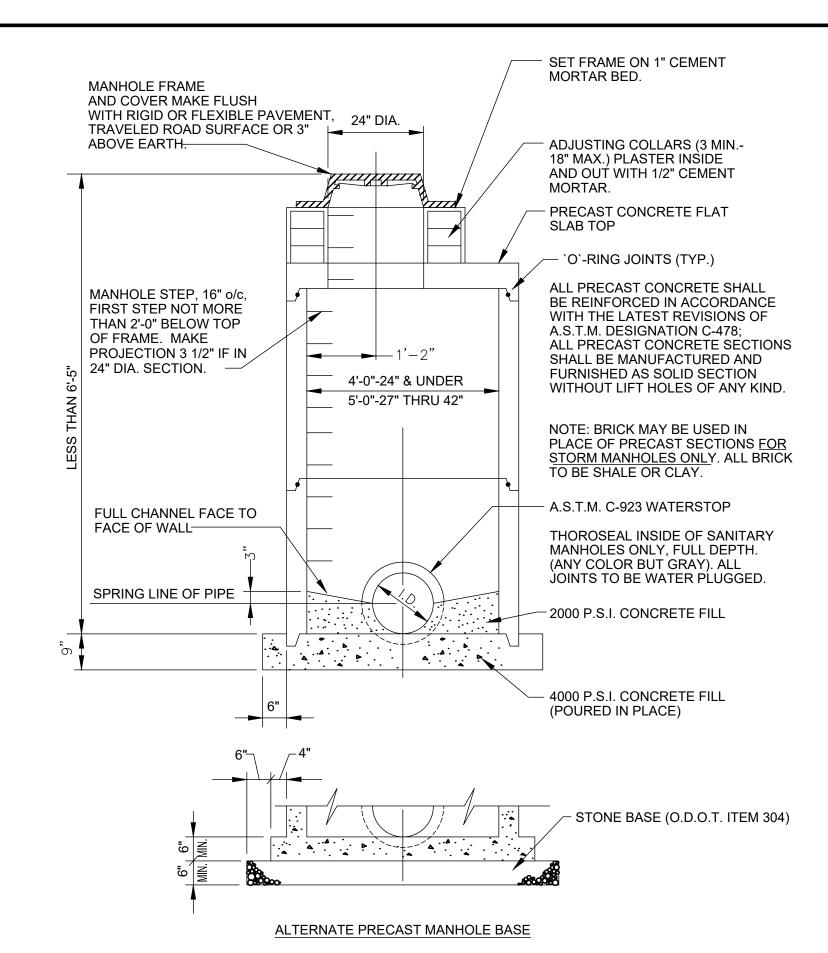

STANDARD SHALLOW PRECAST MANHOLE

1. IN CASES WHERE MANHOLES ARE SHALLOW AND MINIMUM COVER

TYPICAL MANHOLE FORCE MAIN CONNECTION

NOT TO SCALE

CANNOT BE ACHIEVED. CONTRACTOR TO COORDINATE WITH ENGINEER.

FORCE MAIN TO HAVE A

MINIMUM OF 48" COVER —

COUPLING TO BE PLACED

OUTSIDE OF MANHOLE.-

STAINLESS STEEL CLAMP

& C-497 (SEE NOTES). TYPE I = 10" MIN. TREAD WIDTH (SEE NOTES) TYPE II = 14" MIN. TREAD WIDTH (SEE NOTES) - COPOLYMER POLYPROPYLENE PLASTIC 1/2", GRADE 60 REINFORCEMENT PER ASTM A-615 — PER ASTM D-4101 SECTION A - A USE TYPE I STEP FOR MANHOLES OR CIRCULAR STRUCTURES OF 5'-0" DIA. OR LESS - USE 16" C/C SPACING. USE TYPE II STEP FOR FLAT WALL STRUCTURES SUCH AS VAULTS, WELLS, ETC. OR CIRCULAR STRUCTURES OVER 5'-0" DIA. -USE 12" C/C SPACING. MOUNTING REQUIREMENTS SHALL BE IN ACCORDANCE WITH MFR'S RECOMMENDATIONS. **TYPICAL MANHOLE STEP DETAIL**


NOT TO SCALE

PRESS FIT EMBEDMENT

CONFORM TO ASTM C-478

EXISTING MANHOLE NOTE: FORCE MAIN AND FITTINGS TO MANHOLE TO BE CORE DRILLED FORCE MAIN SHALL BE SECURED BE OF LIKE MATERIAL IN PLACE WITH A MANHOLE BOOT --INSIDE DROP CONNECTOR "RELINER-DURAN 'A' DROP TEE **BOWL" OR APPROVED EQUAL-**THREADED PLUG APPROVED RESILIENT PIPE INLET TO MANHOLE CONNECTOR EX MANHOLE OR GASKET 1-1/2" WIDE--FLEXIBLE PIPE | SCH. 80 PVC SHELF COUPLER (TYP.) AND WALL HANGER, 24" O.C. (TYP) 45° BEND 1-1/2" WIDE STAINLESS STEEL PIPE (DIRECTED AT STRAPS ANCHORED IN CONCRETE WALL AT 4' MAX. SPACING WITH MH DISCHARGE) MIN. OF 2 PER PIPE JOINT.-EX SANITARY\ SEWER **PLAN VIEW** 90° LONG RADIUS BEND, ALIGNED WITH DIRECTION OF 4 4 4 4 4 4 4 MANHOLE FLOW CHANNEL-**SECTION VIEW**

STANDARD DROP MANHOLE - INTERIOR DROP DETAIL (EXISTING MANHOLE)

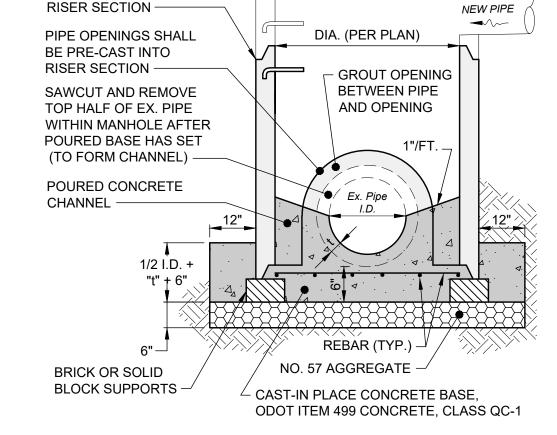

PRECAST MANHOLE

- 1. USE #4 REBAR AT 18" O.C. EACH WAY FOR MANHOLE DEPTH LESS THAN 14', AND USE #5 REBAR FOR MANHOLE DEPTHS GREATER THAN 14'.
- 2. IF NOT PREFORMED, THE PIPE OPENING IN THE PRECAST RISER SECTION MUST BE FULL DEPTH SAW CUT. THE CONTRACTOR SHALL NOT USE A JACKHAMMER OR SLEDGEHAMMER TO CREATE THE OPENING.


DOGHOUSE MANHOLE DETAIL SCALE: NONE

	STRUCTURE TABLE								
NO.	DESCRIPTION	REFERENCE ALIGNMENT	STA (RDWY)	OFFSET (RDWY)	NORTHING (PER PLAN)	EASTING (PER PLAN)	NORTHING (ASBUILT)	EASTING (ASBUILT)	COMMENTS
Structure - (60)	MANHOLE - INTERSEPT TO WET WELL	P.S. CONNECTION TO INDIAN LAKE F.M.	0+42.50	0.00	711162.44	2231336.77			DOGHOUSE MANHOLE
Structure - 1	SANITARY M.H.	LUCASBURG	0+00.00	0.00	712894.62	2231640.61			
Structure - 2	SANITARY M.H.	LUCASBURG	3+55.00	0.00	712882.44	2231995.40			
Structure - 3	SANITARY M.H.	LUCASBURG	7+10.00	0.00	712870.27	2232350.19			
Structure - 4	SANITARY M.H.	LUCASBURG	10+36.00	0.00	712859.08	2232676.00			
Structure - 5	EXISTING SANITARY M.H.	LUCASBURG	11+21.86	0.00	712773.24	2232675.19			VERIFY ALL INVERTS AND PROVIDE AS-BUILT LOCATION FOR RIM

TE OF ON ROBERT McNUTT E-58308

PROJECT NO. 241455 DISCIPLINE

DETAILS SHEET NAME **SD-C-03**

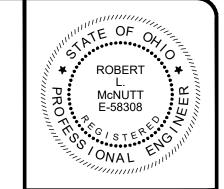

erdanta

8150 STERLING COURT MENTOR, OHIO 44060 (440) 951-9000

 REVIEW
 NO
 REVISION
 DATE

 8/29/25
 AS NOTED
 AS NOTED

NG HILLS WWTP ABANDONEME
SUERNSEY COUNTY, OHIO
ARD DETAILS - SD SERIES


PROJECT NO.

241455
DISCIPLINE
DETAILS
SHEET NAME


SD-C-04

SHEET OF


22 23

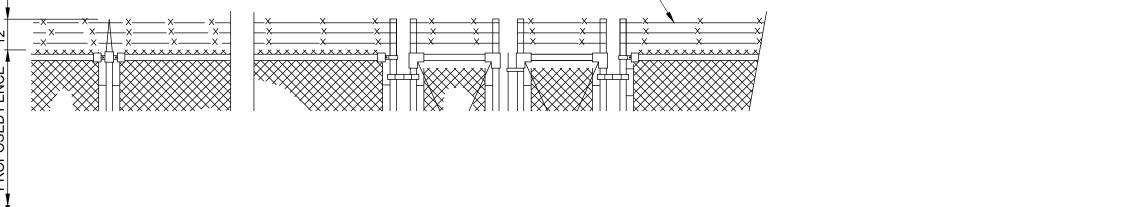


6 - STRANDS OF BARBED WIRE -

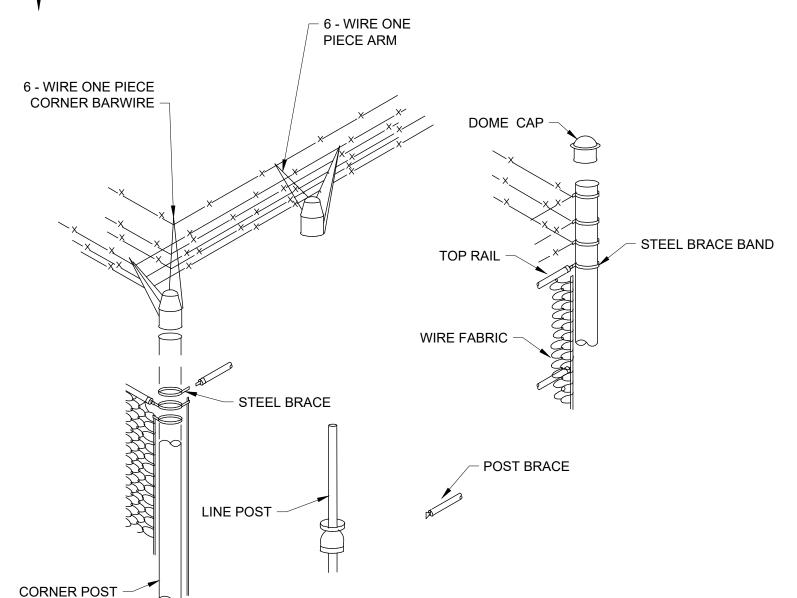

6 TYPCIAL BARBED WIRE DETAIL
20G-03 NOT TO SCALE

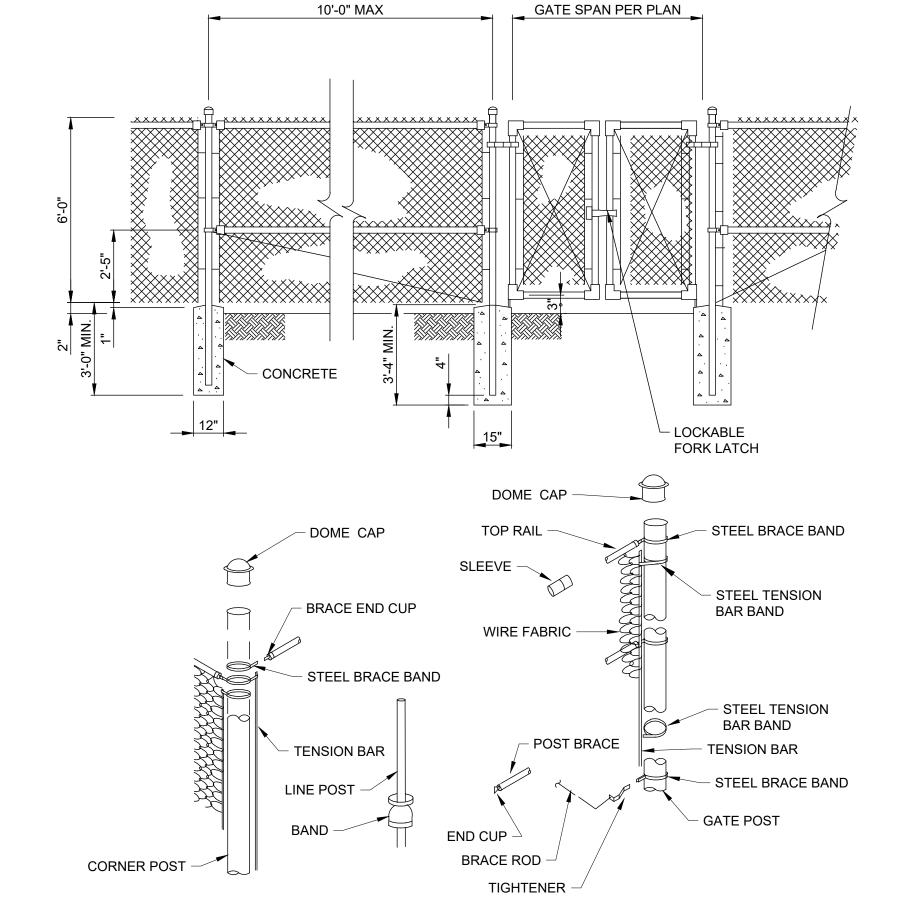

7 TYPICAL FENCE ASSEMBLY DETAIL
20G-03 NOT TO SCALE

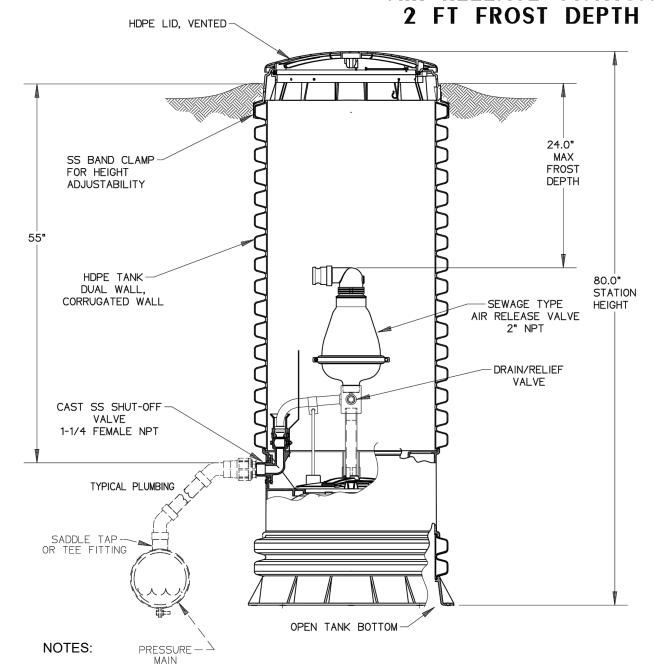


AIR RELEASE STATION

- DIMENSIONS PROVIDED ARE APPROXIMATE AND SHALL BE FIELD VERIFIED.
- 2. MAY NEED CONCRETE VAULT W/ H-20 LOADING.


AIR RELEASE STATION AT INDIAN LAKE ROAD STA. 6+86


NOT TO SCALE

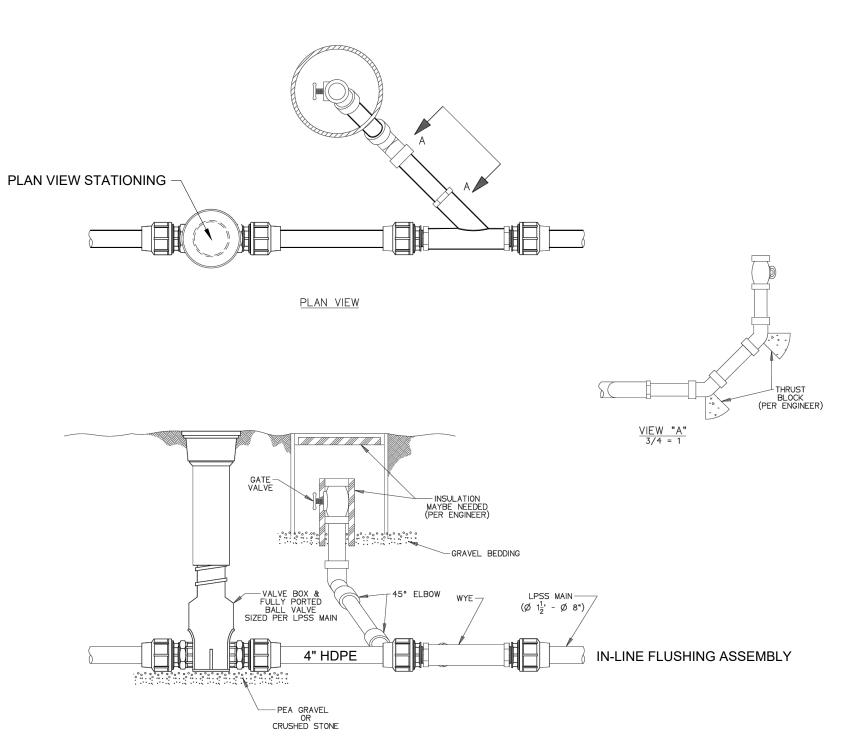



TYPICAL FLUSHING CONNECTION ON LPSS MAIN

NOT TO SCALE

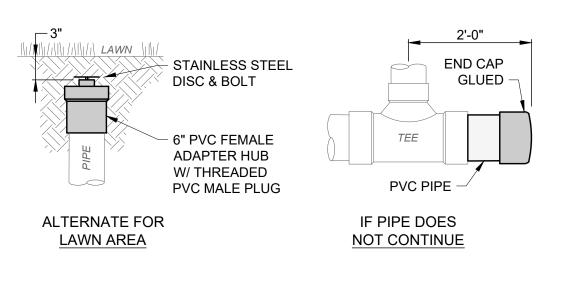

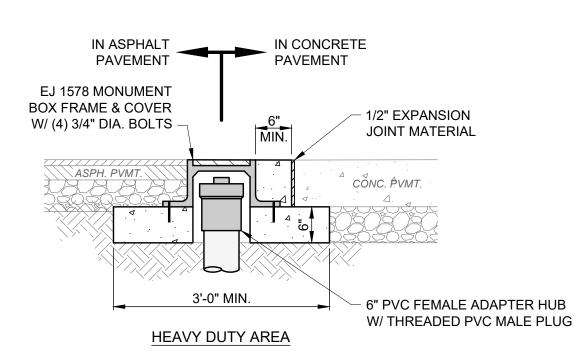

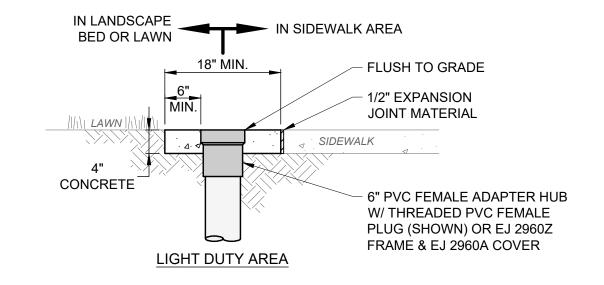

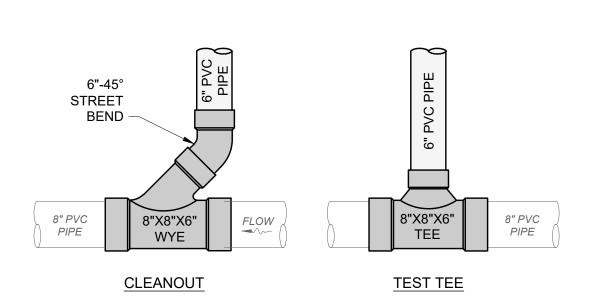

NOTES:

- 1. CONCRETE SHALL BE ODOT ITEM 499, CLASS QC-1.
- THIS DETAIL SHOWS A 6" CLEANOUT AND TEST TEE FOR REFERENCE ONLY. USE 4" CLEANOUT OR TEST TEE FOR 4" PIPE; 6" CLEANOUT OR TEST TEE FOR 6" PIPE AND LARGER; OR AS PER PLAN. NOT ALL ITEMS SHOWN MAY APPLY.

STORM & SANITARY
CLEANOUT & TEST TEE DETAIL
SCALE: NONE

GENERAL NOTES TO CONTRACTOR:

- 1. ALL MATERIALS DISPOSED OF OFF-SITE MUST BE DISPOSED OF IN AN ENVIRONMENTALLY SOUND FASHION. DISPOSING OF DEBRIS ON PRIVATE PROPERTY AND/OR ON AN UNAPPROVED LANDFILL IS NOT ACCEPTABLE.
- 2. PROVIDE SOIL EROSION BARRIERS AS REQUIRED FOR CONSTRUCTION, AS SPECIFIED AND AS DETAILED IN THESE PLANS.
- 3. ALL DEWATERING FLOWS ARE TO BE KEPT FREE OF SILT, SEDIMENT, DEBRIS AND OTHER POLLUTANTS THROUGH APPROPRIATE MEANS (SETTLING BASINS, FILTERS, ETC.). SEE ENVIRONMENTAL GUIDELINES AND REQUIREMENTS FOR ADDITIONAL STORAGE, TESTING, AND DISPOSAL REQUIREMENTS PRIOR TO DISCHARGING/RELEASING DEWATERING FLOWS.
- 4. ONLY WATER WILL BE USED FOR DUST CONTROL. NO SEPARATE PAYMENT WILL BE MADE.

GENERAL EROSION AND SEDIMENT CONTROL NOTES:

- 1. EROSION CONTROL SHALL CONSIST OF TEMPORARY CONTROL MEASURES AS DETAILED ON THE PLANS OR ORDERED BY THE GOVERNING AGENCY DURING THE LIFE OF THE CONTRACT TO CONTROL SOIL EROSION AND SEDIMENTATION THROUGH USE OF EROSION CONTROL BEST MANAGEMENT PRACTICES (BMP'S).
- 2. TEMPORARY EROSION AND SEDIMENT CONTROL ITEMS, THE LOCATION AND SIZE OF WHICH ARE DETAILED ON THE PLANS, SHALL BE INSTALLED BY THE CONTRACTOR PRIOR TO COMMENCEMENT OF ANY CLEARING OR EARTHWORK OPERATIONS. CONDITIONS THAT DEVELOP DURING CONSTRUCTION THAT WERE NOT FORESEEN DURING DESIGN STAGE THAT REQUIRE ADDITIONAL OR MODIFIED TEMPORARY OR PERMANENT BMP'S SHALL BE APPROVED BY THE ENGINEER.
- 3. SEDIMENT PONDS, SEDIMENT TRAPS, AND PERIMETER SEDIMENT CONTROLS SHALL BE IMPLEMENTED AS THE FIRST STEP OF GRADING. THEY SHALL CONTINUE TO FUNCTION UNTIL DISTURBED AREAS ARE RE-ESTABLISHED. NO SEDIMENT CONTROLS SHALL BE PLACED IN A STREAM.
- 4. TRENCH DEWATERING OR DEWATERING GROUND WATER WHICH CONTAINS SEDIMENT SHALL PASS THROUGH AN EFFECTIVE SEDIMENT CONTROL DEVICE. THIS MAY INCLUDE DEWATERING INTO SUMP PIT, FILTER BAG, OR EXISTING VEGETATED UPSLOPE AREA. SEDIMENT LADEN WATER SHALL NOT BE DISCHARGED TO STREAMS OR THE STORM SEWER SYSTEM. SEE ENVIRONMENTAL GUIDELINES AND REQUIREMENTS FOR ADDITIONAL STORAGE, TESTING, AND DISPOSAL REQUIREMENTS PRIOR TO DISCHARGING/RELEASING DEWATERING FLOWS.
- 5. CEMENT WASH WATER SHALL NOT BE ALLOWED TO FLOW TO STREAMS, DITCHES, STORM DRAINS, OR ANY OTHER WATER CONVEYANCE. ALL WASH WATER SHALL BE COLLECTED IN AN APPROVED, DESIGNATED CONTAINER PROVIDED BY THE CONTRACTOR, AND PLACED IN THE DESIGNATED LOCATIONS.
- 6. CONTAINERS SHALL BE PROVIDED FOR COLLECTION OF ALL WASTE MATERIAL INCLUDING CONSTRUCTION DEBRIS, TRASH, PETROLEUM PRODUCTS AND ANY HAZARDOUS MATERIALS TO BE USED ON-SITE. ALL WASTE MATERIAL SHALL BE DISPOSED OF AT FACILITIES APPROVED FOR THAT MATERIAL.
- 7. THESE NOTES AND DRAWINGS ARE INTENDED TO SERVE AS BASIC GUIDELINES. ALL EROSION CONTROL PRACTICES SHALL MEET THE STANDARDS AND SPECIFICATIONS OF THE ODNR RAINWATER AND LAND DEVELOPMENT MANUAL.
- 8. ADDITIONAL EROSION CONTROL BMP'S MAY BE MANDATED BY THE GOVERNING AGENCY AT ANY TIME DURING THIS PROJECT AS UNFORESEEN SITUATIONS MAY ARISE THAT WARRANT FURTHER EROSION AND SEDIMENT CONTROL PRACTICES.

PROHIBITED CONSTRUCTION ACTIVITIES:

THE CONTRACTOR SHALL NOT USE CONSTRUCTION METHODS, ACTIVITIES, OR OPERATIONS THAT MAY NEGATIVELY IMPACT THE NATURAL ENVIRONMENT OR THE PUBLIC HEALTH AND SAFETY. PROHIBITED CONSTRUCTION METHODS, ACTIVITIES, OR OPERATIONS INCLUDE BUT ARE NOT LIMITED TO:

- 1. DISPOSING OF EXCESS OR UNSUITABLE EXCAVATED MATERIAL IN WETLANDS OR FLOOD PLAINS, EVEN WITH THE PERMISSION OF THE PROPERTY OWNER.
- 2. INDISCRIMINATE, ARBITRARY, OR CAPRICIOUS OPERATION OF EQUIPMENT IN ANY STREAM CORRIDORS, ANY WETLANDS, ANY SURFACE WATERS, OR OUTSIDE THE EASEMENT LIMITS.
- 3. PUMPING OF SEDIMENT-LADEN WATER FROM TRENCHES OR OTHER EXCAVATIONS INTO ANY SURFACE WATERS, ANY STREAM CORRIDORS, ANY WETLANDS, OR STORM SEWERS.
- 4. DISCHARGING POLLUTANTS SUCH AS CHEMICALS, FUELS, LUBRICANTS, BITUMINOUS MATERIALS, RAW SEWAGE AND OTHER HARMFUL WASTE INTO OR ALONGSIDE RIVERS, STREAMS, IMPOUNDMENTS OR INTO NATURAL OR MAN-MADE CHANNELS LEADING THERETO.
- 5. PERMANENT OR UNSPECIFIED ALTERATION OF THE FLOW LINE OF A STREAM.
- 6. REMOVAL OF TREES AND BUSHES, OR DAMAGING VEGETATION OUTSIDE THE LIMITS OF THE CONSTRUCTION AREA.
- 7. DISPOSAL OF TREES, BRUSH AND OTHER DEBRIS IN ANY STREAM CORRIDORS, ANY WETLANDS, ANY SURFACE WATERS, OR AT UNSPECIFIED LOCATIONS.
- 8. STORING CONSTRUCTION EQUIPMENT AND VEHICLES AND/OR STOCKPILING CONSTRUCTION MATERIALS ON PROPERTY, PUBLIC OR PRIVATE, NOT PREVIOUSLY SPECIFIED BY THE ENGINEER FOR SAID PURPOSES.

EROSION/SEDIMENT/DUST CONTROL PRACTICES:

- 1. STOCKPILED TOPSOIL AND EXCAVATED MATERIAL IS TO BE PROTECTED THROUGH THE USE OF TEMPORARY SEEDING OR COVERED WITH ANCHORED STRAW MULCH.
- 2. FINAL GRADING WILL BE CONSISTENT WITH PRE-CONSTRUCTION TOPOGRAPHY TO MAINTAIN DRAINAGE AND AESTHETICS.
- 3. REMOVE ONLY THOSE TREES, SHRUBS, AND GRASSES THAT MUST BE REMOVED TO PERMIT ACTUAL CONSTRUCTION: PROTECT THE REMAINING TO PRESERVE THEIR AESTHETIC AND EROSION CONTROL VALUE.
- 4. DISTURBED LAND SHALL BE TEMPORARILY STABILIZED BY SEEDING AND/OR MULCHING.
- 5. BACKFILL TRENCHES IMMEDIATELY AFTER EXCAVATION. SEED AND MULCH TRENCHES WITHIN TWO WEEKS AFTER TRENCHES ARE BACKFILLED.
- 6. SILT FROM CONSTRUCTION OPERATIONS SHALL NOT BE PERMITTED TO ENTER THE STORM DRAIN SYSTEM. FOR CONSTRUCTION OCCURRING NEAR STORM DRAIN INLETS, EROSION CONTROL MEASURES, SUCH AS SILT FENCES, ROCK CHECKS, SEDIMENT BASINS, ETC., SHALL BE USED TO PREVENT SILT FROM ENTERING THE STORM DRAIN.

CONTAMINATED SOILS:

- 1. IF SUBSTANCES SUCH AS OIL, DIESEL FUEL, HYDRAULIC FLUID, ANTIFREEZE, ETC. ARE SPILLED, LEAKED, OR RELEASED ONTO THE SOIL, THE SOIL SHOULD BE DUG UP AND DISPOSED OF AT LICENSED SANITARY LAND FILL OR OTHER APPROVED PETROLEUM CONTAMINATED SOIL REMEDIATION FACILITY. (NOT A CONTRUCTION/DEMOLITION DEBRIS LANDFILL). NOTE THAT STORM WATER RUN OFF ASSOCIATED WITH CONTAMINATED SOILS ARE NOT AUTHORIZED UNDER OHIO EPA'S GENERAL STORM WATER PERMIT ASSOCIATED WITH CONSTRUCTION ACTIVITIES.
- 2. OPEN BURNING IS NOT ALLOWED.

SPILL CONTROL AND CLEANUP:

- 1. ON-SITE VEHICLES WILL BE MONITORED FOR LEAKS AND RECEIVE REGULAR MAINTENANCE TO REDUCE THE CHANCE OF LEAKAGE. PETROLEUM PRODUCTS WILL BE STORED IN TIGHTLY SEALED CONTAINERS THAT ARE CLEARLY LABELED. PREFERABLY, THE CONTAINERS WILL BE STORED IN A COVERED TRUCK OR TRAILER THAT PROVIDES SECONDARY CONTAINMENT FOR THE PRODUCTS.
- 2. BULK STORAGE TANKS HAVING A CAPACITY OF GREATER THAN 55 GALLONS WILL BE PROVIDED WITH SECONDARY CONTAINMENT.
- 3. PERSONNEL ON-SITE WILL BE MADE AWARE OF CLEANUP PROCEDURES AND THE LOCATION OF SPILL CLEANUP EQUIPMENT.
- 4. ALL SPILLS WILL BE CLEANED UP USING APPROPRIATE ABSORBENT MATERIALS AND EXCAVATION AS NECESSARY. CLEANUP WASTE WILL BE CHARACTERIZED AND DISPOSED OF ACCORDINGLY.

CLEARING AND GRADING:

- 1. LIMITS OF CLEARING AND GRADING SHALL BE CLEARLY MARKED ON SITE WITH SIGNAGE, FLAGGING AND/OR CONSTRUCTION FENCING.
- 2. THE CONTRACTOR SHALL LIMIT THE SURFACE AREA OF ERODIBLE EARTH MATERIAL EXPOSED BY EXCAVATION, BORROW, AND FILL OPERATIONS AND PROVIDE IMMEDIATE PERMANENT OR TEMPORARY CONTROL MEASURES TO PREVENT CONTAMINATION OF ADJACENT STREAMS OR OTHER WATER COURSES, LAKES, PONDS, WETLANDS OR OTHER AREAS OF WATER IMPOUNDMENT.

OFF-SITE TRACKING:

1. CONSTRUCTION ENTRANCES SHALL BE INSTALLED AT ALL INGRESS AND EGRESS LOCATIONS TO ELIMINATE OFF-SITE VEHICLE TRACKING OF SEDIMENTS. SEDIMENTS SHALL BE REMOVED FROM ROADWAYS AT LEAST DAILY, OR MORE OFTEN IF REQUESTED BY THE OWNER.

TEMPORARY SEEDING:

- 1. SEDIMENT CONTROL SHALL BE ACCOMPLISHED BY SEEDING AND STRAW MULCHING ALL DISTURBED AREAS IMMEDIATELY UPON COMPLETION OF EXCAVATION OR FILL AND FINISH GRADING IN ACCORDANCE WITH SPECIFICATIONS OF THE ODNR RAINWATER AND LAND DEVELOPMENT MANUAL.
- 2. ALL DETENTION PONDS, RETENTION PONDS, WATER QUALITY STRUCTURES, SEDIMENT PONDS, SEDIMENT TRAPS, EARTHEN DIVERSIONS OR EMBANKMENTS SHALL BE SEEDED AND STRAW MULCHED WITHIN SEVEN (7) DAYS OF COMPLETED CONSTRUCTION.
- 3. DISTURBED AREAS THAT WILL REMAIN INACTIVE FOR A PERIOD OF TWENTY-ONE (21) DAYS OR LONGER SHALL BE STABILIZED WITH SEEDING AND STRAW MULCHING, OR OTHER APPROPRIATE MEANS, WITHIN SEVEN (7) DAYS AFTER EARTH MOVING CEASES. PERMANENT SOILS STABILIZATION SHALL BE INSTALLED WITHIN SEVEN (7) DAYS AFTER FINAL GRADE IS REACHED ON ANY PORTION OF THE SITE
- 4. STABILIZE AREAS WITHIN FIFTY (50) FEET OF ANY STREAM OR WETLAND WITHIN TWO (2) DAYS ON ALL INACTIVE DISTURBED AREAS THAT WILL REMAIN INACTIVE FOR FOURTEEN (14) DAYS OR LONGER.
- 5. SEEDED AREAS SHALL BE INSPECTED AND WHERE THE SEED HAS NOT PRODUCED 80% COVER SHALL BE RESEEDED AS NECESSARY BY THE CONTRACTOR. AREAS SHALL BE STABILIZED WITH STRAW MULCH WHEN SUB-CONDITIONS PROHIBIT SEEDING.
- 6. STRAW MULCHING SHALL BE APPLIED AT A RATE OF 90 POUNDS PER 1,000 SQ.FT. OF DISTURBED AREA OR TWO (2) TONS PER ACRE. ALL HYDROSEEDING MUST BE WOOD CELLULOSE FIBER AND APPLIED AT 2,000 LBS/AC OR 46 POUNDS PER 1,000 SQ.FT.

PERMANENT SEEDIN

1. PERMANENT SEEDING SHALL BE AS PER SEEDING CHART ON SHEET ESC-2.



dantas

8150 STERLING COURT MENTOR, OHIO 44060

NO REVISION							
REVIEW	8/29/25	AS NOTED	RLM	RLM		RLM	
ISSUED FOR:	ISSUE DATE:	SCALE:	DESIGNED BY:	DRAWN BY:		CHECKED BY:	
VILLAGE OF BYESVILLE		GUERNSEY COUNTY, OHIO	CT NO.	EROSION CONTROL - EC SERIES	* ICCHICCIOCCT	EROSION CONTROL - 1	
241455 DISCIPLINE CIVIL							

EC-01


SEEDING DATES	SPECIES	LB./1000 FT2	LB/ACRE
MARCH 1 TO AUGUST 15	OATS	3	128 (4 BUSHEL)
	TALL FESCUE	1	40
	ANNUAL RYEGRASS	1	40
	PERENNIAL RYEGRASS	1	40
	TALL FESCUE	1	40
	ANNUAL RYEGRASS	1	40
	ANNUAL RYEGRASS PERENNIAL RYEGRASS CREEPING RED FESCUE KENTUCKY BLUEGRASS	1.25 3.25 0.4 0.4	55 142 17 17
	OATS	3	128 (3 BUSHEL)
	TALL FESCUE	1	40
	ANNUAL RYEGRASS	1	40
AUGUST 16TH TO NOVEMBER	RYE	3	112 (2 BUSHEL)
	TALL FESCUE	1	40
	ANNUAL RYEGRASS	1	40
	WHEAT	3	120 (2 BUSHEL)
	TALL FESCUE	1	40
	ANNUAL RYEGRASS	1	40
	PERENNIAL RYE	1	40
	TALL FESCUE	1	40
	ANNUAL RYEGRASS	1	40
	ANNUAL RYEGRASS PERENNIAL RYEGRASS CREEPING RED FESCUE KENTUCKY BLUEGRASS	1.25 3.25 0.4 0.4	40 40 40

NOVEMBER 1 TO FEB. 29 USE MULCH ONLY OR DORMANT SEEDING NOTE: OTHER APPROVED SPECIES MAY BE SUBSTITUTED.

TEMPORARY SEEDING CHART

		SEEDING RATE					
	LBS./ACRE	LBS./1,000 SQ. FEET	Notes:				
		GENERAL USE					
CREEPING RED FESCUE DOMESTIC RYEGRASS KENTUCKY BLUEGRASS	20-40 10-20 20-40	1/2-1 1/4-1/2 1/2-1	FOR CLOSE MOWING & FOR WATERWAYS WITH < 2.0 FT/SEC VELOCITY				
TALL FESCUE TURF-TYPE (DWARF) FESCUE	40-50 90	1–1 1/4 2 1/4					
		STEEP BANKS OR CUT SLOP	PES				
TALL FESCUE	40-50	1-1 1/4					
CROWN VETCH TALL FESCUE	10-20 20-30	1/4-1/2 1/2-3/4	DO NOT SEED LATER THAN AUGUST				
FLAT PEA TALL FESCUE	20-25 20-30	1/2-3/4 1/2-3/4	DO NOT SEED LATER THAN AUGUST				
	ROAD DITCHES AND SWALES						
TALL FESCUE	40-50	1-11/4					
TURF-TYPE (DWARF) FESCUE KENTUCKY BLUEGRASS	90 5	2 1/4 0.1					
		LAWNS					
KENTUCKY BLUEGRASS PERENNIAL RYEGRASS	100-120	2 2					
KENTUCKY BLUEGRASS CREEPING RED FESCUE	100-120	2 1-1/2	FOR SHADED AREAS				
NOTE: OTHER APPROVED SEED SPECIES MAY BE SUBSTITUTED.							

PERMANENT SEEDING CHART

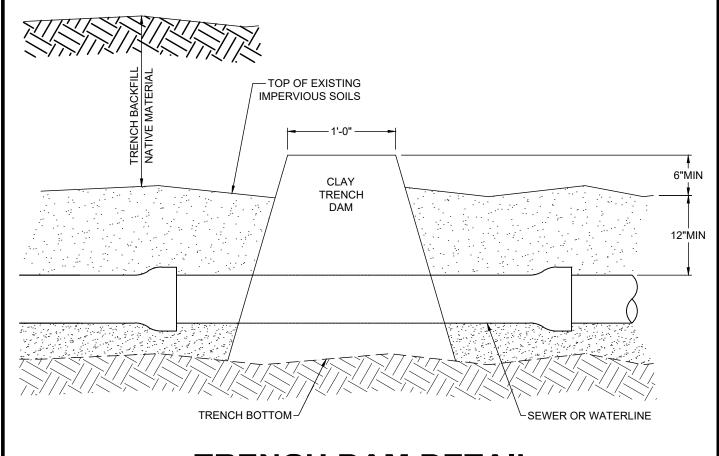


TRENCH DAM DETAIL

NOT TO SCALE


NOTES:

- GEOTEXTILE SHALL HAVE AN EQUIVALENT OPENING OF 20-40 SIEVE AND BE RESISTANT TO SUNLIGHT
- MAINTENANCE: REMOVE ALL ACCUMULATED SEDIMENT AND DEBRIS FROM SURFACE AND VICINITY OF UNIT AFTER EACH STORM EVENT. REMOVE SEDIMENT THAT HAS ACCUMULATED WITHIN THE CONTAINMENT AREA OF THE SILT BARRIER AS NEEDED.
- TO INSTALL CATCH BASIN INLET SILT BARRIER: THE EMPTY SILT BARRIER SHOULD BE PLACED OVER THE GRATE AS THE GRATE STANDS ON END. TUCK THE ENCLOSURE FLAP INSIDE TO COMPLETELY ENCLOSE THE GRATE. HOLDING THE LIFTING DEVICES (DO NOT RELY ON LIFTING DEVICES TO SUPPORT THE ENTIRE WEIGHT OF THE GRATE). PLACE THE GRATE INTO ITS FRAME.

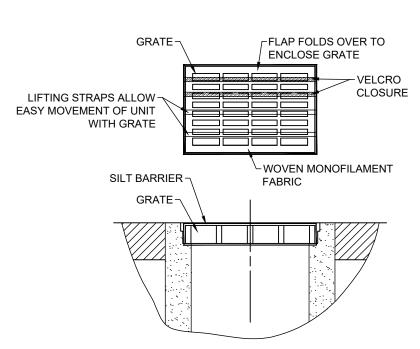

INLET PROTECTION FOR CATCH BASIN IN ROADWAY

NOT TO SCALE

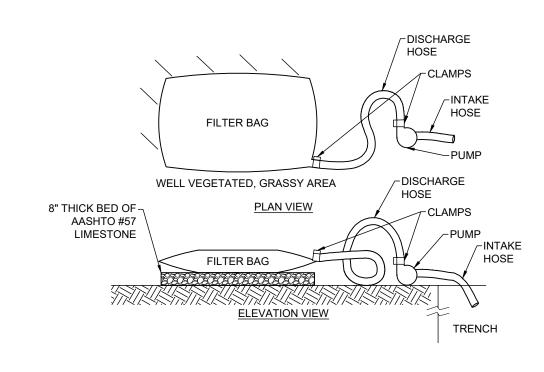

- 1. USE FILTER BAGS MADE FROM NON-WOVEN GEOTEXTILE MATERIAL SEWN WITH HIGH STRENGTH, DOUBLE STITCHED "J" TYPE SEAMS, CAPABLE OF TRAPPING PARTICLES LARGER THAN 150 MICRONS.
- 2. A SUITABLE MEANS OF ACCESSING THE BAG WITH MACHINERY REQUIRED FOR DISPOSAL PURPOSES MUST BE PROVIDED. REPLACE FILTER BAGS WHEN THEY BECOME 1/2 FULL. KEEP SPARE BAGS AVAILABLE FOR REPLACEMENT OF THOSE THAT
- HAVE FAILED OR ARE FILLED. 3. PLACE BAGS IN WELL-VEGETATED (GRASSY) AREAS, AND DISCHARGE ONTO STABLE, EROSION RESISTANT AREAS. WHERE
- THIS IS NOT POSSIBLE, PROVIDE A GEOTEXTILE FLOW PATH. DO NOT PLACE BAGS ON SLOPES GREATER THAN 5%. 4. INSERT PUMP DISCHARGE HOSE INTO THE BAGS IN THE MANNER SPECIFIED BY THE MANUFACTURER AND SECURELY
- 5. THE PUMPING RATE SHOULD BE NO GREATER THAN 750 GPM OR 1/2 THE MAXIMUM SPECIFIED BY THE MANUFACTURER,


WHICHEVER IS LESS. PUMP INTAKES SHOULD BE FLOATING AND SCREENED.

6. INSPECT FILTER BAGS DAILY. IF ANY PROBLEM IS DETECTED, CEASE PUMPING IMMEDIATELY AND DO NOT RESUME UNTIL THE

PROBLEM IS CORRECTED.

PUMPED WATER FILTER BAG DETAIL

NOT TO SCALE

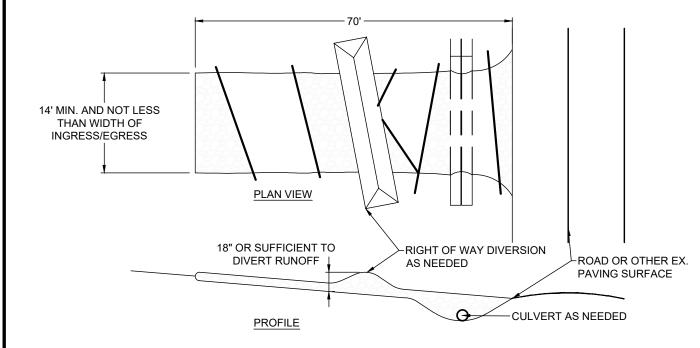


- 1. STONE SIZE ODOT #2 (1.5 2.5 INCH) STONE SHALL BE USED, OR RECYCLED CONCRETE EQUIVALENT.
- LENGTH THE CONSTRUCTION ENTRANCE SHALL BE AS LONG AS REQUIRED TO STABILIZE HIGH TRAFFIC AREAS BUT NOT LESS THAN 70 FEET (EXCEPTION: APPLY 30 FEET MINIMUM TO SINGLE RESIDENCE LOTS).
- THICKNESS THE STONE LAYER SHALL BE AT LEAST 6 INCHES THICK FOR LIGHT DUTY ENTRANCES OR AT LEAST 10 INCHES FOR HEAVY DUTY USE.
- WIDTH THE ENTRANCE SHALL BE AT LEAST 14 FEET WIDE, BUT NOT LESS THAN THE FULL WIDTH AT POINTS WHERE
- GEOTEXTILE A GEOTEXTILE SHALL BE LAID OVER THE ENTIRE AREA PRIOR TO PLACING STONE. IT SHALL BE COMPOSED OF STRONG ROT-ROOF POLYMERIC FIBERS AND MEET THE FOLLOWING SPECIFICATIONS:

GEOTEXTILE SPECIFICATION FOR CONS	TRUCTION ENTRANCE
MINIMUM TENSILE STRENGTH	200 LBS
MINIMUM PUNCTURE STRENGTH	80 PSI
MINIMUM TEAR STRENGTH	50 LBS
MINIMUM BURST STRENGTH	320 PSI
MINIMUM ELONGATION	20%
EQUIVALENT OPENING SIZE	EOS < 0.6 mm
PERMITTIVITY	1x10-3 cm/sec

- TIMING THE CONSTRUCTION ENTRANCE SHALL BE INSTALLED AS SOON AS IS PRACTICABLE BEFORE MAJOR GRADING
- CULVERT A PIPE OR CULVERT SHALL BE CONSTRUCTED UNDER THE ENTRANCE IF NEEDED TO PREVENT SURFACE WATER FROM FLOWING ACROSS THE ENTRANCE OR TO PREVENT RUNOFF FROM BEING DIRECTED OUT ONTO PAVED
- WATER BAR A WATER BAR SHALL BE CONSTRUCTED AS PART OF THE CONSTRUCTION ENTRANCE IF NEEDED TO PREVENT SURFACE RUNOFF FROM FLOWING THE LENGTH OF THE CONSTRUCTION ENTRANCES AND OUT ONTO PAVED
- MAINTENANCE TOP DRESSING OF ADDITIONAL STONE SHALL BE APPLIED AS CONDITIONS DEMAND. MUD SPILLED, DROPPED, WASHED OR TRACKED ONTO PUBLIC ROADS, OR ANY SURFACE WHERE RUNOFF IS NOT CHECKED BY SEDIMENT CONTROLS, SHALL BE REMOVED IMMEDIATELY. REMOVAL SHALL BE ACCOMPLISHED BY SCRAPING OR
- 10. CONSTRUCTION ENTRANCES SHALL NOT BE RELIED UPON TO REMOVE MUD FROM VEHICLES AND PREVENT OFF-SITE TRACKING. VEHICLES THAT ENTER AND LEAVE THE CONSTRUCTION SITE SHALL BE RESTRICTED FROM MUDDY AREAS.
- 1. REMOVAL THE ENTRANCE SHALL REMAIN IN PLACE UNTIL THE DISTURBED AREA IS STABILIZED OR REPLACED WITH A PERMANENT ROADWAY OR ENTRANCE.


CONSTRUCTION ENTRANCE

NOT TO SCALE

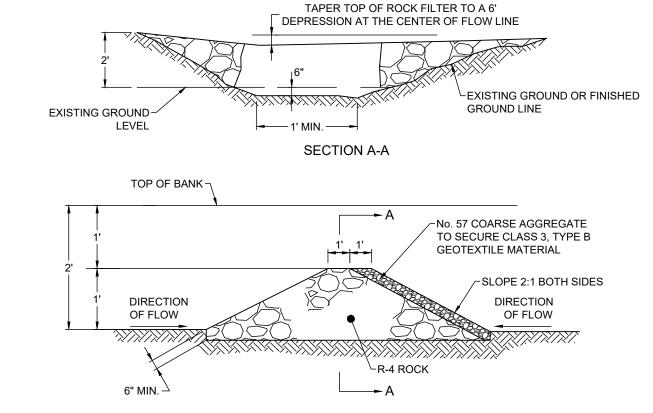

ROCK FILTER DETAIL

NOT TO SCALE

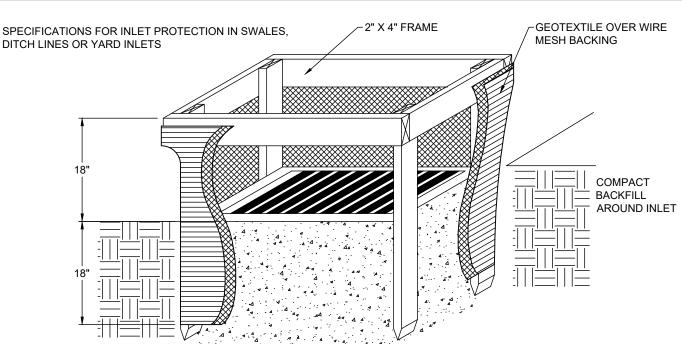


SPECIFICATIONS FOR INLET PROTECTION IN SWALES, DITCH LINES OR YARD INLETS

- INLET PROTECTION SHALL BE CONSTRUCTED EITHER BEFORE UPSLOPE LAND DISTURBANCE BEGINS OR BEFORE THE STORM
- THE EARTH AROUND THE INLET SHALL BE EXCAVATED COMPLETELY TO A DEPTH AT LEAST 18 INCHES.
- THE WOODEN FRAME SHALL BE CONSTRUCTED OF 2-BY-4-INCH CONSTRUCTION-GRADE LUMBER. THE 2-BY-4-INCH POSTS SHALL BE DRIVEN 1 FOOT INTO THE GROUND AT FOUR CORNERS OF THE INLET AND THE TOP PORTION OF 2-BY-4-INCH FRAME ASSEMBLED USING THE OVERLAP JOINT SHOWN. THE TOP OF THE FRAME SHALL BE AT LEAST 6 INCHES BELOW ADJACENT ROADS IF PONDED WATER WOULD POSE A SAFETY HAZARD TO TRAFFIC.
- WIRE MESH SHALL BE OF SUFFICIENT STRENGTH TO SUPPORT FABRIC WITH WATER FULLY IMPOUNDED AGAINST IT. IT SHALL BE STRETCHED TIGHTLY AROUND THE FRAME AND FASTENED SECURELY TO THE FRAME.
- GEOTEXTILE SHALL HAVE AN EQUIVALENT OPENING SIZE OF 20-40 SIEVE AND BE RESISTANT TO SUNLIGHT. IT SHALL BE STRETCHED TIGHTLY AROUND THE FRAME AND FASTENED SECURELY. IT SHALL EXTEND FROM THE TOP OF THE FRAME TO 18 INCHES BELOW THE INLET NOTCH ELEVATION. THE GEOTEXTILE SHALL OVERLAP ACROSS ONE SIDE OF THE INLET SO THE ENDS OF THE CLOTH ARE NOT FASTENED TO THE SAME POST.
- BACKFILL SHALL BE PLACED AROUND THE INLET IN COMPACTED 6 INCH LAYERS UNTIL THE EARTH IS EVEN WITH NOTCH ELEVATION ON ENDS AND TOP ELEVATION ON SIDES.
- A COMPACTED EARTH DIKE OR A CHECK DAM SHALL BE CONSTRUCTED IN THE DITCH LINE BELOW THE INLET IF THE INLET IS NOT IN A DEPRESSION AND IF RUNOFF BYPASSING THE INLET WILL NOT FLOW TO A SETTLING POND. THE TOP OF EARTH DIKES SHALL BE AT LEAST 6 INCHES HIGHER THAN THE TOP OF THE FRAME.


INLET PROTECTION

NOT TO SCALE

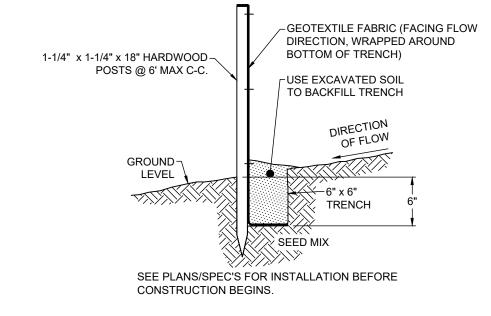


SILT FENCE DETAIL

NOT TO SCALE

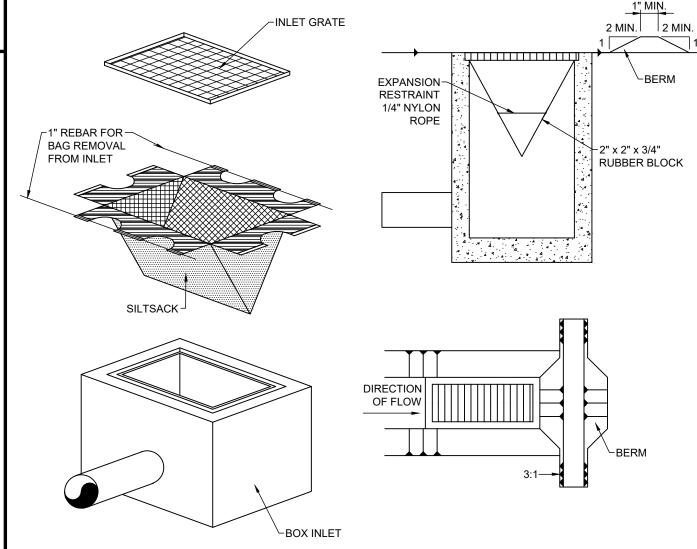

- 1. MAXIMUM DRAINAGE AREA =1/2 ACRE.
- 2. INLET PROTECTION IS NOT REQUIRED FOR INLET TRIBUTARY TO SEDIMENT BASIN OR TRAP.
- 3. BERMS REQUIRED FOR ALL INSTALLATIONS.
- 3.1. EARTHEN BERM IN ROADWAY SHALL BE MAINTAINED UNTIL ROADWAY IS STONED.
- 3.2. ROAD SUBBASE BERM ON ROADWAY SHALL BE MAINTAINED UNTIL ROADWAY IS PAVED.
- 3.3. EARTHEN BERM IN CHANNEL SHALL BE MAINTAINED UNTIL PERMANENT STABILIZATION IS COMPLETED OR TO REMAIN PERMANENTLY.

SILT SACK DETAIL

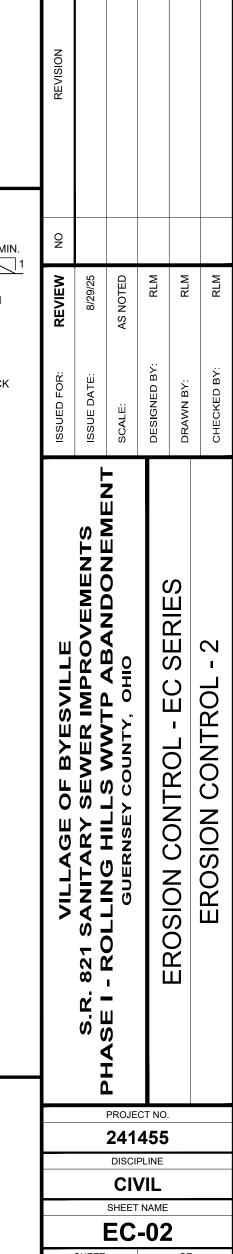

ROBERT

McNUTT

E-58308

H:\2024\241455\DWG\SHEETS\EC_241455 - EROSION CONTROL.DWG - 21 EROSION CONTROL - 2 - 8/28/2025 4:21:22 PM - BOB MARANO